

1

2

3

4

5

6

7

8

9

10

11

12

13

PLAN SYMBOLS

COMM

COMMUNICATION REINFORCED CONCRETE ENCASED DUCTBANK

UE

ELECTRICAL REINFORCED CONCRETE ENCASED DUCTBANK

ELECTRICAL DIRECT BURIED CONDUITS/DUCTBANK

ELECTRICAL EXPOSED CONDUIT

LP1-3

HOMERUN TO PANEL "LP1". "3" IS THE CIRCUIT NO.

LIQUIDTIGHT FLEXIBLE CONDUIT

EXPLOSION-PROOF FLEXIBLE METAL CONDUIT

CONDUIT OR CIRCUIT CONTINUED ON ANOTHER PLAN OR VIEW

STUBBED AND CAPPED CONDUIT

CONDUIT TURNED DOWN

CONDUIT TURNED UP

MAIN AND DOWN CONDUCTORS

LP

EXPOSED LIGHTNING PROTECTION MAIN SIZE GROUNDING CONDUCTOR. #2 COPPER

GROUND COUNTERPOISE #4/0 BARE CU (BELOW GRADE)

G

#2/0 BARE CU (ABOVE GRADE)

GROUNDING CONNECTION, EXOTHERMIC WELD

GROUNDING CONNECTION, BOLTED

GROUND TEST WELL

GROUND ROD

AIR TERMINAL

GROUND REEL

GROUND BUS BAR

MH-###
T3

ELECTRICAL MANHOLE, T3 = TYPE 3

CHH-##
T3

COMMUNICATIONS HANDHOLE, T3 = TYPE 3

L1

POLE MOUNTED LUMINAIRE, WITH LETTER INDICATING FIXTURE TYPE (SEE SHEET E-510 FOR FIXTURE SCHEDULE FOR HEIGHTS AND ADDITIONAL INFORMATION)

EXPLOSION-PROOF CONDUIT SEAL

EXPLOSION-PROOF CONDUIT UNION

DISCONNECT SWITCH

COMBINATION MOTOR STARTER

HEATER

CR

CARD READER

GC

GATE CONTROLLER

IC

INTERCOM

LD

LOOP DETECTOR

GM

GATE MOTOR

FIXED CAMERA

360° MULTI-SENSOR CAMERA

ACS

ACCESS CONTROL SYSTEM

ICM

INTERCOM MASTER

SECTION AND DETAIL IDENTIFICATION

NUMBER INDICATES DETAIL/ELEVATION/PHOTO DESIGNATION. LETTER INDICATES SECTION DESIGNATION.

DETAIL/SECTION/ELEVATION

SECTION, DETAIL, AND ELEVATION TITLE

NOT TO SCALE (OR PLACE SCALE BAR HERE)

DRAWING NUMBER WHERE DETAIL/ELEVATION/PHOTO IS SHOWN

NUMBER INDICATES DETAIL DESIGNATION

SHEET NUMBER WHERE DETAIL IS SHOWN

NUMBER INDICATES DETAIL DESIGNATION

SHEET NUMBER WHERE DETAIL IS SHOWN

NUMBER INDICATES DETAIL DESIGNATION

SHEET NUMBER WHERE DETAIL IS SHOWN

DIAGRAM SYMBOLS

GROUND CONNECTION

(A)CONTACT-NORMALLY OPEN
(B)CONTACT-NORMALLY CLOSED

CONTACTOR

DISCONNECT SWITCH

CONNECTION

SOLENOID VALVE COIL

100AT (BREAKER TRIP FRAME RATING AS INDICATED) 100AF (BREAKER FRAME RATING AS INDICATED) 3P (# OF PHASES AS INDICATED) LSIG (BREAKER TRIP TYPES, LONG TIME, SHORT TIME, INSTANTANEOUS, AND GROUND AS INDICATED) COMBINATION MOTOR CIRCUIT PROTECTOR, NON-REVERSING FULL VOLTAGE STARTER WITH CONTROL POWER TRANSFORMER (TYPE AND NEMA SIZE AS INDICATED), AND OVERLOAD

TRANSFORMER, DELTA-GROUNDED WYE, 3 PHASE 15 KVA, (SIZE AS INDICATED) 480-208Y/120V (PRIMARY VOLTAGE / SECONDARY VOLTAGE AS INDICATED)

HEATER

DASHED LINE INDICATES WIRING REMOTE FROM DEVICE. WIRE COLOR DESIGNATION: B-BLACK, R-RED, BL-BLUE, ETC. SOLID LINE INDICATES CIRCUITRY WITHIN THE DEVICE.

MOTOR (HP SIZE AS INDICATED)

CIRCUIT BREAKER

RELAY, CONTACT (NORMALLY OPEN)

PUSHBUTTON, MOMENTARY, NORMALLY OPEN, NORMALLY CLOSED

EXPULSION FUSE

FUSE

TEMPERATURE SWITCH

INDICATING LIGHTS, RED, GREEN

OVERLOAD

LEVEL SWITCH, NORMALLY CLOSED, OPENS ON RISING LEVEL

LEVEL SWITCH, NORMALLY OPEN, OPENS ON FALLING LEVEL

LIMIT SWITCH, NORMALLY CLOSED

LIMIT SWITCH, NORMALLY OPEN

TIME DELAY RELAY CONTACTS, DELAY ON ENERGIZATION
(A) NORMALLY CLOSED
(B) NORMALLY OPEN
NORMALLY OPEN TIME DELAY RELAY CONTACT, DELAY ON DEENERGIZATION

FLOW SWITCH, NORMALLY OPEN, CLOSED ON DETECTION OF FLOW.

KEYED BYPASS SWITCH

3 POSITION SELECTOR SWITCH:
X REPRESENTS CLOSED AND O REPRESENTS OPEN IN VARIOUS SWITCH POSITIONS

ENCLOSURE

DRAWOUT CONNECTION

LOAD BREAK ELBOW

LIGHTNING ARRESTOR.
NUMBER OF UNITS INDICATED.

TRANSFER SWITCH
AS NOTED

PLC OUTPUT

PLC INPUT

TIME DELAY RELAY

GENERAL NOTES: APPLICABLE TO ALL ELECTRICAL FUELING SHEETS

1. SYMBOL SIZE DOES NOT IMPLY EQUIPMENT SIZE, UON.

2. NOT ALL SYMBOLS SHOWN ON THIS SHEET ARE USED IN THIS PROJECT.

3. ALL JUNCTION BOXES SHALL BE RATED NEMA 4X STAINLESS STEEL WHEN LOCATED OUTDOORS, UON.

4. COORDINATE ALL NEW DUCTBANKS WITH OTHER UTILITIES IN THE AREA.

5. PROVIDE AN INSULATED GREEN EQUIPMENT GROUNDING CONDUCTOR FOR ALL CIRCUITS IN CONDUITS OR RACEWAYS.

6. ALL ELECTRICAL WORK AND MATERIAL IS NEW, AND PROVIDED BY THE ELECTRICAL SUBCONTRACTOR UNLESS NOTED OTHERWISE.

7. ALL DARK LINEWEIGHT IS NEW WORK AND ALL LIGHT LINEWEIGHT IN EXISTING, UON.

8. CONDUIT ROUTING IS SCHEMATIC IN NATURE. ROUTE ALL CONDUIT TO AVOID OBSTRUCTIONS. WHERE CONDUIT IS EXPOSED/ABOVE GRADE, ROUTE CONDUIT TO AVOID TRIPPING HAZARDS AND BLOCKING EQUIPMENT ACCESS. CONDUITS MUST BE SUPPORTED AT INTERVALS NOT EXCEEDING NEC REQUIREMENTS.

9. ALL PRODUCTS SHALL BE LISTED BY A NATIONALLY RECOGNIZED TESTING LABORATORY (NRTL). (E.G. UNDERWRITERS LABORATORIES (UL) OR EQUIVALENT)

ABBREVIATIONS

A

AMPERES (AMP)

AC

ALTERNATING CURRENT

AF

AMPS FRAME

AFF

ABOVE FINISHED FLOOR

AFG

ABOVE FINISHED GRADE

AIC

AMPERE INTERRUPTING CAPACITY

APPROX

APPROXIMATE

AST

ABOVE GROUND STORAGE TANK

AT

AMPS TRIP

ATG

AUTOMATIC TANK GAUGING

C

CONDUIT

CKT

CIRCUIT

COM

COMMUNICATION

CPT

CONTROL POWER TRANSFORMER

CU

COPPER

DB

DUCTBANK

DC

DIRECT CURRENT

DP

DISTRIBUTION PANEL

DPDT

DOUBLE POLE DOUBLE THROW

DS

DISCONNECT SWITCH

DT

DENSITY TRANSMITTER

EFSO

EMERGENCY FUEL SHUTOFF

EHH

ELECTRICAL HANDHOLE

EMH

ELECTRICAL MANHOLE

EOL

END OF LINE

EP

INDICATES EXPLOSION PROOF EQUIPMENT CLASS I, GROUP D HAZARDOUS AREA

FACU

FIRE ALARM CONTROL UNIT

FLA

FULL LOAD AMPS

FO

FIBER OPTIC

FSC

FUEL SYSTEM CONTROL

FSCP

FUEL SYSTEM CONTROL PANEL

FT

FEET, FLOW TRANSMITTER

GFEP

GROUND FAULT EQUIPMENT PROTECTION

GFI

GROUND FAULT INTERRUPTER

GND

GROUND

HCTS

HYDRANT CART TEST STAND

HMI

HUMAN MACHINE INTERFACE

HP

HORSEPOWER

HS

HAND SWITCH

HZ

HERTZ

I/O

INPUT/OUTPUT

INCL

INCLUDING

INST

INSTRUMENT / INSTRUMENTATION

JY

SOLENOID

KVA

KILOVOLT-AMPS

KAIC

KILOAMPS INTERRUPTING CAPACITY

KW

KILOWATT

LDP

LEVEL/LEAK DETECTION PANEL

LFMC

LIQUID-TIGHT FLEXIBLE METAL CONDUIT

LS

LEVEL SWITCH

LSH

LEVEL SWITCH, HIGH

LSHH

LEVEL SWITCH, HIGH-HIGH

LSL

LEVEL SWITCH, LOW

LSLL

LEVEL SWITCH, LOW-LOW

LT

LEVEL TRANSMITTER

LTG

LIGHTING

MCC

MOTOR CONTROL CENTER

MCP

MOTOR CIRCUIT PROTECTOR

MIN

MINIMUM

MOV

MOTOR OPERATED VALVE

MPC

MINI-POWER CENTER

MS

MOISTURE SENSOR

MWTS

MOTOR WINDING TEMPERATURE SWITCH

NC

NORMALLY CLOSED

NEC

NATIONAL ELECTRICAL CODE

NIC

NOT IN CONTRACT

NO

NORMALLY OPEN

OC

OCCUPANCY SENSOR

OIT

OPERATOR INTERFACE TERMINAL

OWS

OIL WATER SEPARATOR

OWSO

OIL WATER SEPARATOR (OIL)

OWSP

OIL WATER SEPARATOR (SEPARATION CHAMBER)

P

POLE

PB

PANELBOARD / PUSHBUTTON

PC

PHOTOCELL

PDC

POWER DISTRIBUTION CENTER

PDS

PRESSURE DIFFERENTIAL

PH

PHASE

PIT

PRESSURE INDICATING TRANSMITTER

PLC

PROGRAMMABLE LOGIC CONTROLLER

PT

PRESSURE TRANSMITTER

PR

PAIR

PRI

PRIMARY

PRT

PRODUCT RECOVERY TANK

PVC

POLYVINYL CHLORIDE

RGAP

REMOTE GENERATOR ALARM PANEL

RGS

RIGID GALVANIZED STEEL CONDUIT

SLT

SANITARY LIFT STATION

SSRV

SOLID STATE REDUCED VOLTAGE

SYM

SYMMETRICAL

TEMP

TEMPERATURE

TLP

TANK LEVEL PANEL

TLV

TRUCK LOAD VALVE

TS

TEMPERATURE SWITCH

TSP

TWISTED SHIELDED PAIR

TT

TEMPERATURE TRANSMITTER

TYP

TYPICAL

UON

UNLESS OTHERWISE NOTED

UTP

UNSHIELDED TWISTED PAIR

V

VOLTS

WP

WEATHERPROOF

WTR

WATER

WTS

WINDING TEMPERATURE SWITCH

XFMR

TRANSFORMER

12/20/2023

no.

date

by

ckd

description

A

12/21/23

TSR

BAW

ISSUED FOR PERMIT

ISSUED FOR PERMIT ONLY

BURNS
McDONNELL

9400 WARD PARKWAY
KANSAS CITY, MO 64114
816-333-9400
Burns & McDonnell Engineering Co, Inc.

date

04/24/2023

detailed

S. JESBERG

designed

T. RENSHAW

checked

B. WINTER

PDX FUEL COMPANY L.L.C

PORTLAND INTERNATIONAL AIRPORT
5000 NE MARINE DR.
PORTLAND, OREGON 97218

PDX FACILITY IMPROVEMENTS
ELECTRICAL GENERAL NOTES, LEGEND & ABBREVIATIONS

project

153929

contract

drawing

E-001

rev.

A

file 153929E-001.dwg

1

2

3

4

5

6

7

8

9

10

11

12

13

Scale For Microfining

Millimeters

Inches

12/20/2023

12/19/2023 4:29 PM SNJESBERG

NOTE:


1. SEE SHEET E-001 FOR GENERAL NOTES, LEGEND AND ABBREVIATIONS.

KEYED NOTE:

- 1 ONCE TANKS 5, 6 AND 7 ARE COMMISSIONED AND OPERATIONAL, DEMOLISH AND REMOVE ALL ELECTRICAL APPURTANCES ON THE STORAGE TANK. THIS INCLUDES BUT IS NOT LIMITED TO
A. CONDUIT
B. WIRING
C. ELECTRICAL SUPPORTS
D. ELECTRICAL EQUIPMENT
E. GROUNDING ELECTRODES
F. LIGHTING FIXTURES & OBSTRUCTION LIGHTS"
- 2 SEE ONE-LINE FOR DEMOLITION DETAILS.
- 3 DUCTBANK SHALL BE DEMOLISHED BACK TO A POINT TO BE INTERCEPTED AND EXTENDED.
- 4 BUILDING SHALL BE RELOCATED.

LEGEND:


DEMOLITION

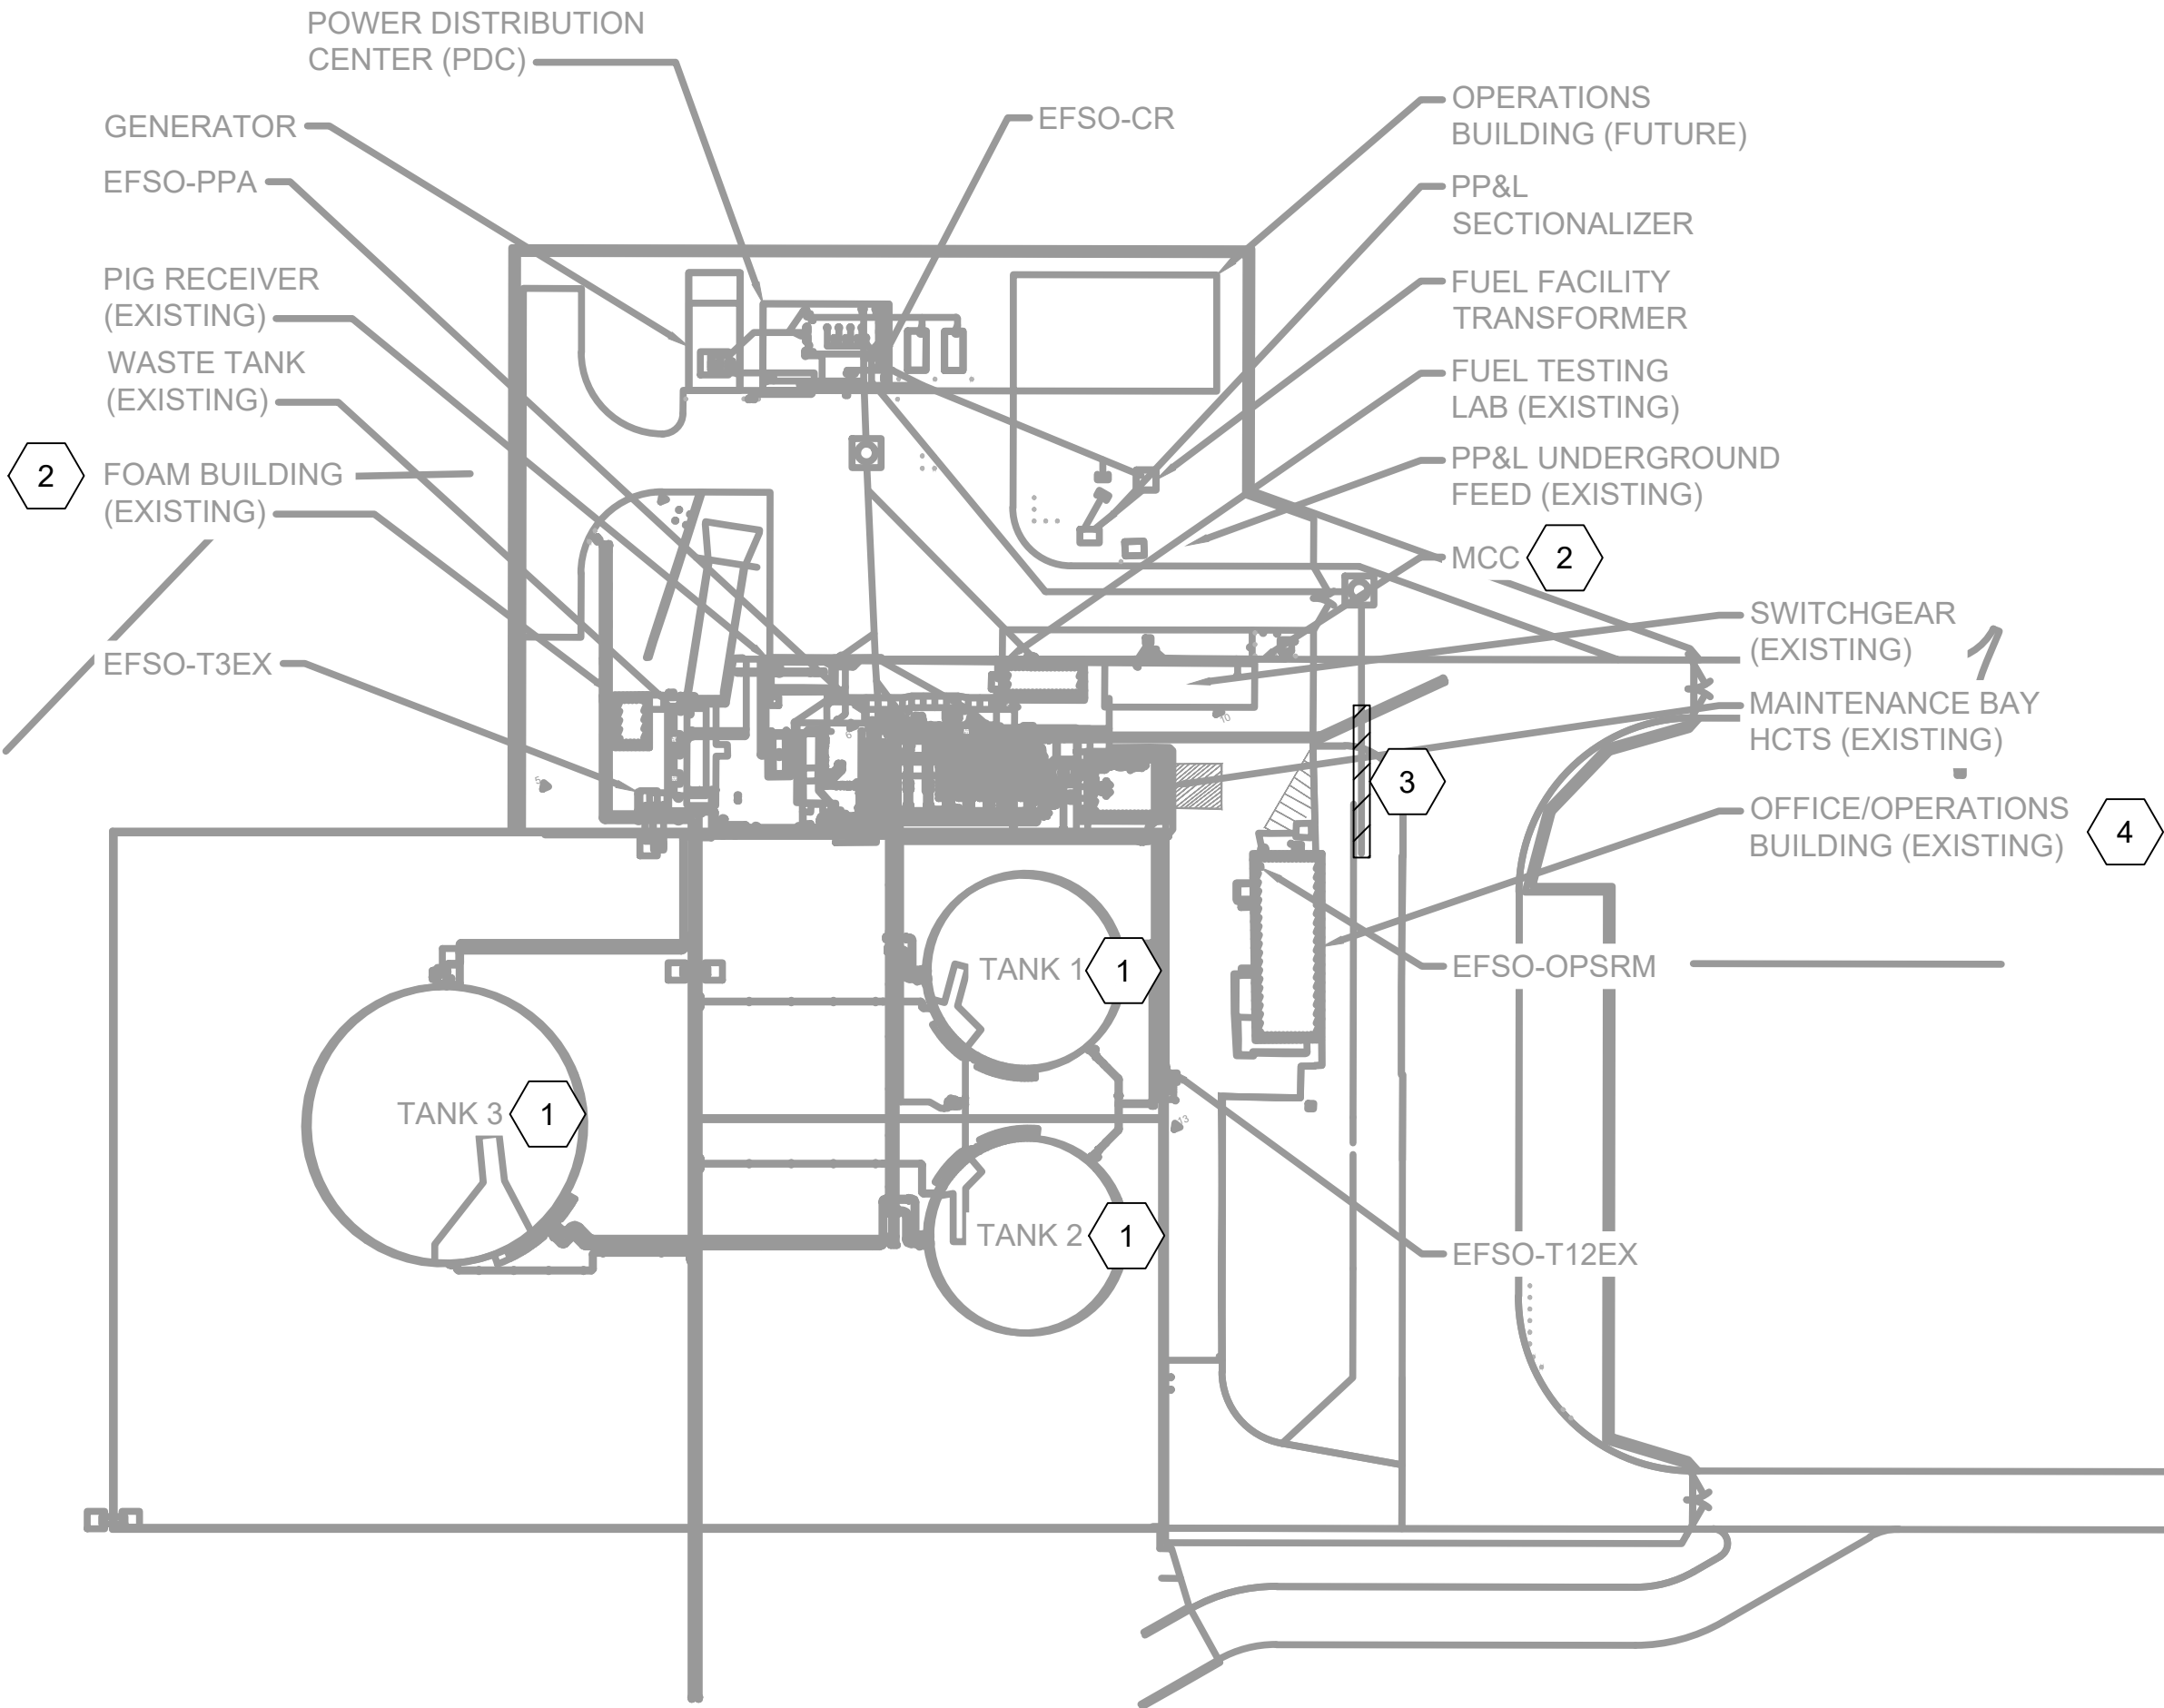

OVERALL ELECTRICAL
DEMOLITION PLAN

0 60' 120'

SCALE IN FEET

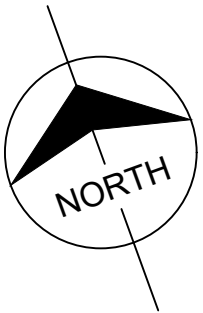

no.	date	by	ckd	description
A	12/21/23	TSR	BAW	ISSUED FOR PERMIT

ISSUED FOR PERMIT
ONLY



9400 WARD PARKWAY
KANSAS CITY, MO 64114
816-333-9400
Burns & McDonnell Engineering Co., Inc.

date	04/24/2023	detailed	S. JESBERG
designed	T. RENSHAW	checked	B. WINTER

PDX FUEL COMPANY L.L.C

PORTLAND INTERNATIONAL AIRPORT
5000 NE MARINE DR.
PORTLAND, OREGON 97218

PDX FACILITY IMPROVEMENTS
OVERALL ELECTRICAL DEMOLITION PLAN

project	153929	contract	
drawing	ED101	rev.	A

file 153929ED101.dwg

NOTES:

 
 
 
 
- SEE SHEET E-001 FOR GENERAL NOTES, LEGEND AND ABBREVIATIONS.
- SEE HAZARDOUS AREA DETAILS ON DRAWING E-502.
- HAZARDOUS AREAS WITHIN THIS DRAWING SET ARE ONLY IDENTIFIED FOR AREAS WITHIN THIS PROJECT'S SCOPE OF WORK.
- HAZARDOUS AREAS WITHIN THIS DRAWING SET ARE BASED ON ARTICLE 500, 501 AND 515 IN NFPA 70: NATIONAL ELECTRICAL CODE (2020), NFPA 407 STANDARD FOR AIRCRAFT FUEL SERVICING (2022) AND API RECOMMENDED PRACTICE 500 (NOV 2014) BASED ON THE PRESENCE OF FLAMMABLE LIQUIDS (CLASS I).
- THIS FACILITY DISTRIBUTES THE FOLLOWING PRODUCTS/ADDITIVES:


JET A - CLASS II LIQUID (CONSIDERED A CLASS I LIQUID FOR ELECTRICAL INSTALLATIONS PER NFPA 407)

KEYED NOTES:


- INTERIOR OF TANK IS CONSIDERED CLASS I, DIVISION 1. HATCHING OMITTED FOR CLARITY.
- GENERATOR HAS AN INTEGRAL BELLY TANK. DIESEL IS A CLASS II LIQUID WITH NO AREA CLASSIFICATION.

LEGEND:

-  CLASS I, DIVISION 1, GROUP D (REQUIRES T3 RATED MOTORS/EQUIPMENT)
-  CLASS I, DIVISION 2, GROUP D (REQUIRES T3 RATED MOTORS/EQUIPMENT)
-  ENGINEERED CLASS I, DIVISION 1, GROUP D (REQUIRES T3 RATED MOTORS/EQUIPMENT)
-  ENGINEERED CLASS I, DIVISION 2, GROUP D (REQUIRES T3 RATED MOTORS/EQUIPMENT)
-  NON-CLASSIFIED

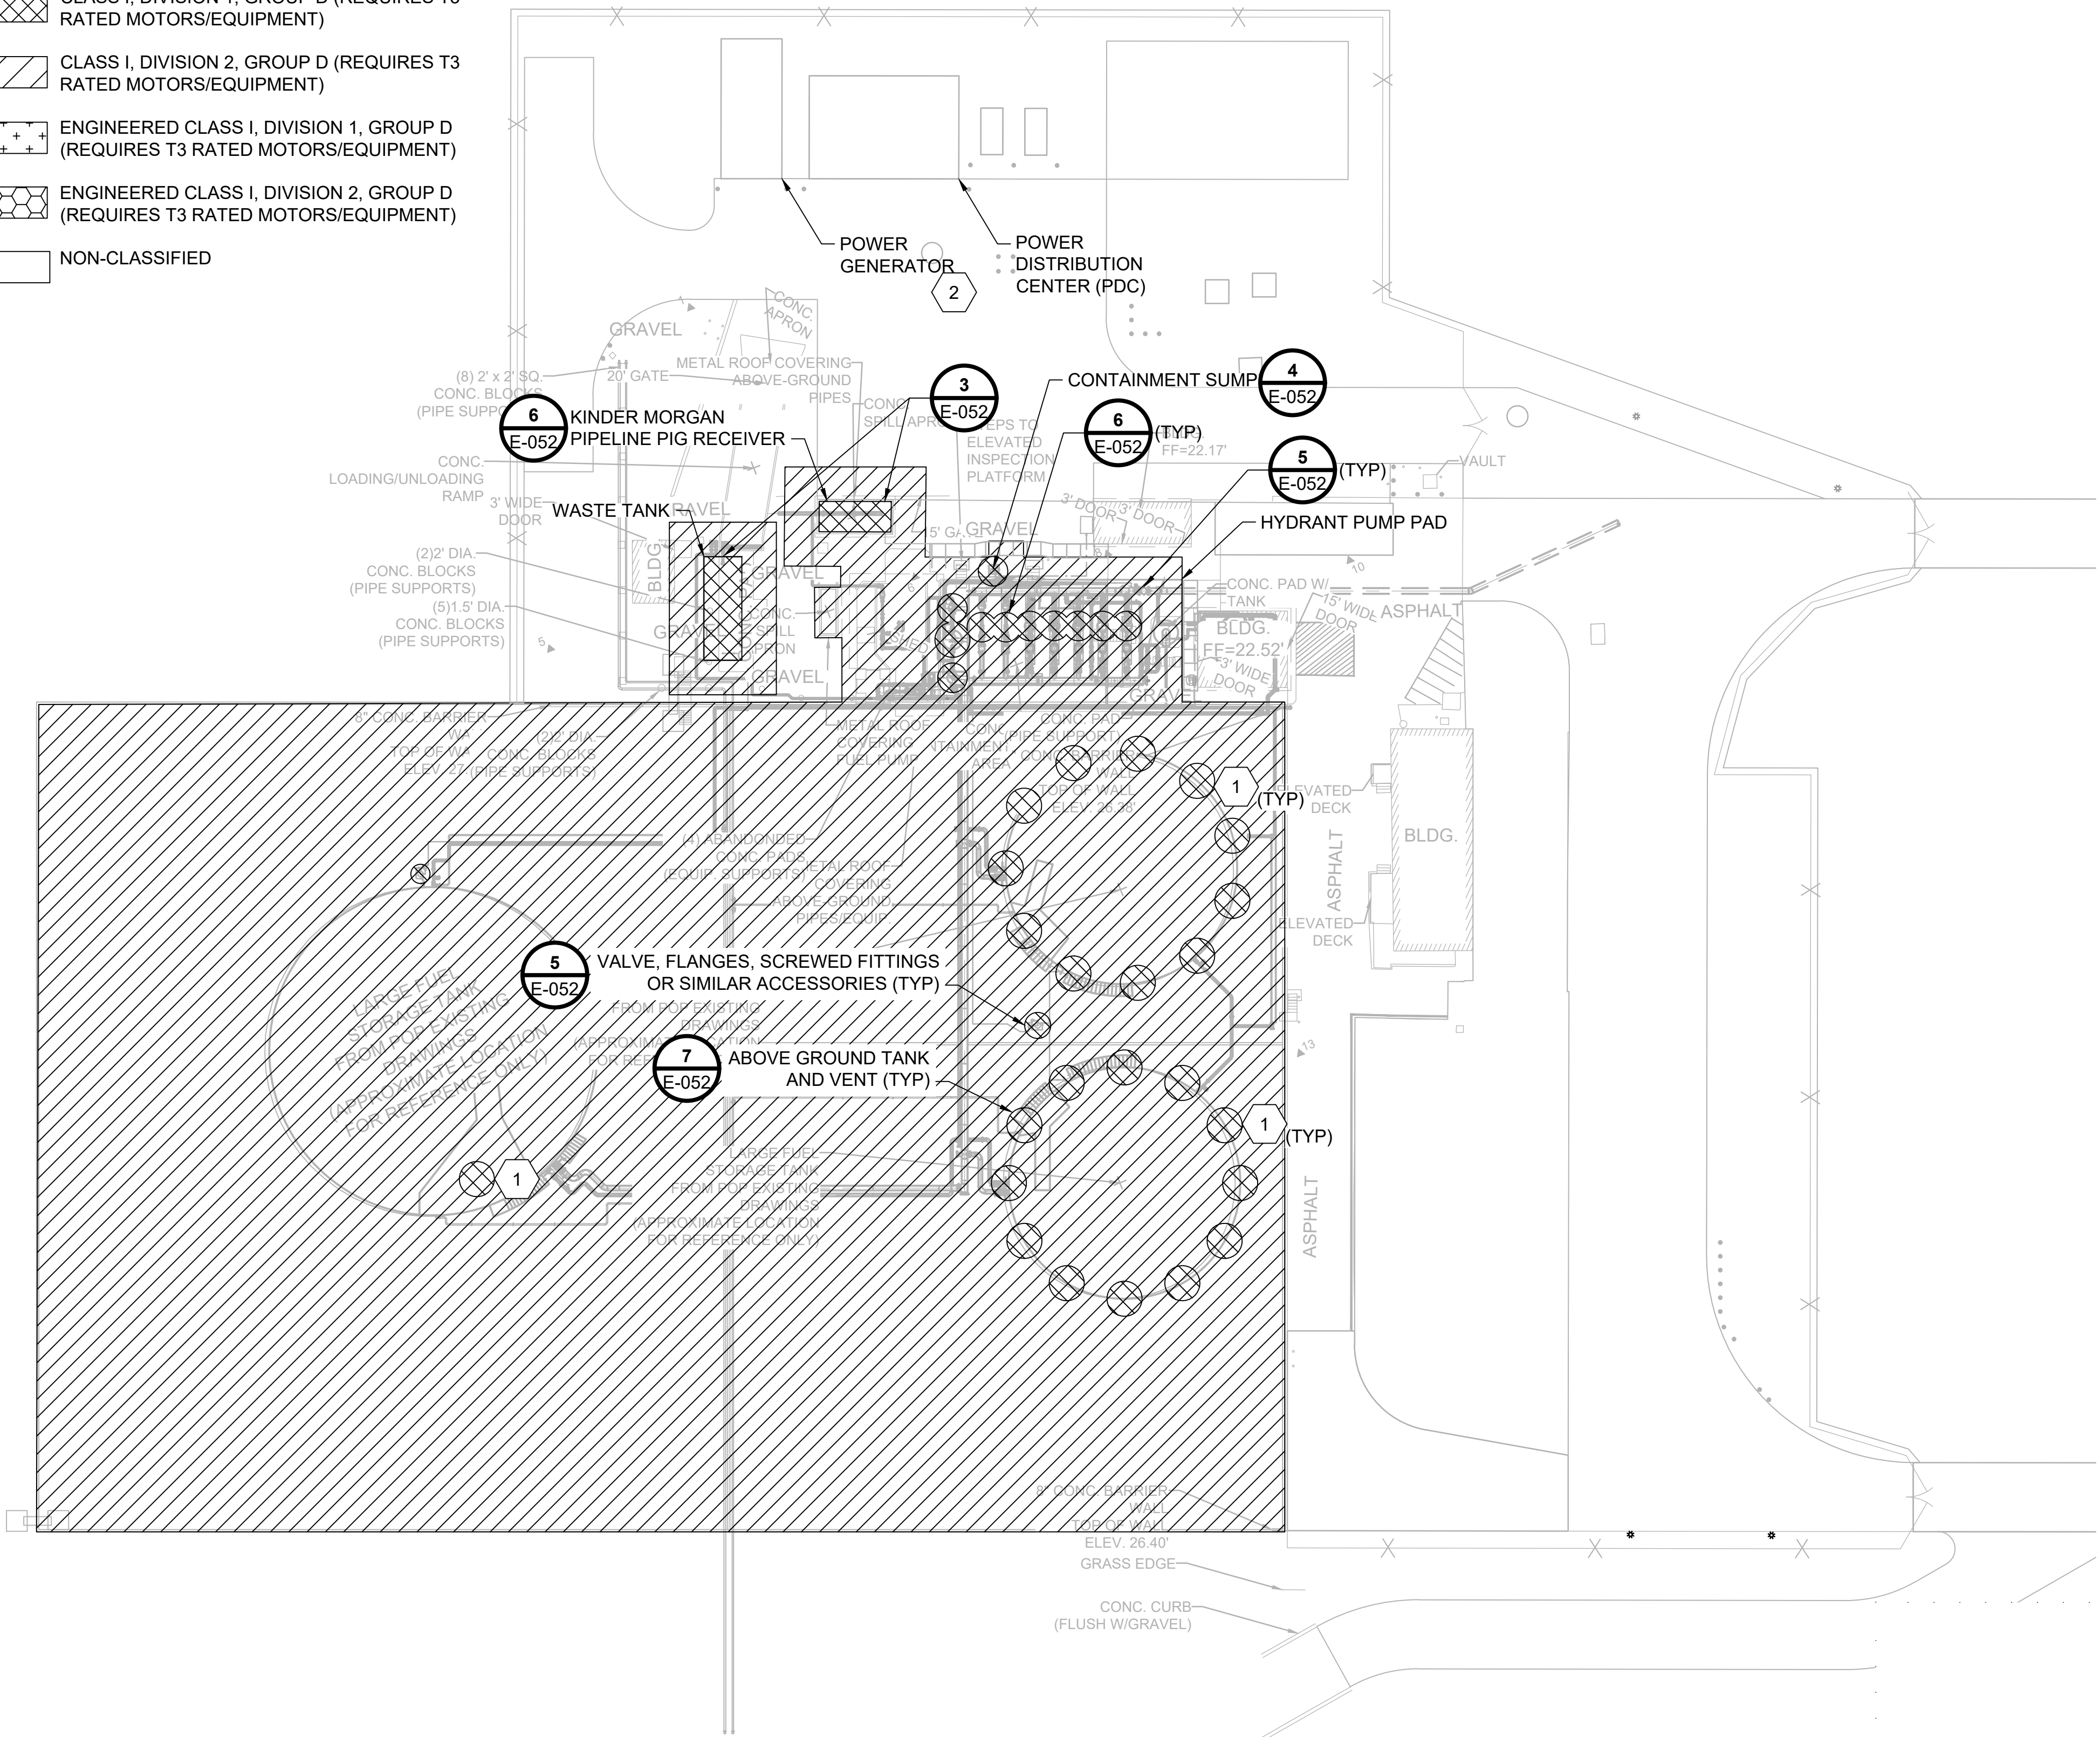

OVERALL ELECTRICAL PLAN
- EXISTING

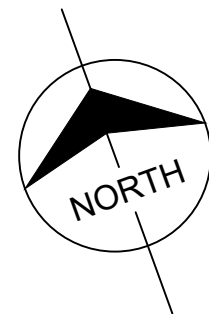

12/20/2023

no.	date	by	ckd	description
A	12/21/23	TSR	BAW	ISSUED FOR PERMIT

ISSUED FOR PERMIT
ONLY



9400 WARD PARKWAY
KANSAS CITY, MO 64114
816-333-9400
Burns & McDonnell Engineering Co., Inc.

date	04/24/2023	detailed	S. JESBERG
designed	T. RENSHAW	checked	B. WINTER


PDX FUEL COMPANY L.L.C

PORTLAND INTERNATIONAL AIRPORT
5000 NE MARINE DR.
PORTLAND, OREGON 97218

PDX FACILITY IMPROVEMENTS
HAZARDOUS AREA PLAN - EXISTING

project	153929	contract	
drawing	E-050A	rev.	A

file 153929E-050A.dwg

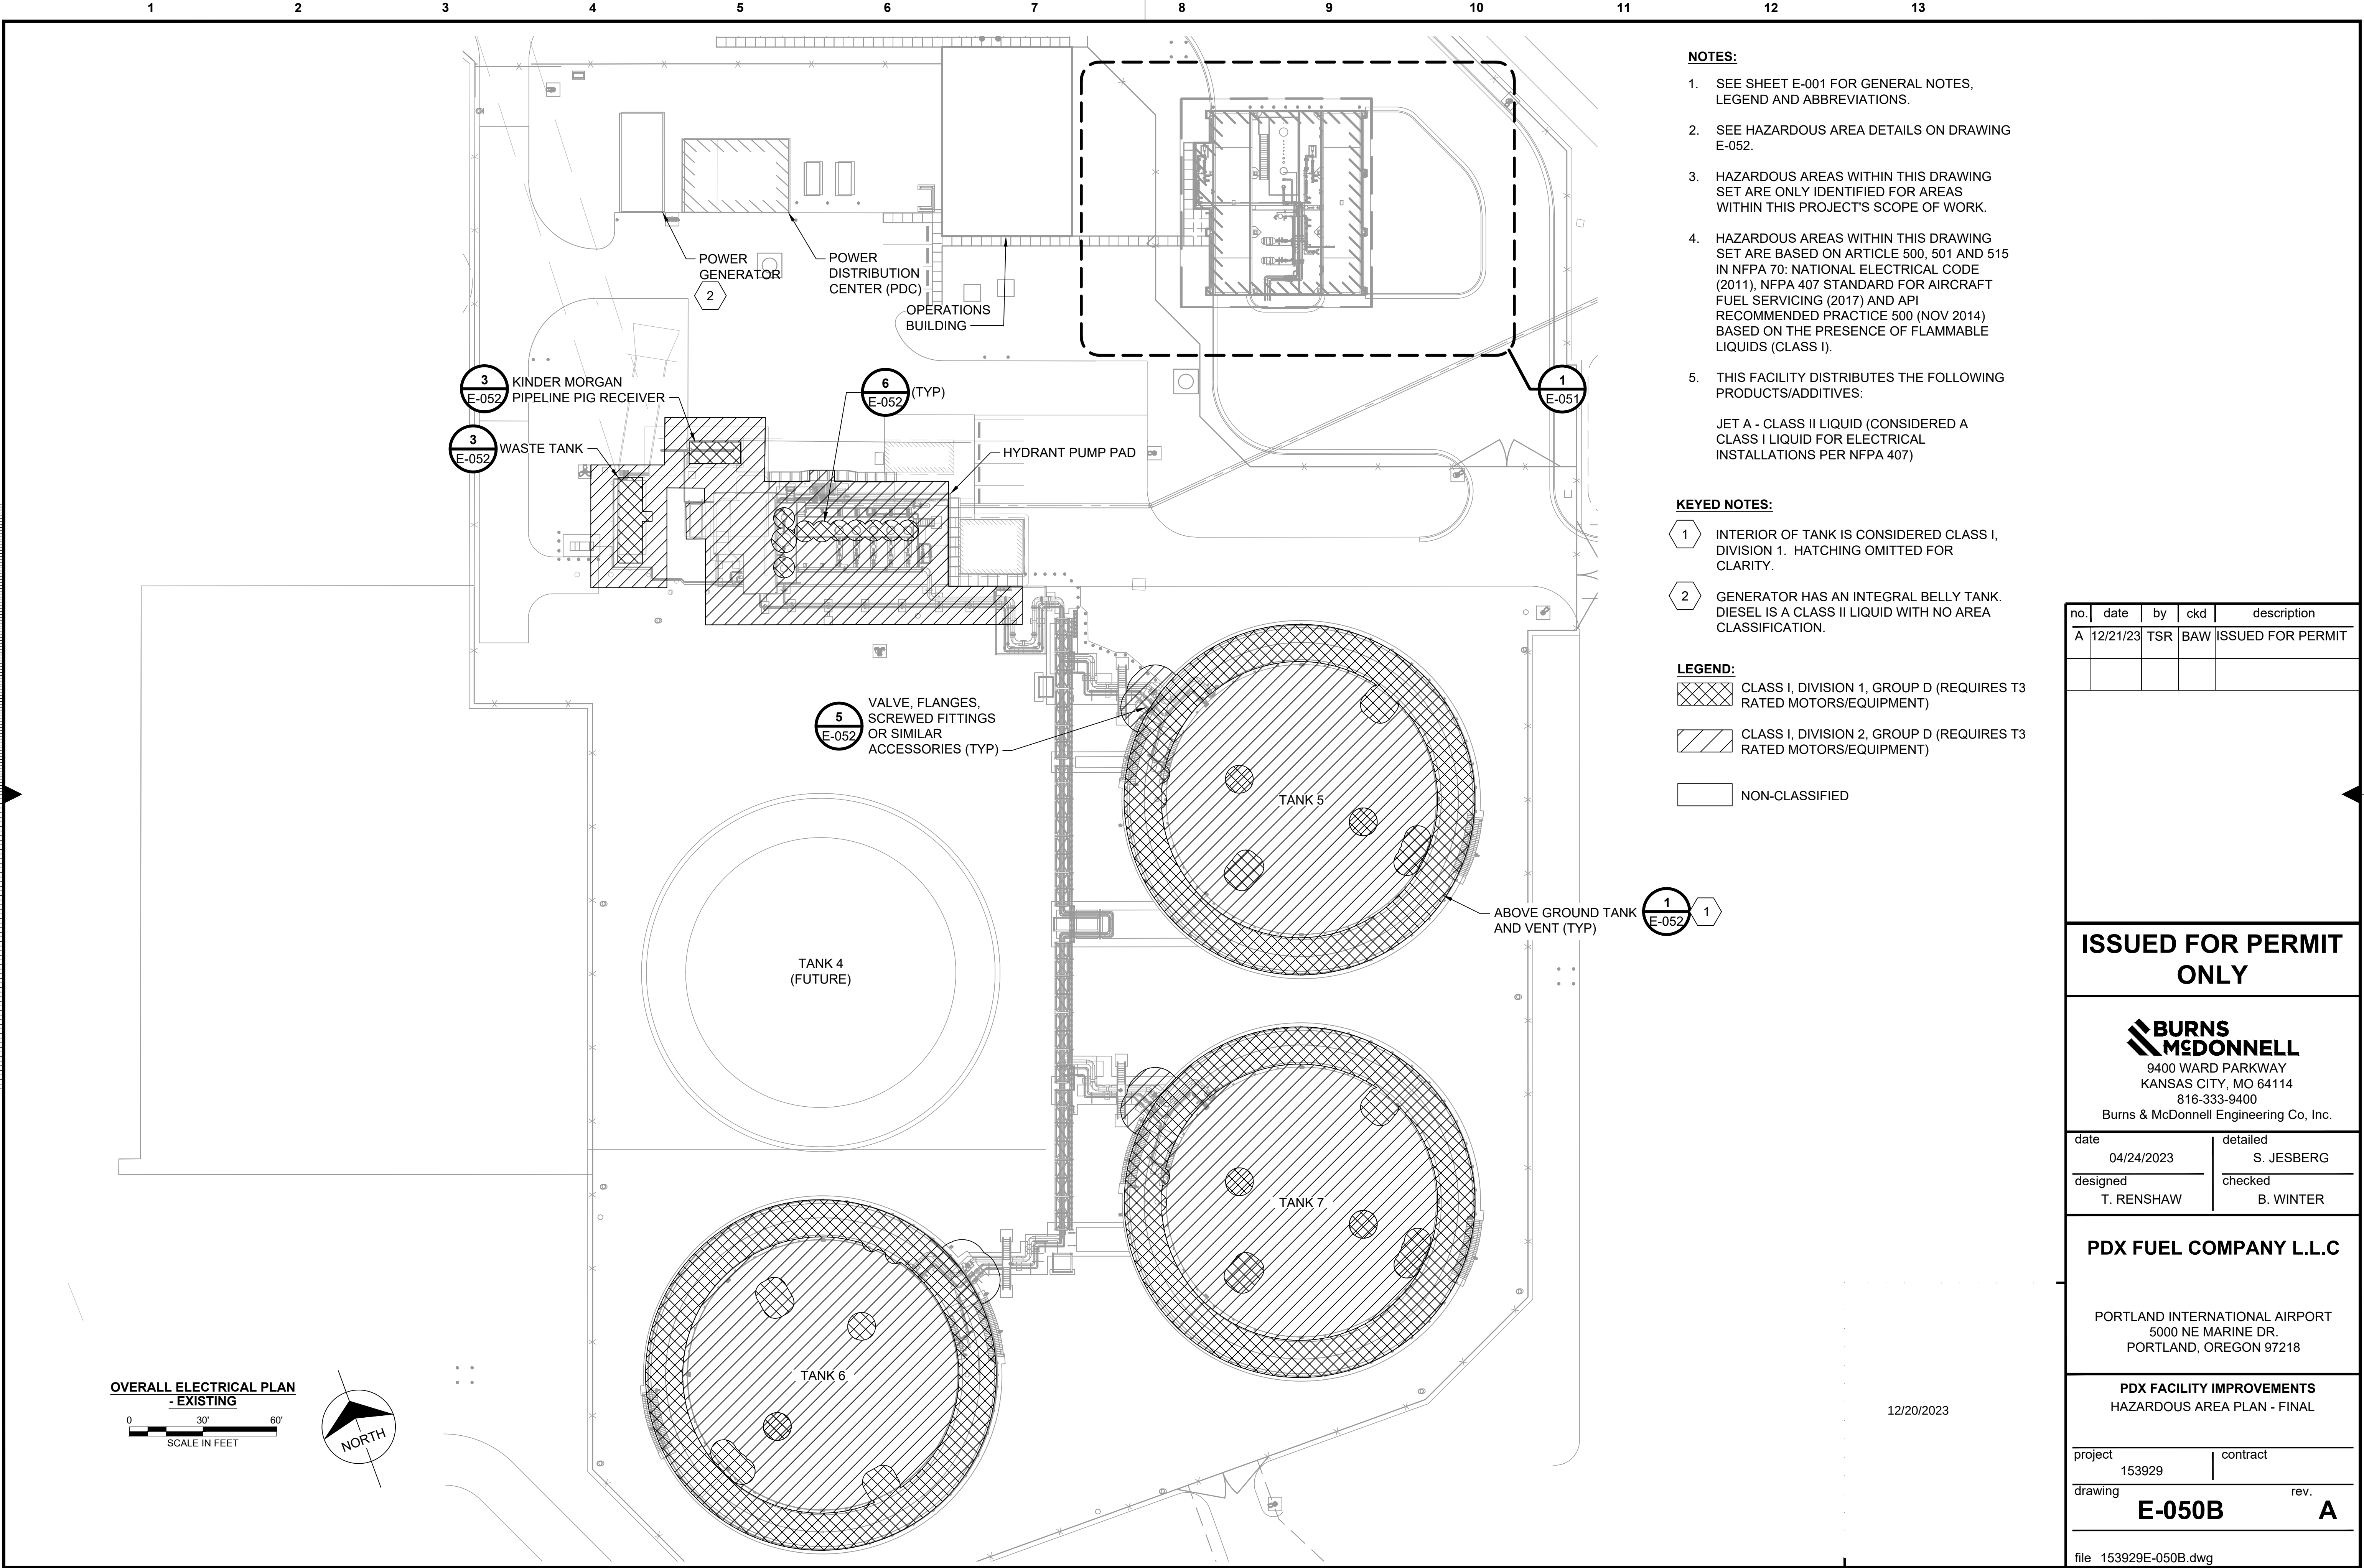

- NOTES:**
- SEE SHEET E-001 FOR GENERAL NOTES, LEGEND AND ABBREVIATIONS.
 - SEE HAZARDOUS AREA DETAILS ON DRAWING E-052.
 - HAZARDOUS AREAS WITHIN THIS DRAWING SET ARE ONLY IDENTIFIED FOR AREAS WITHIN THIS PROJECT'S SCOPE OF WORK.
 - HAZARDOUS AREAS WITHIN THIS DRAWING SET ARE BASED ON ARTICLE 500, 501 AND 515 IN NFPA 70: NATIONAL ELECTRICAL CODE (2011), NFPA 407 STANDARD FOR AIRCRAFT FUEL SERVICING (2017) AND API RECOMMENDED PRACTICE 500 (NOV 2014) BASED ON THE PRESENCE OF FLAMMABLE LIQUIDS (CLASS I).
 - THIS FACILITY DISTRIBUTES THE FOLLOWING PRODUCTS/ADDITIVES:

JET A - CLASS II LIQUID (CONSIDERED A CLASS I LIQUID FOR ELECTRICAL INSTALLATIONS PER NFPA 407)

- KEYED NOTES:**
- INTERIOR OF TANK IS CONSIDERED CLASS I, DIVISION 1. HATCHING OMITTED FOR CLARITY.
 - GENERATOR HAS AN INTEGRAL BELLY TANK. DIESEL IS A CLASS II LIQUID WITH NO AREA CLASSIFICATION.

- LEGEND:**
- CLASS I, DIVISION 1, GROUP D (REQUIRES T3 RATED MOTORS/EQUIPMENT)
 - CLASS I, DIVISION 2, GROUP D (REQUIRES T3 RATED MOTORS/EQUIPMENT)
 - NON-CLASSIFIED

no.	date	by	ckd	description
A	12/21/23	TSR	BAW	ISSUED FOR PERMIT

ISSUED FOR PERMIT ONLY

**BURNS
MCDONNELL**
9400 WARD PARKWAY
KANSAS CITY, MO 64114
816-333-9400
Burns & McDonnell Engineering Co., Inc.

date	04/24/2023	detailed	S. JESBERG
designed	T. RENSHAW	checked	B. WINTER


PDX FUEL COMPANY L.L.C

PORTLAND INTERNATIONAL AIRPORT
5000 NE MARINE DR.
PORTLAND, OREGON 97218

PDX FACILITY IMPROVEMENTS
HAZARDOUS AREA PLAN - FINAL

project	153929	contract	
drawing	E-050B	rev.	A

file 153929E-050B.dwg

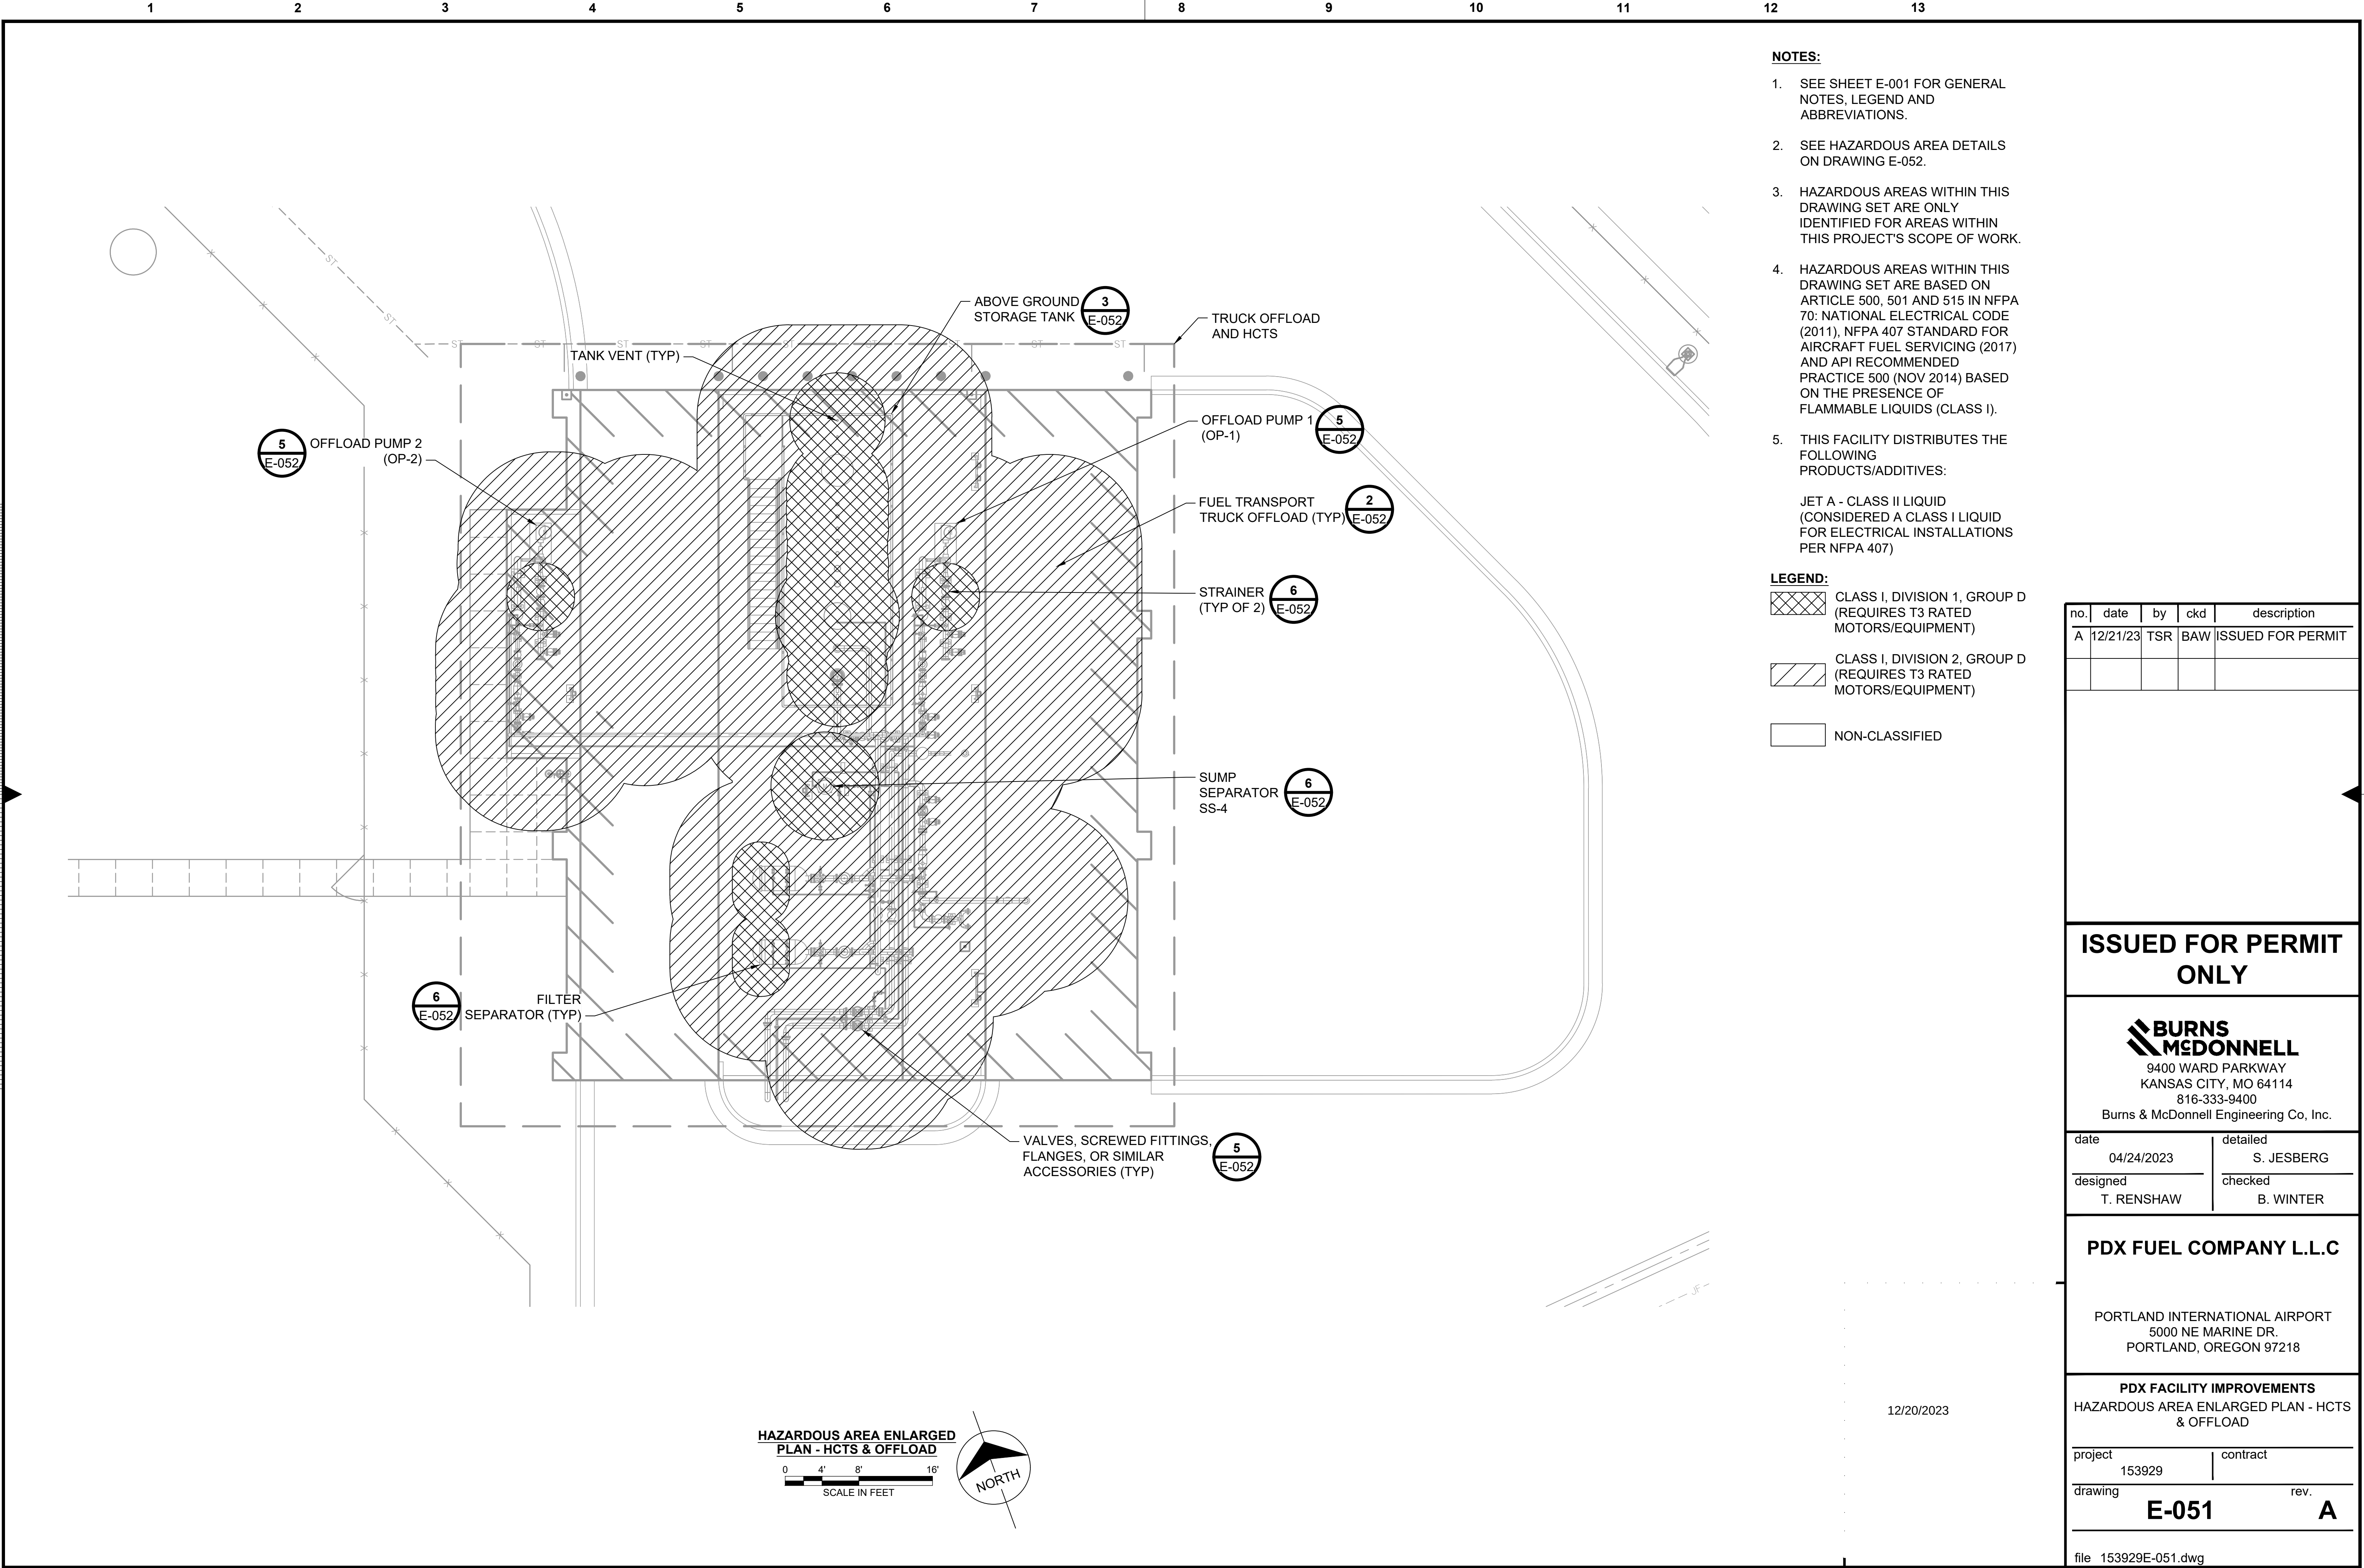

- NOTES:**
- SEE SHEET E-001 FOR GENERAL NOTES, LEGEND AND ABBREVIATIONS.
 - SEE HAZARDOUS AREA DETAILS ON DRAWING E-052.
 - HAZARDOUS AREAS WITHIN THIS DRAWING SET ARE ONLY IDENTIFIED FOR AREAS WITHIN THIS PROJECT'S SCOPE OF WORK.
 - HAZARDOUS AREAS WITHIN THIS DRAWING SET ARE BASED ON ARTICLE 500, 501 AND 515 IN NFPA 70: NATIONAL ELECTRICAL CODE (2011), NFPA 407 STANDARD FOR AIRCRAFT FUEL SERVICING (2017) AND API RECOMMENDED PRACTICE 500 (NOV 2014) BASED ON THE PRESENCE OF FLAMMABLE LIQUIDS (CLASS I).
 - THIS FACILITY DISTRIBUTES THE FOLLOWING PRODUCTS/ADDITIVES:

JET A - CLASS II LIQUID (CONSIDERED A CLASS I LIQUID FOR ELECTRICAL INSTALLATIONS PER NFPA 407)

LEGEND:

	CLASS I, DIVISION 1, GROUP D (REQUIRES T3 RATED MOTORS/EQUIPMENT)
	CLASS I, DIVISION 2, GROUP D (REQUIRES T3 RATED MOTORS/EQUIPMENT)
	NON-CLASSIFIED

no.	date	by	ckd	description
A	12/21/23	TSR	BAW	ISSUED FOR PERMIT

ISSUED FOR PERMIT ONLY



9400 WARD PARKWAY
KANSAS CITY, MO 64114
816-333-9400
Burns & McDonnell Engineering Co., Inc.

date	04/24/2023	detailed	S. JESBERG
designed	T. RENSHAW	checked	B. WINTER

PDX FUEL COMPANY L.L.C


PORTLAND INTERNATIONAL AIRPORT
5000 NE MARINE DR.
PORTLAND, OREGON 97218

PDX FACILITY IMPROVEMENTS
HAZARDOUS AREA ENLARGED PLAN - HCTS & OFFLOAD


project	153929	contract	
drawing	E-051	rev.	A

file 153929E-051.dwg


Scale For Microfilming
Inches
Millimeters

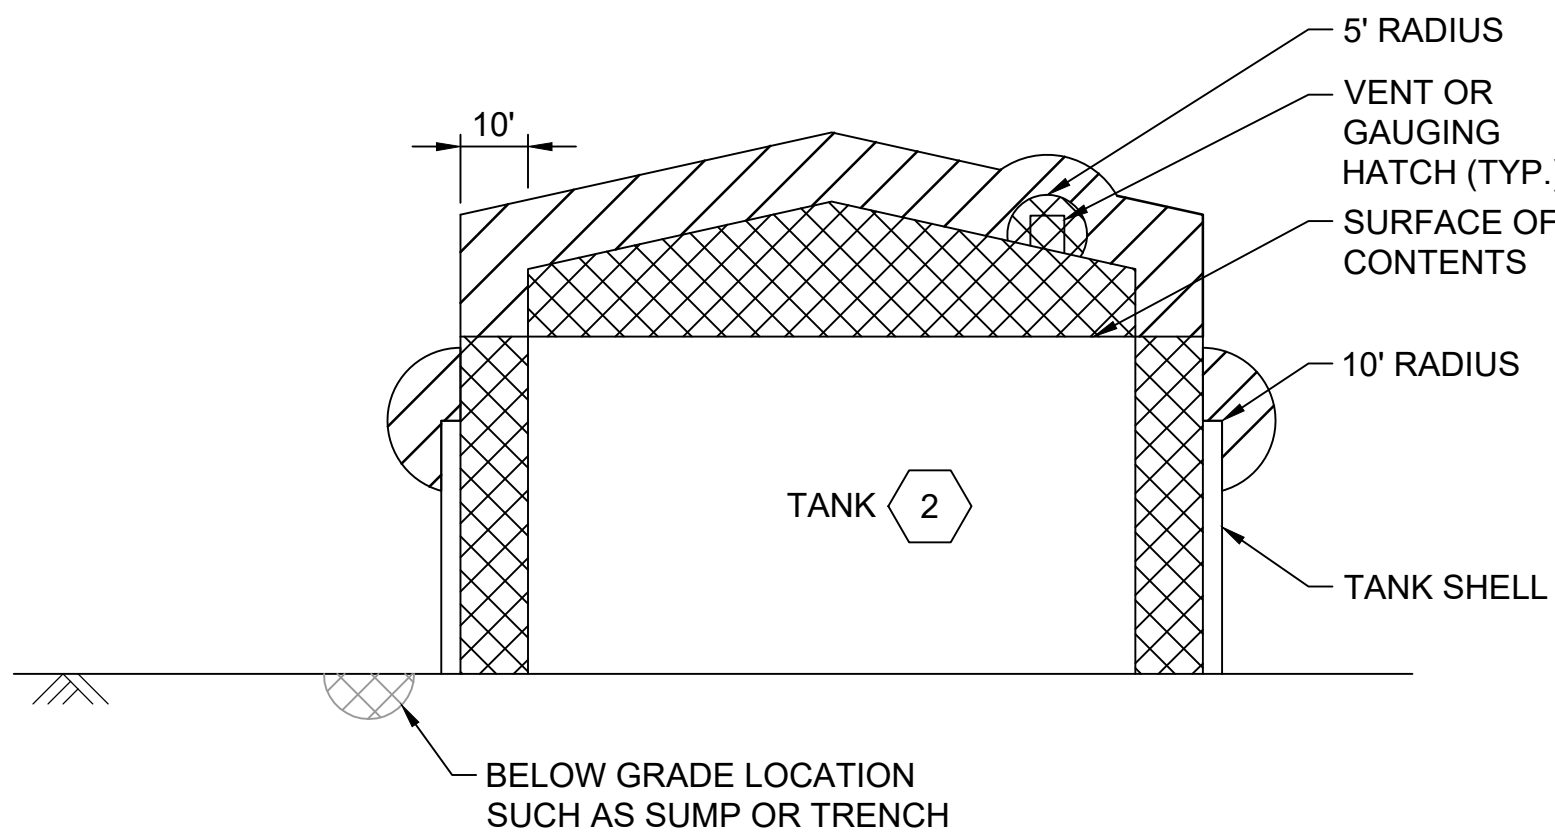


DETAIL 1
ABOVE GROUND TANK WITH TANK SHELL
NOT TO SCALE
E-050B

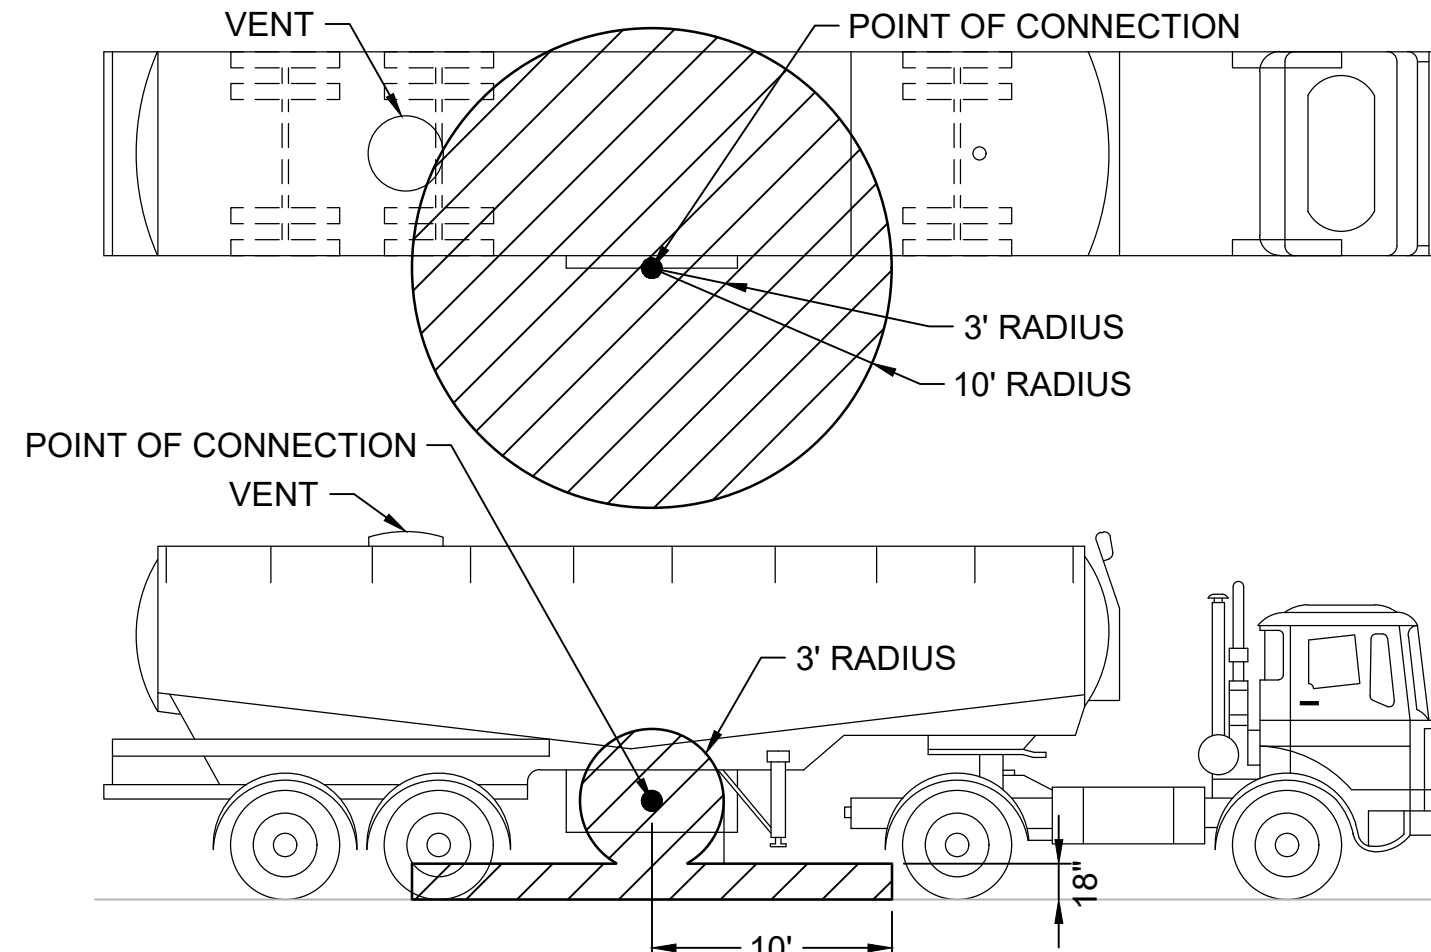


DETAIL 2
FUEL TRANSPORT TRUCK OFFLOAD (BOTTOM CONNECTION)
NOT TO SCALE
E-051

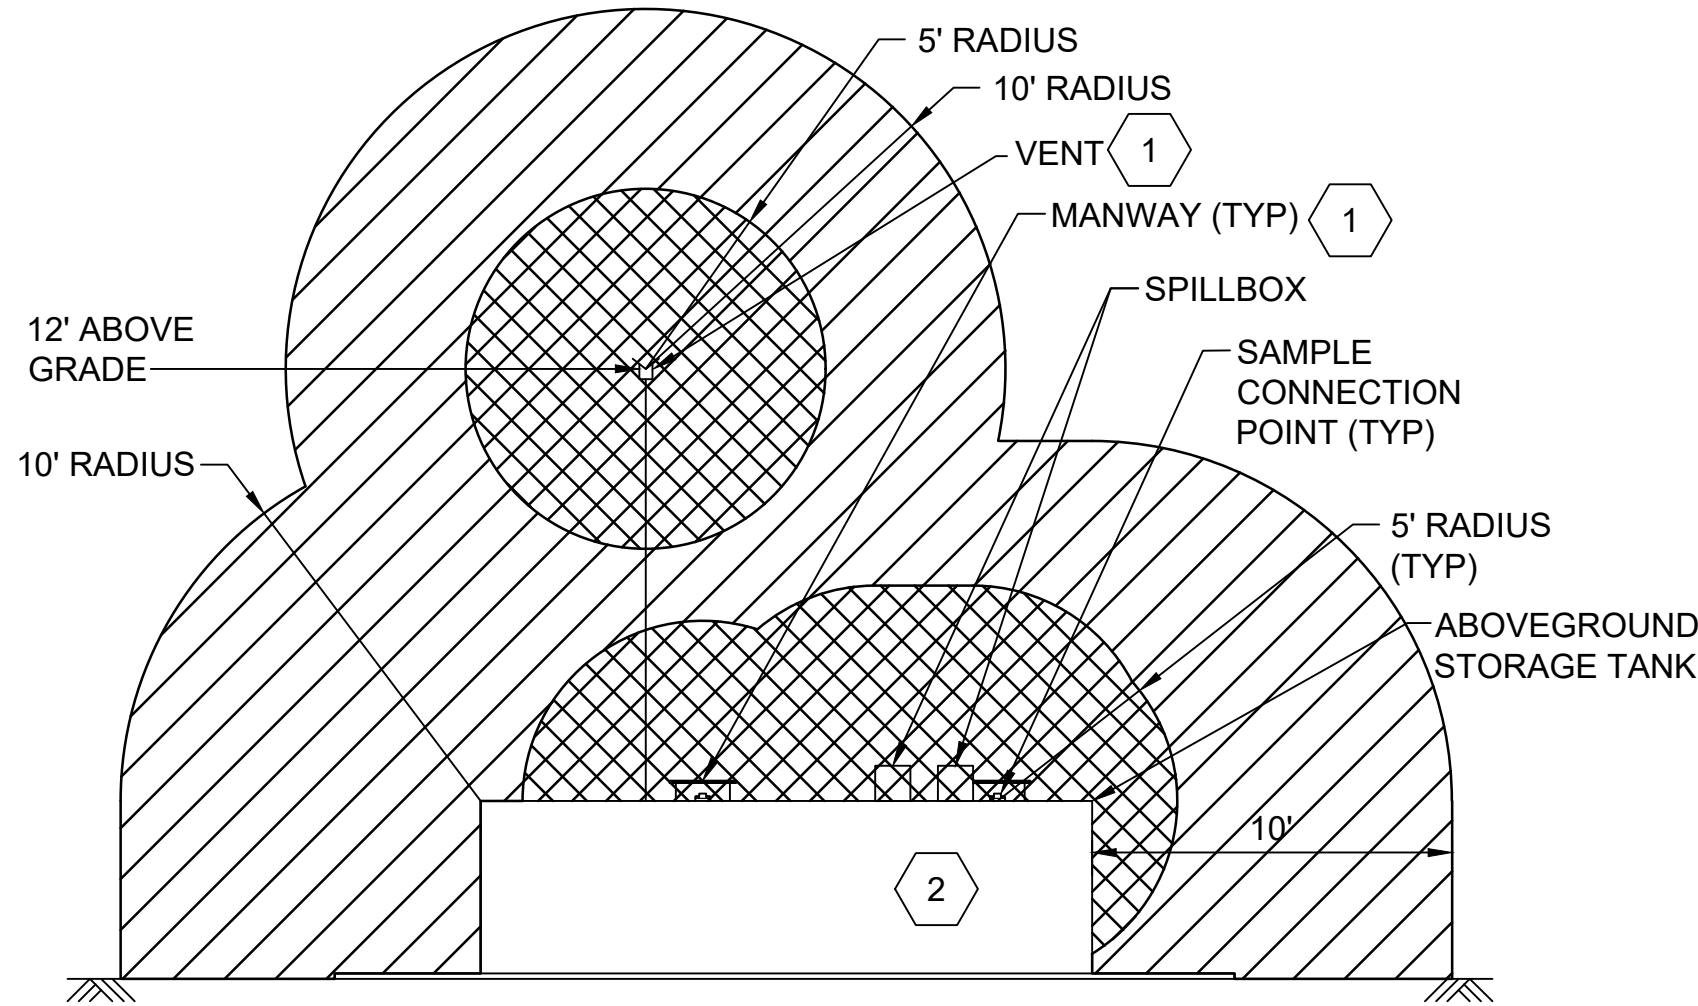


DETAIL 3
TYPICAL ABOVEGROUND HORIZONTAL STORAGE TANK / RECOVERY TANK
NOT TO SCALE
E-050A
E-050B
E-051

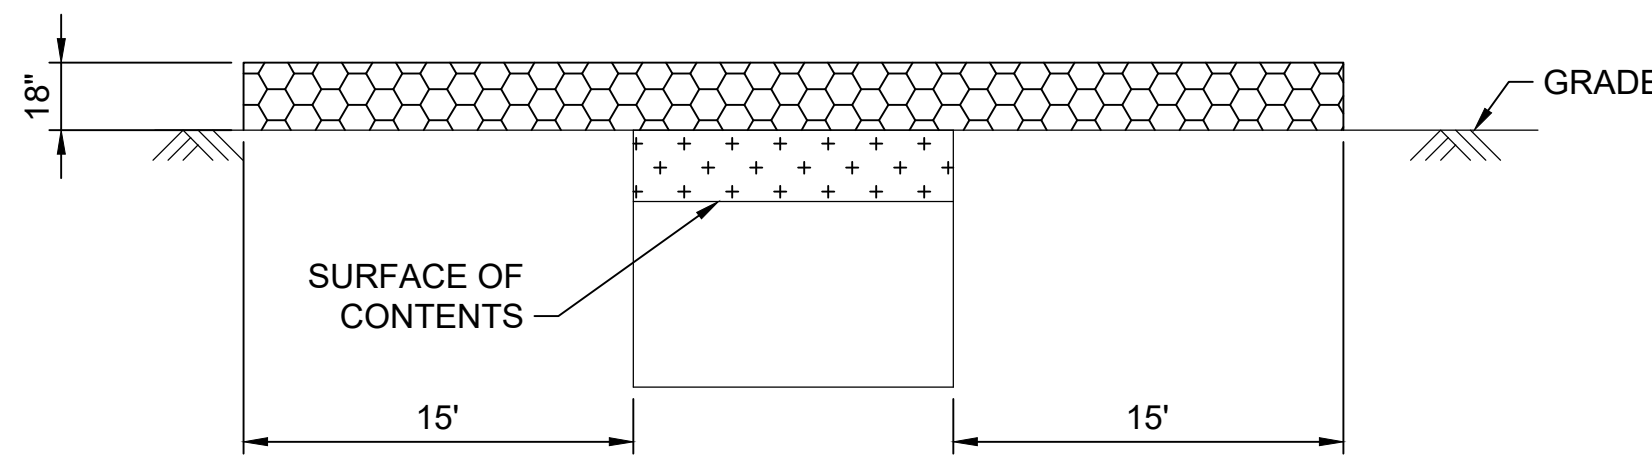


DETAIL 4
CONTAINMENT SUMP/LIFT STATION
NOT TO SCALE
E-050A

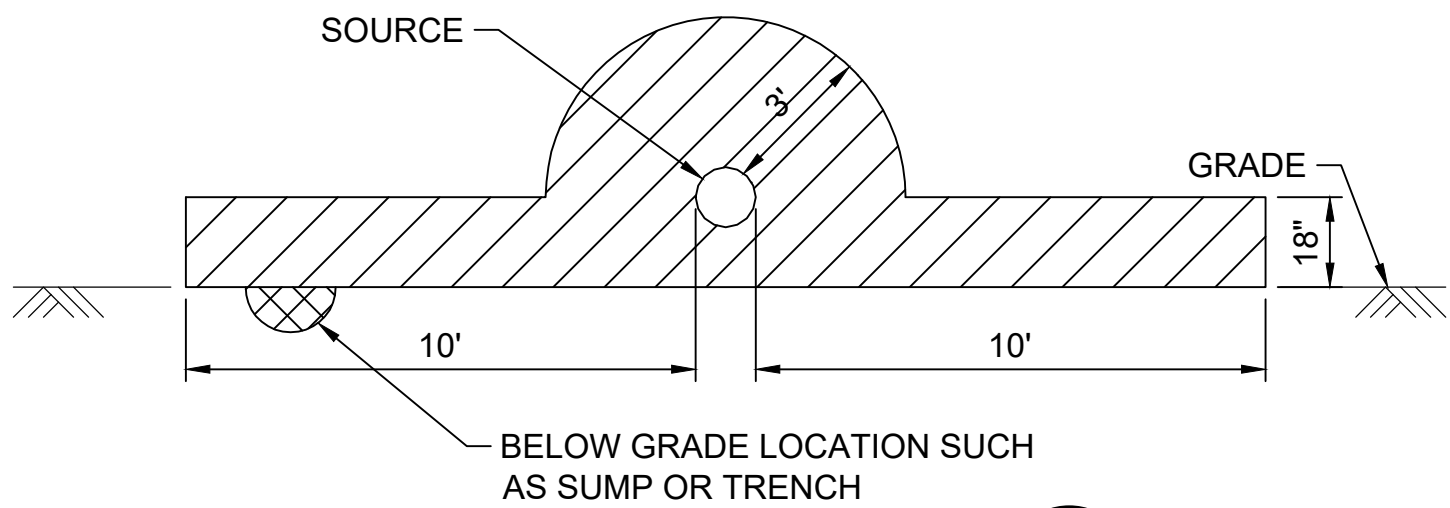

DETAIL 5
PUMPS (LESS THAN 275 PSIG) AND PIPING WITH VALVES, SCREWED FITTINGS, FLANGES OR SIMILAR ACCESSORIES - OUTDOORS
NOT TO SCALE
E-050A
E-050B
E-051

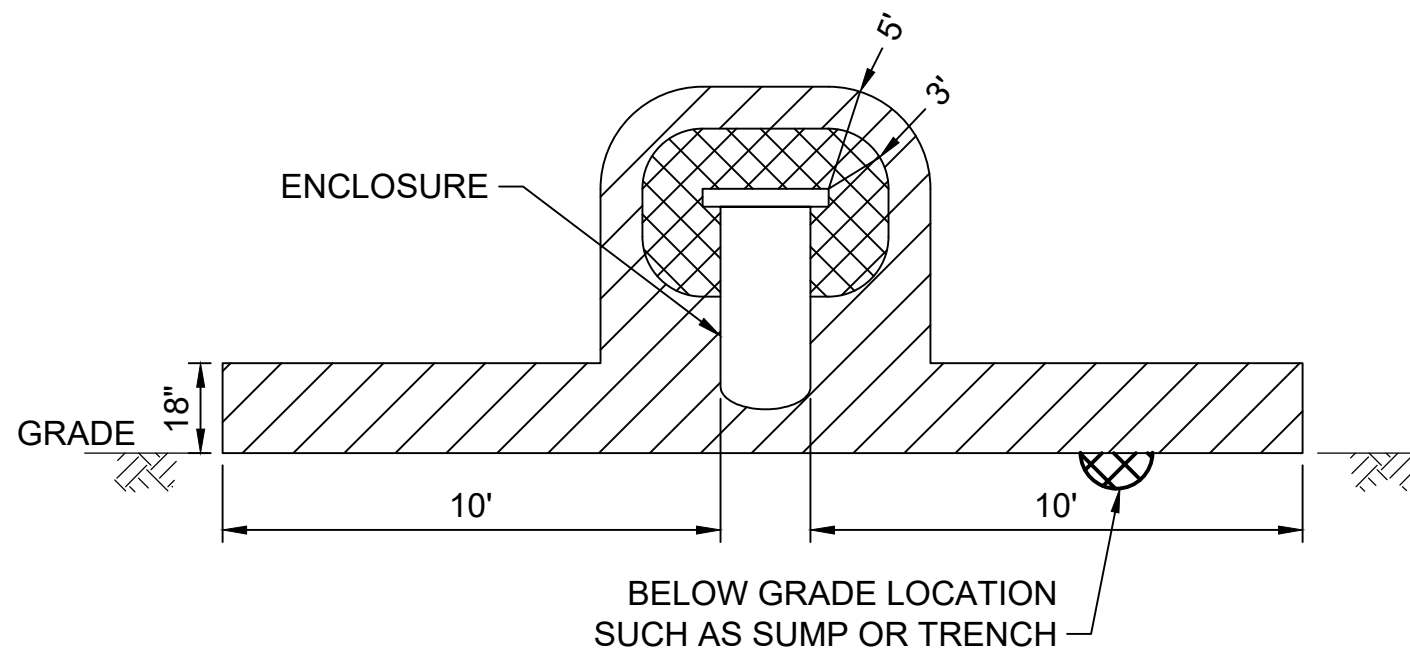

DETAIL 6
SCRAPER LAUNCHERS AND RECEIVERS / STRAINERS / FILTER/SEPARATOR / SUMP SEPARATORS / FUEL BUCKET DRAIN / PROVER / CLAY TREATER / PRE-FILTER - OUTDOORS
NOT TO SCALE
E-050A
E-050B
E-051

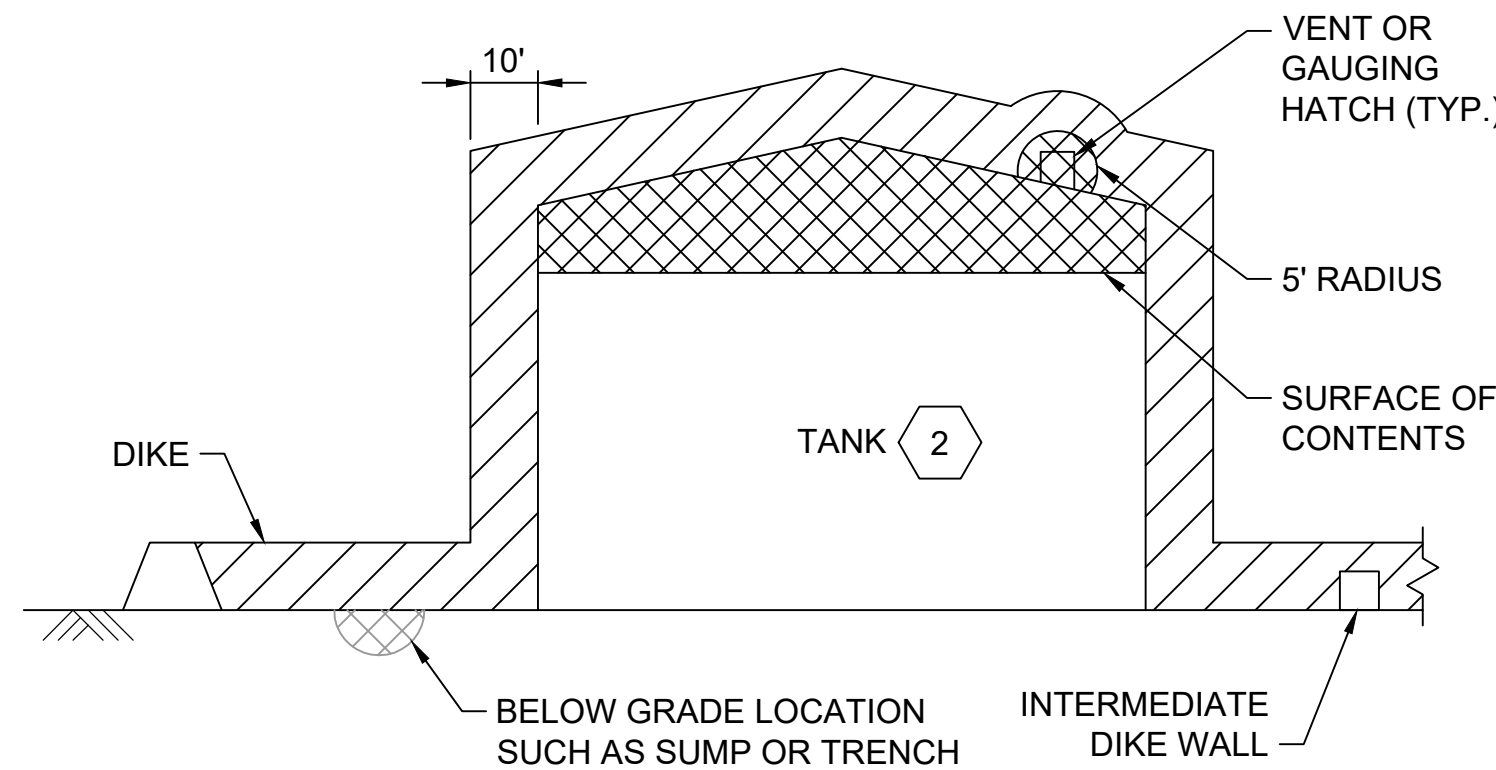

DETAIL 7
ABOVE GROUND TANK
NOT TO SCALE
E-050A

NOTES:

- SEE SHEET E-001 FOR GENERAL NOTES, LEGEND AND ABBREVIATIONS.
- HAZARDOUS AREAS WITHIN THIS DRAWING SET ARE ONLY IDENTIFIED FOR AREAS WITHIN THIS PROJECT'S SCOPE OF WORK.
- HAZARDOUS AREAS WITHIN THIS DRAWING SET ARE BASED ON ARTICLE 500, 501 AND 515 IN NFPA 70: NATIONAL ELECTRICAL CODE (2011), NFPA 407 STANDARD FOR AIRCRAFT FUEL SERVICING (2017) AND API RECOMMENDED PRACTICE 500 (NOV 2014) BASED ON THE PRESENCE OF FLAMMABLE LIQUIDS (CLASS I).
- THIS FACILITY DISTRIBUTES THE FOLLOWING PRODUCTS/ADDITIVES:
JET A - CLASS II LIQUID (CONSIDERED A CLASS I LIQUID FOR ELECTRICAL INSTALLATIONS PER NFPA 407)

KEYED NOTES:

- POSITION AND NUMBER OF VENTS, MANWAYS, ETC. DEPENDENT ON TANK FABRICATOR.
- SPACE ABOVE FUEL AND WITHIN THE TANK SHELL IS A CLASS I, DIVISION 1 AREA.

LEGEND:

- CLASS I, DIVISION 1, GROUP D (REQUIRES T3 RATED MOTORS/EQUIPMENT)
- CLASS I, DIVISION 2, GROUP D (REQUIRES T3 RATED MOTORS/EQUIPMENT)
- ENGINEERED CLASS I, DIVISION 1, GROUP D (REQUIRES T3 RATED MOTORS/EQUIPMENT)
- ENGINEERED CLASS I, DIVISION 2, GROUP D (REQUIRES T3 RATED MOTORS/EQUIPMENT)
- NON-CLASSIFIED

no.	date	by	ckd	description
A	12/21/23	TSR	BAW	ISSUED FOR PERMIT

ISSUED FOR PERMIT ONLY

BURNS MCDONNELL

9400 WARD PARKWAY
KANSAS CITY, MO 64114
816-333-9400
Burns & McDonnell Engineering Co., Inc.

date	04/24/2023	detailed	S. JESBERG
designed	T. RENSHAW	checked	B. WINTER


PDX FUEL COMPANY L.L.C


PORTLAND INTERNATIONAL AIRPORT
5000 NE MARINE DR.
PORTLAND, OREGON 97218

**PDX FACILITY IMPROVEMENTS
HAZARDOUS AREA DETAILS**

project	153929	contract	
drawing	E-052	rev.	A

file 153929E-052.dwg

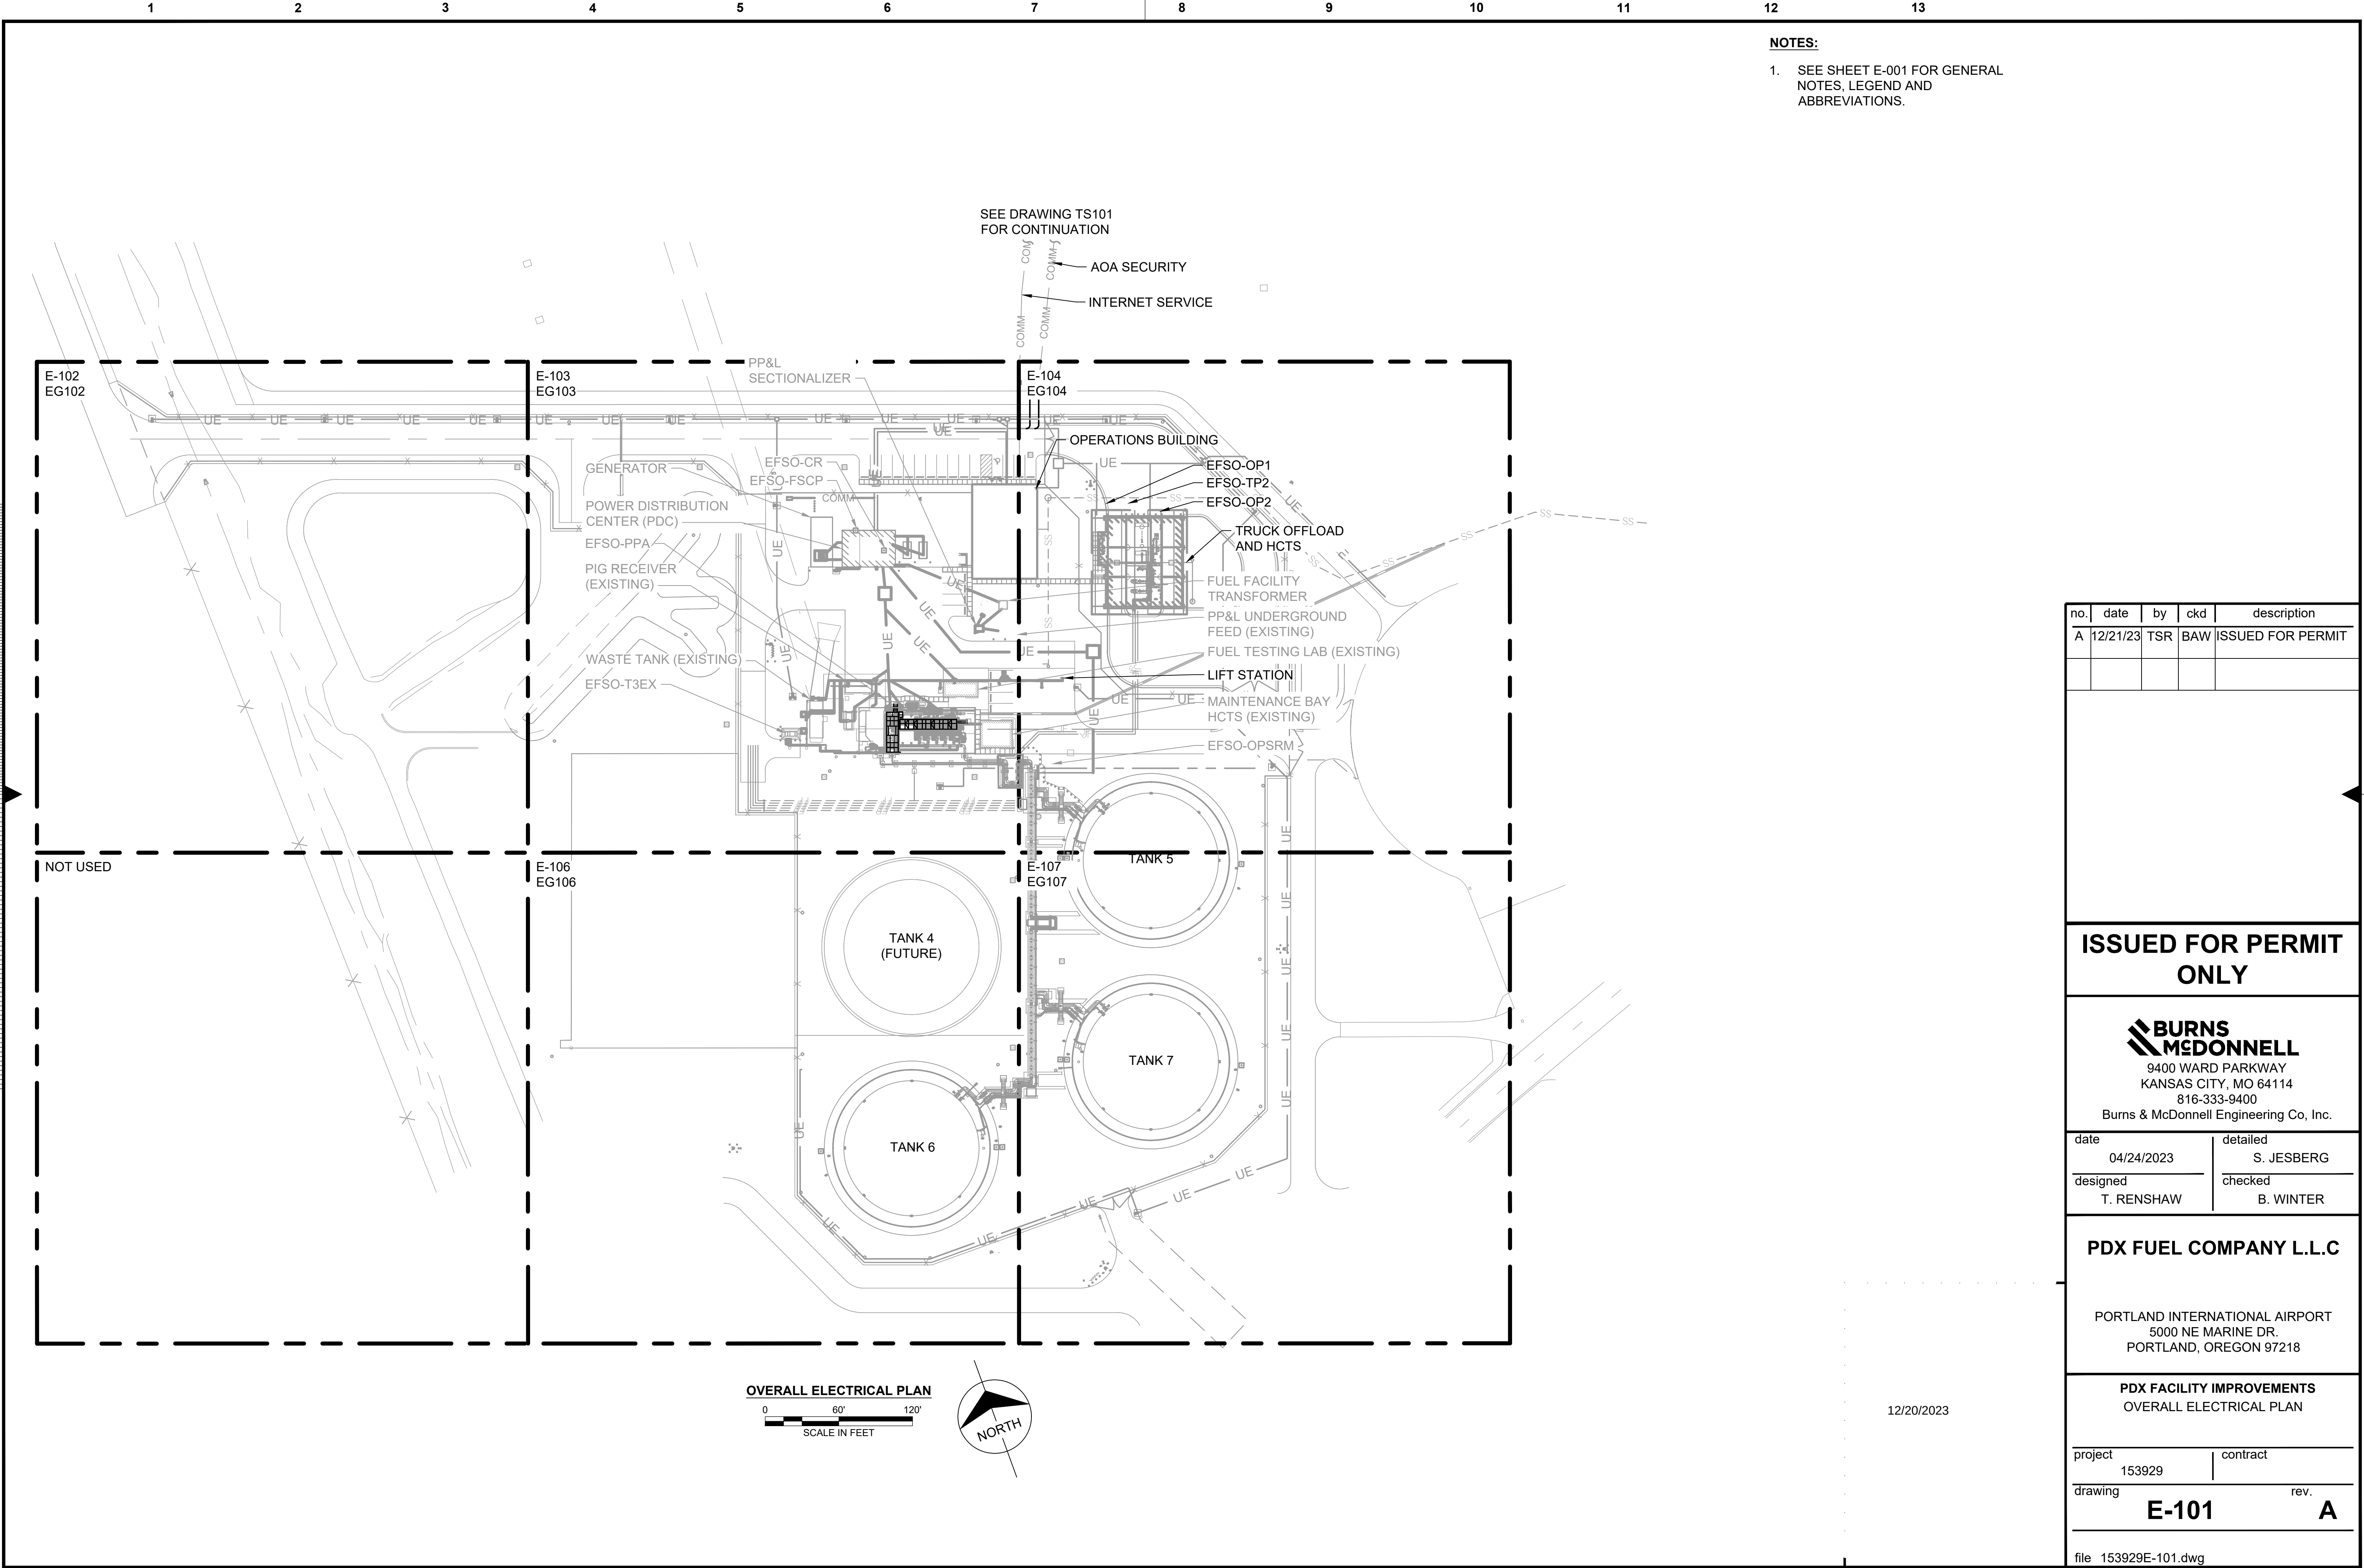

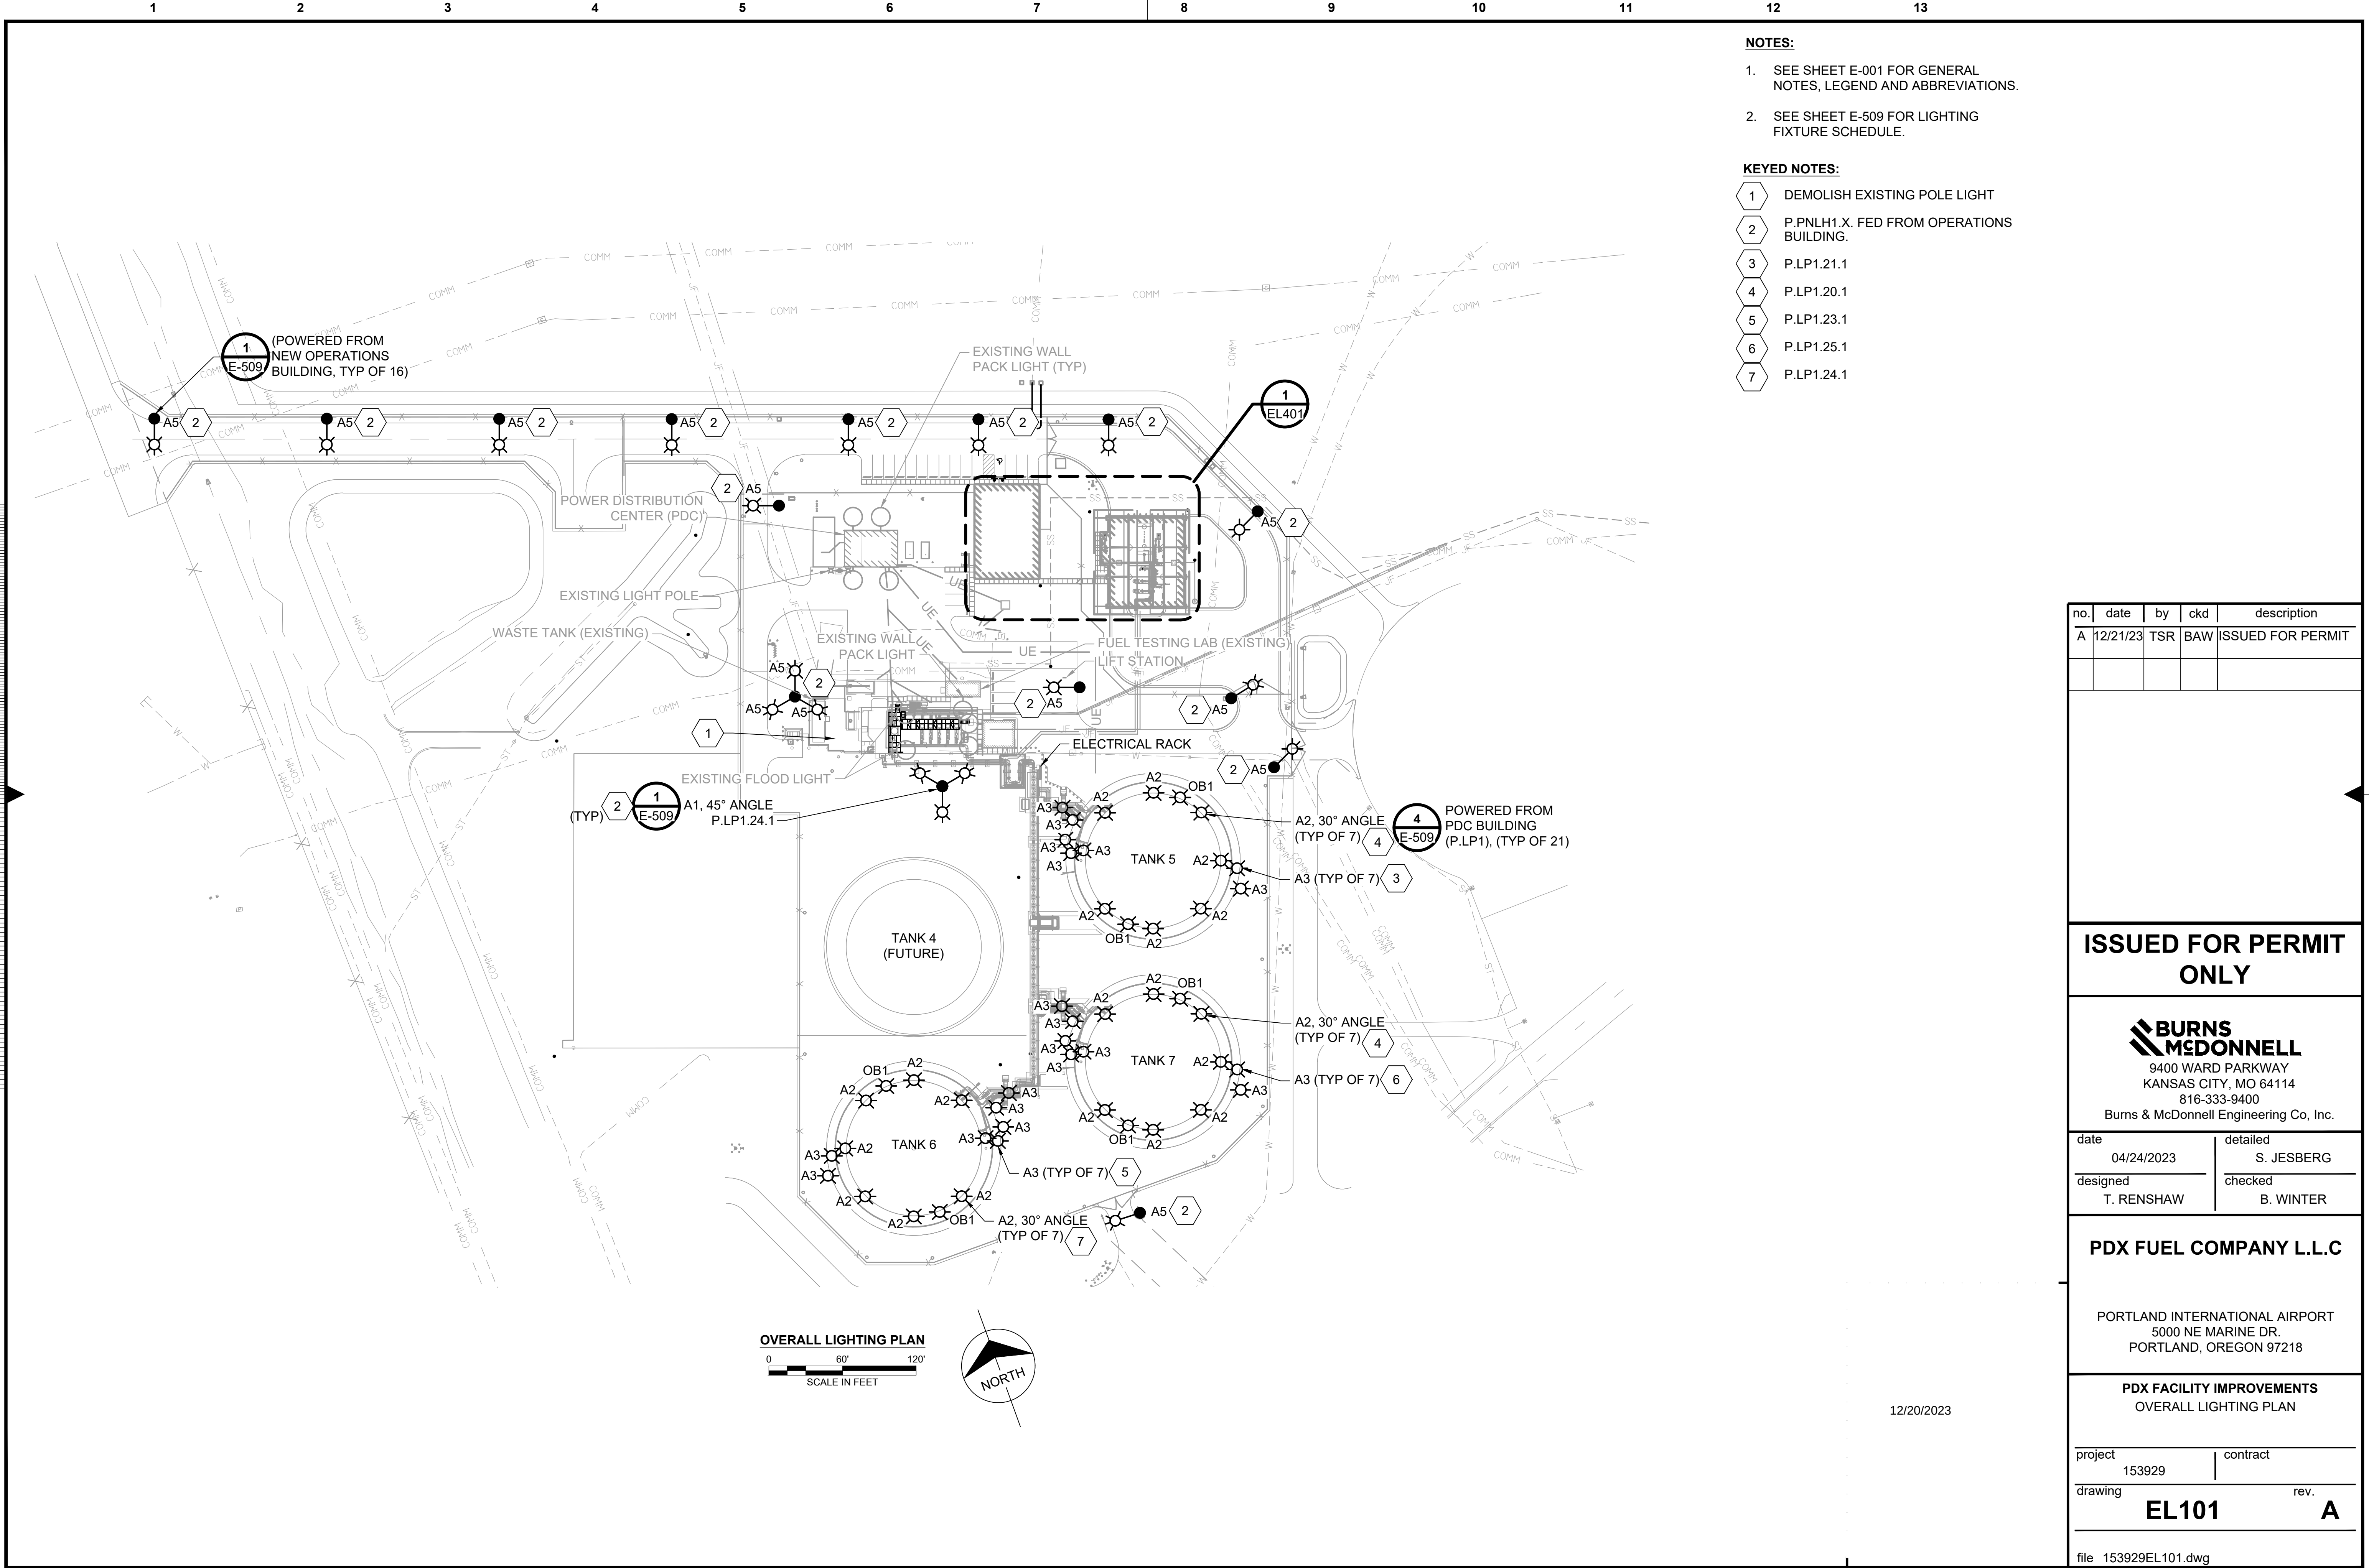

- NOTES:**
- SEE SHEET E-001 FOR GENERAL NOTES, LEGEND AND ABBREVIATIONS.
 - SEE SHEET E-509 FOR LIGHTING FIXTURE SCHEDULE.

- KEYED NOTES:**
- 1 DEMOLISH EXISTING POLE LIGHT
 - 2 P.PNLH1.X. FED FROM OPERATIONS BUILDING.
 - 3 P.LP1.21.1
 - 4 P.LP1.20.1
 - 5 P.LP1.23.1
 - 6 P.LP1.25.1
 - 7 P.LP1.24.1

no.	date	by	ckd	description
A	12/21/23	TSR	BAW	ISSUED FOR PERMIT

ISSUED FOR PERMIT
ONLY



9400 WARD PARKWAY
KANSAS CITY, MO 64114
816-333-9400
Burns & McDonnell Engineering Co., Inc.

date	04/24/2023	detailed	S. JESBERG
designed	T. RENSHAW	checked	B. WINTER


PDX FUEL COMPANY L.L.C

PORTLAND INTERNATIONAL AIRPORT
5000 NE MARINE DR.
PORTLAND, OREGON 97218

PDX FACILITY IMPROVEMENTS
OVERALL LIGHTING PLAN

project	153929	contract	
drawing	EL101	rev.	A

file 153929EL101.dwg

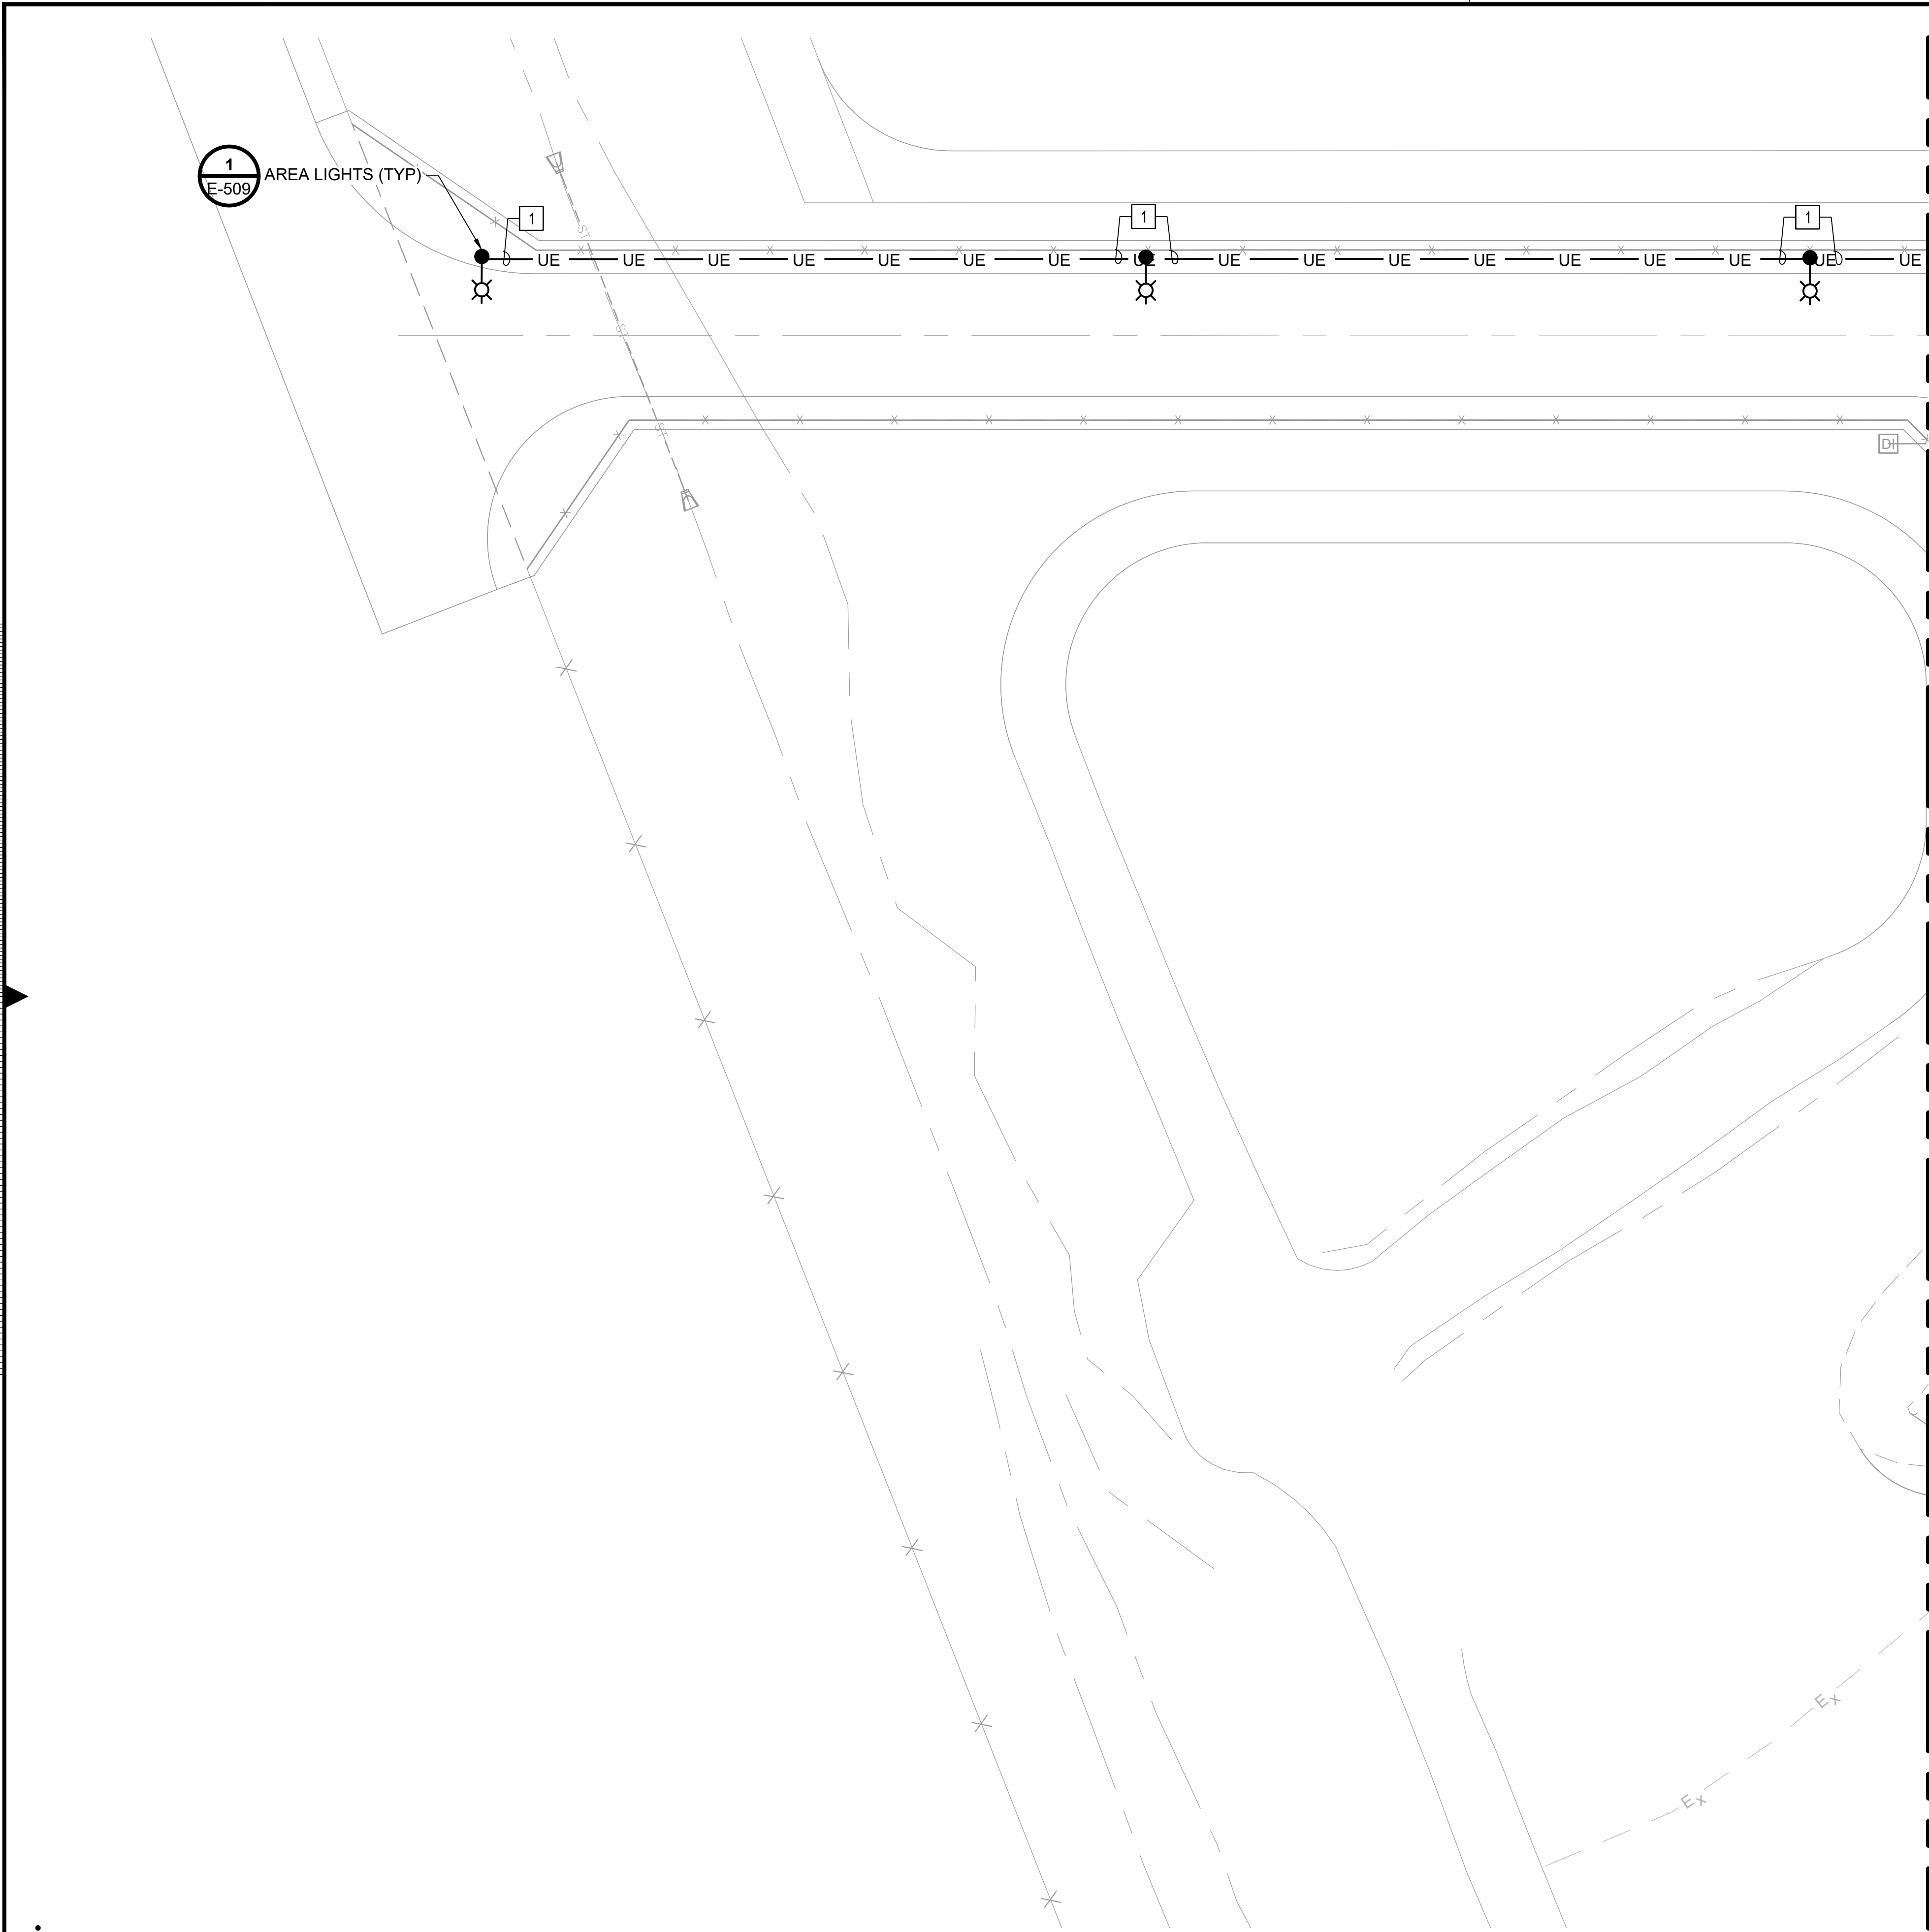

1. 2"C: (M1, N1) P.PNLH1.X. (FED FROM OPERATIONS BUILDING)

KEYPLAN

A keyplan diagram of the engine compartment. The diagram is divided into six numbered regions: 1 (hatched area on the left), 2 (top center), 3 (top right), 4 (bottom left), 5 (bottom center), and 6 (bottom right). Various components are labeled with letters and numbers, including '12a', '12b', '12c', '12d', '12e', '12f', '12g', '12h', '12i', '12j', '12k', '12l', '12m', '12n', '12o', '12p', '12q', '12r', '12s', '12t', '12u', '12v', '12w', '12x', '12y', '12z', '12aa', '12ab', '12ac', '12ad', '12ae', '12af', '12ag', '12ah', '12ai', '12aj', '12ak', '12al', '12am', '12an', '12ao', '12ap', '12aq', '12ar', '12as', '12at', '12au', '12av', '12aw', '12ax', '12ay', '12az', '12ba', '12bb', '12bc', '12bd', '12be', '12bf', '12bg', '12bh', '12bi', '12bj', '12bk', '12bl', '12bm', '12bn', '12bo', '12bp', '12bq', '12br', '12bs', '12bt', '12bu', '12bv', '12bw', '12bx', '12by', '12bz', '12ca', '12cb', '12cc', '12cd', '12ce', '12cf', '12cg', '12ch', '12ci', '12cj', '12ck', '12cl', '12cm', '12cn', '12co', '12cp', '12cq', '12cr', '12cs', '12ct', '12cu', '12cv', '12cw', '12cx', '12cy', '12cz', '12da', '12db', '12dc', '12dd', '12de', '12df', '12dg', '12dh', '12di', '12dj', '12dk', '12dl', '12dm', '12dn', '12do', '12dp', '12dq', '12dr', '12ds', '12dt', '12du', '12dv', '12dw', '12dx', '12dy', '12dz', '12ea', '12eb', '12ec', '12ed', '12ee', '12ef', '12eg', '12eh', '12ei', '12ej', '12ek', '12el', '12em', '12en', '12eo', '12ep', '12eq', '12er', '12es', '12et', '12eu', '12ev', '12ew', '12ex', '12ey', '12ez', '12fa', '12fb', '12fc', '12fd', '12fe', '12ff', '12fg', '12fh', '12fi', '12fj', '12fk', '12fl', '12fm', '12fn', '12fo', '12fp', '12fq', '12fr', '12fs', '12ft', '12fu', '12fv', '12fw', '12fx', '12fy', '12fz', '12ga', '12gb', '12gc', '12gd', '12ge', '12gf', '12gg', '12gh', '12gi', '12gj', '12gk', '12gl', '12gm', '12gn', '12go', '12gp', '12gq', '12gr', '12gs', '12gt', '12gu', '12gv', '12gw', '12gx', '12gy', '12gz', '12ha', '12hb', '12hc', '12hd', '12he', '12hf', '12hg', '12hh', '12hi', '12hj', '12hk', '12hl', '12hm', '12hn', '12ho', '12hp', '12hq', '12hr', '12hs', '12ht', '12hu', '12hv', '12hw', '12hx', '12hy', '12hz', '12ia', '12ib', '12ic', '12id', '12ie', '12if', '12ig', '12ih', '12ii', '12ij', '12ik', '12il', '12im', '12in', '12io', '12ip', '12iq', '12ir', '12is', '12it', '12iu', '12iv', '12iw', '12ix', '12iy', '12iz', '12ja', '12jb', '12jc', '12jd', '12je', '12jf', '12jg', '12jh', '12ji', '12jj', '12jk', '12jl', '12jm', '12jn', '12jo', '12jp', '12jq', '12jr', '12js', '12jt', '12ju', '12jv', '12jw', '12jx', '12jy', '12jz', '12ka', '12kb', '12kc', '12kd', '12ke', '12kf', '12kg', '12kh', '12ki', '12kj', '12kk', '12kl', '12km', '12kn', '12ko', '12kp', '12kq', '12kr', '12ks', '12kt', '12ku', '12kv', '12kw', '12kx', '12ky', '12kz', '12la', '12lb', '12lc', '12ld', '12le', '12lf', '12lg', '12lh', '12li', '12lj', '12lk', '12ll', '12lm', '12ln', '12lo', '12lp', '12lq', '12lr', '12ls', '12lt', '12lu', '12lv', '12lw', '12lx', '12ly', '12lz', '12ma', '12mb', '12mc', '12md', '12me', '12mf', '12mg', '12mh', '12mi', '12mj', '12mk', '12ml', '12mm', '12mn', '12mo', '12mp', '12mq', '12mr', '12ms', '12mt', '12mu', '12mv', '12mw', '12mx', '12my', '12mz', '12na', '12nb', '12nc', '12nd', '12ne', '12nf', '12ng', '12nh', '12ni', '12nj', '12nk', '12nl', '12nm', '12nn', '12no', '12np', '12nq', '12nr', '12ns', '12nt', '12nu', '12nv', '12nw', '12nx', '12ny', '12nz', '12oa', '12ob', '12oc', '12od', '12oe', '12of', '12og', '12oh', '12oi', '12oj', '12ok', '12ol', '12om', '12on', '12oo', '12op', '12oq', '12or', '12os', '12ot', '12ou', '12ov', '12ow', '12ox', '12oy', '12oz', '12pa', '12pb', '12pc', '12pd', '12pe', '12pf', '12pg', '12ph', '12pi', '12pj', '12pk', '12pl', '12pm', '12pn', '12po', '12pp', '12pq', '12pr', '12ps', '12pt', '12pu', '12pv', '12pw', '12px', '12py', '12pz', '12qa', '12qb', '12qc', '12qd', '12qe', '12qf', '12qg', '12qh', '12qi', '12qj', '12qk', '12ql', '12qm', '12qn', '12qo', '12qp', '12qq', '12qr', '12qs', '12qt', '12qu', '12qv', '12qw', '12qx', '12qy', '12qz', '12ra', '12rb', '12rc', '12rd', '12re', '12rf', '12rg', '12rh', '12ri', '12rj', '12rk', '12rl', '12rm', '12rn', '12ro', '12rp', '12rq', '12rr', '12rs', '12rt', '12ru', '12rv', '12rw', '12rx', '12ry', '12rz', '12sa', '12sb', '12sc', '12sd', '12se', '12sf', '12sg', '12sh', '12si', '12sj', '12sk', '12sl', '12sm', '12sn', '12so', '12sp', '12sq', '12sr', '12ss', '12st', '12su', '12sv', '12sw', '12sx', '12sy', '12sz', '12ta', '12tb', '12tc', '12td', '12te', '12tf', '12tg', '12th', '12ti', '12tj', '12tk', '12tl', '12tm', '12tn', '12to', '12tp', '12tq', '12tr', '12ts', '12tt', '12tu', '12tv', '12tw', '12tx', '12ty', '12tz', '12ua', '12ub', '12uc', '12ud', '12ue', '12uf', '12ug', '12uh', '12ui', '12uj', '12uk', '12ul', '12um', '12un', '12uo', '12up', '12uq', '12ur', '12us', '12ut', '12uu', '12uv', '12uw', '12ux', '12uy', '12uz', '12va', '12vb', '12vc', '12vd', '12ve', '12vf', '12vg', '12vh', '12vi', '12vj', '12vk', '12vl', '12vm', '12vn', '12vo', '12vp', '12vq', '12vr', '12vs', '12vt', '12vu', '12vv', '12vw', '12vx', '12vy', '12vz', '12wa', '12wb', '12wc', '12wd', '12we', '12wf', '12wg', '12wh', '12wi', '12wj', '12wk', '12wl', '12wm', '12wn', '12wo', '12wp', '12wq', '12wr', '12ws', '12wt', '12wu', '12wv', '12ww', '12wx', '12wy', '12wz', '12xa', '12xb', '12xc', '12xd', '12xe', '12xf', '12xg', '12xh', '12xi', '12xj', '12xk', '12xl', '12xm', '12xn', '12xo', '12xp', '12xq', '12xr', '12xs', '12xt', '12xu', '12xv', '12xw', '12xx', '12xy', '12xz', '12ya', '12yb', '12yc', '12yd', '12ye', '12yf', '12yg', '12yh', '12yi', '12yj', '12yk', '12yl', '12ym', '12yn', '12yo', '12yp', '12yq', '12yr', '12ys', '12yt', '12yu', '12yv', '12yw', '12yx', '12yy', '12yz', '12za', '12zb', '12zc', '12zd', '12ze', '12zf', '12zg', '12zh', '12zi', '12zj', '12zk', '12zl', '12zm', '12zn', '12zo', '12zp', '12zq', '12zr', '12zs', '12zt', '12zu', '12zv', '12zw', '12zx', '12zy', '12zz'. The diagram also shows various mechanical parts like the alternator, water pump, and other engine components.




Burns & McDonnell Engineering Co, Inc.

date 04/24/2023	detailed S. JESBERG
designed T. RENSHAW	checked B. WINTER

PORTLAND INTERNATIONAL AIRPORT
5000 NE MARINE DR.
PORTLAND, OREGON 97218


file 153929E-102.dwg

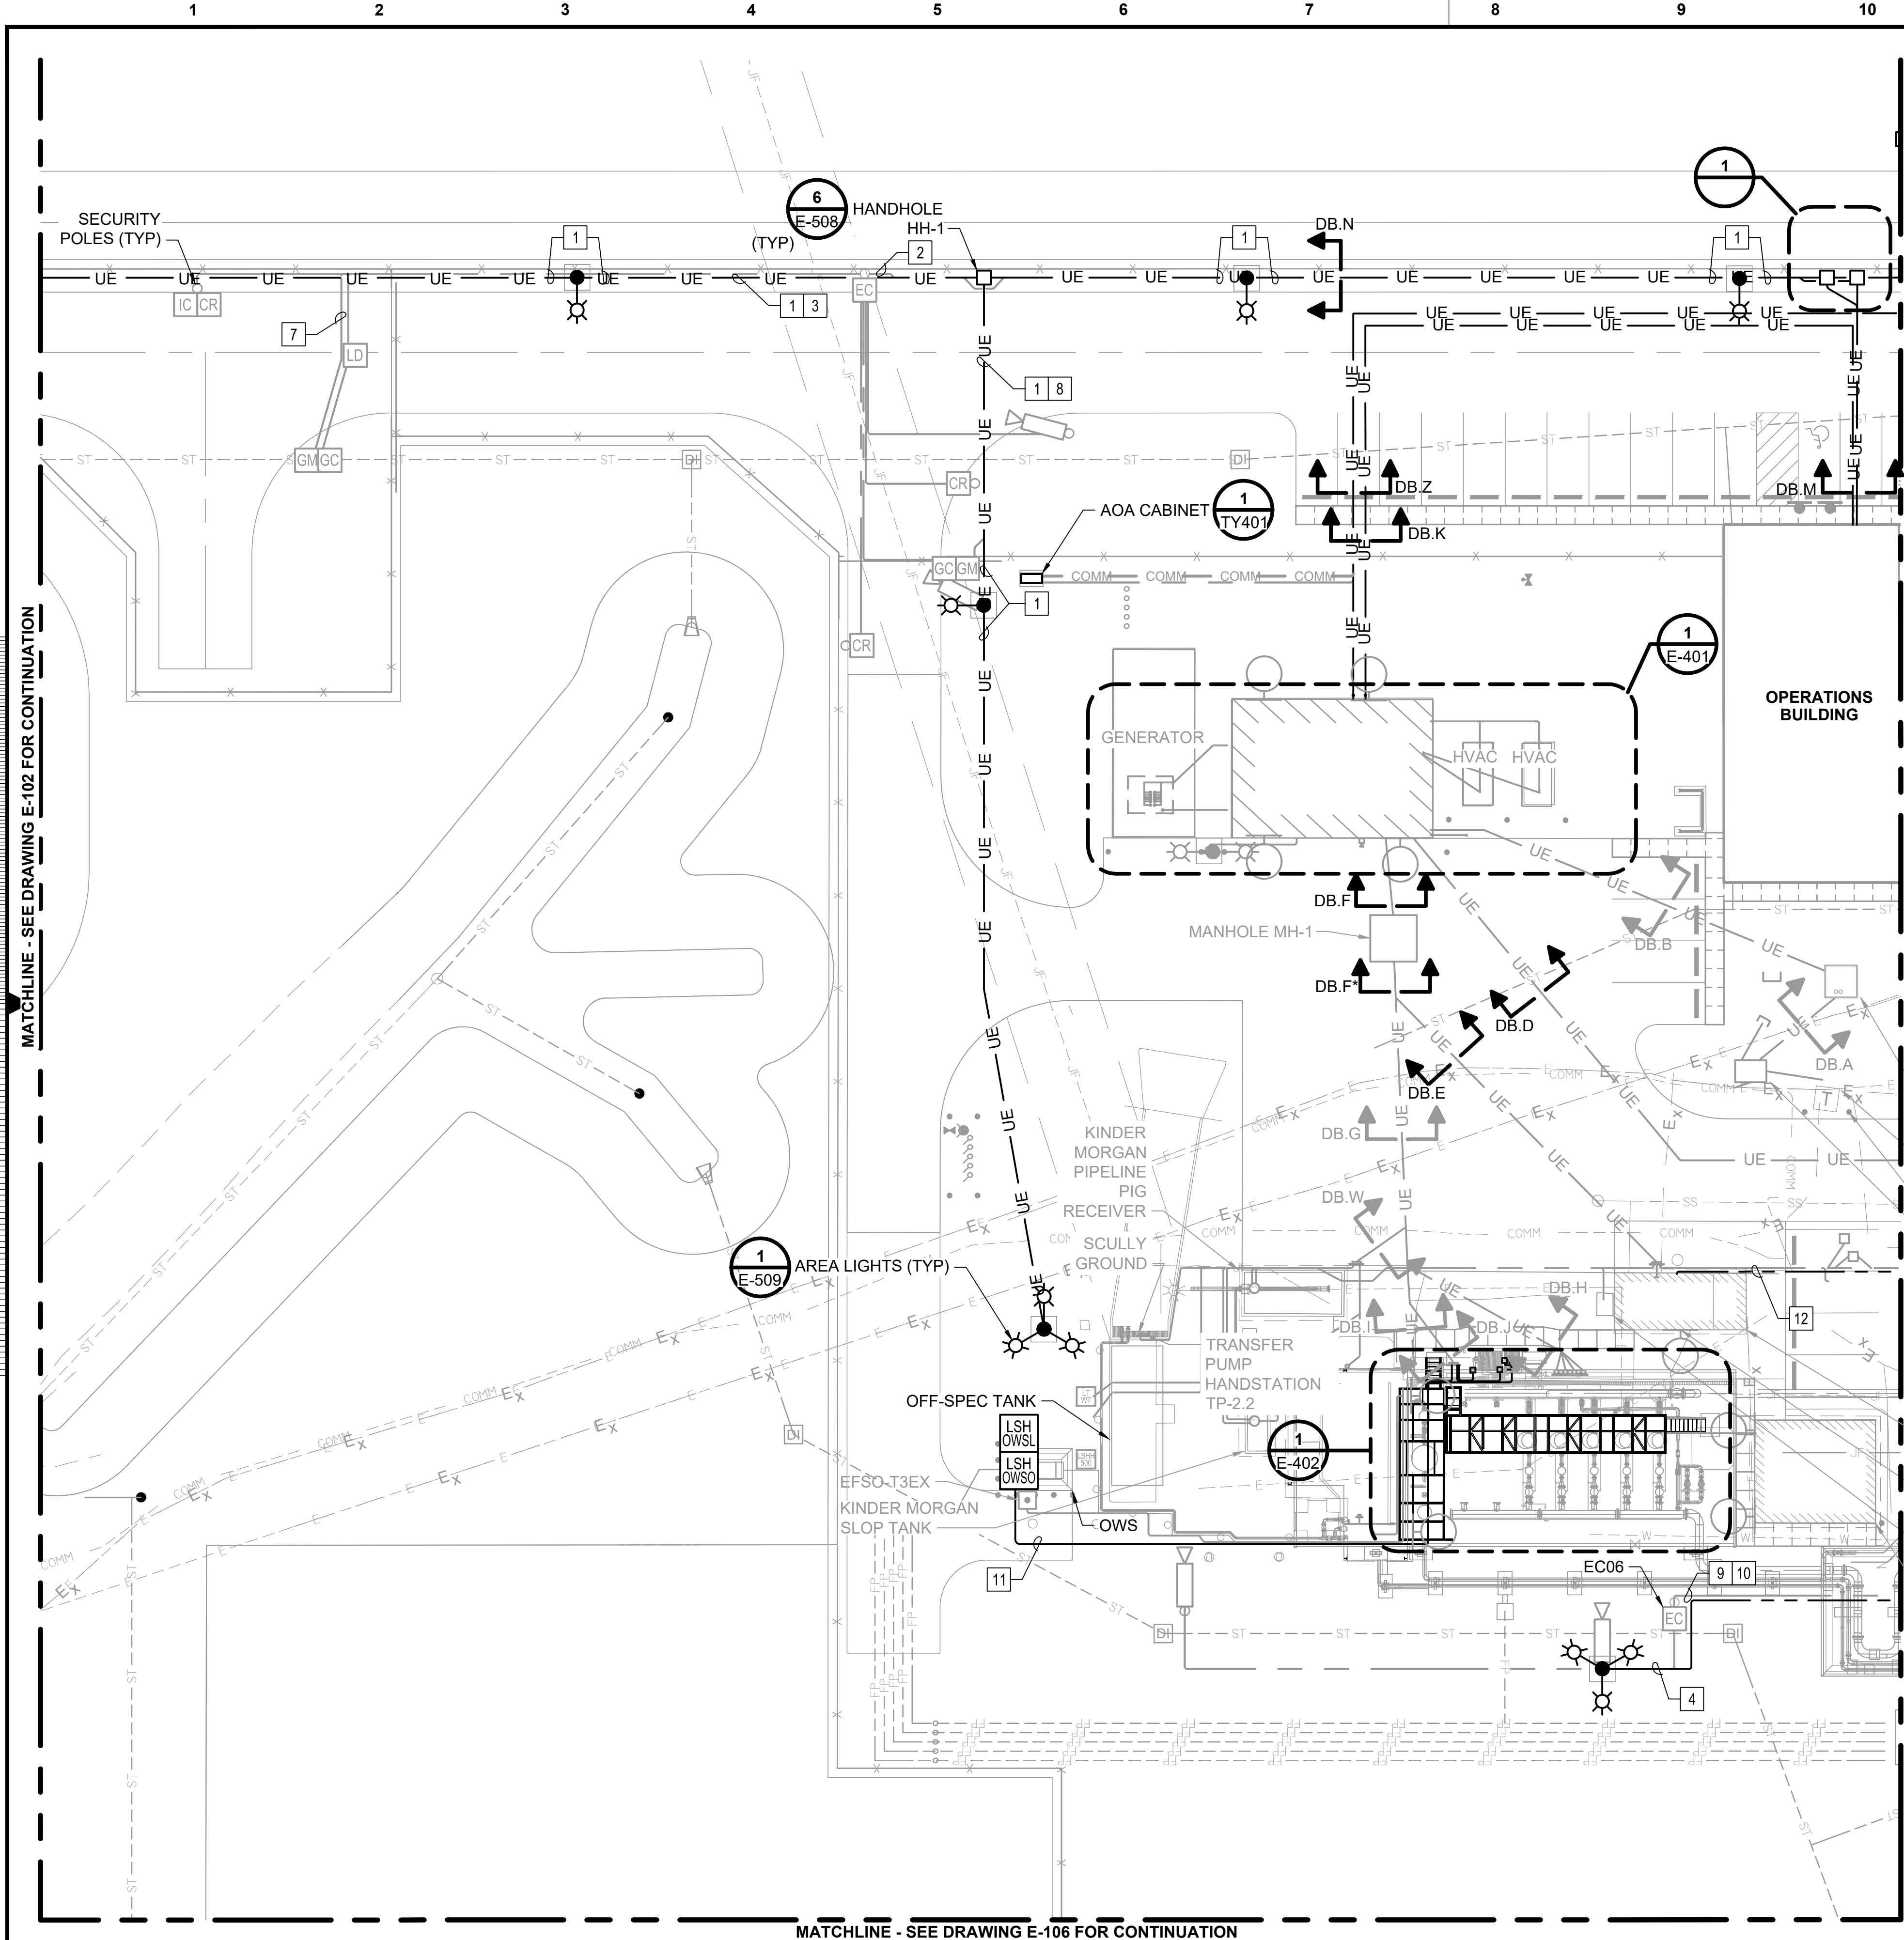


- NOTES:**
- SEE SHEET E-001 FOR GENERAL NOTES, LEGEND AND ABBREVIATIONS.
 - CONDUIT ROUTING IS SCHEMATIC IN NATURE.
 - SEE SHEETS E-301 - E-305 FOR DUCTBANK SECTIONS.
 - SEE TS SERIES FOR COMMUNICATION AND TY SERIES FOR SECURITY. TS AND TY CONTENT IS SCREENED BACK FOR CLARITY.

- CONDUIT SCHEDULE:**
- 2"C: (M1, N1) P.PNLH1.X. (FED FROM OPERATIONS BUILDING)
 - 2"C: (M2, N2) IC.OPS.EC01
 - 2"C: P.PA2.57 (FED FROM OPERATIONS BUILDING)
 - 2"C: P.PNLH1.X. FED FROM OPERATIONS BUILDING.
 - 2"C: (M5, N5) P.PA2.79 (FED FROM OPERATIONS BUILDING)
 - 2"C: (M3, N3) P.PA.69, P.PA.57 (FED FROM OPERATIONS BUILDING)
 - 2"C: (M4, N4) SPARE
 - 2"C: P.PA.69 (FED FROM OPERATIONS BUILDING)
 - 2"C: IC.OPS.EC06
 - 2"C: P.PA2.75(EC02, EC03, EC06)
 - 3/4"C: C.CSP.OWS
 - 2"C: P.P1.31, P.P1.32

- KEYED NOTES:**
- 1 FLOW METER TO BE SALVAGED

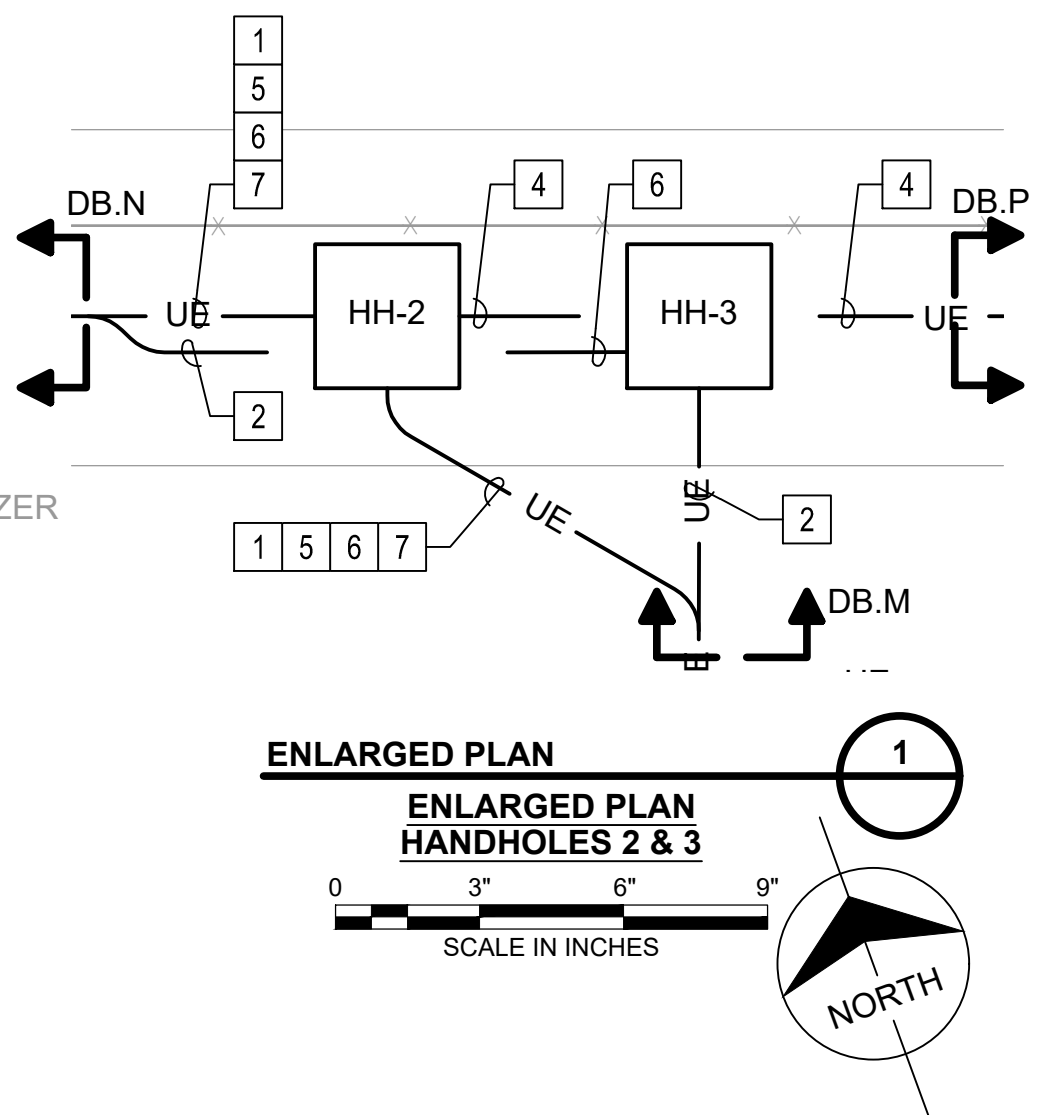

no.	date	by	ckd	description
A	12/21/23	TSR	BAW	ISSUED FOR PERMIT

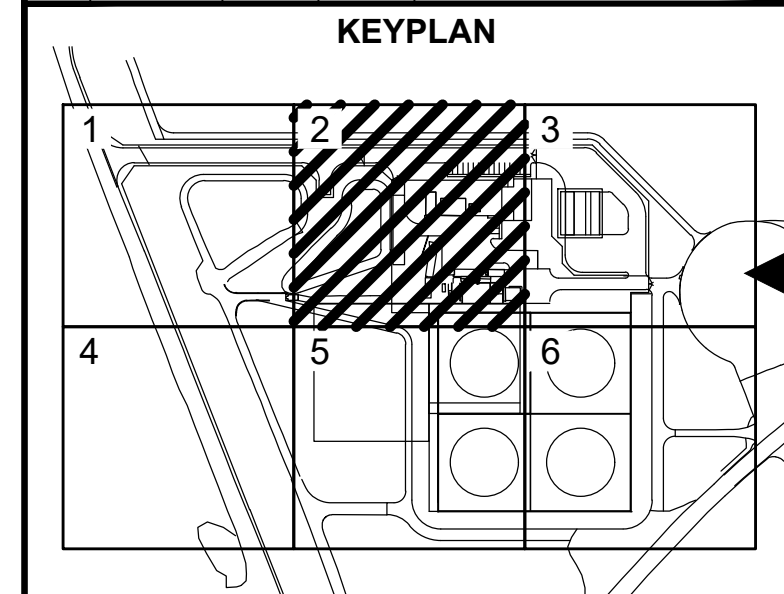

ISSUED FOR PERMIT ONLY

BURNS MEDONNELL
9400 WARD PARKWAY
KANSAS CITY, MO 64114
816-333-9400
Burns & McDonnell Engineering Co., Inc.

date	04/24/2023	detailed	S. JESBERG
designed	T. RENSHAW	checked	B. WINTER


PDX FUEL COMPANY L.L.C


PORTLAND INTERNATIONAL AIRPORT
5000 NE MARINE DR.
PORTLAND, OREGON 97218

**PDX FACILITY IMPROVEMENTS
ELECTRICAL PLAN**

project	153929	contract	
drawing	E-103	rev.	A


file 153929E-103.dwg

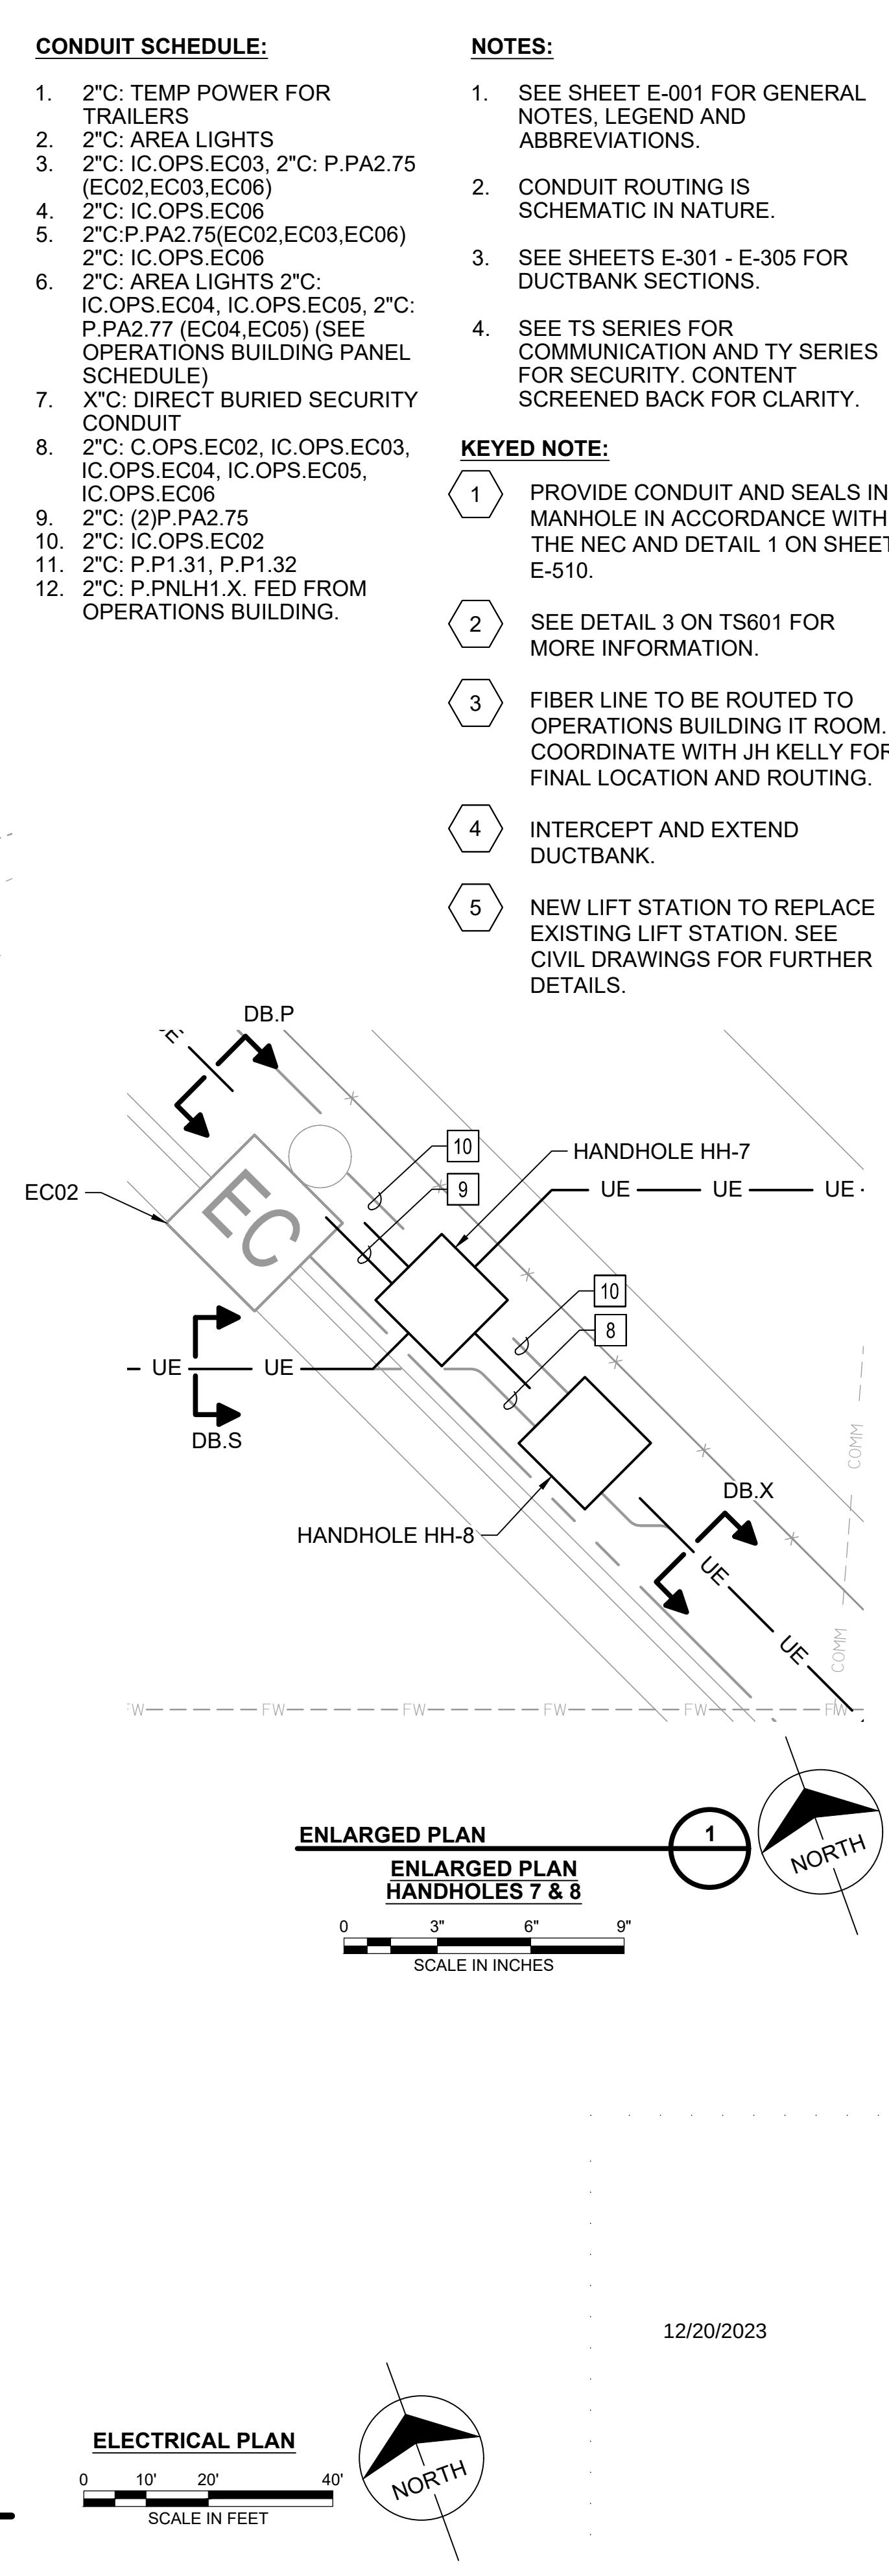

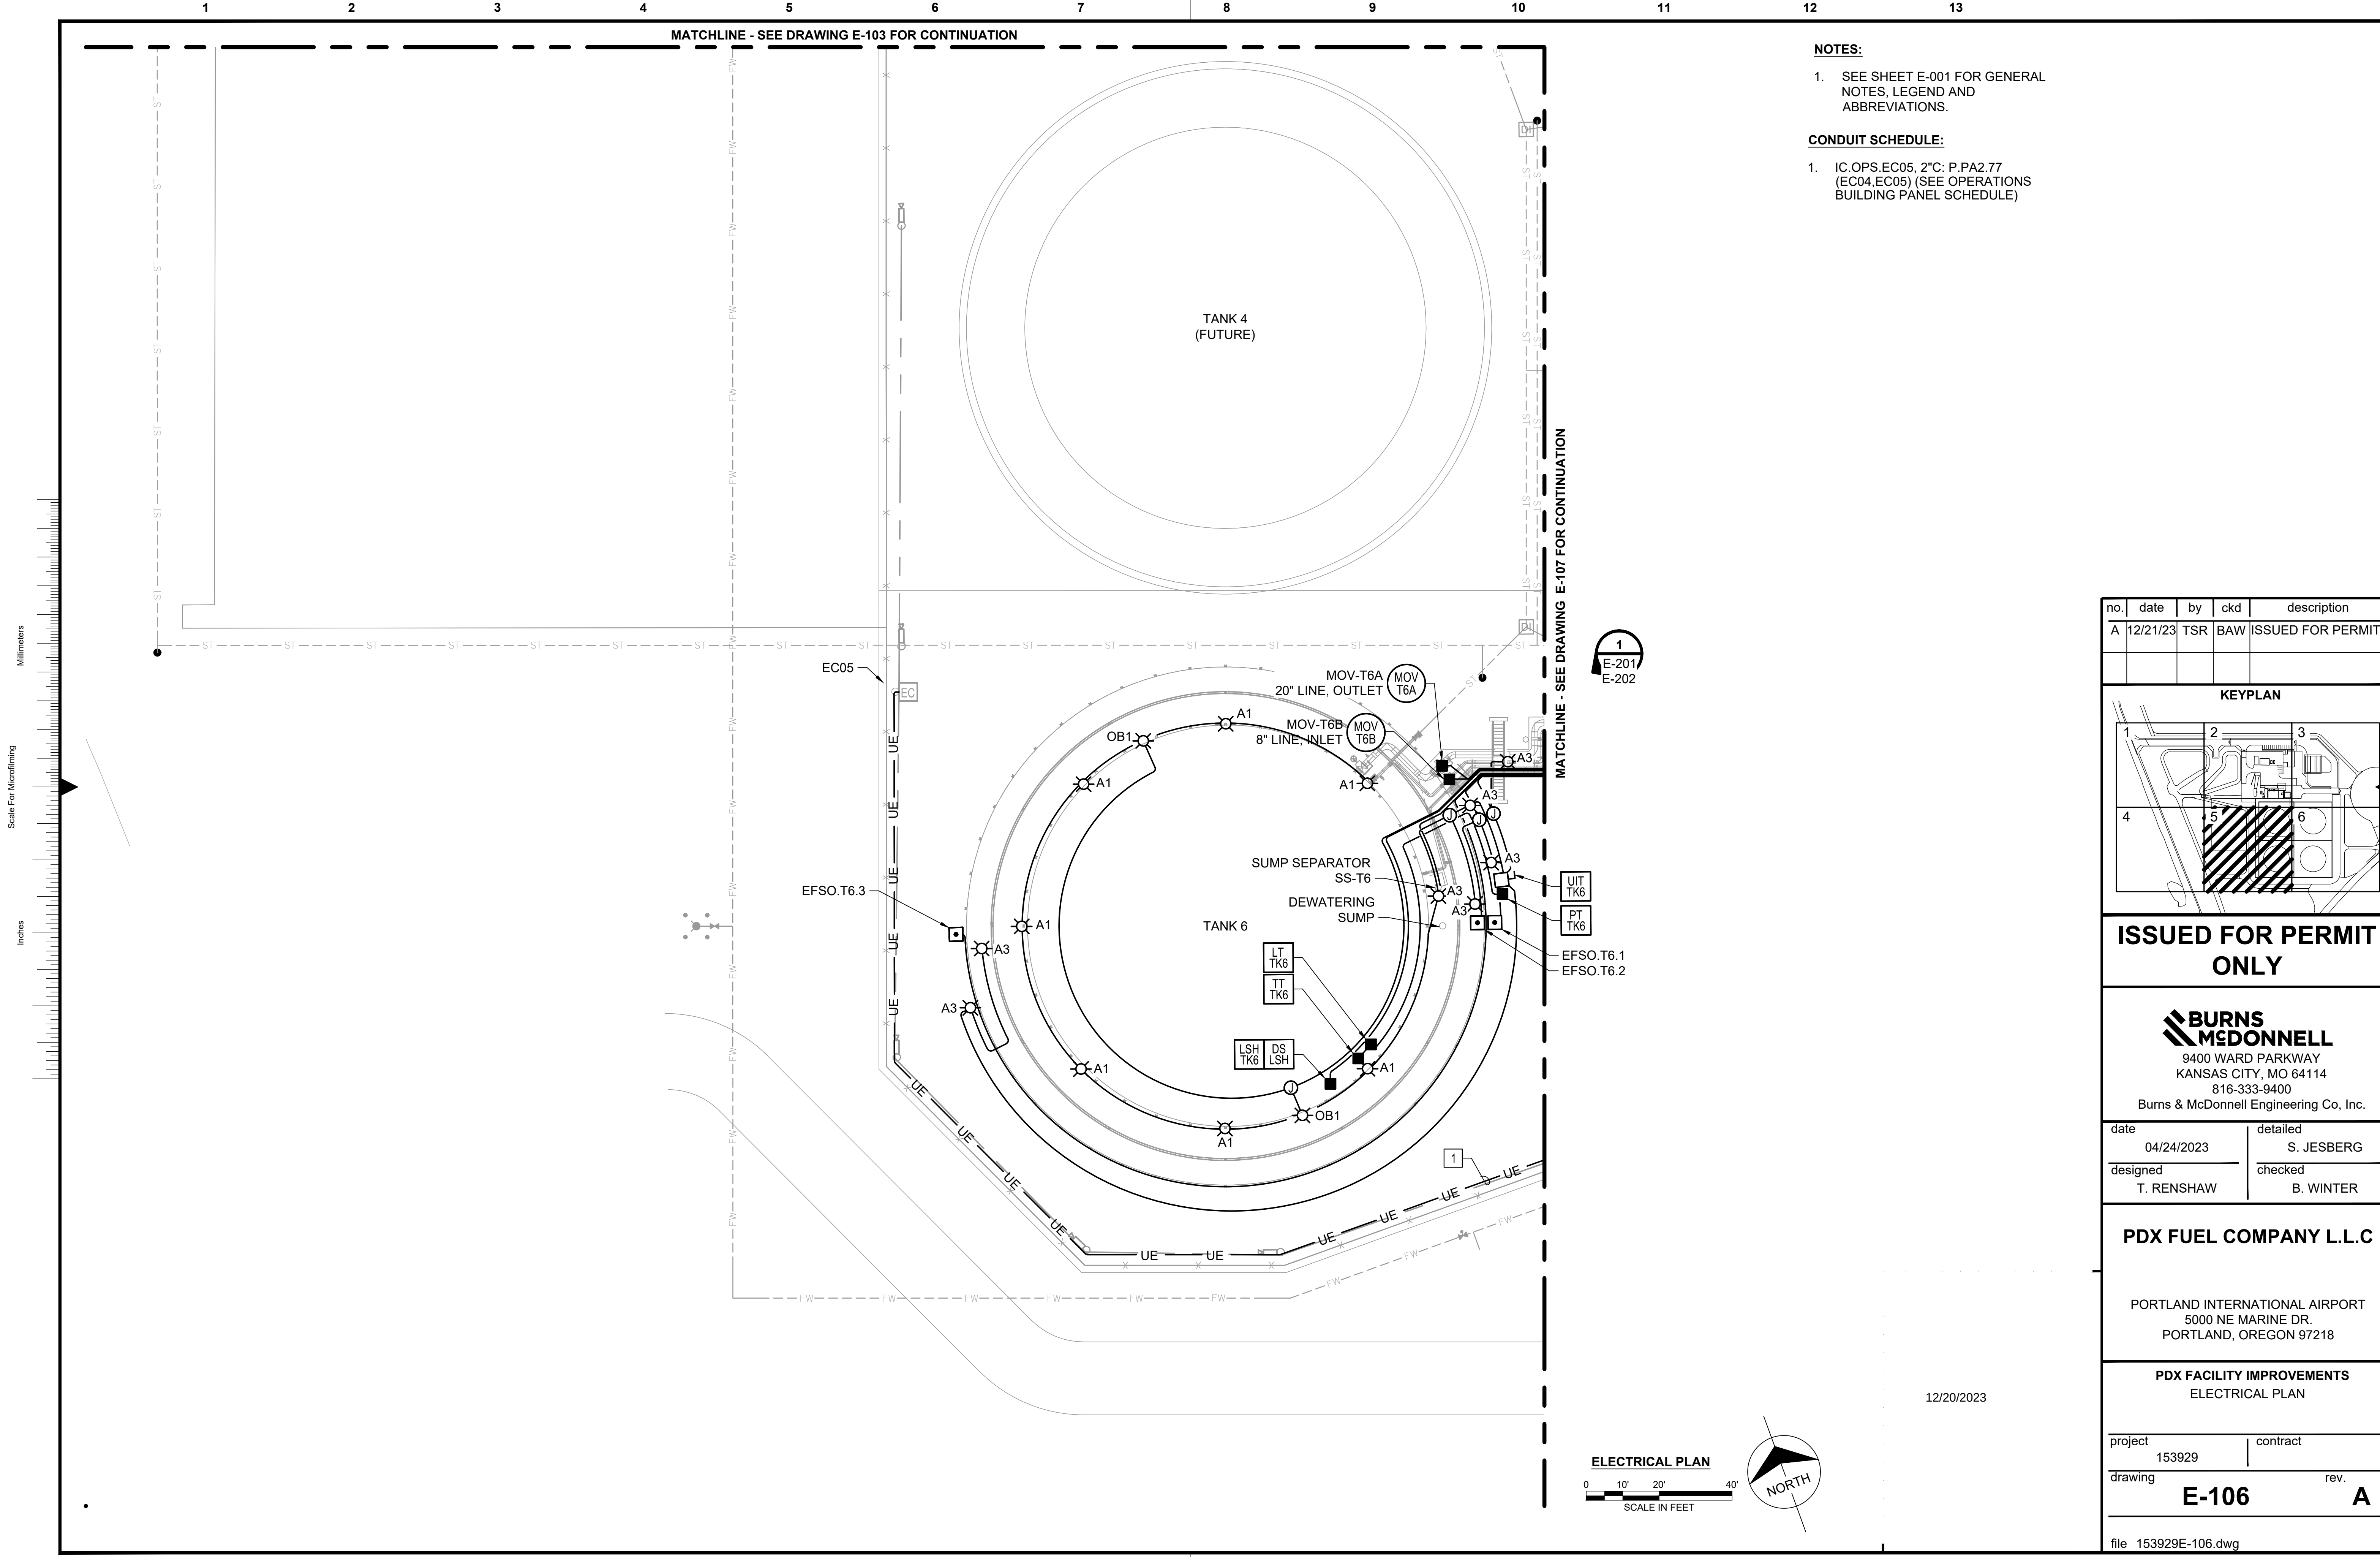

- NOTES:**
- SEE SHEET E-001 FOR GENERAL NOTES, LEGEND AND ABBREVIATIONS.
- CONDUIT SCHEDULE:**
- IC.OPS.EC05, 2"C: P.PA2.77 (EC04,EC05) (SEE OPERATIONS BUILDING PANEL SCHEDULE)

no.	date	by	ckd	description
A	12/21/23	TSR	BAW	ISSUED FOR PERMIT

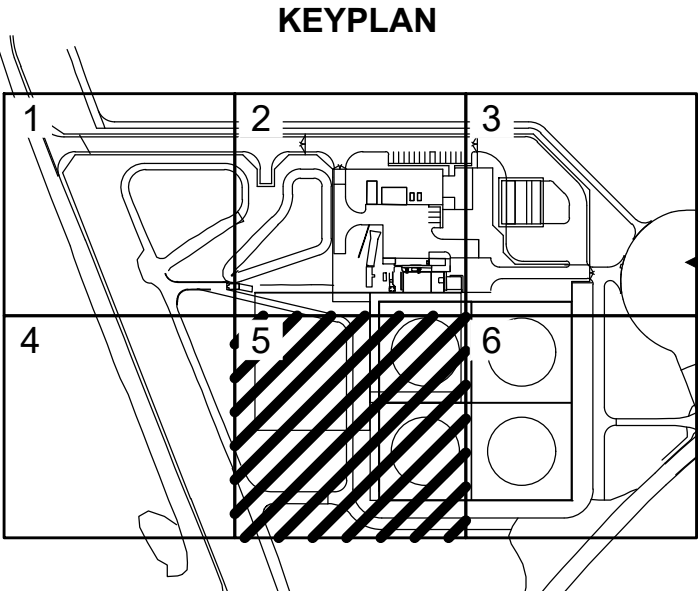

ISSUED FOR PERMIT ONLY



9400 WARD PARKWAY
KANSAS CITY, MO 64114
816-333-9400
Burns & McDonnell Engineering Co., Inc.

date	04/24/2023	detailed	S. JESBERG
designed	T. RENSHAW	checked	B. WINTER


PDX FUEL COMPANY L.L.C

PORTLAND INTERNATIONAL AIRPORT
5000 NE MARINE DR.
PORTLAND, OREGON 97218

**PDX FACILITY IMPROVEMENTS
ELECTRICAL PLAN**


project	153929	contract	
drawing	E-106	rev.	A

file 153929E-106.dwg

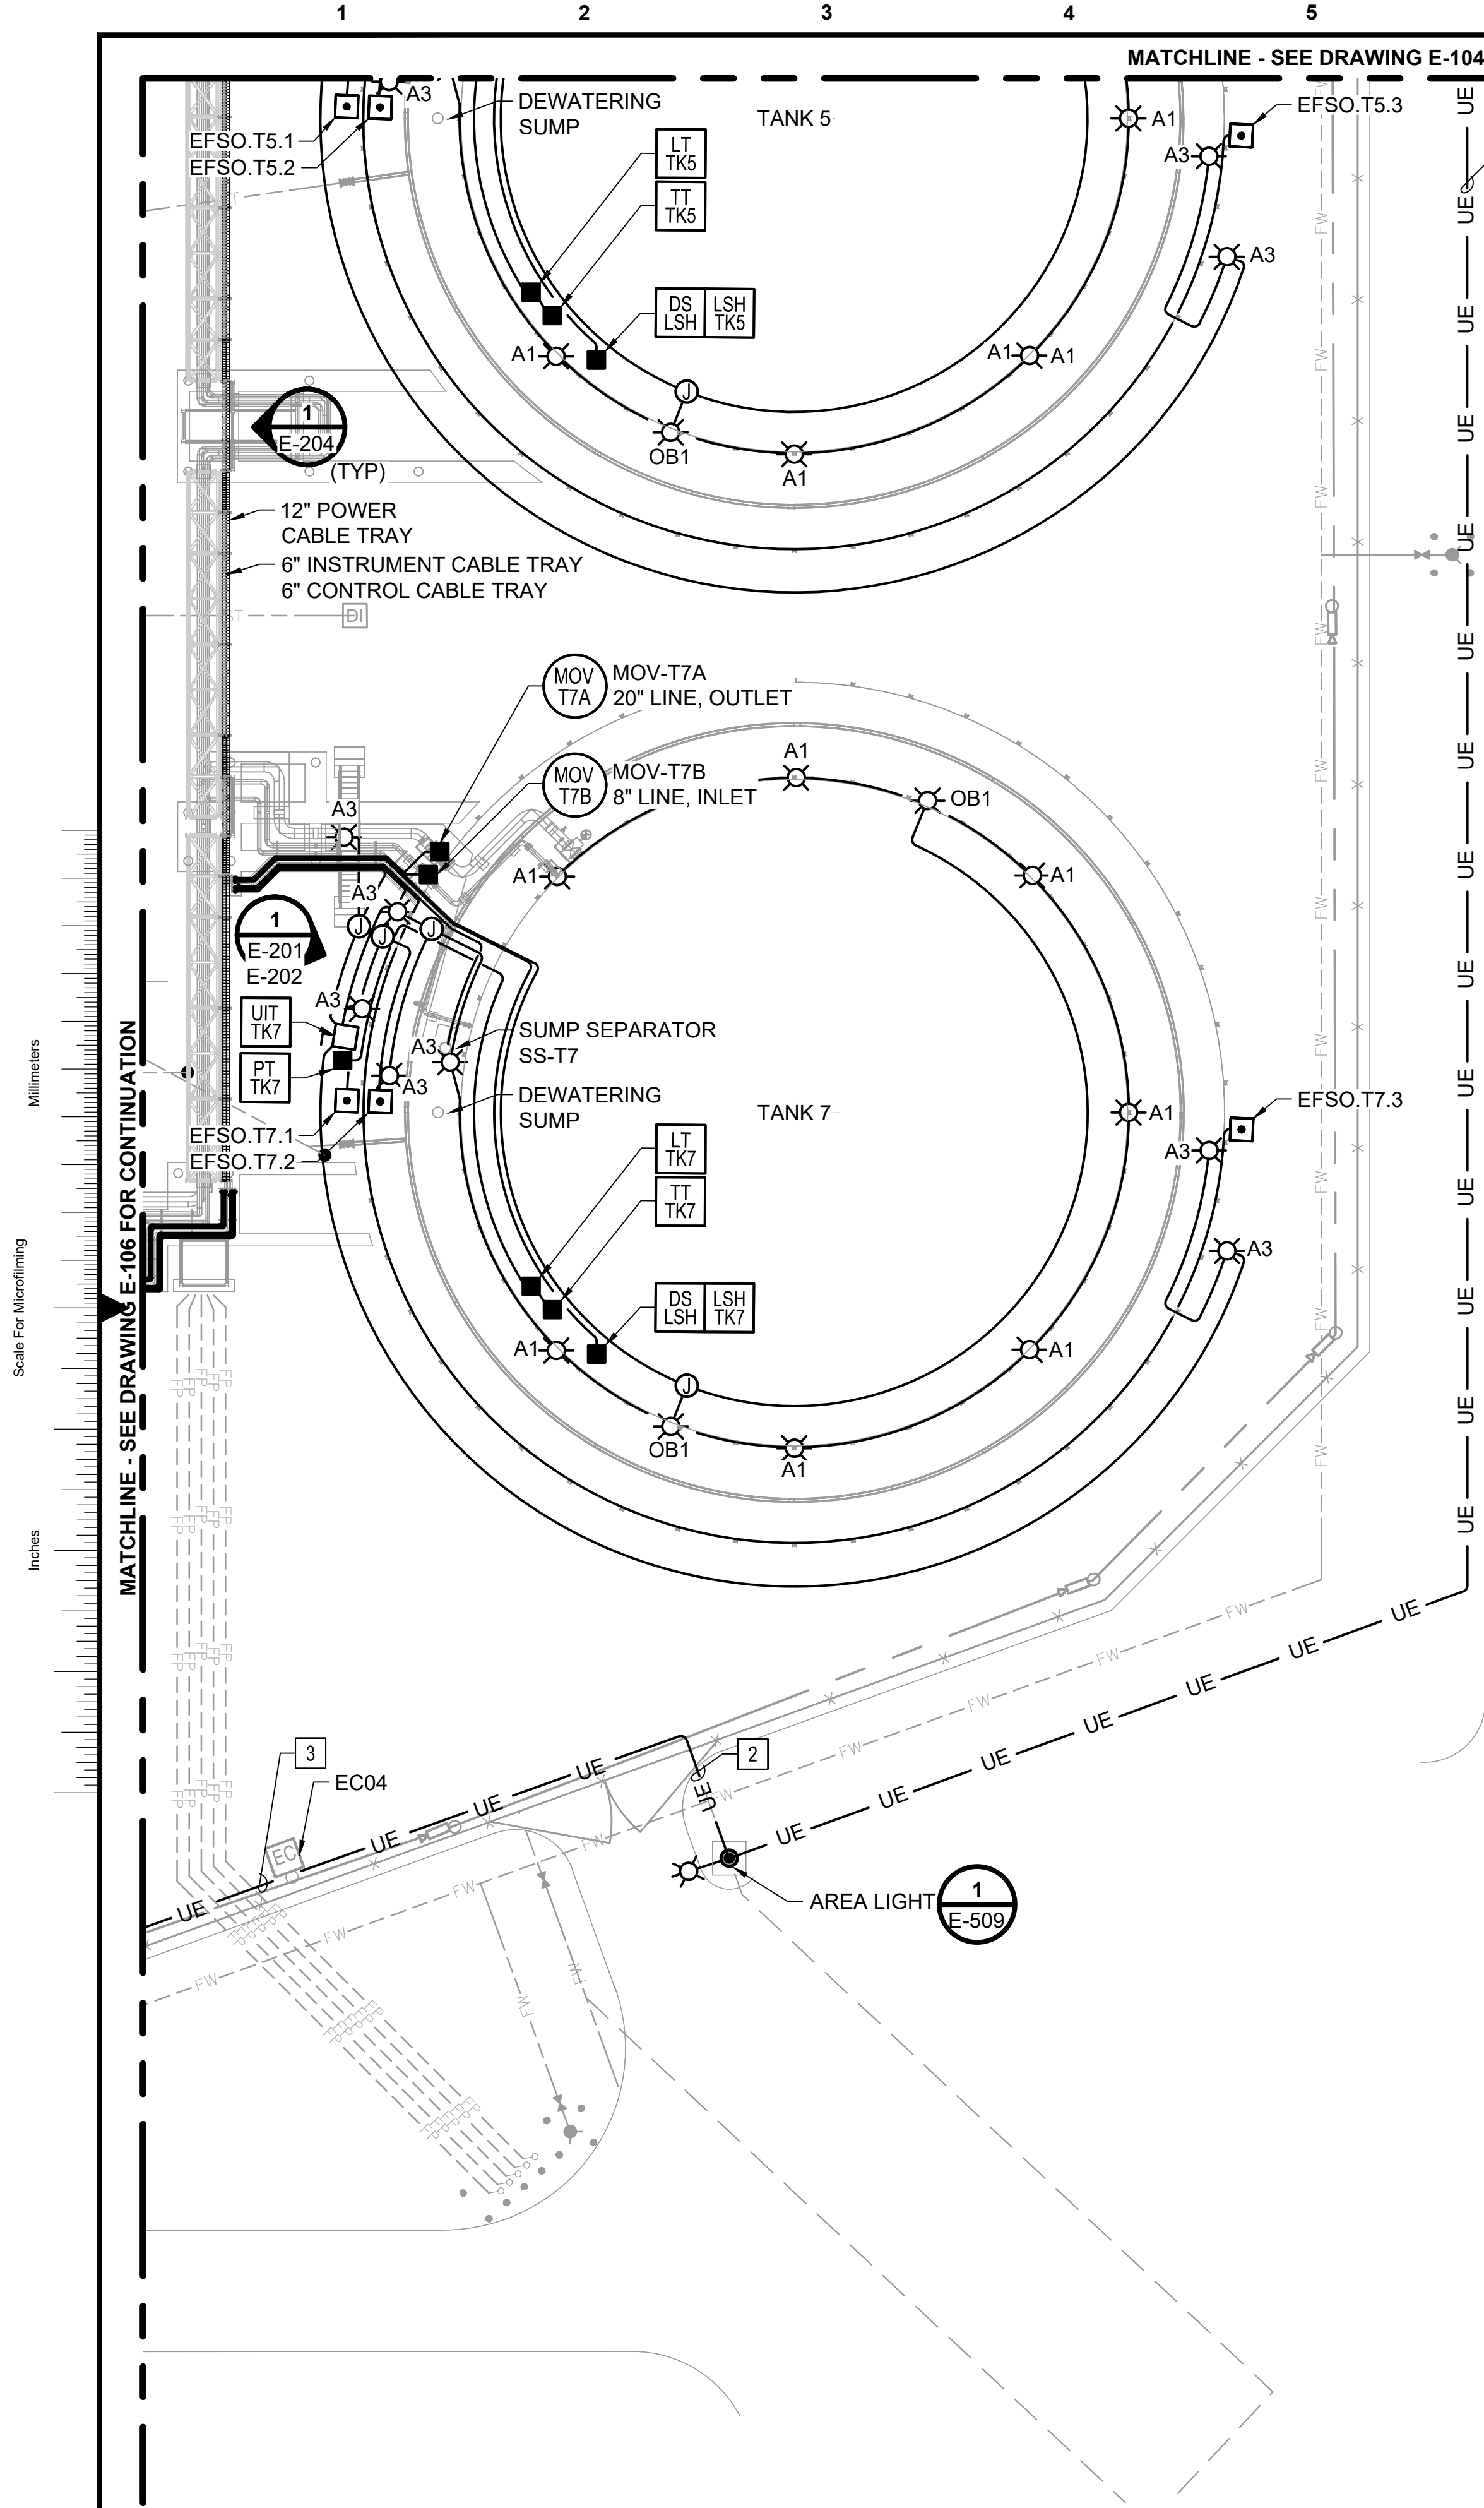

- NOTE:**
- SEE SHEET E-001 FOR GENERAL NOTES, LEGEND AND ABBREVIATIONS.
- CONDUIT SCHEDULE:**
- 2"C: AREA LIGHTS 2"C: IC.OPS.EC04, IC.OPS.EC05, 2"C: P.PA2.77 (EC04,EC05) (SEE OPERATIONS BUILDING PANEL SCHEDULE)
 - 2"C: IC.OPS.EC04, IC.OPS.EC05, 2"C: P.PA2.77 (EC04,EC05) (SEE OPERATIONS BUILDING PANEL SCHEDULE)
 - IC.OPS.EC05, 2"C: P.PA2.77 (EC04,EC05) (SEE OPERATIONS BUILDING PANEL SCHEDULE)

no.	date	by	ckd	description
A	12/21/23	TSR	BAW	ISSUED FOR PERMIT

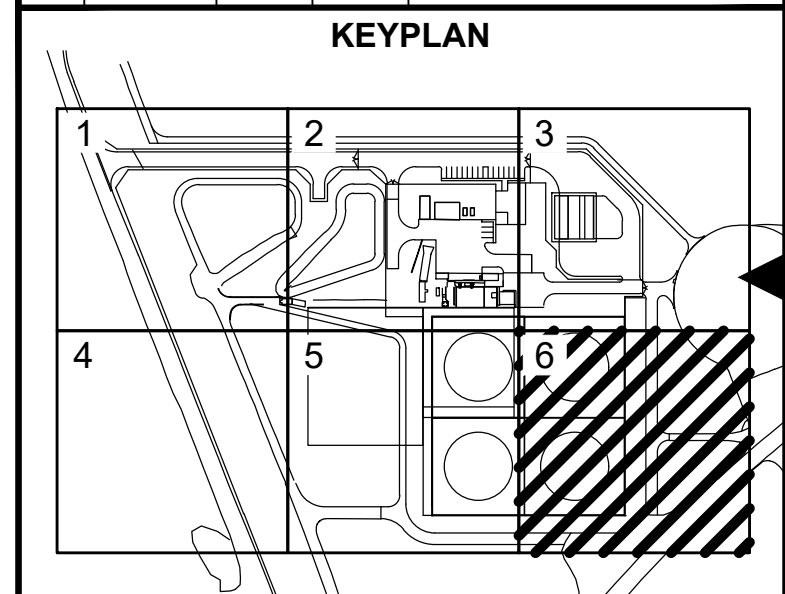

ISSUED FOR PERMIT ONLY

BURNS MCDONNELL
9400 WARD PARKWAY
KANSAS CITY, MO 64114
816-333-9400
Burns & McDonnell Engineering Co., Inc.

date	04/24/2023	detailed	S. JESBERG
designed	T. RENSHAW	checked	B. WINTER


PDX FUEL COMPANY L.L.C


PORTLAND INTERNATIONAL AIRPORT
5000 NE MARINE DR.
PORTLAND, OREGON 97218

**PDX FACILITY IMPROVEMENTS
ELECTRICAL PLAN**

project	153929	contract	
drawing	E-107	rev.	A

file 153929E-107.dwg

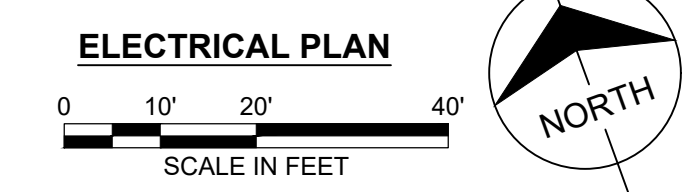

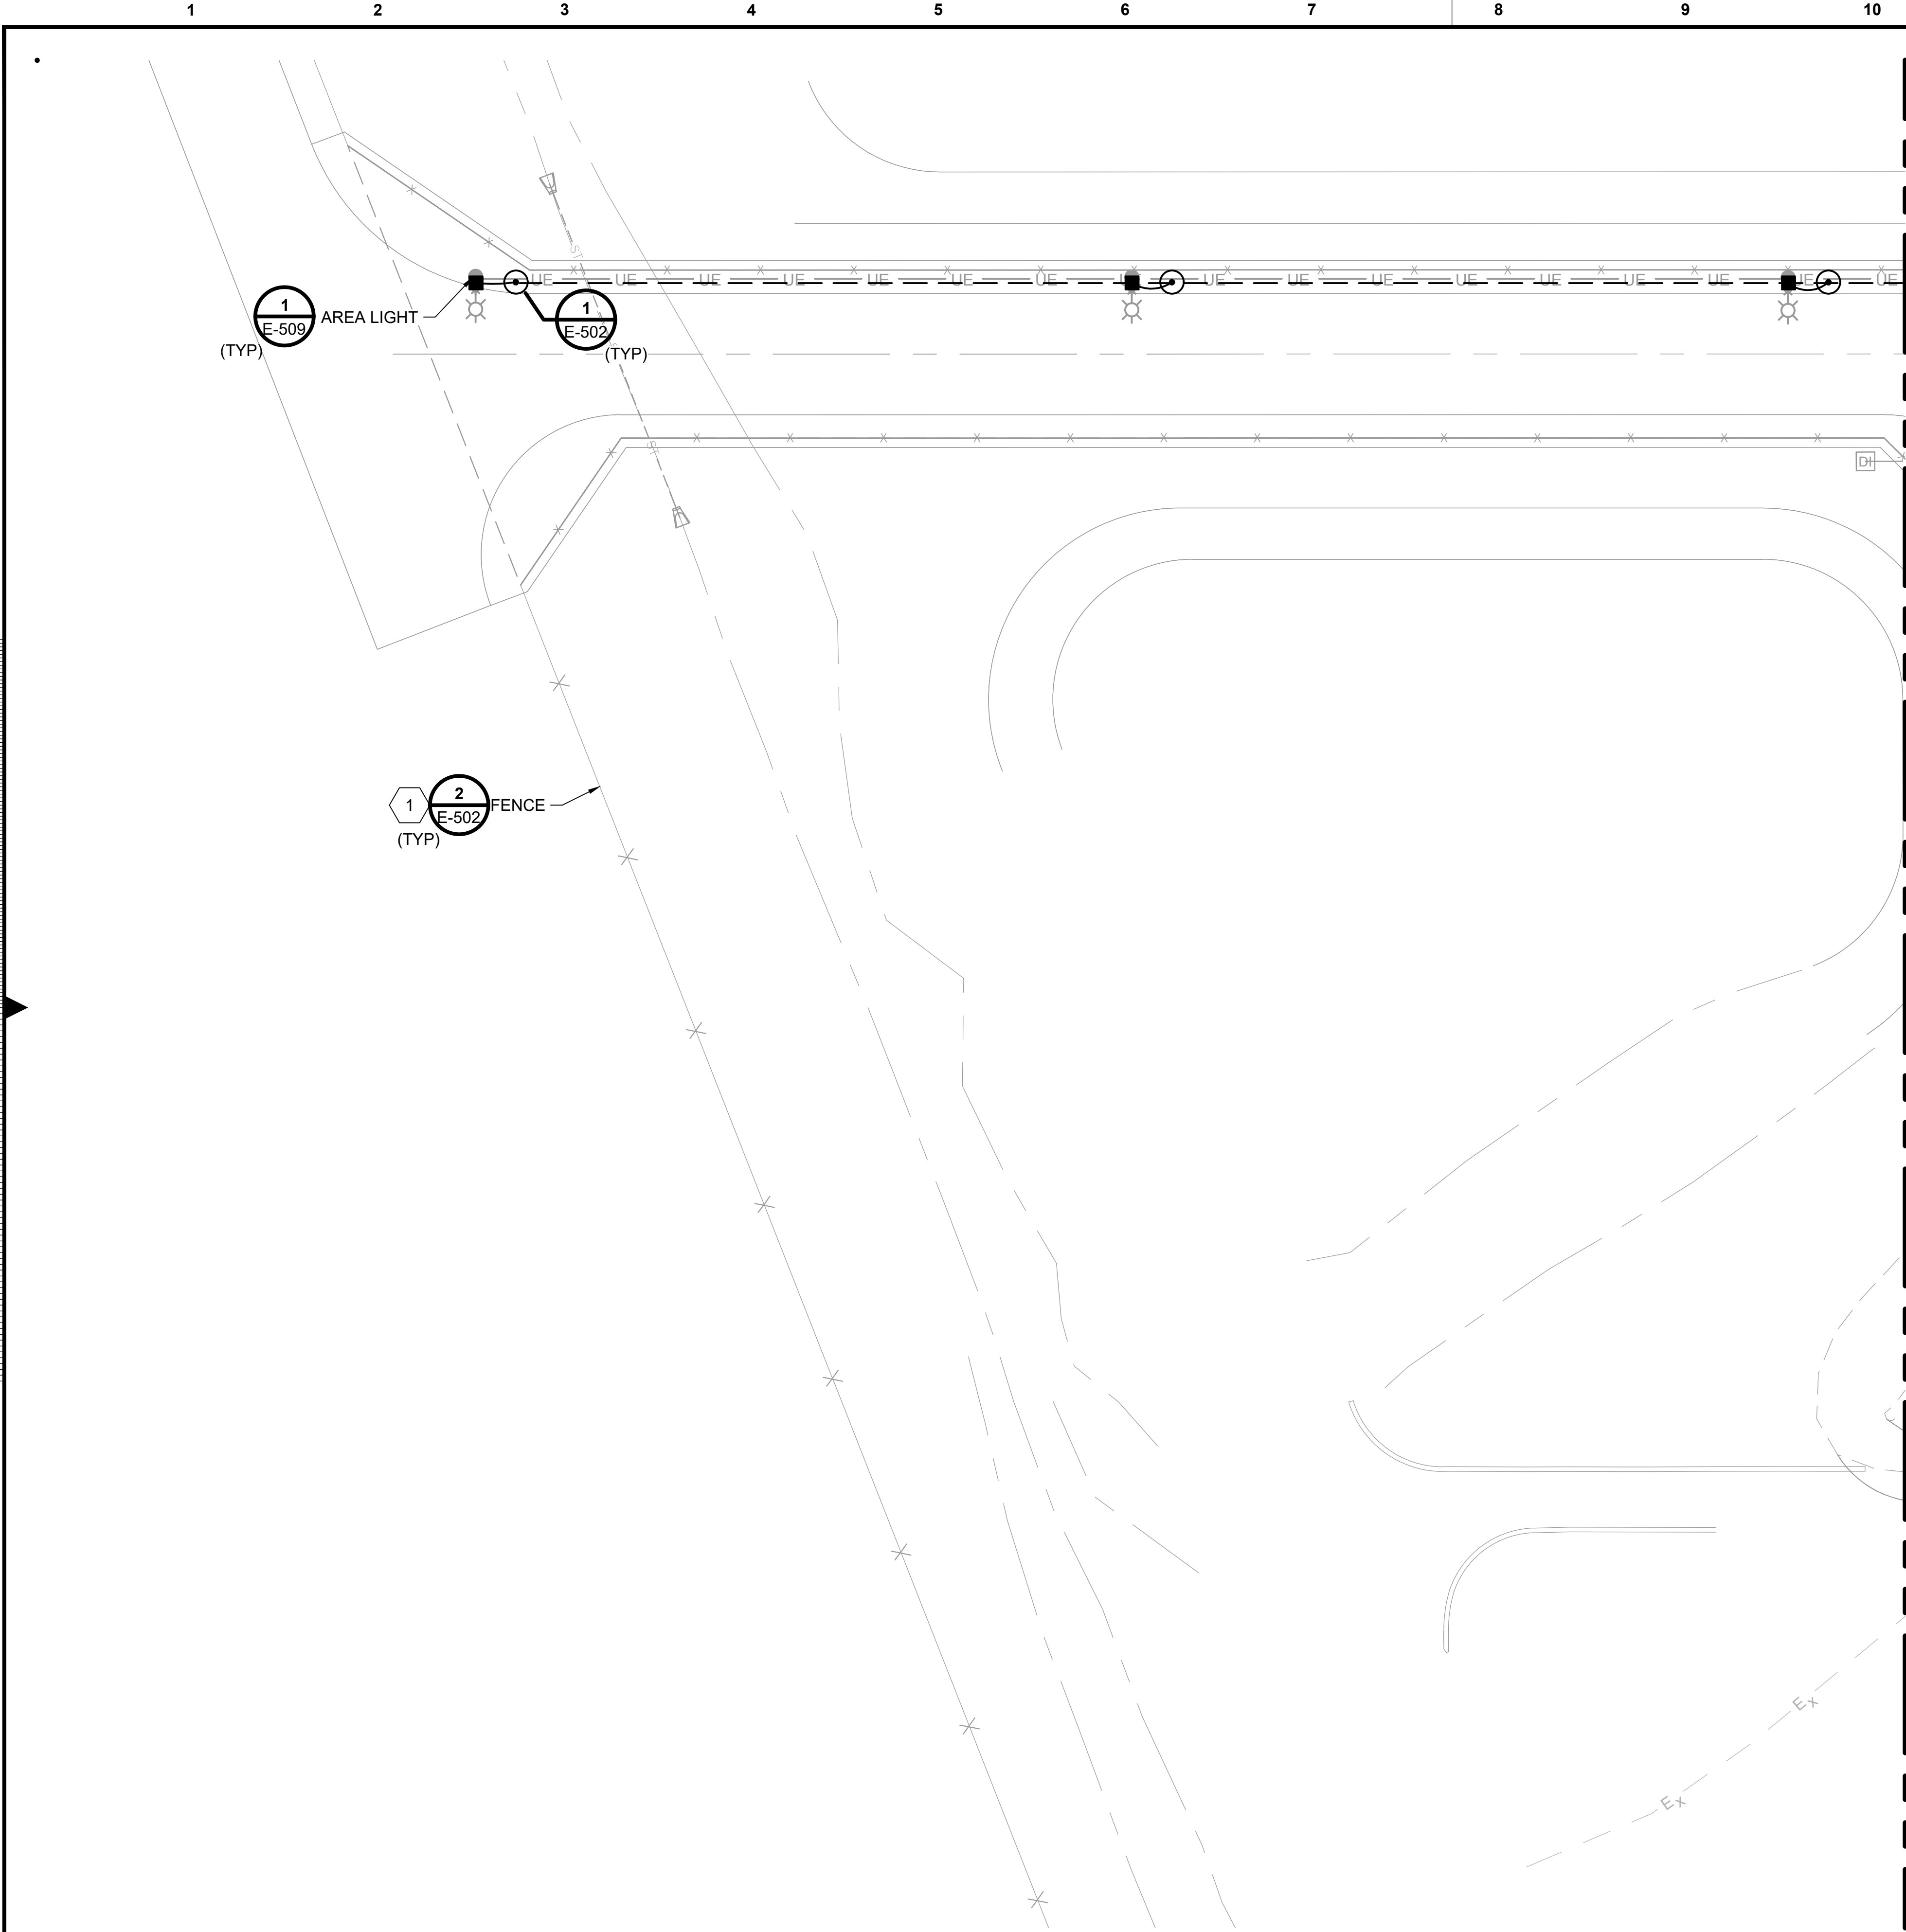


NOTES:



- SEE SHEET E-001 FOR GENERAL NOTES, LEGEND AND ABBREVIATIONS.
- PROVIDE FENCE GROUNDING PER DETAIL 2 ON DRAWING E-502 AT EACH GATE AND ALL CHANGES IN DIRECTION FOR ALL FENCING AND GATES SUPPLIED BY SUBCONTRACTOR.

KEYED NOTES:

- 1 PROVIDE FENCE GROUNDING. PROVIDE GROUNDING AT EACH GATE AND ALL CHANGES IN DIRECTION.

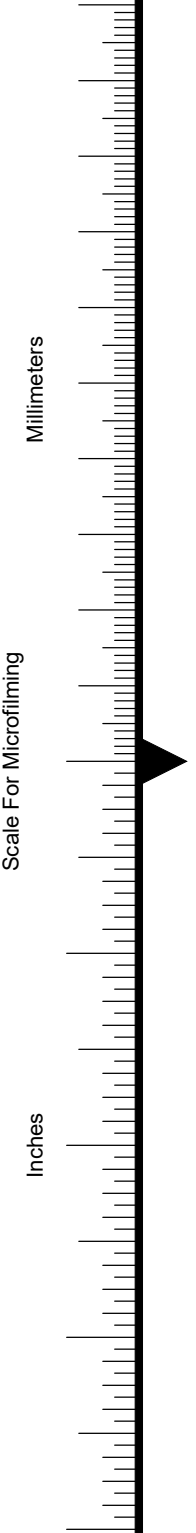


MATCHLINE - SEE DRAWING EG103 FOR CONTINUATION

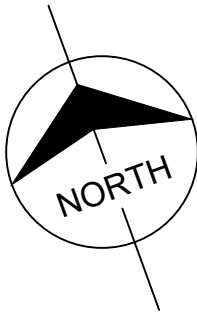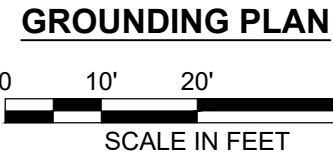

12/20/2023

no.	date	by	ckd	description
A	12/21/23	TSR	BAW	ISSUED FOR PERMIT

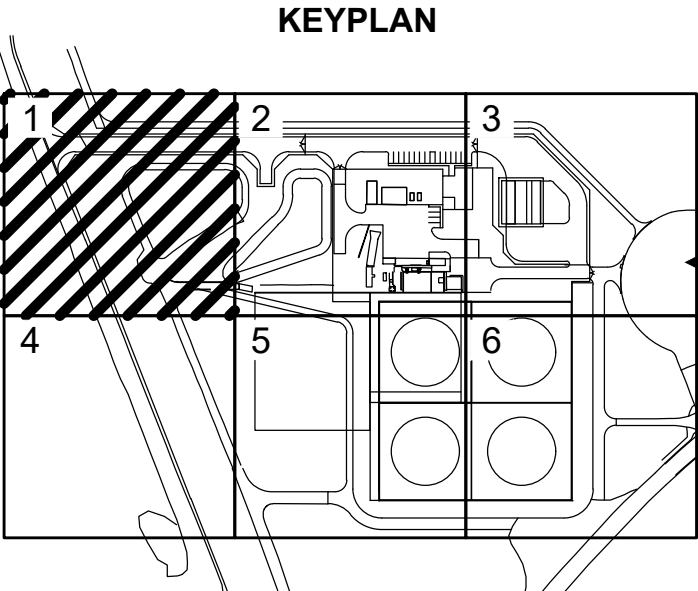

ISSUED FOR PERMIT ONLY



9400 WARD PARKWAY
KANSAS CITY, MO 64114
816-333-9400
Burns & McDonnell Engineering Co., Inc.

date	04/24/2023	detailed	S. JESBERG
designed	T. RENSHAW	checked	B. WINTER


PDX FUEL COMPANY L.L.C

PORTLAND INTERNATIONAL AIRPORT
5000 NE MARINE DR.
PORTLAND, OREGON 97218

PDX FACILITY IMPROVEMENTS
GROUNDING PLAN

project	153929	contract	
drawing	EG102	rev.	A


file 153929EG102.dwg

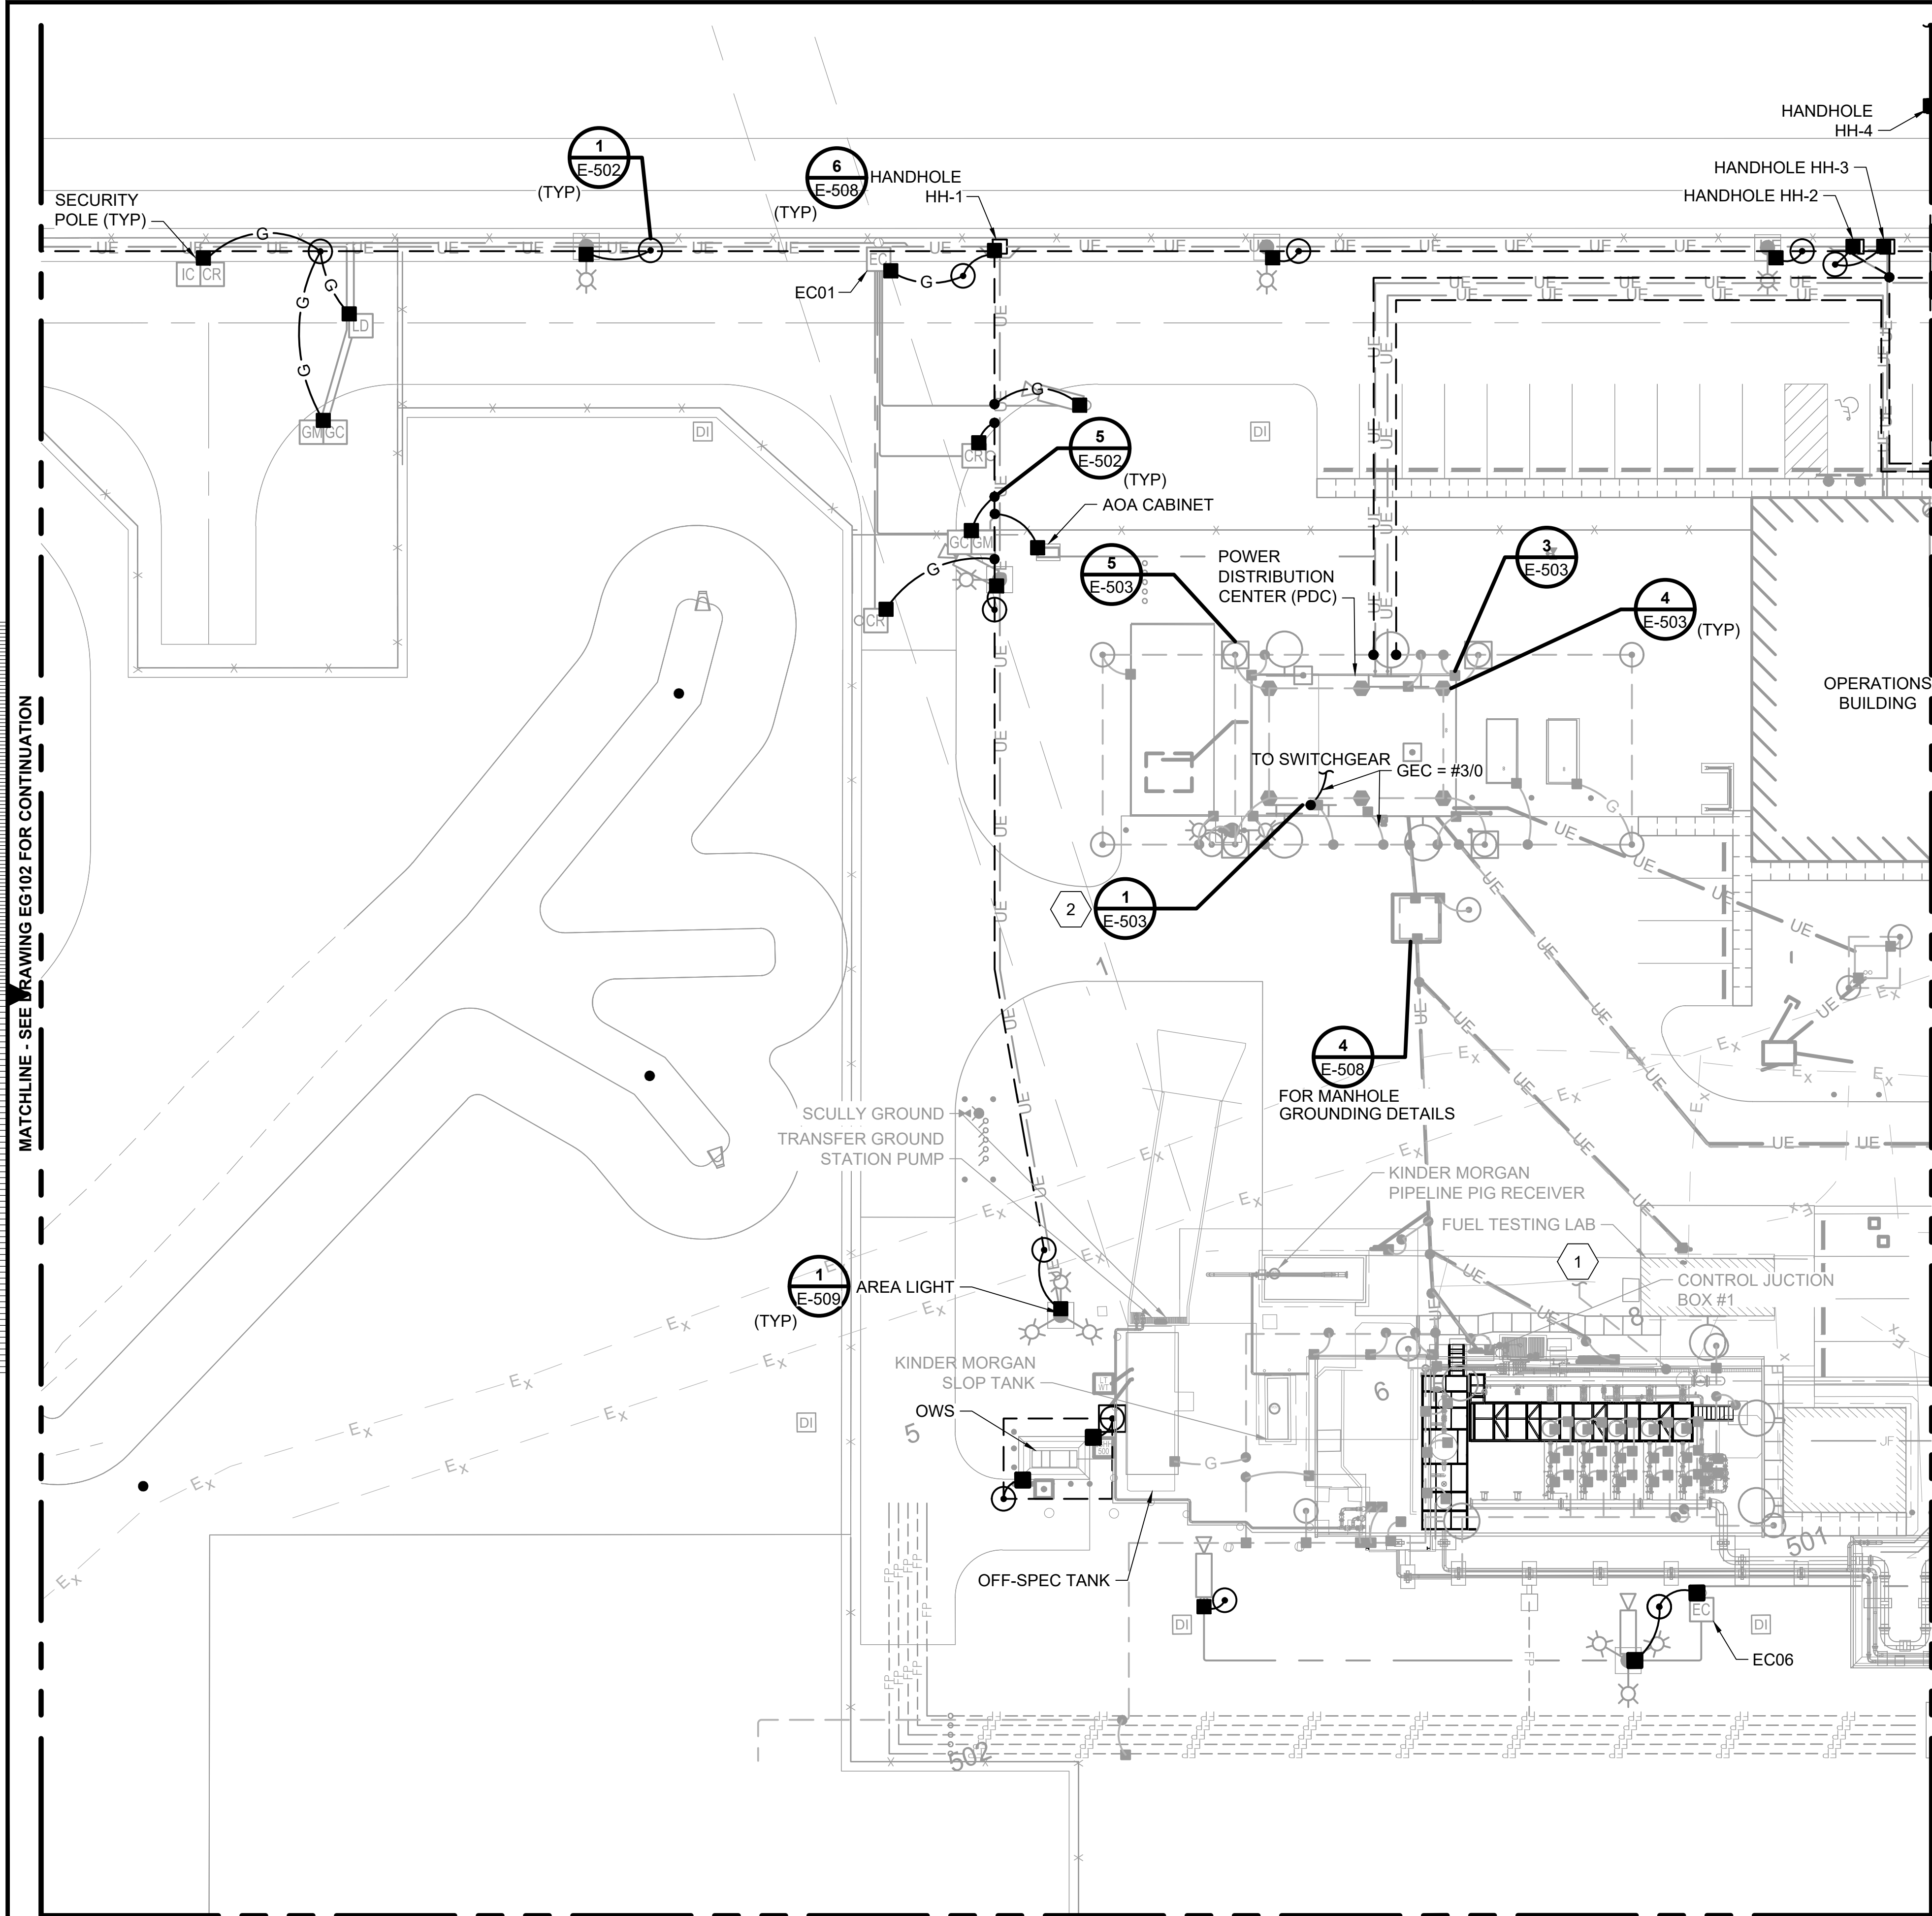

- NOTES:**
- SEE SHEET E-001 FOR GENERAL NOTES, LEGEND AND ABBREVIATIONS.
 - PROVIDE FENCE GROUNDING PER DETAIL 2 ON DRAWING E-502 AT EACH GATE AND ALL CHANGES IN DIRECTION FOR ALL FENCING AND GATES SUPPLIED BY SUBCONTRACTOR.
 - LIGHTNING PROTECTION SYSTEM FOR THE POWER DISTRIBUTION CENTER PER NFPA 780, UL 96, UL 96A, AND SPECIFICATION 26 41 13.

- KEYED NOTES:**
- 1 GROUND GRID TO EXISTING GRID AT THE FENCE.

no.	date	by	ckd	description
A	12/21/23	TSR	BAW	ISSUED FOR PERMIT

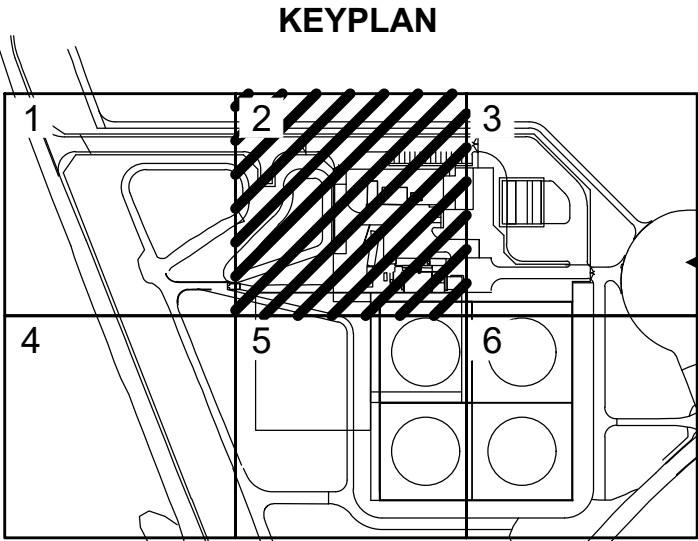

ISSUED FOR PERMIT ONLY



9400 WARD PARKWAY
KANSAS CITY, MO 64114
816-333-9400
Burns & McDonnell Engineering Co., Inc.

date	04/24/2023	detailed	S. JESBERG
designed	T. RENSHAW	checked	B. WINTER


PDX FUEL COMPANY L.L.C

PORTLAND INTERNATIONAL AIRPORT
5000 NE MARINE DR.
PORTLAND, OREGON 97218

PDX FACILITY IMPROVEMENTS
GROUNDING PLAN

project	153929	contract	
drawing	EG103	rev.	A

file 153929EG103.dwg

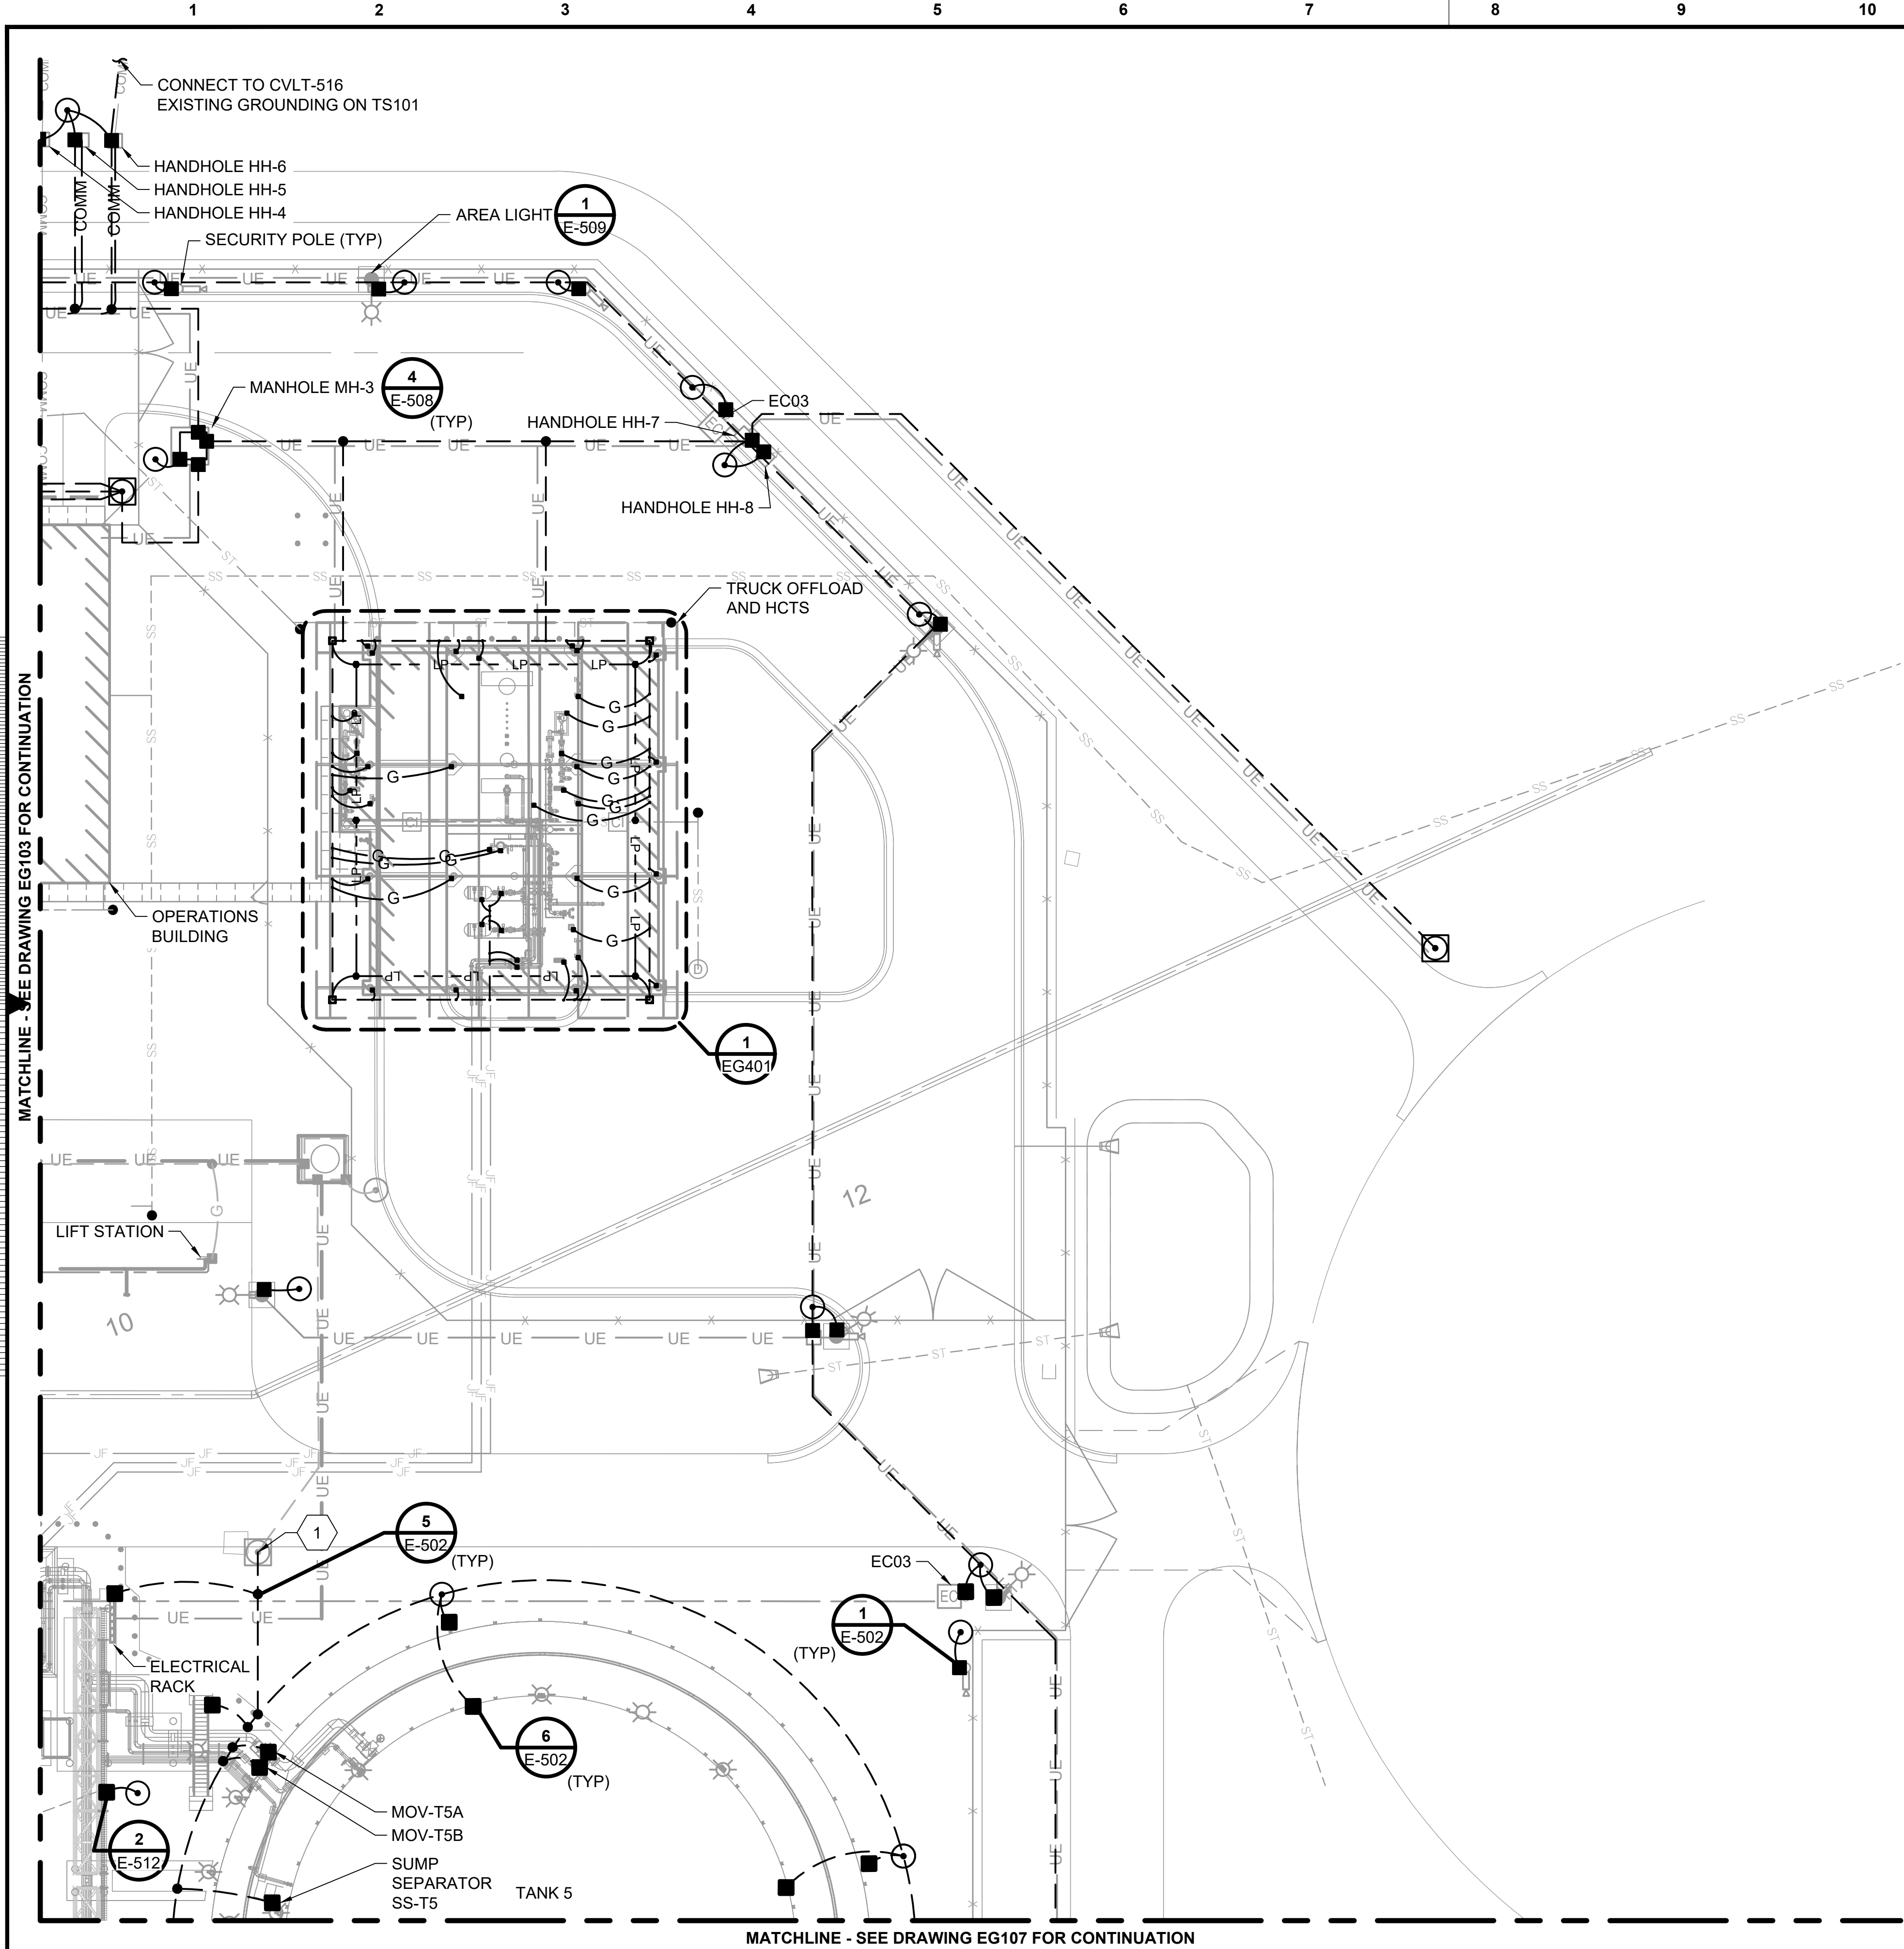


NOTES:

- SEE SHEET E-001 FOR GENERAL NOTES, LEGEND AND ABBREVIATIONS.
- PROVIDE FENCE GROUNDING PER DETAIL 2 ON DRAWING E-502 AT EACH GATE AND ALL CHANGES IN DIRECTION FOR ALL FENCING AND GATES SUPPLIED BY SUBCONTRACTOR.
- PROVIDE LIGHTNING PROTECTION SYSTEM FOR THE OFFLOAD PUMP #2 AND HCTS CANOPY PER NFPA 780, UL 96, UL 96A, AND SPECIFICATION 26 41 13.

KEYED NOTES:

- 1 CONNECT TANK GROUNDING TO EXISTING GROUND GRID.

no.	date	by	ckd	description
A	12/21/23	TSR	BAW	ISSUED FOR PERMIT

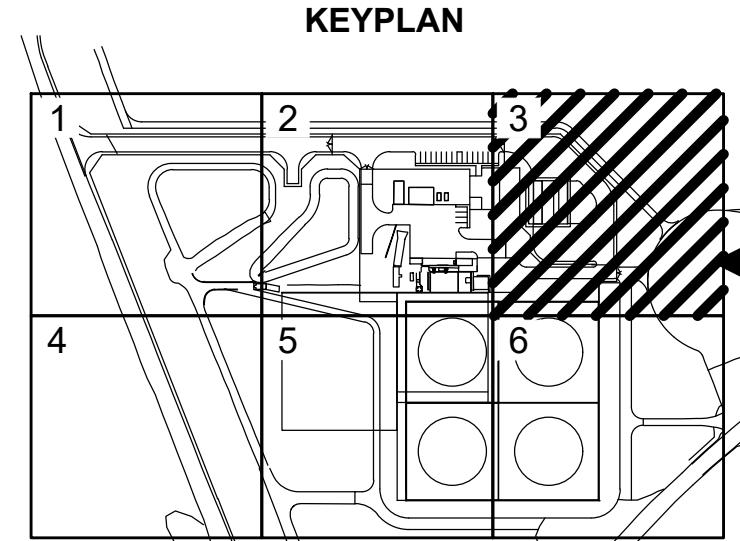

ISSUED FOR PERMIT ONLY

**BURNS
MCDONNELL**
9400 WARD PARKWAY
KANSAS CITY, MO 64114
816-333-9400
Burns & McDonnell Engineering Co., Inc.

date	04/24/2023	detailed	S. JESBERG
designed	T. RENSHAW	checked	B. WINTER


PDX FUEL COMPANY L.L.C

PORTLAND INTERNATIONAL AIRPORT
5000 NE MARINE DR.
PORTLAND, OREGON 97218

**PDX FACILITY IMPROVEMENTS
GROUNDING PLAN**


project	153929	contract	
drawing	EG104	rev.	A

file 153929EG104.dwg

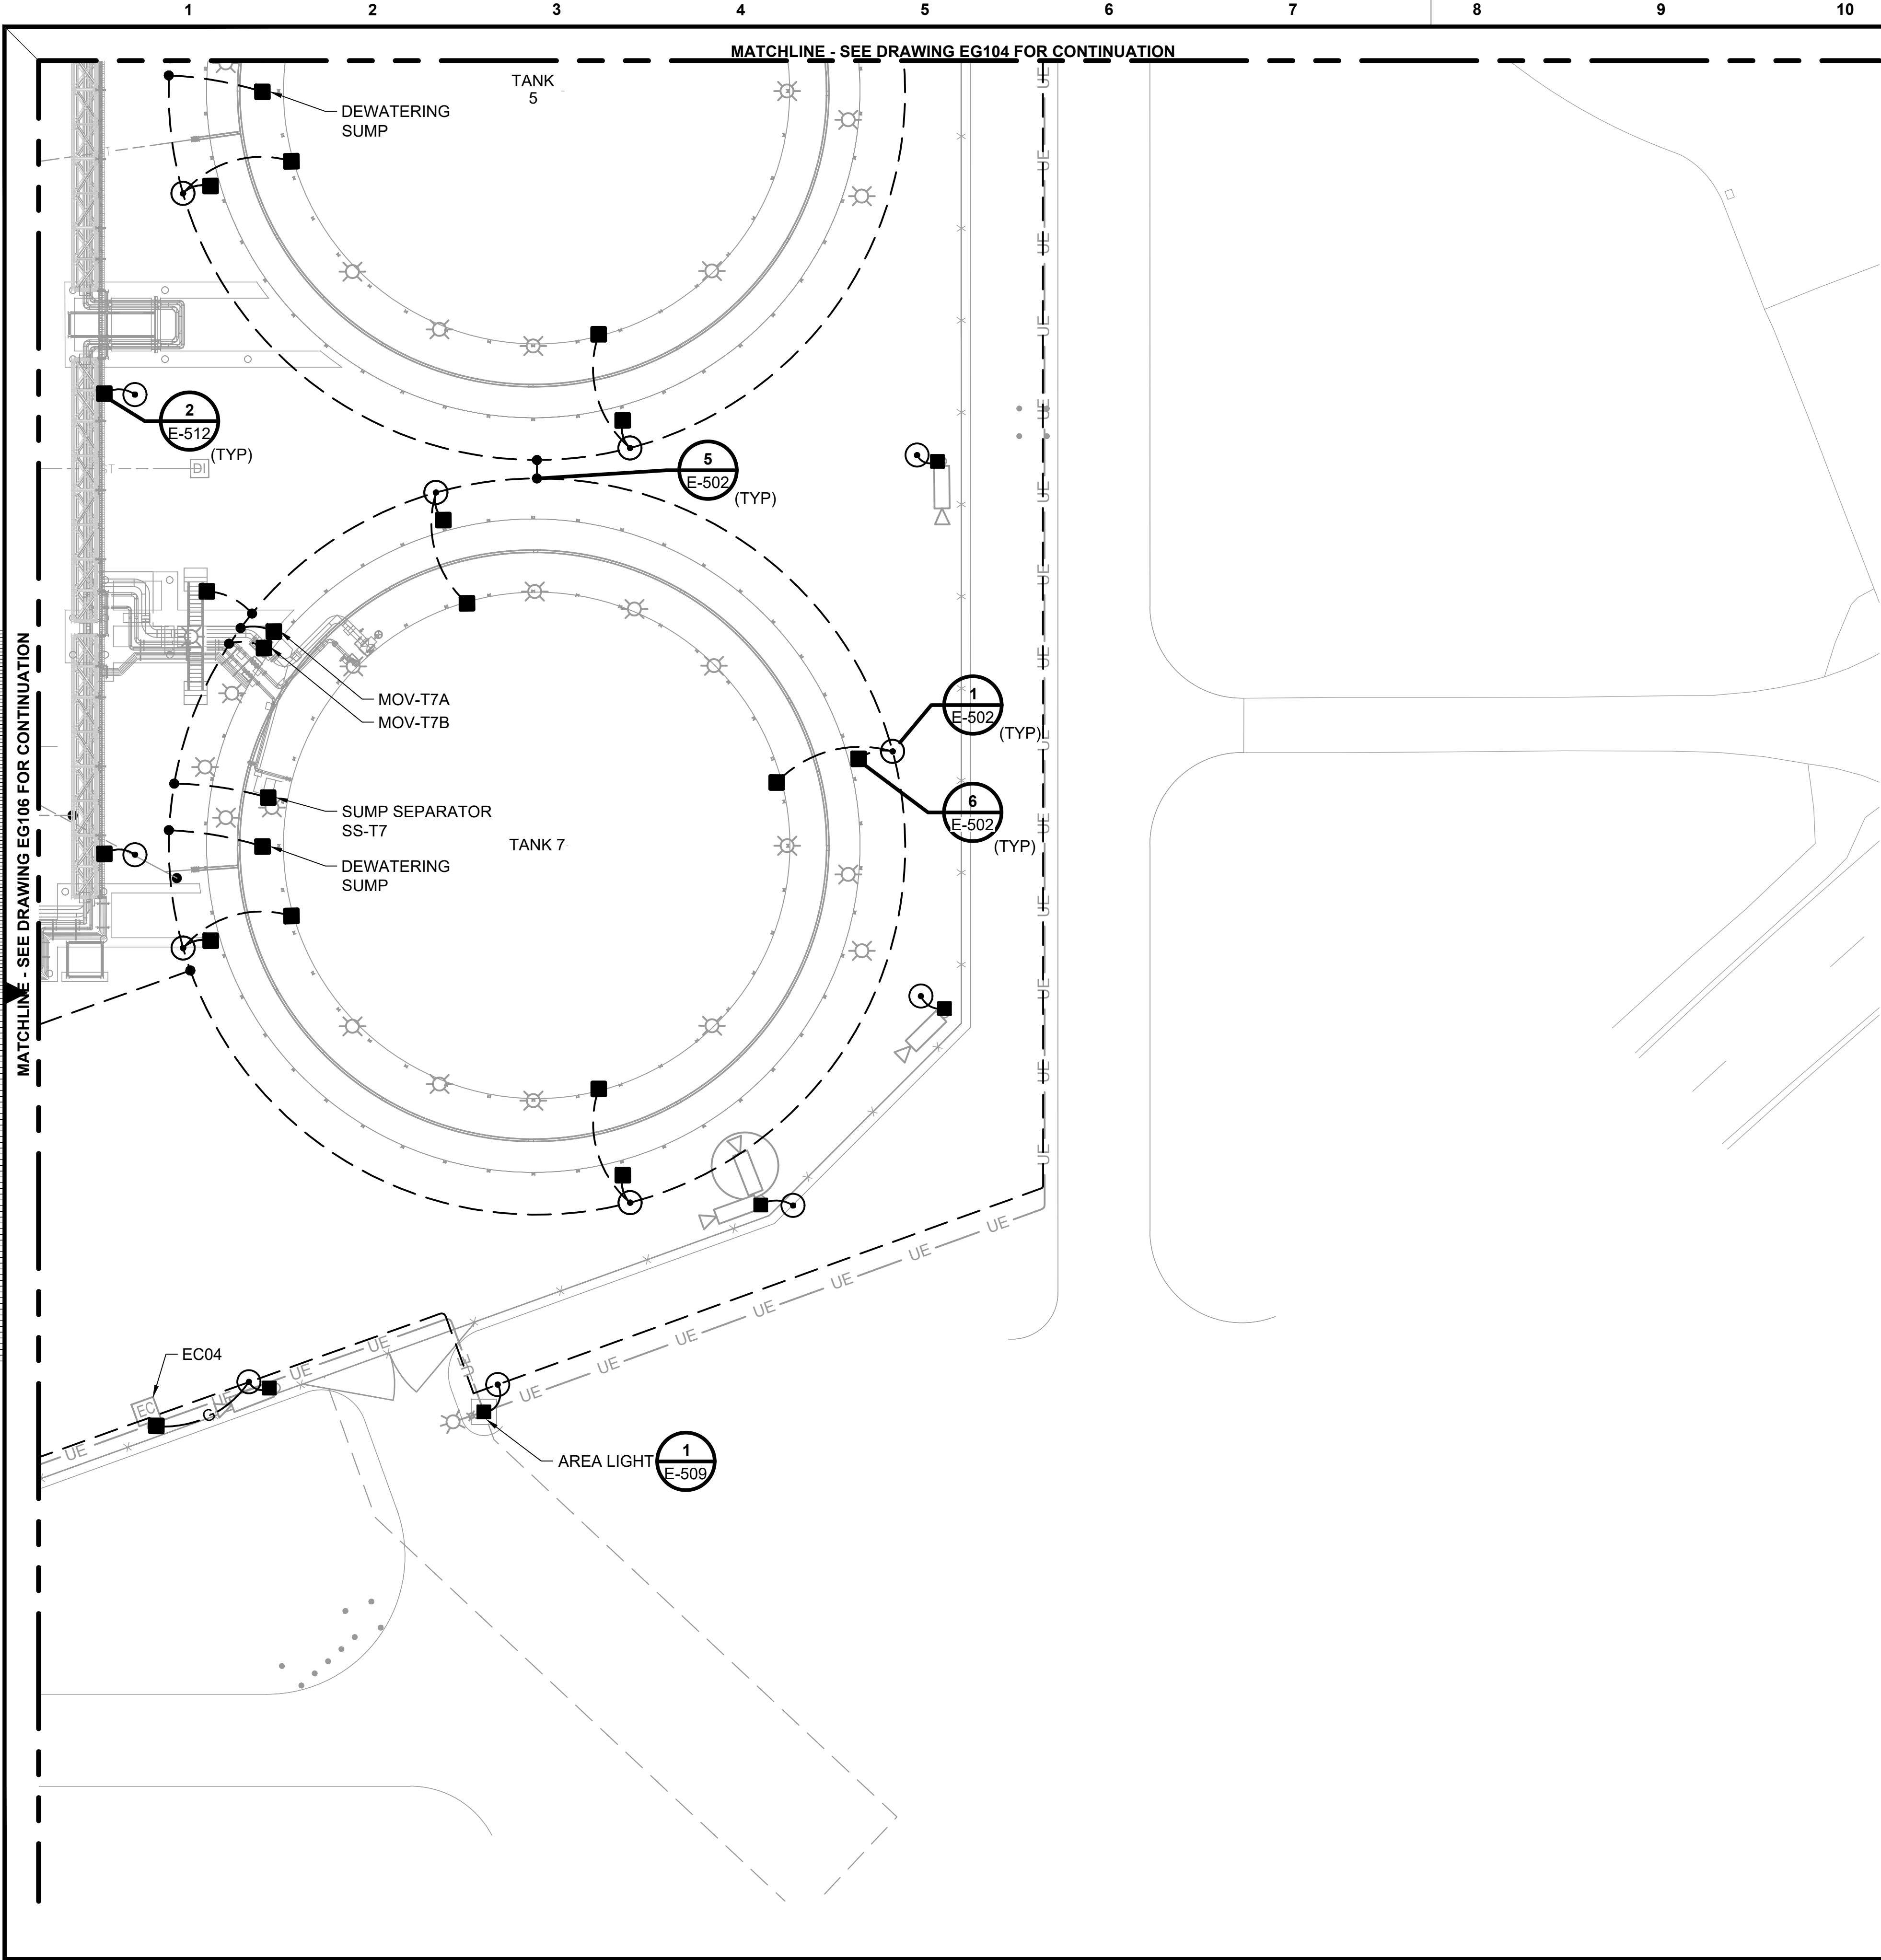

- NOTES:
- SEE SHEET E-001 FOR GENERAL NOTES, LEGEND AND ABBREVIATIONS.
 - PROVIDE FENCE GROUNDING PER DETAIL 2 ON DRAWING E-502 AT EACH GATE AND ALL CHANGES IN DIRECTION FOR ALL FENCING AND GATES SUPPLIED BY SUBCONTRACTOR.

no.	date	by	ckd	description
A	12/21/23	TSR	BAW	ISSUED FOR PERMIT

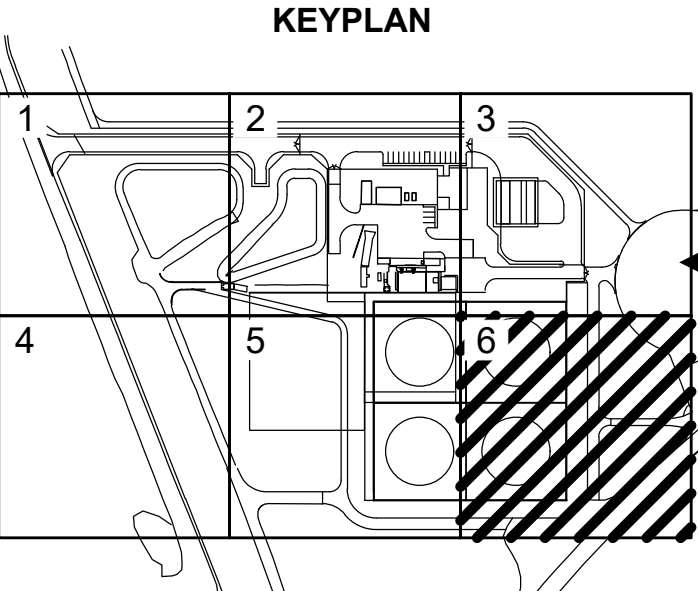

ISSUED FOR PERMIT ONLY

**BURNS
MCDONNELL**
9400 WARD PARKWAY
KANSAS CITY, MO 64114
816-333-9400
Burns & McDonnell Engineering Co, Inc.

date	04/24/2023	detailed	S. JESBERG
designed	T. RENSHAW	checked	B. WINTER



PDX FUEL COMPANY L.L.C


PORTLAND INTERNATIONAL AIRPORT
5000 NE MARINE DR.
PORTLAND, OREGON 97218

PDX FACILITY IMPROVEMENTS
GROUNDING PLAN

project	153929	contract	
drawing	EG107	rev.	A

file 153929EG107.dwg

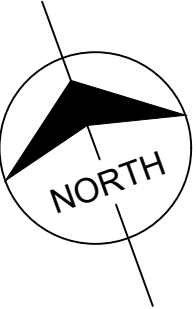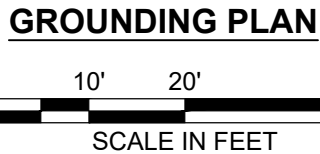

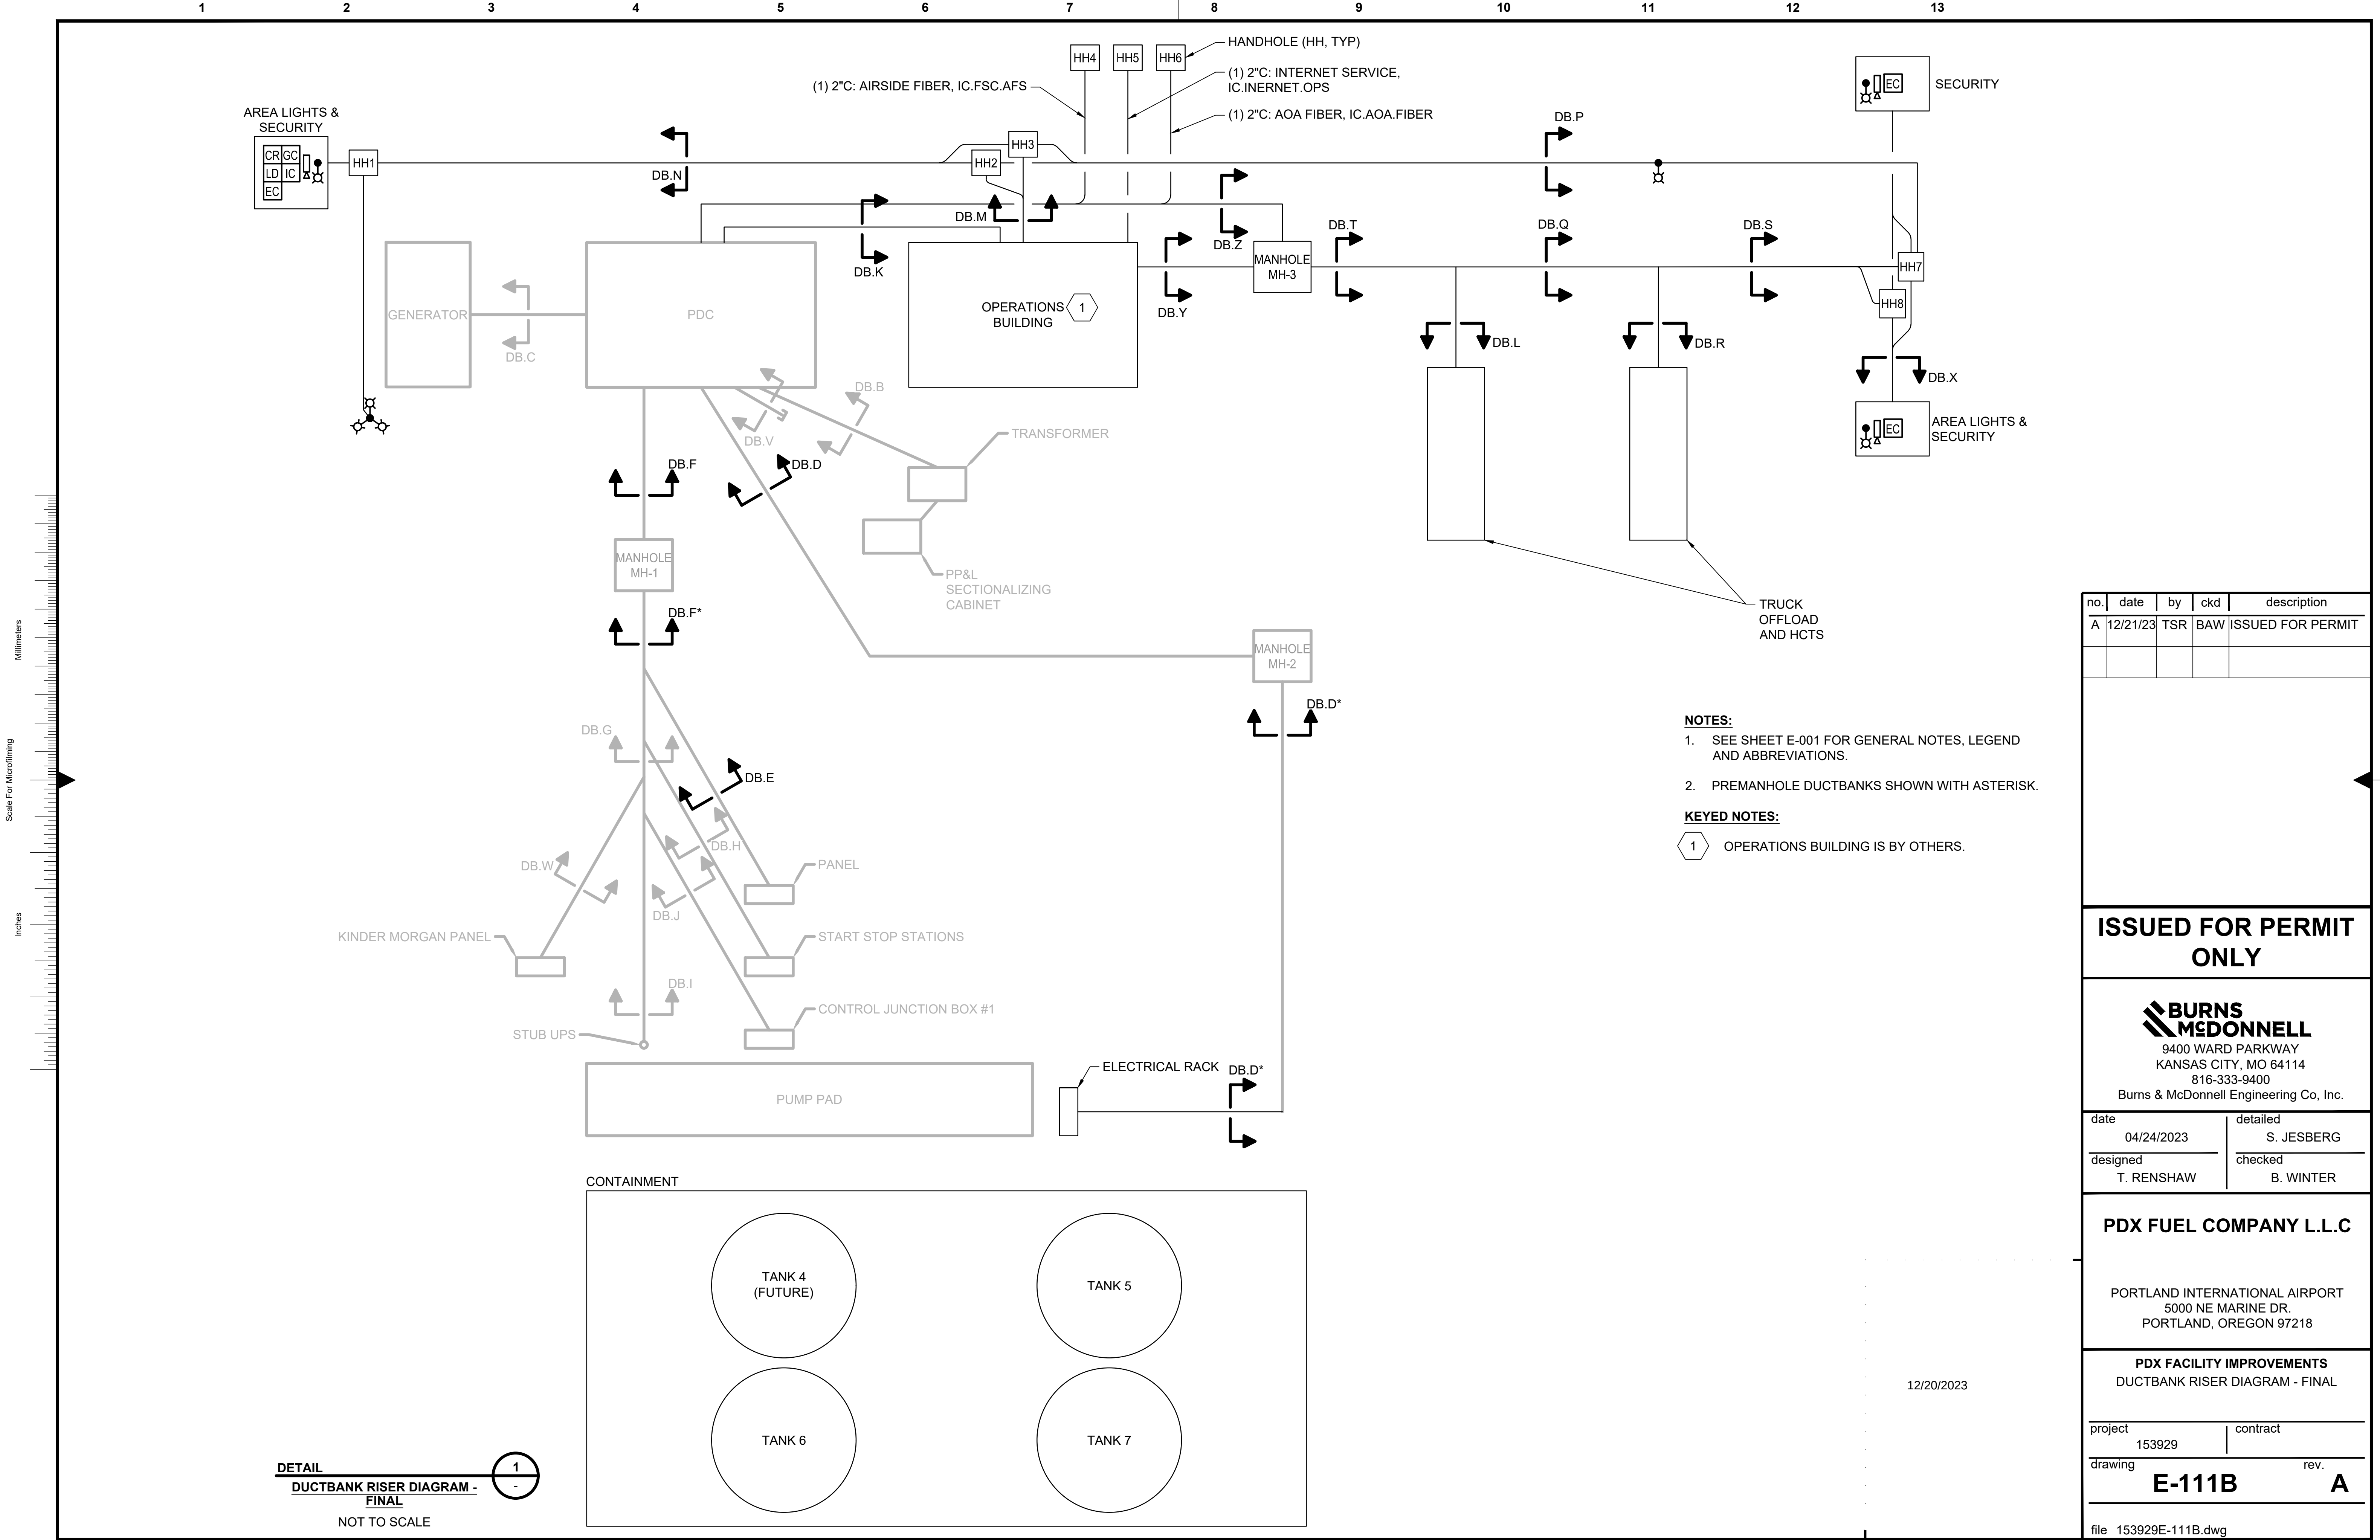

CORRESPONDING CIRCUIT NUMBERS			
CIRCUIT CALLOUT	TANK 5	TANK 6	TANK 7
1 SUMP MOTOR	P.PNL6.30	P.PNL6.31	P.PNL6.35
2 STAIR LIGHTS	P.LP1.21.1	P.LP1.23.1	P.LP1.25.1
3 OBSTRUCTION LIGHTS	P.LP1.32	P.LP1.34	P.LP1.36
4 AREA LIGHTS	P.LP1.20.1	P.LP1.24.1	P.LP1.20.1
5 MOV POWER	P.PNL5.32	P.PNL5.37	P.PNL5.38
6 MOV "A" CONTROLS	C.FSC.T5A	C.FSC.T6A	C.FSC.T7A
7 MOV "B" CONTROLS	C.FSC.T5B	C.FSC.T6B	C.FSC.T7B
8 UIT - POWER	P.UIT.T5	P.UIT.T6	P.UIT.T7
9 UIT - COMMUNICATION	IC.UIT.T5	IC.UIT.T6	IC.UIT.T7


10 PT COMMUNICATION	IC.PT.T5	IC.PT.T6	IC.PT.T7
11 LT COMMUNICATION	IS.LT.T5	IS.LT.T6	IS.LT.T7
12 TT COMMUNICATION	IS.TT.T5	IS.TT.T6	IS.TT.T7
13 LSHH	C.LS.T5	C.LS.T6	C.LS.T7
14 LSH-DW	C.DSLSH.T5	C.DSLSH.T6	C.DSLSH.T7
15 EFSO WEST STAIR	C.EFSO.T5W	C.EFSO.T6W	C.EFSO.T7W
16 EFSO EAST STAIR	C.EFSO.T5E	C.EFSO.T6E	C.EFSO.T7E
17 EFSO INSIDE STAIR	C.EFSO.T5I	C.EFSO.T6I	C.EFSO.T7I
18 MOV "A" - ESD	C.EFSO.T5A	C.EFSO.T6A	C.EFSO.T7A
19 MOV "B" - ESD	C.EFSO.T5B	C.EFSO.T6B	C.EFSO.T7B

NOTES:

- SEE SHEET E-001 FOR LEGEND, ABBREVIATIONS, AND GENERAL NOTES.
- SEE SHEET E-509 FOR LIGHT FIXTURE SCHEDULE.
- LIGHTING TO BE PLACED AT BOTTOM, MIDDLE AND TOP OF STAIRS. TANK STAIRS TO BE DETERMINED BY SUBCONTRACTOR.
- (*) ASTERIK MEANS THE WIRE IS DOWNSTREAM OF A SWITCH/DISCONNECT.

KEYED NOTES:

- 1 CONDUITS SHALL BE SUPPORTED UNDERNEATH STAIR PLATFORM AND CONTINUE UP TANK WALL TO INSTRUMENTS.

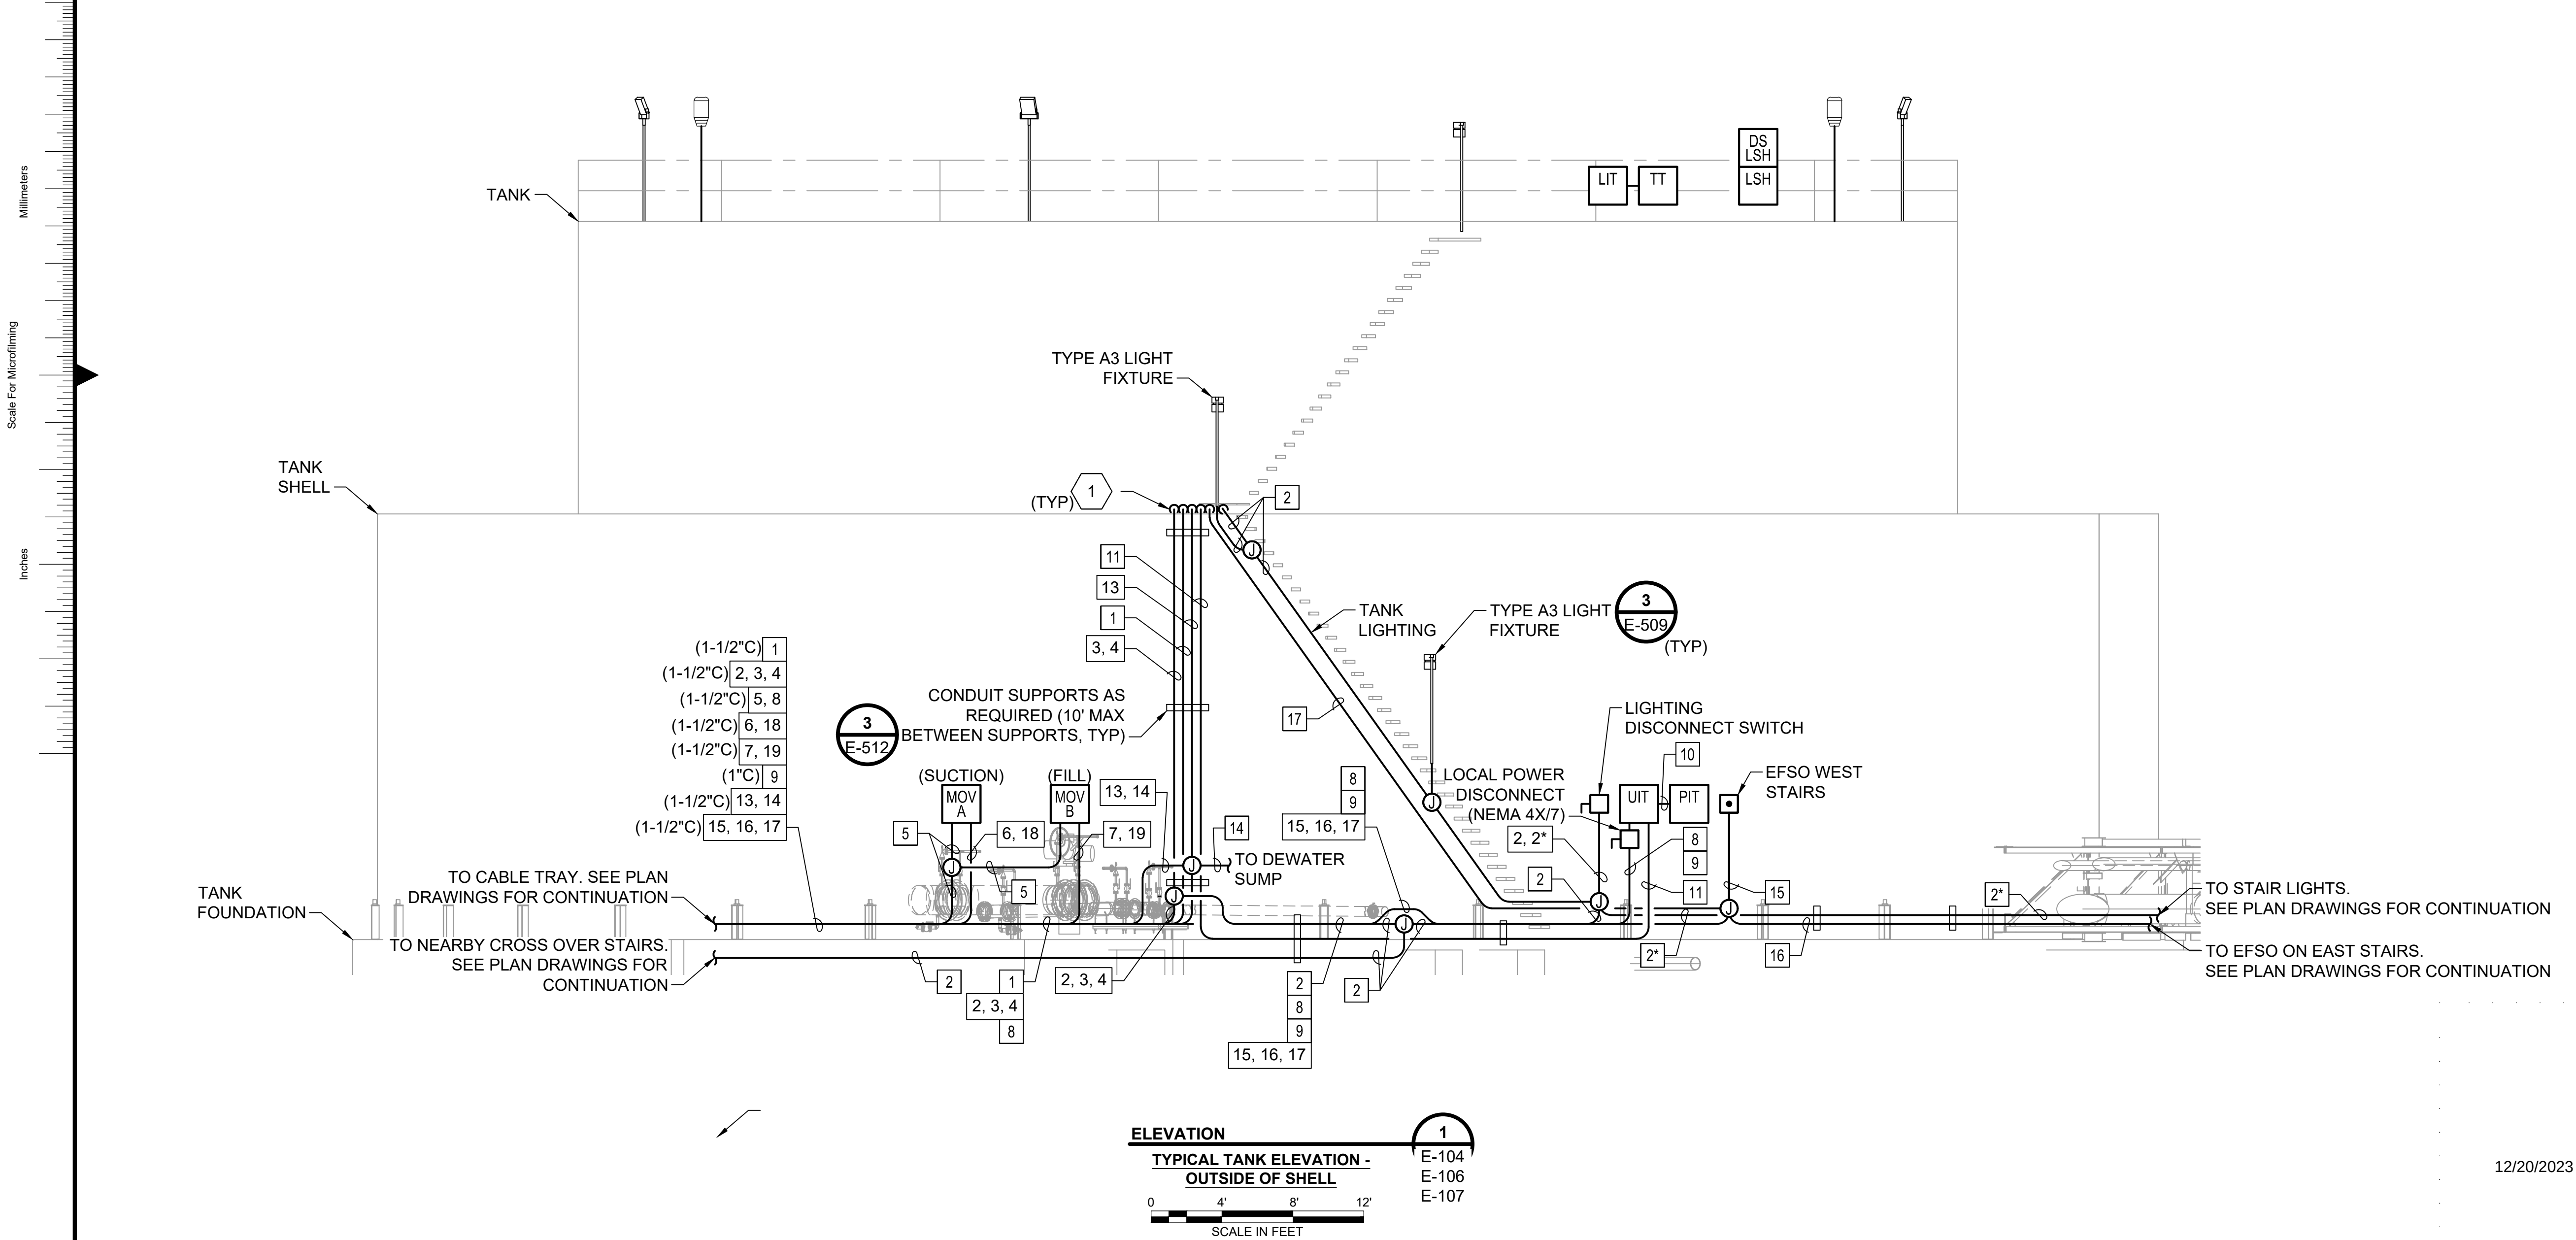

no.	date	by	ckd	description
A	12/21/23	TSR	BAW	ISSUED FOR PERMIT

ISSUED FOR PERMIT ONLY



9400 WARD PARKWAY
KANSAS CITY, MO 64114
816-333-9400
Burns & McDonnell Engineering Co., Inc.

date	04/24/2023	detailed	S. JESBERG
designed	T. RENSHAW	checked	B. WINTER

PDX FUEL COMPANY L.L.C

PORTLAND INTERNATIONAL AIRPORT
5000 NE MARINE DR.
PORTLAND, OREGON 97218

PDX FACILITY IMPROVEMENTS
TYPICAL TANK ELEVATION - OUTSIDE OF SHELL

project	153929	contract	
drawing	E-201	rev.	A

file 153929E-201.dwg

CORRESPONDING CIRCUIT NUMBERS			
CIRCUIT CALLOUT	TANK 5	TANK 6	TANK 7
1 SUMP MOTOR	P.PNL6.30	P.PNL6.31	P.PNL6.35
2 STAIR LIGHTS	P.LP1.21.1	P.LP1.23.1	P.LP1.25.1
3 OBSTRUCTION LIGHTS	P.LP1.32	P.LP1.34	P.LP1.36
4 AREA LIGHTS	P.LP1.20.1	P.LP1.24.1	P.LP1.20.1
5 MOV POWER	P.PNL5.32	P.PNL5.37	P.PNL5.38
6 MOV "A" CONTROLS	C.FSC.T5A	C.FSC.T6A	C.FSC.T7A
7 MOV "B" CONTROLS	C.FSC.T5B	C.FSC.T6B	C.FSC.T7B
8 UIT - POWER	P.UIT.T5	P.UIT.T6	P.UIT.T7
9 UIT - COMMUNICATION	IC.UIT.T5	IC.UIT.T6	IC.UIT.T7


10 PT COMMUNICATION	IC.PT.T5	IC.PT.T6	IC.PT.T7
11 LT COMMUNICATION	IS.LT.T5	IS.LT.T6	IS.LT.T7
12 TT COMMUNICATION	IS.TT.T5	IS.TT.T6	IS.TT.T7
13 LSHH	C.LS.T5	C.LS.T6	C.LS.T7
14 LSH-DW	C.DSLSH.T5	C.DSLSH.T6	C.DSLSH.T7
15 EFSO WEST STAIR	C.EFSO.T5W	C.EFSO.T6W	C.EFSO.T7W
16 EFSO EAST STAIR	C.EFSO.T5E	C.EFSO.T6E	C.EFSO.T7E
17 EFSO INSIDE STAIR	C.EFSO.T5I	C.EFSO.T6I	C.EFSO.T7I
18 MOV "A" - ESD	C.EFSO.T5A	C.EFSO.T6A	C.EFSO.T7A
19 MOV "B" - ESD	C.EFSO.T5B	C.EFSO.T6B	C.EFSO.T7B

NOTES:


- SEE SHEET E-001 FOR LEGEND, ABBREVIATIONS, AND GENERAL NOTES.
- SEE SHEET E-509 FOR LIGHT FIXTURE SCHEDULE.
- LIGHTING TO BE PLACED AT BOTTOM, MIDDLE AND TOP OF STAIRS. TANK STAIRS TO BE DETERMINED BY SUBCONTRACTOR.
- (*) ASTERIK MEANS THE WIRE IS DOWNSTREAM OF A SWITCH/DISCONNECT.

KEYED NOTES:

- 1 CONDUITS SHALL BE SUPPORTED UNDERNEATH STAIR PLATFORM AND CONTINUE UP TANK WALL TO INSTRUMENTS.

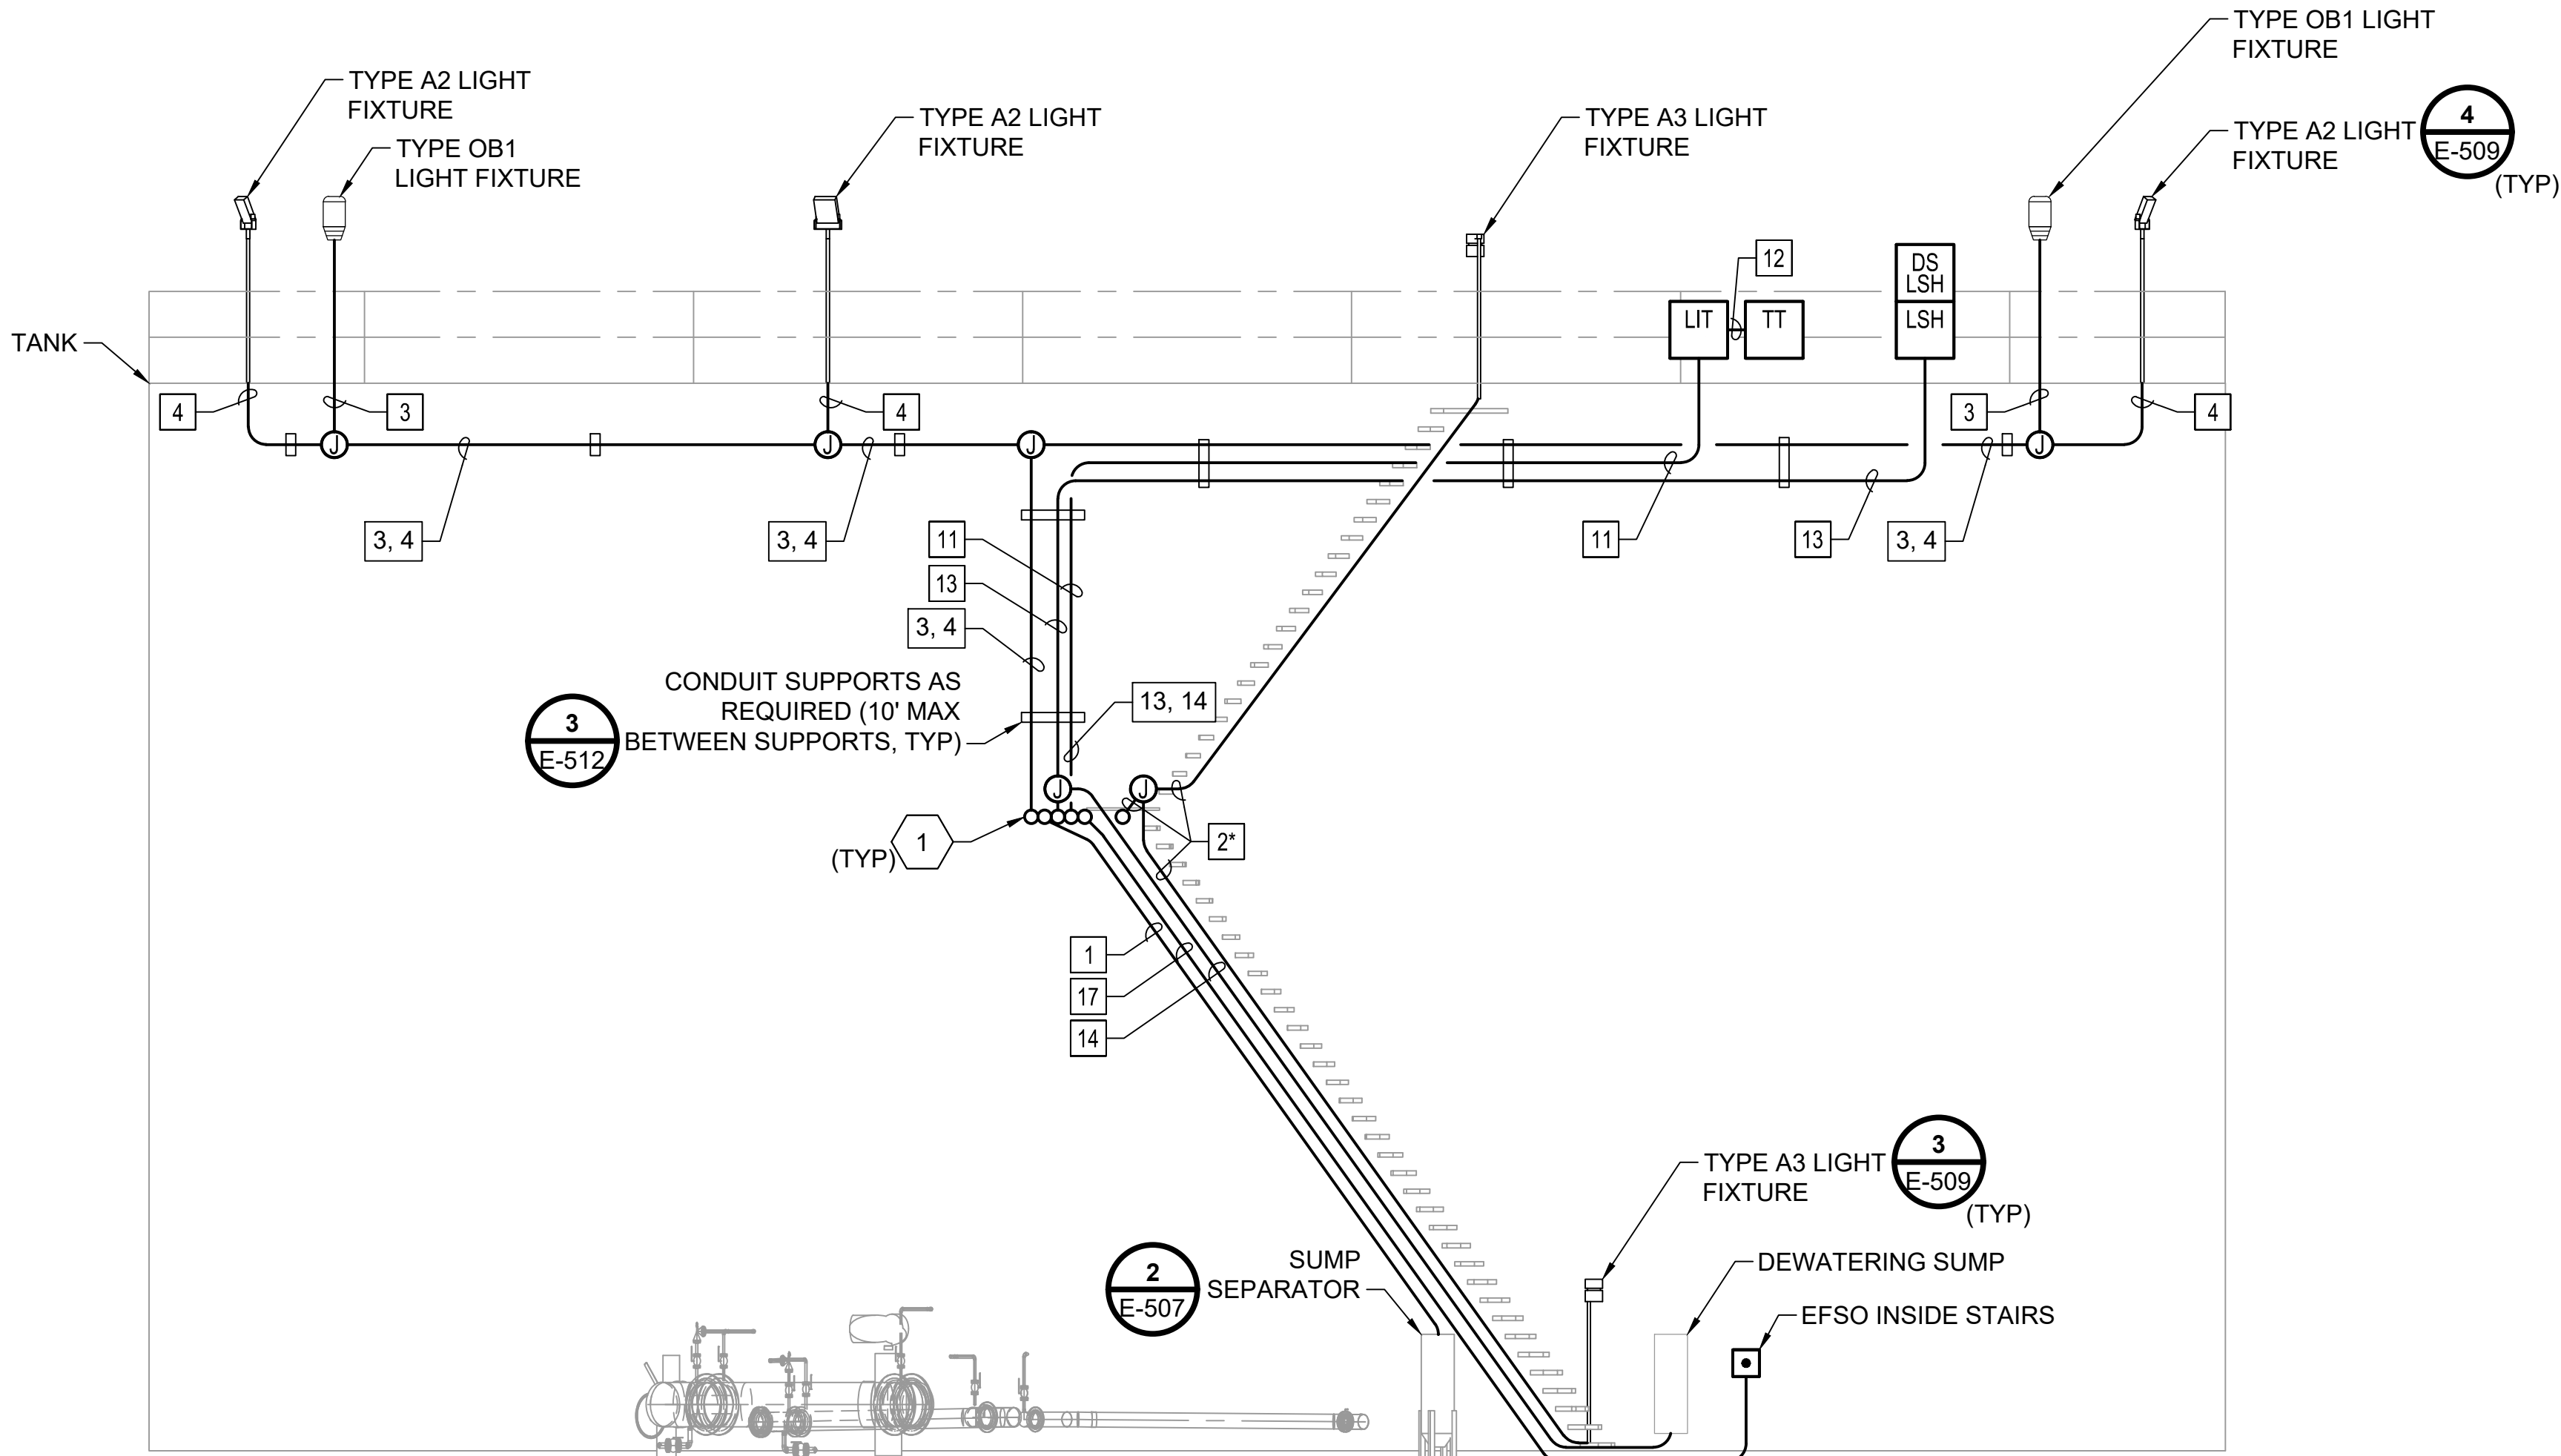

ELEVATION

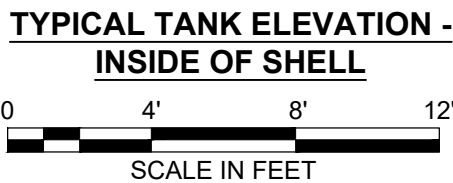

- 1
- E-104
 - E-106
 - E-107

no.	date	by	ckd	description
A	12/21/23	TSR	BAW	ISSUED FOR PERMIT

ISSUED FOR PERMIT ONLY



9400 WARD PARKWAY
KANSAS CITY, MO 64114
816-333-9400
Burns & McDonnell Engineering Co., Inc.

date	04/24/2023	detailed	S. JESBERG
designed	T. RENSHAW	checked	B. WINTER

PDX FUEL COMPANY L.L.C


PORTLAND INTERNATIONAL AIRPORT
5000 NE MARINE DR.
PORTLAND, OREGON 97218

PDX FACILITY IMPROVEMENTS
TYPICAL TANK ELEVATION - INSIDE OF SHELL


project	153929	contract	
drawing	E-202	rev.	A

file 153929E-202.dwg

- NOTES:**
- SEE SHEET E-001 FOR GENERAL NOTES, LEGEND AND ABBREVIATIONS.
 - SEE CORRESPONDING CIRCUIT NUMBER SCHEDULE ON SHEET E-201 FOR CIRCUIT LABELS.

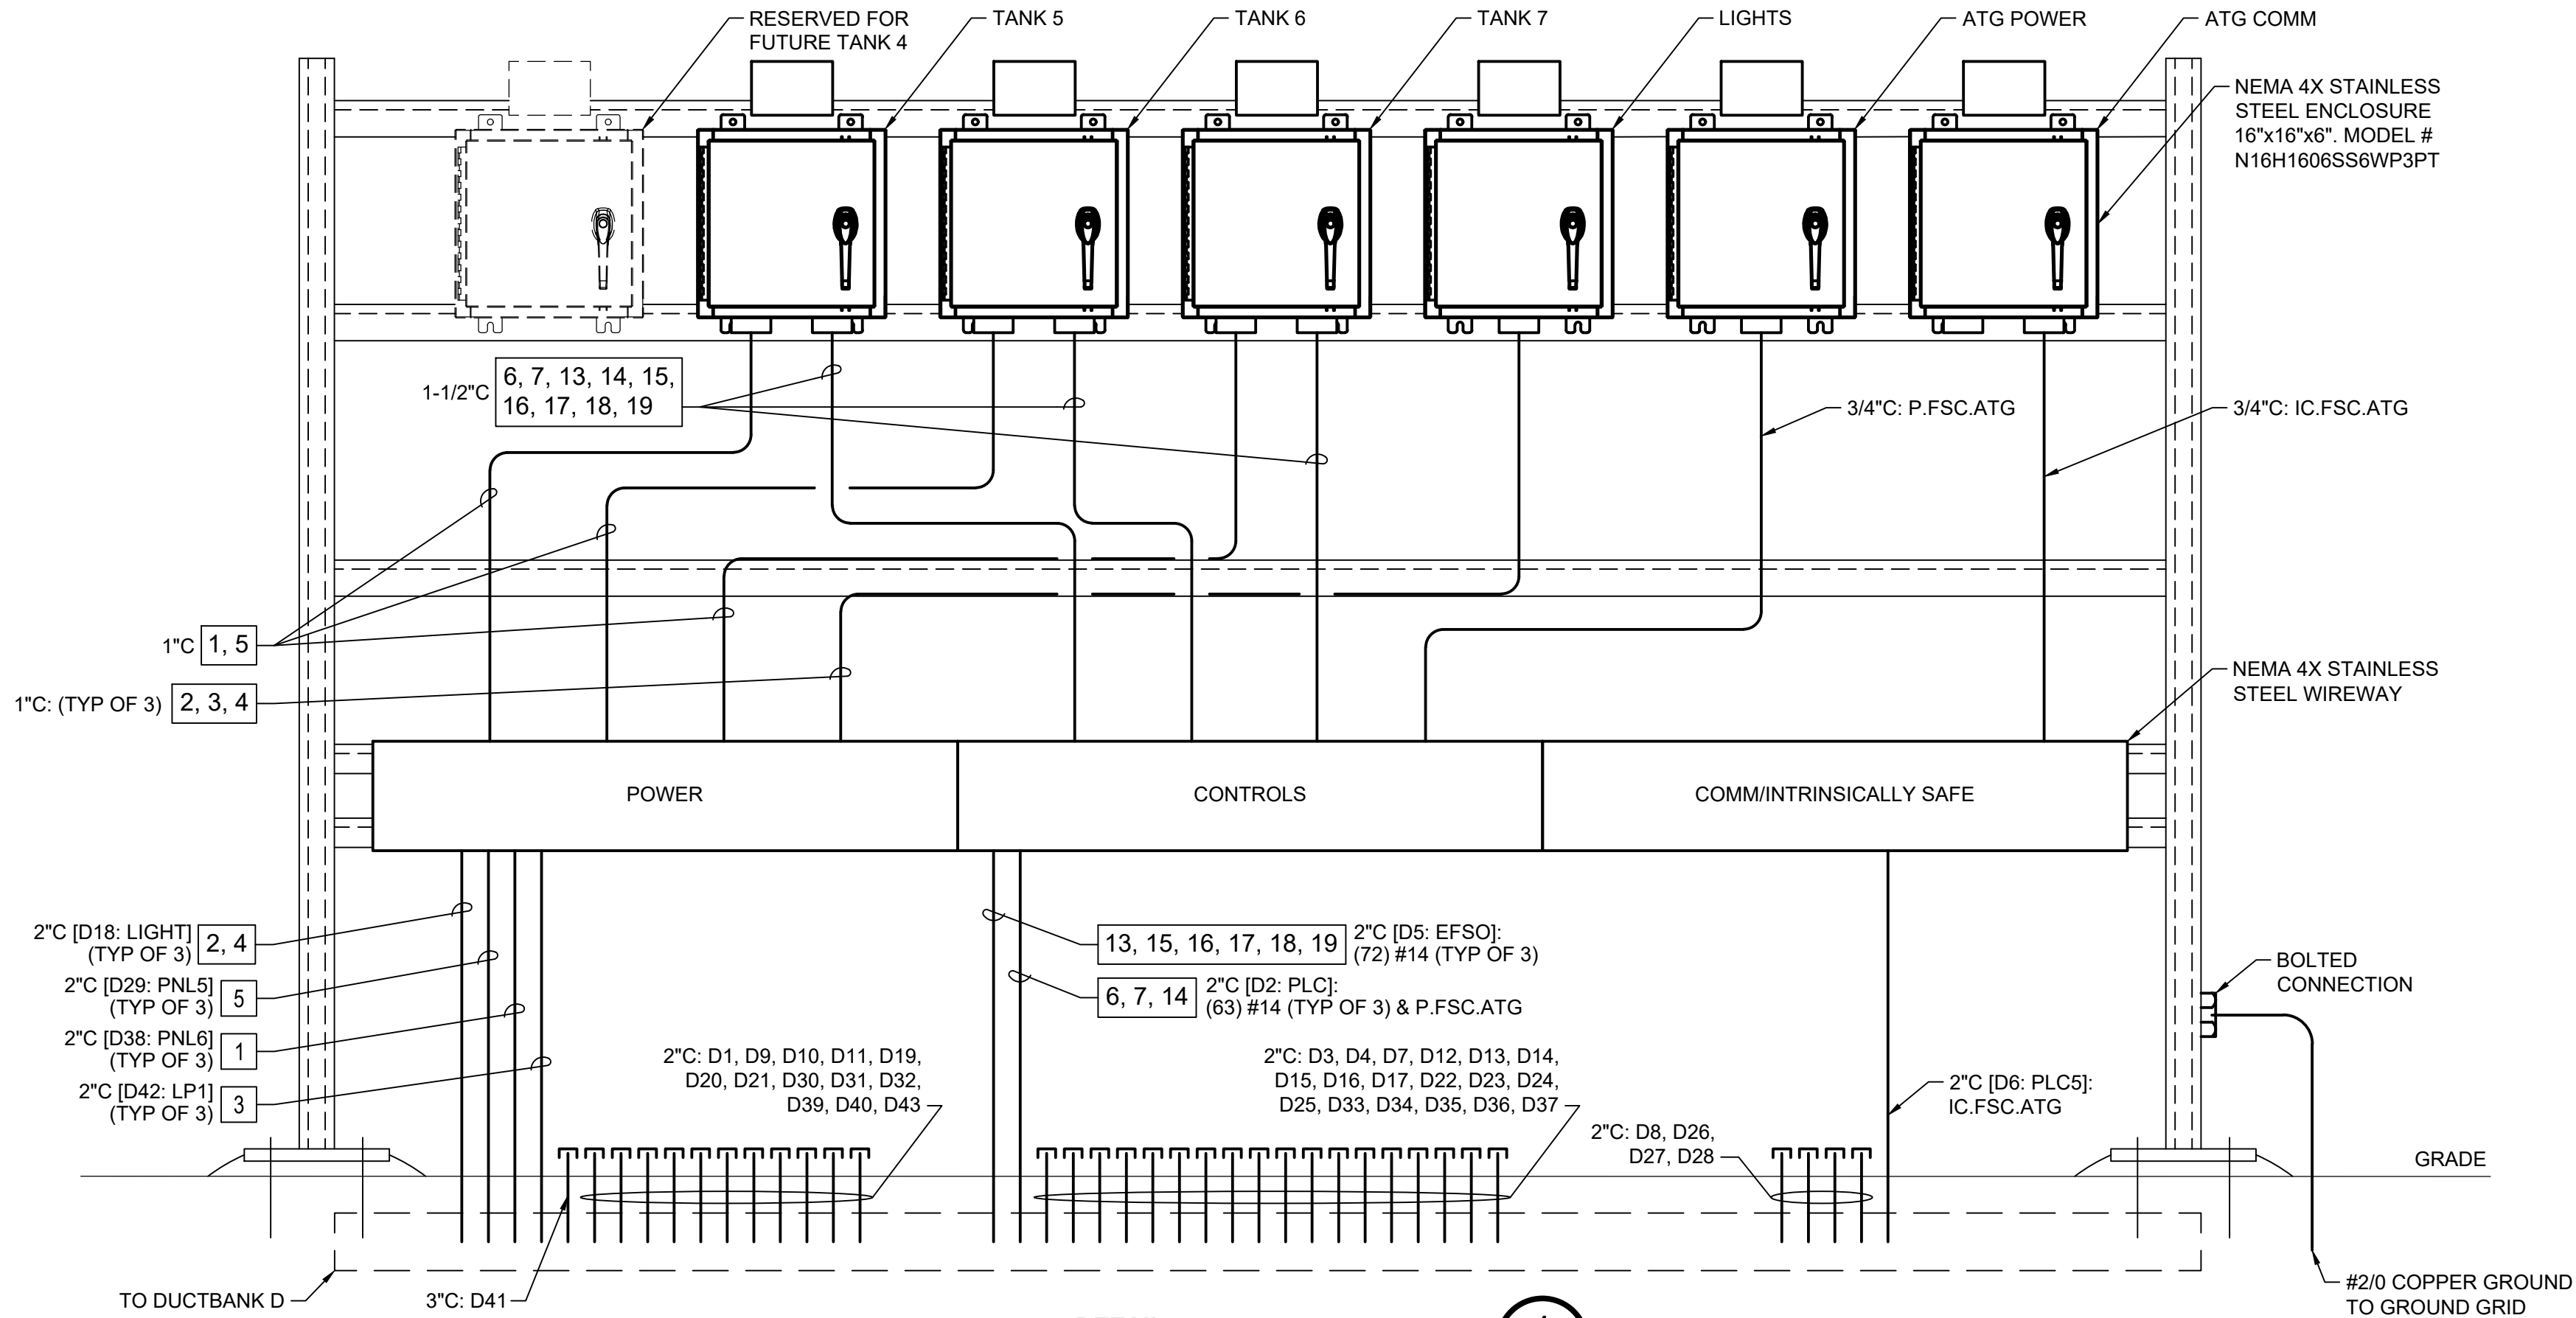

DETAIL 1
ELECTRICAL RACK SECTION
NOT TO SCALE

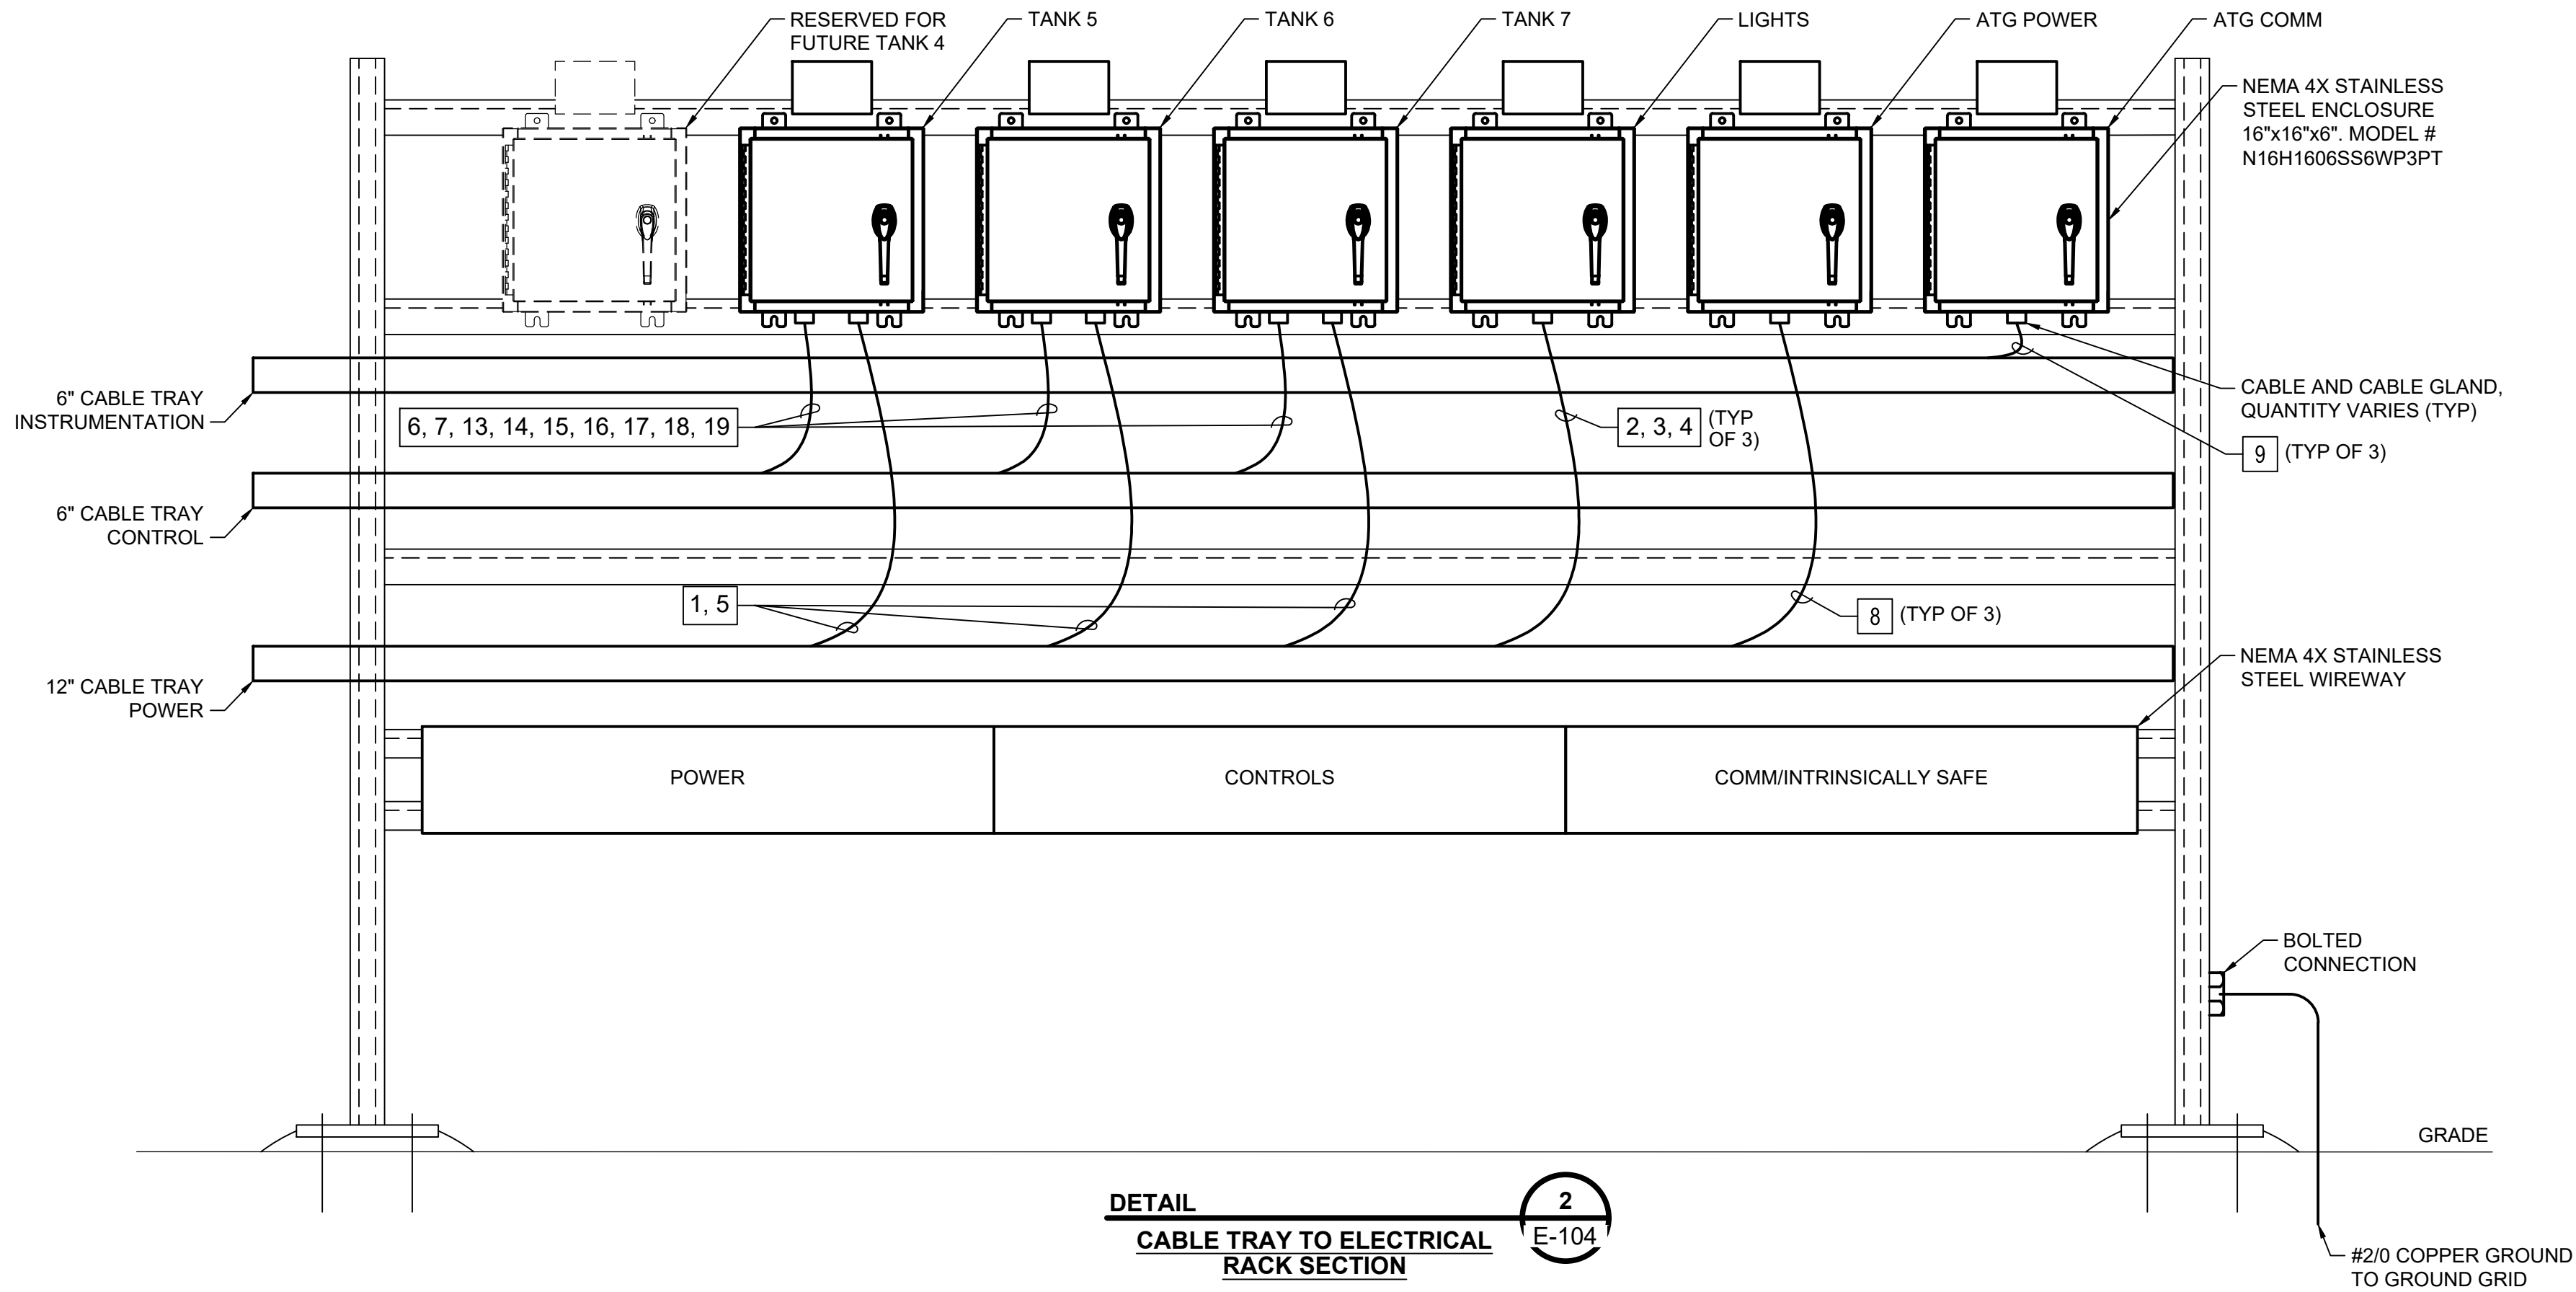

DETAIL 2
CABLE TRAY TO ELECTRICAL RACK SECTION
NOT TO SCALE

no.	date	by	ckd	description
A	12/21/23	TSR	BAW	ISSUED FOR PERMIT

ISSUED FOR PERMIT ONLY



9400 WARD PARKWAY
KANSAS CITY, MO 64114
816-333-9400
Burns & McDonnell Engineering Co., Inc.

date	04/24/2023	detailed	S. JESBERG
designed	T. RENSHAW	checked	B. WINTER

PDX FUEL COMPANY L.L.C

PORTLAND INTERNATIONAL AIRPORT
5000 NE MARINE DR.
PORTLAND, OREGON 97218

PDX FACILITY IMPROVEMENTS
CABLE TRAY ELECTRICAL RACK
ELEVATION

project	153929	contract	
drawing	E-203	rev.	A


file 153929E-203.dwg

NOTES:

1. SEE SHEET E-001 FOR LEGEND, ABBREVIATIONS, AND GENERAL NOTES.
2. NOT ALL SECONDARY SUPPORTS REQUIRED ARE SHOW. PROVIDE ALL C-CHANNEL, CLAMPS AND OTHER APPURTENANCES AS REQUIRED TO SUPPORT CABLE TRAY AS SPECIFIED. ALL CABLE TRAY SHALL BE SUPPORTED PER NEMA VE-2 AND MANUFACTURER REQUIREMENTS.

KEYED NOTES:

- 1 PROVIDE #4 BONDING JUMPER BETWEEN ALL DISCONTINUOUS SECTIONS OF CABLE TRAY.

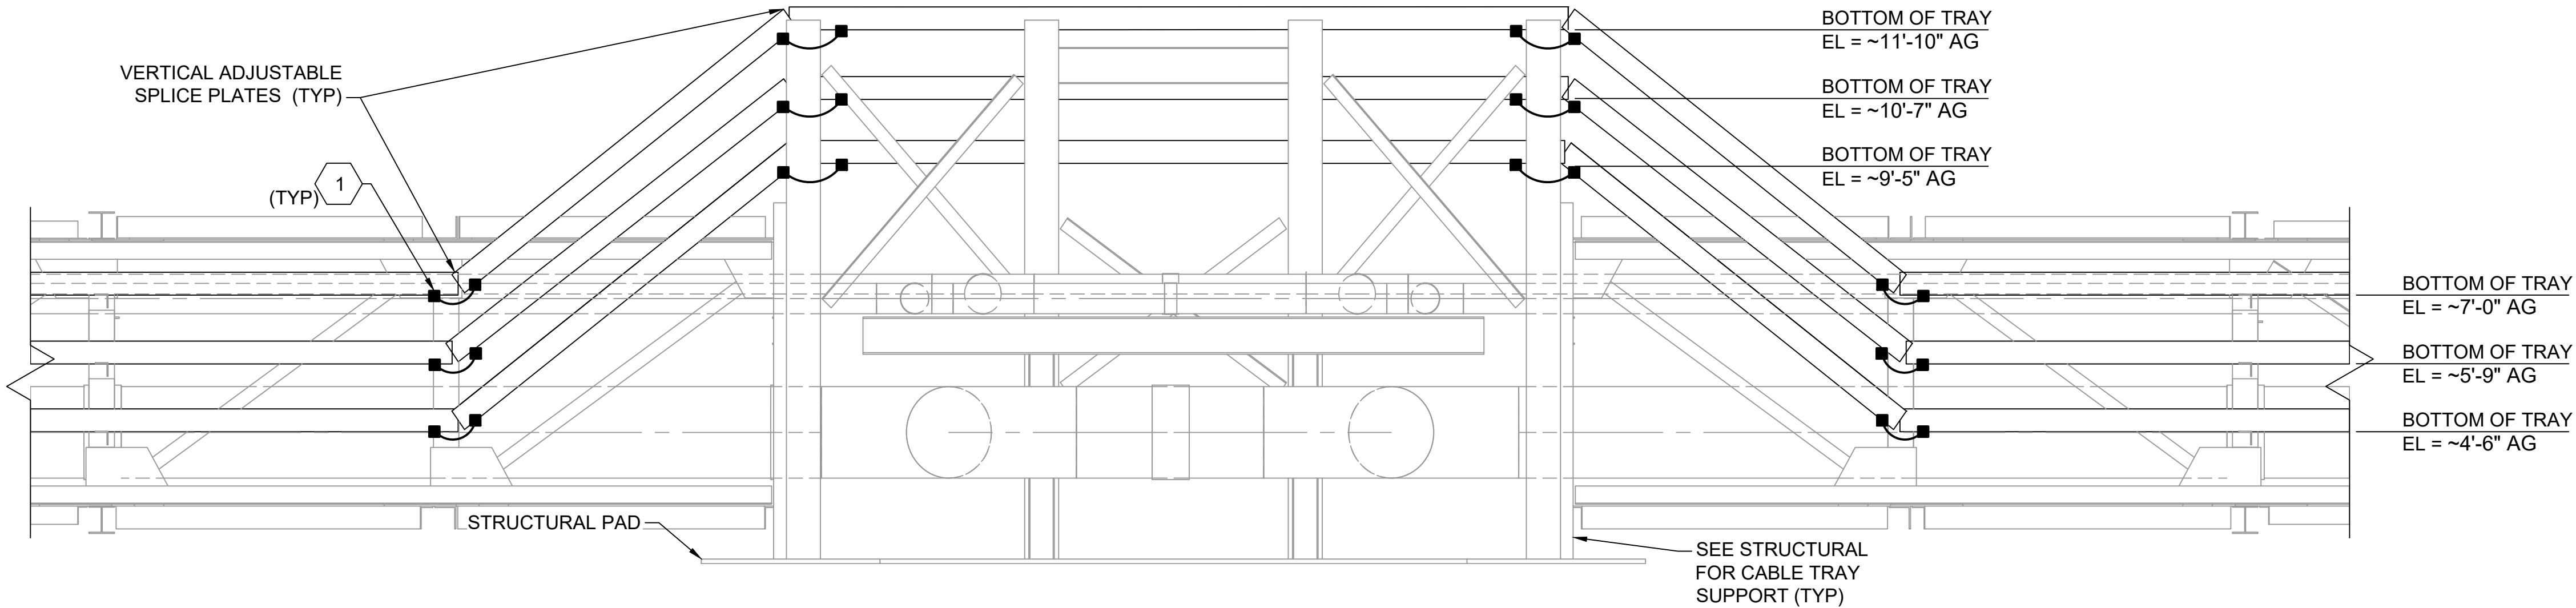

ELEVATION

TYPICAL CABLE TRAY
ELEVATION

1

E-104
E-107

no.	date	by	ckd	description
A	12/21/23	TSR	BAW	ISSUED FOR PERMIT

ISSUED FOR PERMIT
ONLY

**BURNS
MCDONNELL**

9400 WARD PARKWAY
KANSAS CITY, MO 64114
816-333-9400
Burns & McDonnell Engineering Co., Inc.

date	04/24/2023	detailed	S. JESBERG
designed	T. RENSHAW	checked	B. WINTER

PDX FUEL COMPANY L.L.C

PORTLAND INTERNATIONAL AIRPORT
5000 NE MARINE DR.
PORTLAND, OREGON 97218

PDX FACILITY IMPROVEMENTS
TYPICAL CABLE TRAY ELEVATION

project	153929	contract	
drawing	E-204	rev.	A

file 153929E-204.dwg

1'-8"

1'-0 1/2"

12

1

2

CONDUIT SCHEDULE

ID	DESCRIPTION
A1	4"C: (BY UTILITY)
A2	4"C: (BY UTILITY)

2'-11"

1'-8"

8

1

2

3

4

5

6

7

8

CONDUIT SCHEDULE

ID	DESCRIPTION
B1	4"C: (BY KINDER MORGAN)
B2	4"C: P.XFMR.SWGR1
B3	4"C: P.XFMR.SWGR1
B4	4"C: P.XFMR.SWGR1
B5	4"C: (BY KINDER MORGAN)
B6	4"C: P.XFMR.SWGR1
B7	4"C: P.XFMR.SWGR1
B8	4"C: SPARE

4'-6 1/2"

12"

1'-8"

12

1

2

3

4

5

6

7

8

9

10

11

12

CONDUIT SCHEDULE

ID	DESCRIPTION
C1	4"C: SPARE
C2	4"C: P.GEN.ATS1
C3	4"C: P.GEN.ATS1
C4	4"C: P.GEN.ATS1
C5	4"C: P.GEN.ATS1
C6	2"C: C.ATS1.GEN, C.ATS2.GEN, C.FSC.GEN, C.EPO.GEN
C7	4"C: SPARE
C8	4"C: P.GEN.ATS2
C9	4"C: P.GEN.ATS2
C10	4"C: P.GEN.ATS2
C11	4"C: P.GEN.ATS2
C12	2"C: IC.GEN.RGAP

SECTION

NOT TO SCALE

A

E-103
E-111A
E-111B

SECTION

NOT TO SCALE

B

E-103
E-111A
E-111B
E-401
E-404

SECTION

NOT TO SCALE

C

E-103
E-111A
E-111B
E-401

6'-5 1/4"

12"

2'-3 5/8"

9

1

18

39

11

2

6

12

34

38

25

5

17

13

20

26

27

33

42

23

24

28

31

32

35

36

37

15

43

3

4

7

8

10

14

16

21

22

29

30

40

41

SECTION VIEW D - POST MANHOLE

6'-5 1/4"

12"

2'-3 5/8"

42

1

2

3

4

5

6

7

8

9

43

10

11

12

13

14

15

16

17

18

19

20

21

22

23

24

25

26

27

28

29

30

31

32

33

34

35

36

37

38

39

40

41

SECTION VIEW D* - PRE MANHOLE

CONDUIT SCHEDULE

ID	DESCRIPTION
D1	2"C: SPARE
D2	2"C: C.FSC.T5A, C.FSC.T6A, C.FSC.T7A, C.FSC.T5B, C.FSC.T6B, C.FSC.T7B, C.DSLSH.T5, C.DSLSH.T6, C.DSLSH.T7, P.FSC.ATG
D3	2"C: SPARE
D4	2"C: SPARE
D5	2"C: C.LS.T5, C.LS.T6, C.LS.T7, C.EFSO.T5W, C.EFSO.T6W, C.EFSO.T7W, C.EFSO.T5E, C.EFSO.T6E, C.EFSO.T7E, C.EFSOT5I, C.EFSO.T6I, C.EFSO.T7I, C.EFSO.T5A, C.EFSO.T6A, C.EFSO.T7A, C.EFSO.T5B, C.EFSO.T6B, C.EFSO.T7B
D6	2"C: IC.FSC.ATG
D7	2"C: SPARE
D8	2"C: SPARE
D9	2"C: SPARE
D10	2"C: SPARE
D11	2"C: SPARE
D12	2"C: SPARE

D13

2"C: SPARE

D14

2"C: SPARE

D15

2"C: SPARE

D16

2"C: SPARE

D17

2"C: SPARE

D18

2"C: P.LP1.21.1, P.LP1.23.1, P.LP1.25.1
P.LP1.20.1, P.LP1.24.1, P.LP1.20.1

D19

2"C: SPARE

D20

2"C: SPARE

D21

2"C: SPARE

D22

2"C: SPARE

D23

2"C: SPARE

D24

2"C: SPARE

D25

2"C: SPARE

D26

2"C: SPARE

D27

2"C: SPARE

D28

2"C: SPARE

CONDUIT SCHEDULE

ID	DESCRIPTION
D29	2"C: P.PNL5.32, P.PNL5.37, P.PNL5.38
D30	2"C: SPARE
D31	2"C: SPARE
D32	2"C: SPARE
D33	2"C: SPARE
D34	2"C: SPARE
D35	2"C: SPARE
D36	2"C: SPARE
D37	2"C: SPARE
D38	2"C: P.PNL6.30, P.PNL6.31, P.PNL6.35
D39	2"C: SPARE
D40	2"C: SPARE
D41	3"C: SPARE
D42	2"C: P.LP1.32, P.LP1.34, P.LP1.36
D43	2"C: SPARE

D44

2"C: SPARE

D45

2"C: SPARE

D46

2"C: SPARE

D47

2"C: SPARE

D48

2"C: SPARE

D49

2"C: SPARE

D50

2"C: SPARE

D51

2"C: SPARE

D52

2"C: SPARE

D53

2"C: SPARE

D54

2"C: SPARE

D55

2"C: SPARE

D56

2"C: SPARE

D57

2"C: SPARE

D58

2"C: SPARE

D59

2"C: SPARE

D60

2"C: SPARE

D61

2"C: SPARE

D62

2"C: SPARE

D63

2"C: SPARE

D64

2"C: SPARE

D65

2"C: SPARE

D66

2"C: SPARE

D67

2"C: SPARE

D68

2"C: SPARE

D69

2"C: SPARE

D70

2"C: SPARE

D71

2"C: SPARE

D72

2"C: SPARE

D73

2"C: SPARE

D74

2"C: SPARE

D75

2"C: SPARE

D76

2"C: SPARE

D77

2"C: SPARE

D78

2"C: SPARE

D79

2"C: SPARE

D80

2"C: SPARE

D81

2"C: SPARE

D82

2"C: SPARE

D83

2"C: SPARE

D84

2"C: SPARE

D85

2"C: SPARE

D86

2"C: SPARE

D87

2"C: SPARE

D88

2"C: SPARE

D89

2"C: SPARE

D90

2"C: SPARE

D91

2"C: SPARE

D92

2"C: SPARE

D93

2"C: SPARE

D94

2"C: SPARE

D95

2"C: SPARE

D96

2"C: SPARE

D97

2"C: SPARE

D98

2"C: SPARE

D99

2"C: SPARE

D100

2"C: SPARE

3'-7 7/8"

12"

10 3/8"

1

2

3

4

5

6

CONDUIT SCHEDULE

ID	DESCRIPTION
E1	2"C:P.MCC1.PP1, C.HS.TP2.2
E2	2"C: IC.FSC.TEMP - NOT IN USE, I.LT.WT
E3	2"C: IC.FSC.AFS
E4	2"C: C.LSH.500, C.FSC.SG, C.FSC.SLTLSHH, C.FSC.SLTLA, C.FSC.LABLSH, C.FSC.KM - NOT IN USE, C.EFSO.AIRSIDE - NOT IN USE
E5	2"C: SPARE
E6	2"C: SPARE

SECTION

NOT TO SCALE

D

E-103
E-104A E-104
E-111A E-111B
E-401 E-404

SECTION

NOT TO SCALE

E

E-103
E-111A
E-111B

NOTES:

- SEE SHEET E-001 FOR GENERAL NOTES, LEGEND AND ABBREVIATIONS.
- PREMANHOLE DUCTBANKS SHOWN WITH ASTERISK.

no.	date	by	ckd	description
A	12/21/23	TSR	BAW	ISSUED FOR PERMIT

ISSUED FOR PERMIT
ONLY

9400 WARD PARKWAY
KANSAS CITY, MO 64114
816-333-9400
Burns & McDonnell Engineering Co., Inc.

date	04/24/2023	detailed	S. JESBERG
designed	T. RENSHAW	checked	B. WINTER

PDX FUEL COMPANY L.L.C

PORTLAND INTERNATIONAL AIRPORT
5000 NE MARINE DR.
PORTLAND, OREGON 97218

PDX FACILITY IMPROVEMENTS
DUCTBANK SECTIONS - 1

project	153929	contract	
drawing	E-301	rev.	A

file 153929E-301.dwg

\\BMCD.BURNSMCD.COM\DFS\CLIENTS\ANF\PORTLAND\PORT\PD\153929_FACILITY\IMPRV\DESIGN\ELEC\SHEETS\153929E-301.DWG 12/20/2023 12:55 PM JLITTLE

SECTION VIEW F* - PRE MANHOLE

SECTION VIEW F - POST MANHOLE


CONDUIT SCHEDULE	
ID	DESCRIPTION
F1	4"C: P.P.NL5.1, P.P.NL5.2, P.P.NL5.7, P.P.NL6.8
F2	4"C: SPARE
F3	2"C: P.MCC1.PP1, C.HS.TP2.2,
F4	2"C: (BY KINDER MORGAN)
F5	2"C: (BY KINDER MORGAN)
F6	2"C: (BY KINDER MORGAN)
F7	2"C: (BY KINDER MORGAN)
F8	2"C: IC.FSC.TEMP - NOT IN USE, I.LT.WT
F9	2"C: IC.FSC.AFS
F10	4"C: P.P.NL5.8, P.P.NL5.13, P.P.NL5.14
F11	4"C: P.VFD1.HP1, C.HTR.HP1, C.MWTS.HP1
F12	4"C: P.VFD2.HP2, C.HTR.HP2, C.MWTS.HP2
F13	4"C: P.VFD3.HP3, C.HTR.HP3, C.MWTS.HP3
F14	4"C: P.VFD4.HP4, C.HTR.HP4, C.MWTS.HP4

F15	3°C: C.MOV1A.CTL, C.MOV1B.CTL, C.MOV2A.CTL, C.MOV2B.CTL,C.MOV3A.CTL, C.MOV3B.CTL, C.EFSO.MOV1A, C.EFSO.MOV1B, C.EFSO.MOV2A, C.EFSO.MOV2B, C.EFSO.MOV3A, C.EFSO.MOV3B,
F16	3°C: C.FSC.CJB1.1, C.FSC.CJB1.2
F17	3°C: I.FSC.CJB1.3, I.FSC.CJB1.4, P.FE.RCL1
F18	3°C: C.ME.HFS1, C.J.Y.HP1, C.FSTS.HP1, C.ME.HFS2, C.J.Y.HP2, C.FSTS.HP2, C.ME.HFS3, C.J.Y.HP3, C.FSTS.HP3, C.ME.HFS4, C.J.Y.HP4, C.FSTS.HP4, C.ME.HFS5, C.J.Y.HP5, C.FSTS.HP5
F19	2°C: C.TANK1.CTLP, C.TANK2.CTLP, C.TANK3.CTLP, C.LSHH.T1, C.LSHH.T2, C.LSHH.T3
F20	2°C: C.LSH.500, C.FSC.SG, C.FSC.SLTLSSH, C.FSC.SLTLA, C.FSC.LABLSH, C.FSC.KM - NOT IN USE, C.EFSO.AIRSIDE - NOT IN USE
F21	4°C: SPARE

F22	4°C: P.MCC1.TP2, C.HTR.TP2, C.MWTS.TP2, C.HS.TP2.1, C.FS.TP2, C.JY.TP2
F23	4°C: P.VFD5.HP5, C.HTR.HP5, C.MWTS.HP5
F24	4°C: (FUTURE HP-6)
F25	4°C: (FUTURE HP-7)
F26	3°C: SPARE
F27	3°C: IS.TLS.HCARBON
F28	2°C: IC.FSC.WTG
F29	2°C: SPARE
F30	2°C: C.HS.HP1.1, C.HS.HP1.2, C.HS.HP2.1, C.HS.HP2.2, C.HS.HP3.1, C.HS.HP3.2, C.HS.HP4.1, C.HS.HP4.2, C.HS.HP5.1, C.HS.HP5.2
F31	2°C: SPARE
F32	4°C: CATHODIC PROTECTION
F33	4°C: SPARE
F34	2°C: SPARE

CONDUIT SCHEDULE	
ID	DESCRIPTION
G1	4"C: P.PNL5.1, P.PNL5.2, P.PNL5.7, P.PNL6.8
G2	4"C: P.PNL5.8, P.PNL5.13, P.PNL5.14
G3	4"C: P.VFDHP1.HP1, C.HTR.HP1, C.MWTS.HP1
G4	4"C: P.VFDHP2.HP2, C.HTR.HP2, C.MWTS.HP2
G5	4"C: P.VFDHP3.HP3, C.HTR.HP3, C.MWTS.HP3
G6	4"C: P.VFDHP4.HP4, C.HTR.HP4, C.MWTS.HP4
G7	3"C: C.MOV1A.CTL, C.MOV1B.CTL, C.MOV2A.CTL, C.MOV2B.CTL, C.MOV3A.CTL, C.MOV3B.CTL, C.EFSS.MOV1A, C.EFSS.MOV1B, C.EFSS.MOV2A, C.EFSS.MOV2B, C.EFSS.MOV3A, C.EFSS.MOV3B,
G8	3"C: C.FSC.CJB1.1, C.FSC.CJB1.2
G9	1.FSC.CJB1.3, 1.FSC.CJB1.4, P.FE.RCL1
G10	3"C: C.ME.HFS1, C.JY.HP1, C.FSTS.HP1, C.ME.HFS2, C.JY.HP2, C.FSTS.HP2, C.ME.HFS3, C.JY.HP3, C.FSTS.HP3, C.ME.HFS4, C.JY.HP4, C.FSTS.HP4, C.ME.HFS5, C.JY.HP5 C.FSTS.HP5,

G11	2°C: C.HS.HP1.1, C.HS.HP1.2, C.HS.HP2.1, C.HS.HP2.2, C.HS.HP3.1, C.HS.HP3.2, C.HS.HP4.1, C.HS.HP4.2, C.HS.HP5.1, C.HS.HP5.2
G12	4°C: SPARE
G13	4°C: SPARE
G14	4°C: P.MCC1.TP2, C.HTR.TP2, C.MWTS.TP2, C.HS.TP2.1, C.FS.TP2, C.JY.TP2
G15	4°C: P.VFDHP5.HP5, C.HTR.HP5, C.MWTS.HP5
G16	4°C: (FUTURE HP-6)
G17	4°C: (FUTURE HP-7)
G18	3°C: SPARE
G19	3°C: IS.TLS.HCARBON
G20	2°C: IC.FSC.WTG
G21	2°C: C.TANK1.CTLP, C.TANK2.CTLP, C.TANK3.CTLP, C.LSHH.T1, C.LSHH.T2, C.LSHH.T3
G22	2°C: SPARE
G23	4°C: CATHODIC PROTECTION
G24	4°C: SPARE
G25	2°C: (BY KINDER MORGAN)
G26	2°C: (BY KINDER MORGAN)
G27	2°C: (BY KINDER MORGAN)
G28	2°C: (BY KINDER MORGAN)

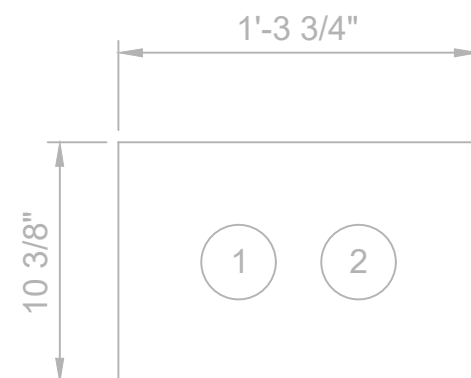

CONDUIT SCHEDULE	
ID	DESCRIPTION
H1	2"C: C.H.S.HP1.1, C.H.S.HP1.2, C.H.S.HP2.1, C.H.S.HP2.2, C.H.S.HP3.1, C.H.S.HP3.2, C.H.S.HP4.1, C.H.S.HP4.2, C.H.S.HP5.1, C.H.S.HP5.2
H2	2"C: SPARE (FUTURE HP-6, HP-7)

CONDUIT SCHEDULE	
ID	DESCRIPTION
11	4"C: P.P.NL5.1, P.P.NL5.2, P.P.NL5.7, P.P.NL6.8
12	4"C: SPARE
13	4"C: P.VFD1.HP1, C.HTR.HP1, C.MWTS.HP1
14	4"C: P.VFD2.HP2, C.HTR.HP2, C.MWTS.HP2
15	4"C: P.VFD3.HP3, C.HTR.HP3, C.MWTS.HP3
16	4"C: P.VFD4.HP4, C.HTR.HP4, C.MWTS.HP4
17	4"C: P.P.NL5.8, P.P.NL5.13, P.P.NL5.14
18	4"C: SPARE
19	4"C: P.MCC1.TP2, C.HTR.TP2, C.MWTS.TP2, C.HS.TP2.1, C.FS.TP2, C.JY.TP2
110	4"C: P.VFD5.HP5, C.HTR.HP5, C.MWTS.HP5
111	4"C: (FUTURE HP-6)
112	4"C: (FUTURE HP-7)
113	4"C: CATHODIC PROTECTION
114	4"C: SPARE

CONDUIT SCHEDULE	
ID	DESCRIPTION
J1	3"C: C.MOV1A.CTL, C.MOV1B.CTL, C.MOV2A.CTL, C.MOV2B.CTL, C.MOV3A.CTL, C.MOV3B.CTL, C.EFSO.MOV1A, C.EFSO.MOV1B, C.EFSO.MOV2A, C.EFSO.MOV2B, C.EFSO.MOV3A, C.EFSO.MOV3B.
J2	3"C: C.FSC.CJB1.1, C.FSC.CJB1.2
J3	3"C: 1.FSC.CJB1.3, 1.FSC.CJB1.4, P.FE.RCL1
J4	3"C: C.ME.HFS1, C.JY.HP1, C.FSTS.HP1, C.ME.HFS2, C.JY.HP2, C.FSTS.HP2, C.ME.HFS3, C.JY.HP3, C.FSTS.HP3, C.ME.HFS4, C.JY.HP4, C.FSTS.HP4, C.ME.HFS5, C.JY.HP5 C.FSTS.HP5,
J5	3"C: SPARE
J6	2"C: IS.TLS.HCARBON
J7	2"C: 1C.FSC.WTG
J8	2"C: C.TANK1.CTLP, C.TANK2.CTLP, C.TANK3.CTLP, C.LSHH.T1, C.LSHH.T2, C.LSHH.T3

12/20/2023

no.	date	by	ckd	description
A	12/21/23	TSR	BAW	ISSUED FOR PERMIT

**ISSUED FOR PERMIT
ONLY**



9400 WARD PARKWAY
KANSAS CITY, MO 64114
816-333-9400

Burns & McDonnell Engineering Co, Inc.

date 04/24/2023	detailed S. JESBERG
designed T. RENSHAW	checked B. WINTER


PDX FUEL COMPANY L.L.C

PORTLAND INTERNATIONAL AIRPORT
5000 NE MARINE DR.
PORTLAND, OREGON 97218

PDX FACILITY IMPROVEMENTS
DUCTBANK SECTIONS - 2


project	contract
153929	
drawing	rev.

file 153929E-302.dwg

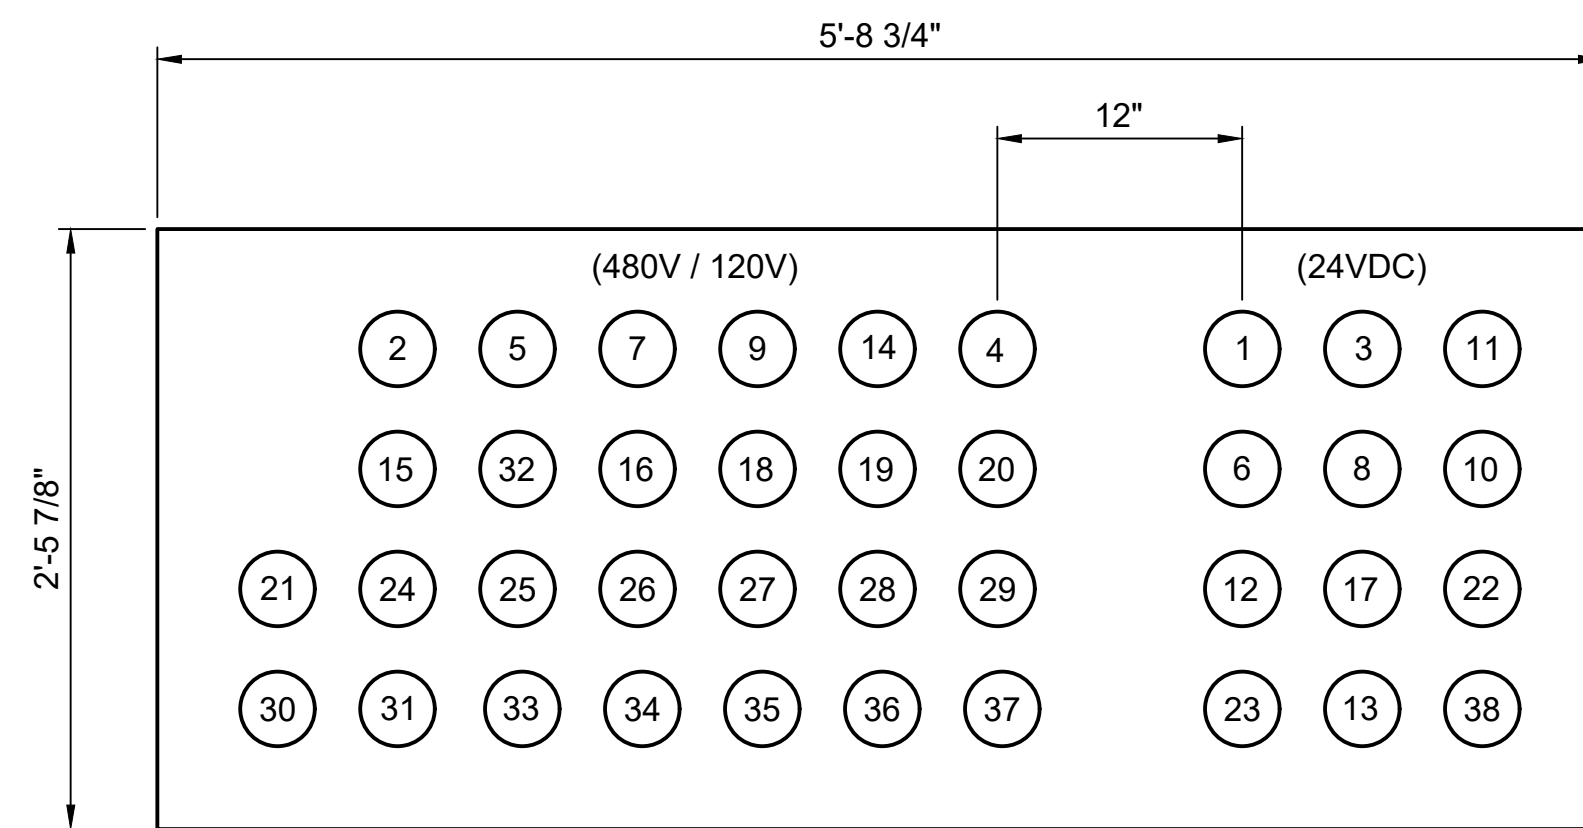

NOTE:


1. SEE SHEET E-001 FOR GENERAL NOTES, LEGEND AND ABBREVIATIONS.

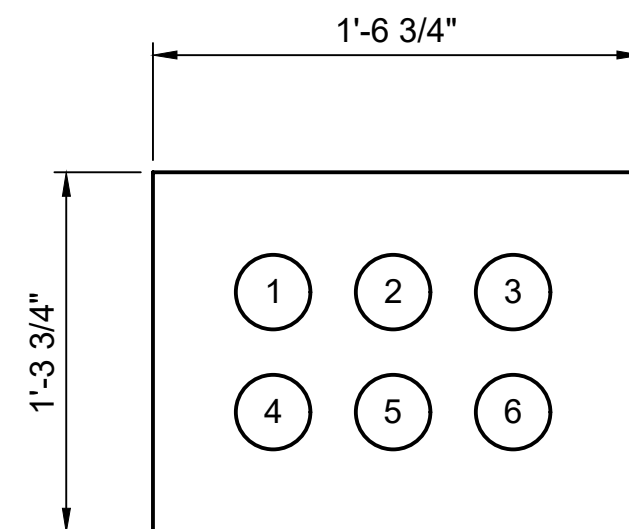




CONDUIT SCHEDULE	
ID	DESCRIPTION
S1	2"C: IC, OPS.EC02, IC, OPS.EC03, IC, OPS.EC04, IC, OPS.EC05, IC, OPS.EC06
S2	2"C: P.PA2.75 (EC02, EC03, EC06) , P.PA2.77 (EC04, EC05)
S3	2"C: P.PNLP5.26 (CONSTR. TRAILER POWER)
S4	2"C: IC, EC02, CT22, IC, EC02, CT23
S5	2"C: SPARE
S6	2"C: SPARE

CONDUIT SCHEDULE	
ID	DESCRIPTION
T1	2"C: SPARE
T2	2"C: C.FSC.MOVRCS, C.FSC.MOVRCR, C.EFSO.MOVRCS, C.EFSO.MOVRCP
T3	2"C: I.FIT.OP2, P.FIT.OP2, I.PT.TP1, I.TT.TP1, I.VTX.TP1, I.VTY.TP1, P.FIT.HCTS, I.FIT.HCTS, I.DPIT.RFS1, I.DPIT.RFS2
T4	2"C: C.MS.RFS1, C.MS.RFS2, C.LSH.SS4, C.LSH.RCT
T5	2"C: P.FIT.OP1, I.FIT.OP1
T6	2"C: SPARE
T7	3"C: P.MCC1.OP1, C.MWTS.OP1, C.HTR.OP1, C.FS.OP1, C.HS.OP1
T8	2"C: SPARE
T9	2"C: C.EFSO.OP1
T10	2"C: SPARE
T11	2"C: SPARE
T12	2"C: SPARE
T13	2"C: SPARE
T14	2"C: C.EFSO.HCTS, C.EFSO.OP2
T15	2"C: C.FSC.HCTSAP
T16	2"C: SPARE


T17	2°C: SPARE
T18	2°C: P.PNL5.19
T19	3°C: P.MCC1.OP2, C.MWTS.OP2, C.HTR.OP2, C.FS.OP2, C.HS.OP2
T20	2°C: C.TLS.OAS
T21	2°C: SPARE
T22	2°C: IS.TLS.LT.RCT, IS.TLS.LD.RCT
T23	2°C: SPARE
T24	2°C: SPARE
T25	2°C: SPARE
T26	2°C: SPARE
T27	2°C: SPARE
T28	2°C: P.PNL6.34, P.LP1.11
T29	2°C: SPARE
T30	3°C: P.VFDTP1.TP1, C.HTR.TP1, C.MWTS.TP1, C.FSTS.TP1, C.HS.HCTS
T31	2°C: P.LP1.7.1
T32	2°C: P.PNL5.26 (CONSTR. TRAILER POWER)
T33	2°C: SPARE
T34	2°C: SPARE
T35	2°C: SPARE
T36	IC.OPS.EC02, IC.OPS.EC03, IC.OPS.EC04, IC.OPS.EC05
T37	2°C: P.PA2.75 (EC02,EC03,EC06), P.PA2.77 (EC04,EC05)
T38	2°C: SPARE

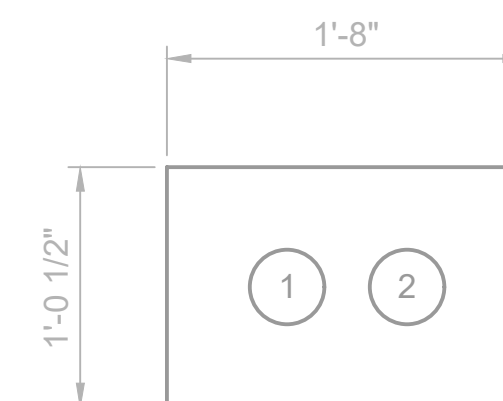


CONDUIT SCHEDULE	
ID	DESCRIPTION
V1	4"C: (BY KINDER MORGAN)
V2	4"C: (BY KINDER MORGAN)

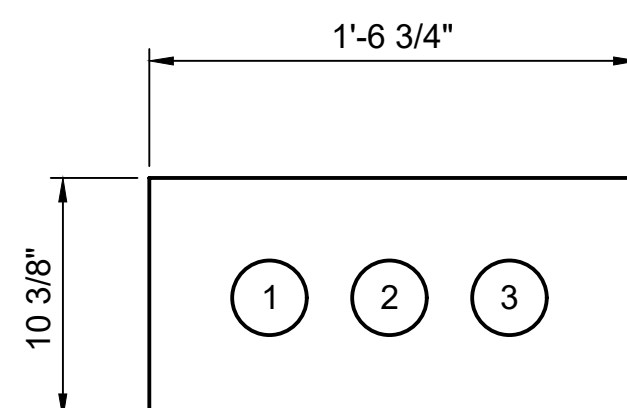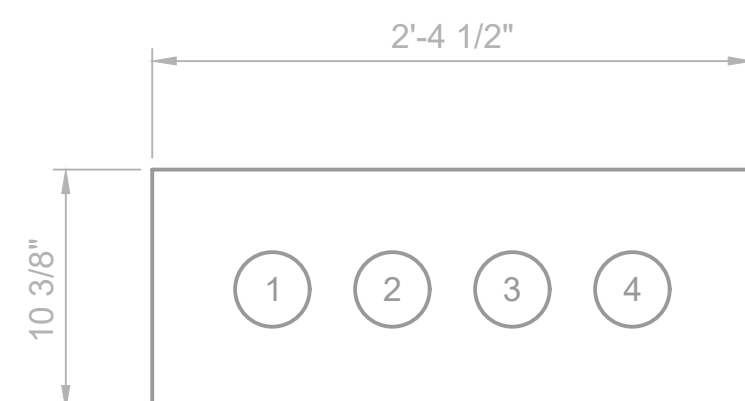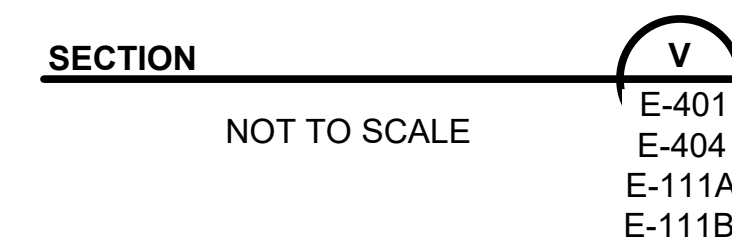

CONDUIT SCHEDULE	
ID	DESCRIPTION
X1	2" C: IC. OPS.EC03, IC. OPS.EC04, IC. OPS.EC05, IC. OPS.EC06
X2	2" C: P.PA2.75 (EC02, EC03, EC06) , P.PA2.77 (EC04, EC05)
X3	2" C: P.PNLH1 X (AREA LIGHTS) FED FROM OPERATIONS BUILDING LIGHTING CONTACTOR (SEE OPERATIONS BUILDING PANEL SCHEDULE)

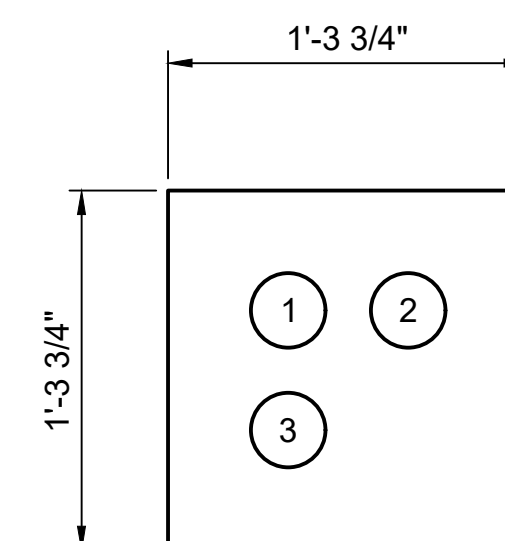

CONDUIT SCHEDULE	
ID	DESCRIPTION
Y1	2" C: IC, OPS.EC02, IC, OPS.EC03, IC, OPS.EC04, IC, OPS.EC05, IC, OPS.EC06
Y2	2" C: P.PA2.75 (EC02, EC03, EC04) , P.PA2.77 (EC05, EC06) (SEE OPERATIONS BUILDING PANEL SCHEDULE)
Y3	2" C: SPARE

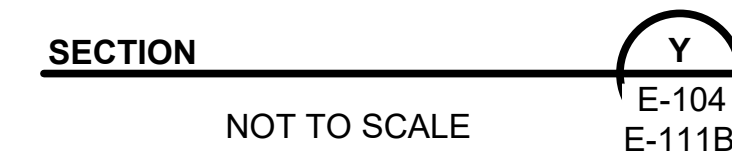

12/20/2023

no.	date	by	ckd	description
A	12/21/23	TSR	BAW	ISSUED FOR PERMIT

**ISSUED FOR PERMIT
ONLY**



9400 WARD PARKWAY
KANSAS CITY, MO 64114
816-333-9400
ns & McDonnell Engineering Co, Inc.

date	detailed
04/24/2023	S. JESBERG
designed	checked
T. RENSHAW	B. WINTER

PDX FUEL COMPANY L.L.C

PORTLAND INTERNATIONAL AIRPORT
5000 NE MARINE DR.
PORTLAND, OREGON 97218

PDX FACILITY IMPROVEMENTS
DUCTBANK SECTIONS - 4


project	contract
153929	
drawing	rev.

E-304

A

file 153929E-304.dwg

NOTE:
1. SEE SHEET E-001 FOR GENERAL NOTES, LEGEND AND ABBREVIATIONS.

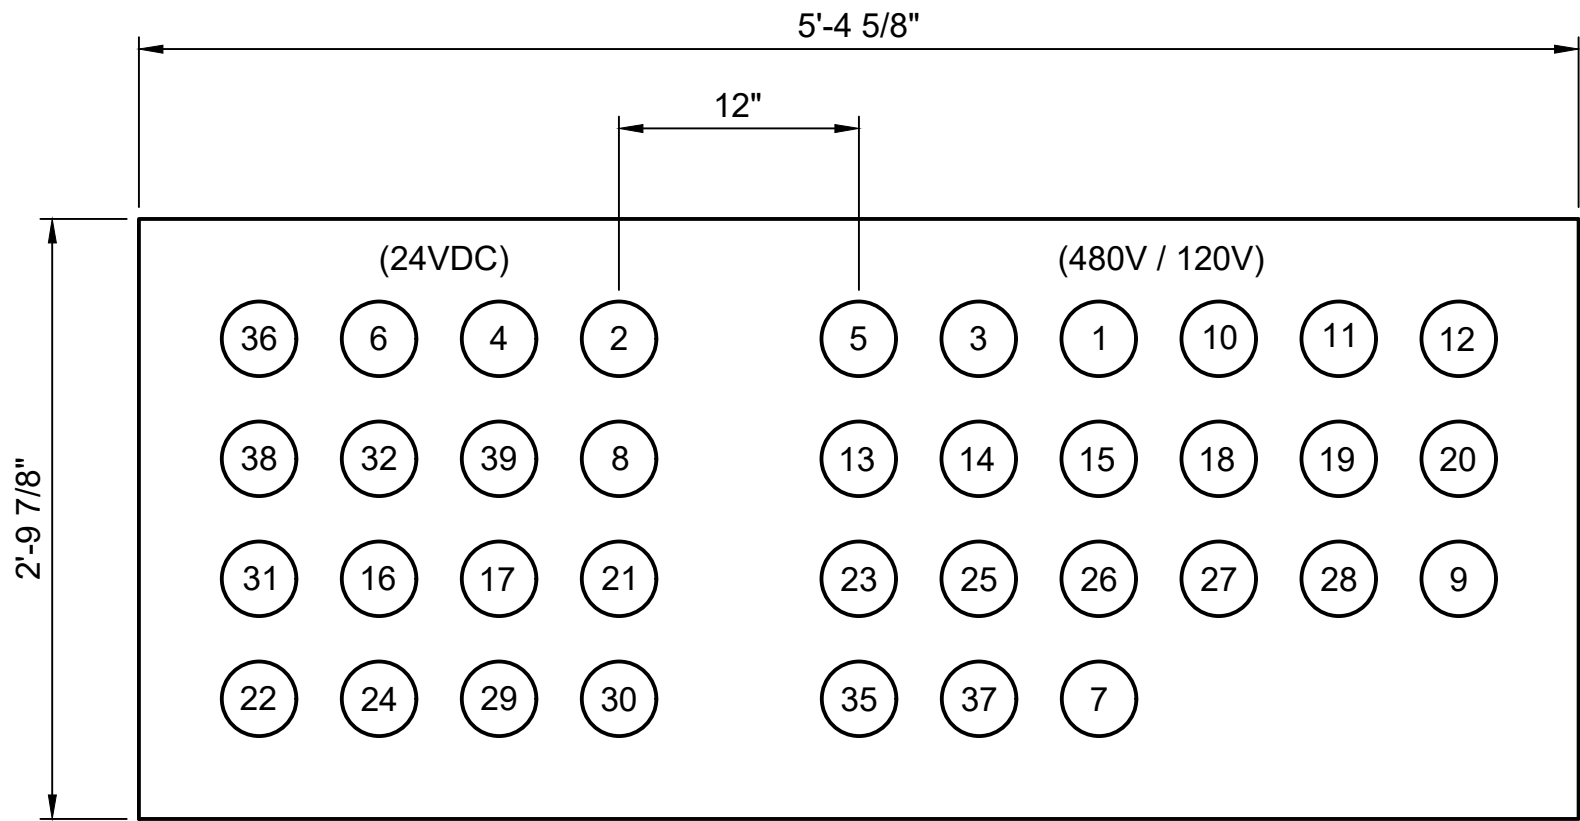


CONDUIT SCHEDULE			
ID	DESCRIPTION		
Z1	2"C: C.EFSO.OP1, C.EFSO.OP2, C.EFSO.HCTS		
Z2	2"C: P.FIT.OP1, I.FIT.OP1		
Z3	2"C: P.PNLP5.26 (CONSTR. TRAILER POWER)		
Z4	2"C: IC.FSC.AFS		
Z5	2"C: SPARE		
Z6	2"C: SPARE		
Z7	2"C: C.FSC.MOVRCS, C.FSC.MOVRCR, C.EFSO.MOVRCS, C.EFSO.MOVRCR		
Z8	2"C: I.FIT.OP2, P.FIT.OP2, I.PT.TP1, I.TT.TP1, I.VTX.TP1, I.VTY.TP1, P.FIT.HCTS, I.FIT.HCTS, I.DPIT.RFS1, I.DPIT.RFS2		
Z9	C.MS.RFS1, C.MS.RFS2, C.LSH.SS4, C.LSHH.RCT		
Z10	2"C: SPARE		
Z11	2"C: SPARE		
Z12	2"C: SPARE		
Z13	2"C: SPARE		
Z14	2"C: P.LP1.7.1, P.LP1.11		
Z15	3"C: P.MCC1.OP1, C.MWTS.OP1, C.HTR.OP1, C.FS.OP1, C.HS.OP1		
Z16	2"C: SPARE		
Z17	2"C: SPARE		
Z18	2"C: SPARE		
Z19	2"C: SPARE		
Z20	2"C: C.TLS.OAS		
Z21	2"C: SPARE		
Z22	2"C: C.FSC.HCTSAP		
Z23	2"C: SPARE		
Z24	2"C: SPARE		
Z25	2"C: P.PNL5.19		
Z26	3"C: P.MCC1.OP2, C.MWTS.OP2, C.HTR.OP2, C.FS.OP2, C.HS.OP2		
Z27	2"C: SPARE		
Z28	2"C: SPARE		
Z29	2"C: IS.TLS.LT.RCT, IS.TLS.LD.RCT		
Z30	2"C: SPARE		
Z31	2"C: SPARE		
Z32	2"C: SPARE		
Z33	NOT USED		
Z34	NOT USED		
Z35	2"C: P.PNL6.34		
Z36	2"C: IC.AOA.FIBER		
Z37	3"C: P.VFDTP1.TP1, C.HTR.TP1, C.MWTS.TP1, C.FSTS.TP1, C.HS.HCTS		
Z38	2"C: SPARE		
Z39	2"C: SPARE		

SECTION

NOT TO SCALE

Z
E-103
E-104
E-111B

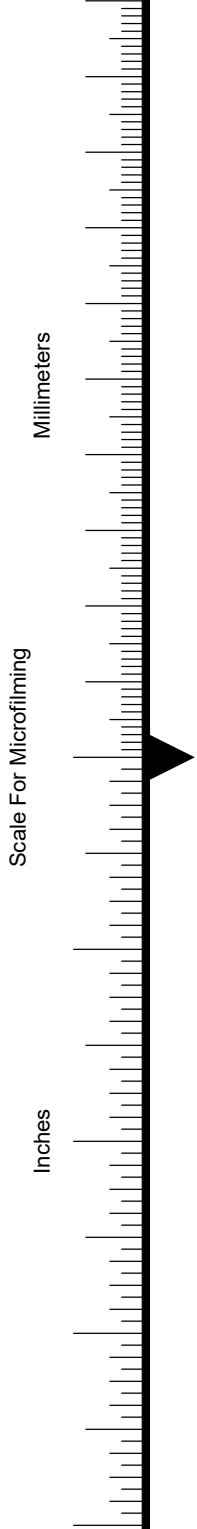

no.	date	by	ckd	description
A	12/21/23	TSR	BAW	ISSUED FOR PERMIT

ISSUED FOR PERMIT
ONLY



9400 WARD PARKWAY
KANSAS CITY, MO 64114
816-333-9400
Burns & McDonnell Engineering Co., Inc.

date	04/24/2023	detailed	S. JESBERG
designed	T. RENSHAW	checked	B. WINTER

PDX FUEL COMPANY L.L.C

PORTLAND INTERNATIONAL AIRPORT
5000 NE MARINE DR.
PORTLAND, OREGON 97218


PDX FACILITY IMPROVEMENTS
DUCTBANK SECTIONS - 5

project	153929	contract	
drawing	E-305	rev.	A

file 153929E-305.dwg

CONDUIT SCHEDULE:

- 2"C: I.PT.MAIN3,
I.DPT.HFS1, I.DPT.HFS2,
I.DPT.HFS3, I.DPT.HFS4,
I.DPT.HFS5, I.DPT.FS6,
I.DPT.CF1, I.DPT.PF1,
I.FE.RCL1, P.FE.RCL1,
NOT USED
- 2"C: I.TT.HP1, I.VT.HP1.1,
I.VT.HP1.2, I.TT.HP2,
I.VT.HP2.1, I.VT.HP2.2,
I.TT.HP3, I.VT.HP3.1,
I.VT.HP3.2, I.TT.HP4,
I.VT.HP4.1, I.VT.HP4.2,
I.TT.HP5, I.VT.HP5.1,
I.VT.HP5.2
- 3"C: C.ME.HFS1,
C.FSTS.HP1, C.ME.HFS2,
C.FSTS.HP2, C.ME.HFS3,
C.FSTS.HP3, C.ME.HFS4,
C.FSTS.HP4, C.ME.HFS5,
C.FSTS.HP5
- 3/4"C: C.EFSO.PPA,
C.EFSO.T3EX,
C.EFSO.T12EX
- 3"C: C.JY.HP1, C.JY.HP2,
C.JY.HP3, C.JY.HP4,
C.JY.HP5, C.JY.RCL1,
C.JY.RCL2
- 2"C: I.FE.HP1, I.FE.HP2,
I.FE.HP3, I.FE.HP4,
I.FE.HP5, I.PT.MAIN1,
I.PT.MAIN2
- 4"C: P.VFD1.HP1
C.MWTS.HP1,
C.HTR.HP1
- 4"C: P.VFD2.HP2
C.MWTS.HP2,
C.HTR.HP2
- 4"C: P.VFD3.HP3
C.MWTS.HP3,
C.HTR.HP3
- 4"C: P.VFD4.HP4
C.MWTS.HP4,
C.HTR.HP4
- 4"C: P.VFD5.HP5
C.MWTS.HP5,
C.HTR.HP5
- 1"C: C.AE.FS6
- NOT USED
- 1"C: P.PNL5.1, P.PNL5.2,
P.PNL5.7, P.PNL6.8
- 1"C: P.PNL5.8, P.PNL5.13,
P.PNL5.14
- 3"C: C.MOV1A.CTL,
C.EFSO.MOV1A,
C.MOV1B.CTL,
C.EFSO.MOV1B,
C.MOV2A.CTL,
C.EFSO.MOV2A,
C.MOV2B.CTL,
C.EFSO.MOV2B,
C.MOV3A.CTL,
C.EFSO.MOV3A,
C.MOV3B.CTL,
C.EFSO.MOV3B
- 2"C: C.HS.TP2.1, C.FS.TP2,
C.JY.TP2
- 2"C: P.MCC1.TP2,
C.HTR.TP2, C.MWTS.TP2
- 3/4"C: C.EFSO.T3EX,
C.EFSO.T12EX
- 3/4"C: IC.FSC.WTG
- 2"C: C.TANK1.CTLP,
C.TANK2.CTLP,
C.TANK3.CTLP,
C.LSHH.T1, C.LSHH.T2,
C.LSHH.T3
- 1"C: P.PNL5.1, P.PNL5.2,
P.PNL5.7
- 1"C: P.PNL6.8
- 2"C: CATHODIC
PROTECTION
- 3/4"C: C.LSH.SS3
- 3/4"C: IS.TLS.HCARBON
- 3/4"C: C.LSH.OWS.O,
C.LSH.OWS.L,
C.YP14.PERMISSIVE,
C.CSP.OWS
- 3/4"C: C.LSH.OWS.O,
C.LSH.OWS.L,
C.YP14.PERMISSIVE
- 3/4"C: C.CSP.OWS
- 3/4"C: IS.SUMPLS.START
- 3/4"C: IS.SUMPLS.STOP

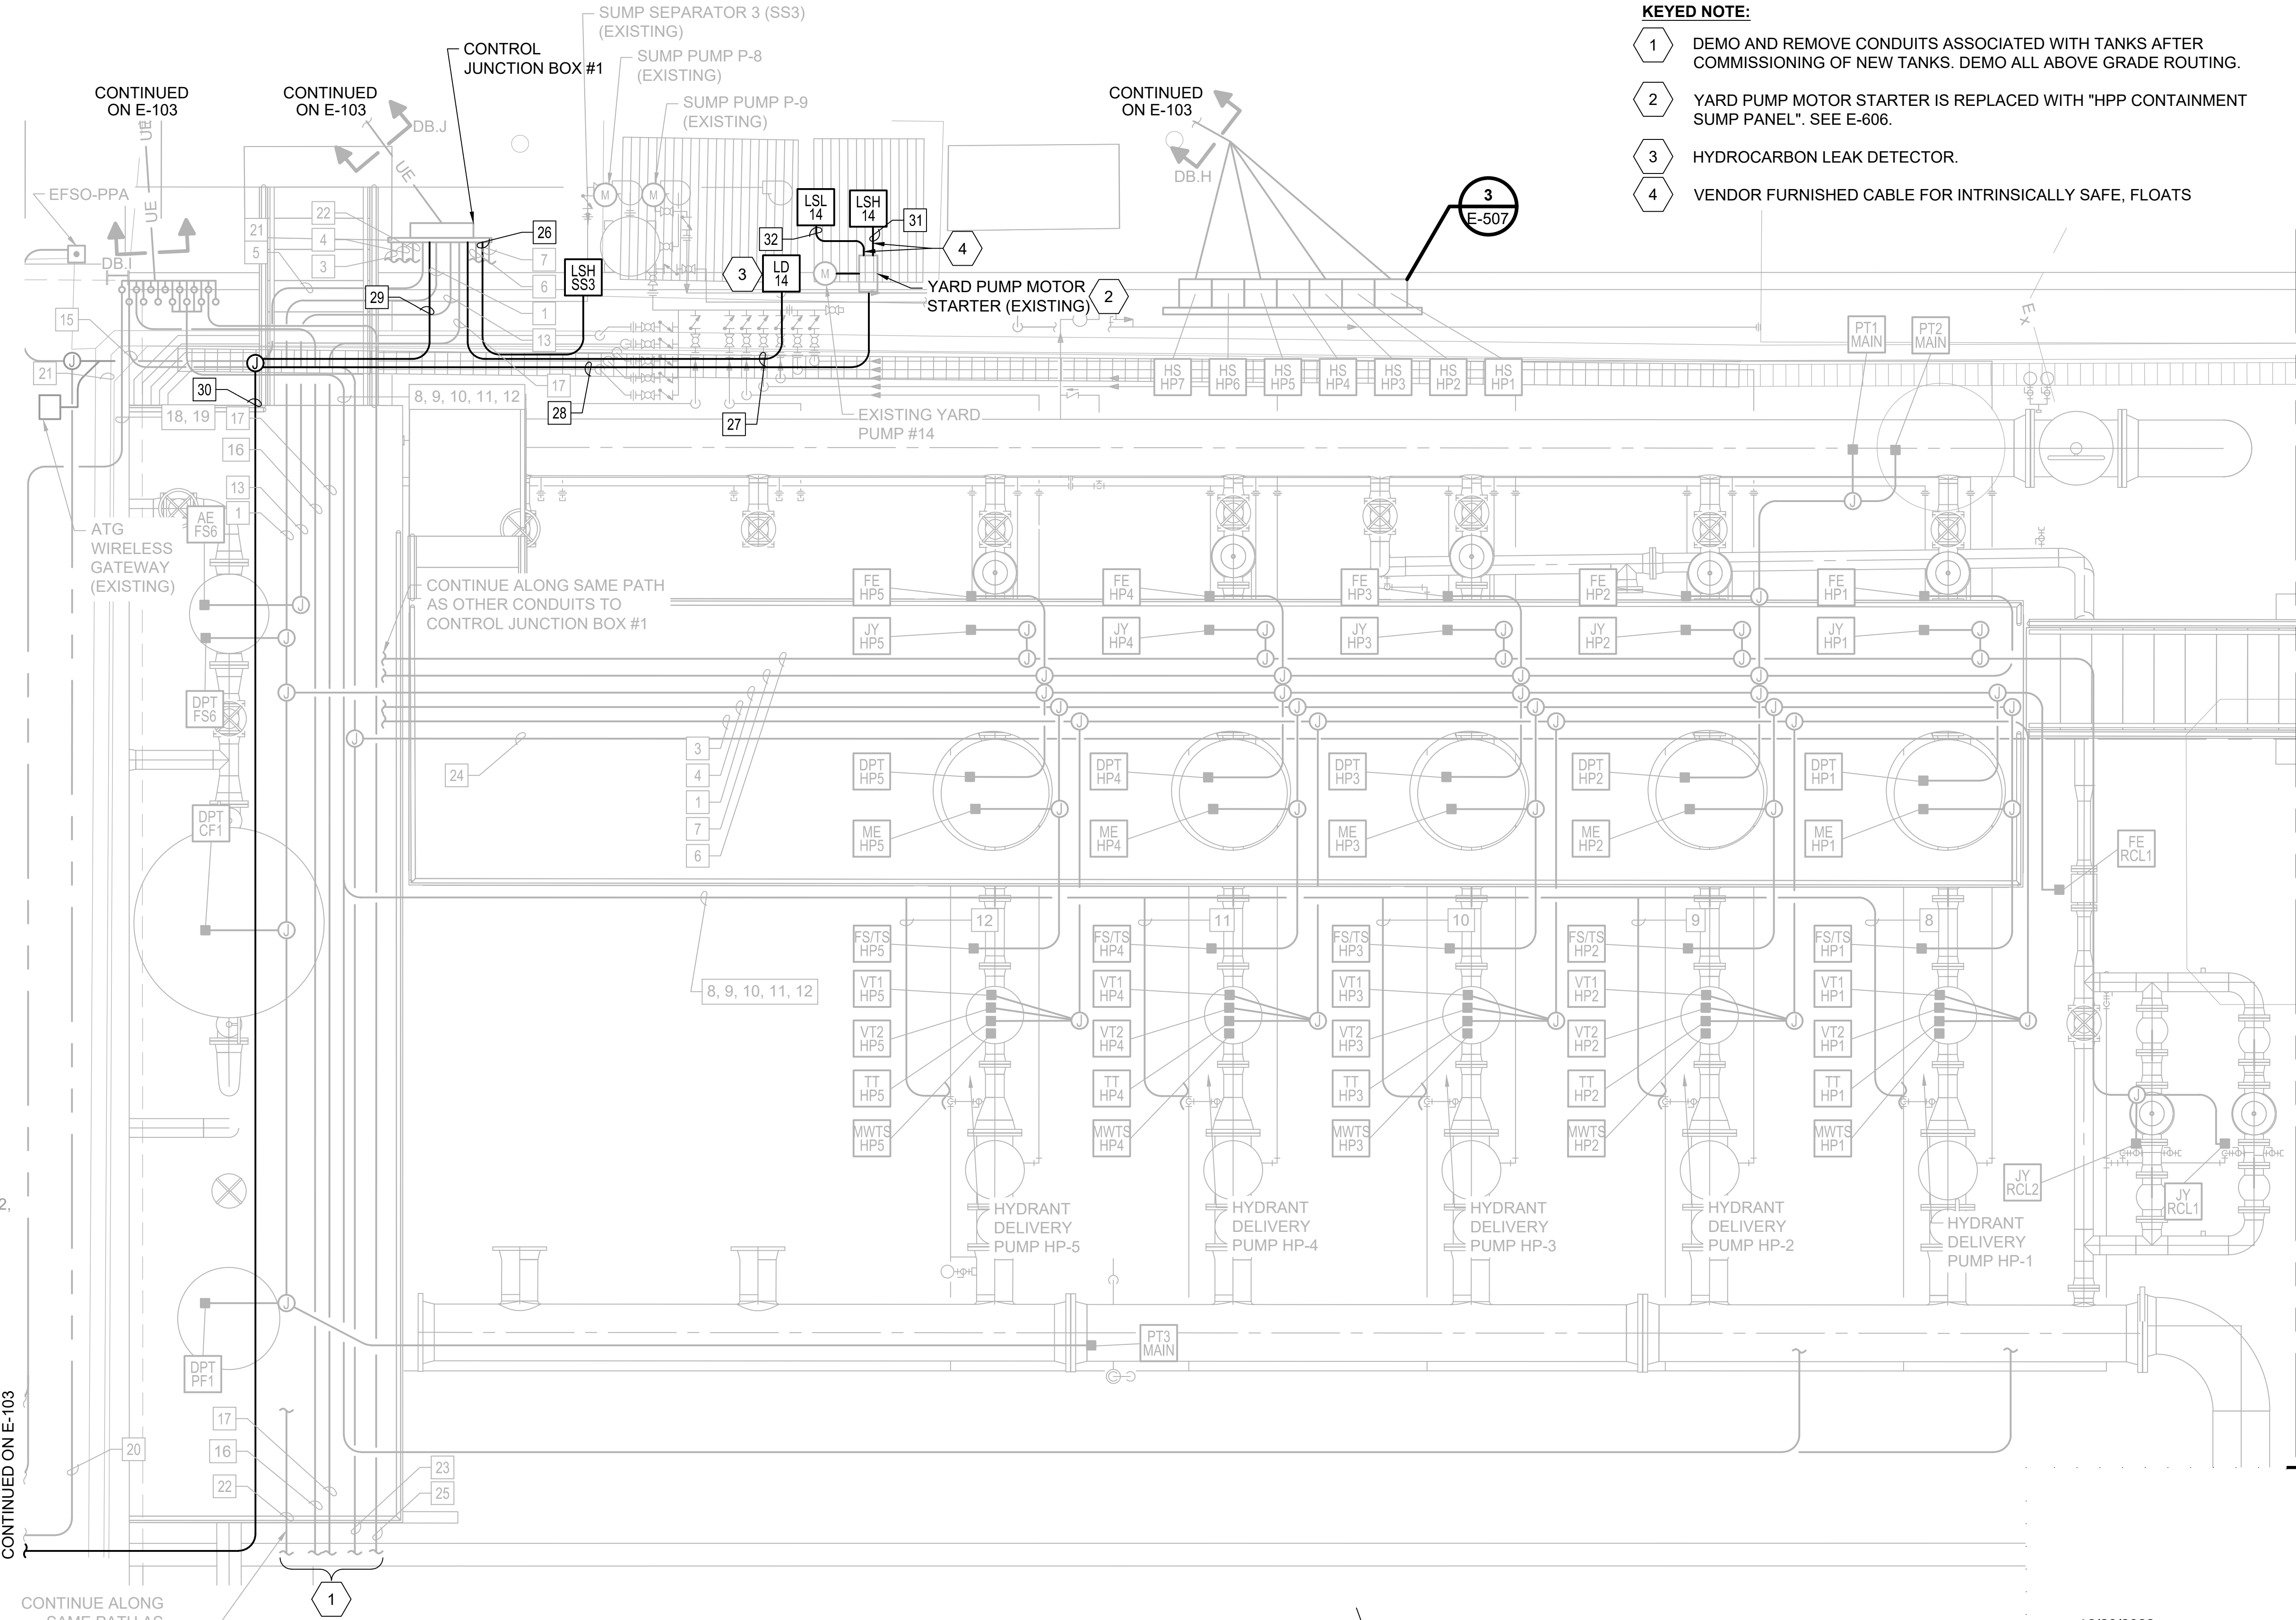

NOTE:

- SEE SHEET E-001 FOR GENERAL NOTES, LEGEND AND ABBREVIATIONS.

KEYED NOTE:

- DEMO AND REMOVE CONDUITS ASSOCIATED WITH TANKS AFTER COMMISSIONING OF NEW TANKS. DEMO ALL ABOVE GRADE ROUTING.
- YARD PUMP MOTOR STARTER IS REPLACED WITH "HPP CONTAINMENT SUMP PANEL". SEE E-606.
- HYDROCARBON LEAK DETECTOR.
- VENDOR FURNISHED CABLE FOR INTRINSICALLY SAFE, FLOATS

no.	date	by	ckd	description
A	12/21/23	TSR	BAW	ISSUED FOR PERMIT

ISSUED FOR PERMIT
ONLY



9400 WARD PARKWAY
KANSAS CITY, MO 64114
816-333-9400
Burns & McDonnell Engineering Co., Inc.

date	04/24/2023	detailed	S. JESBERG
designed	T. RENSHAW	checked	B. WINTER

PDX FUEL COMPANY L.L.C

PORTLAND INTERNATIONAL AIRPORT
5000 NE MARINE DR.
PORTLAND, OREGON 97218

PDX FACILITY IMPROVEMENTS
ENLARGED PLAN - 2

project	153929	contract	
drawing	E-402	rev.	A


file 153929E-402.dwg

ENLARGED PLAN

ENLARGED PLAN - 2



1
E-103

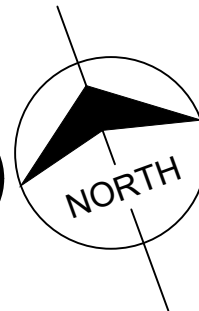




NOTES:

1. SEE SHEET E-001 FOR GENERAL NOTES, LEGEND AND ABBREVIATIONS.
2. CONDUIT ROUTING IS SCHEMATIC IN NATURE.
3. SEE SHEETS E-301 - E-305 FOR DUCTBANK SECTIONS.
4. INSTRUMENT CALLOUTS ARE APPROXIMATE. REFER TO MECHANICAL DRAWINGS FOR EXACT INSTRUMENT LOCATIONS.

CONDUIT SCHEDULE:


1. 2-1/2"C: P.MCC1.OP1, C.HTR.OP1, C.MWTS.OP1
2. 3/4"C: C.FS.OP1
3. 1-1/2"C: P.MCC1.OP1
4. 3/4"C: C.HS.OP1
5. 1-1/2"C: C.MS.RFS1, C.MSRFS2, C.LSH.SS4
6. 3/4"C: P.FIT.OP1, I.FIT.OP1
7. 3/4"C: C.EFSO.OP2
8. 2-1/2"C: P.MCC1.OP2, C.HTR.OP2, C.MWTS.OP2
9. 3/4"C: C.FS.OP2
10. 1"C: P.PNL6.34
11. 3/4"C: C.HS.OP2
12. 1"C: P.FIT.OP2, I.FIT.OP2
13. NOT USED
14. 1-1/2"C: C.FSC.HCTSAP
15. 3/4"C: C.EFSO.HCTS
16. 3/4"C: P.LP1.11
17. 1-1/2"C: C.MS.RFS1, C.MSRFS2
18. NOT USED
19. NOT USED
20. NOT USED
21. 1"C: C.MWTS.OP2, C.HTR.OP2
22. 2-1/2"C: P.VFDTP1.TP1, C.HTR.TP1, C.MWTS.TP1, C.FSTS.TP1, C.HS.HCTS
23. 3/4"C: I.PT.TP1
24. 2"C: I.LT.RCT
25. 3/4"C: C.LSHH.RCT
26. 1-1/2"C: P.MCC1.OP2
27. 3/4"C: C.MS.RFS1
28. 3/4"C: JY.RFS1
29. 3/4"C: C.MS.RFS2
30. 3/4"C: C.JY.RFS2
31. 3"C: P.VFDTP1.TP1, C.HTR.TP1, C.MWTS.TP1, C.FSTS.TP1, C.HS.HCTS
32. 2-1/2"C: P.VFDTP1.TP1, C.HTR.TP1, C.MWTS.TP1
33. 3/4"C: P.PNL5.25
34. NOT USED
35. 1-1/2"C: C.FS.OP2, C.HS.OP2
36. 1"C: P.FIT.HCTS, I.FIT.HCTS
37. 3/4"C: I.DPIT.RFS1, I.DPIT.RFS2
38. NOT USED
39. 1-1/2"C: C.FS.OP1, C.HS.OP1
40. 3/4"C: C.LSH.SS4
41. 1"C: C.MWTS.OP1, C.HTR.OP1
42. 3/4"C: IS.TLS.LD.RCT
43. 1-1/2"C: I.FIT.OP2, P.FIT.OP2, P.FIT.HCTS, I.FIT.HCTS, I.DPIT.RFS1, I.DPIT.RFS2
44. 3/4"C: I.PT.TP1, I.TT.TP1, I.VTX.TP1, I.VTY.TP1
45. 1"C: P.FIT.HCTS, I.FIT.HCTS, I.DPIT.RFS1, I.DPIT.RFS2

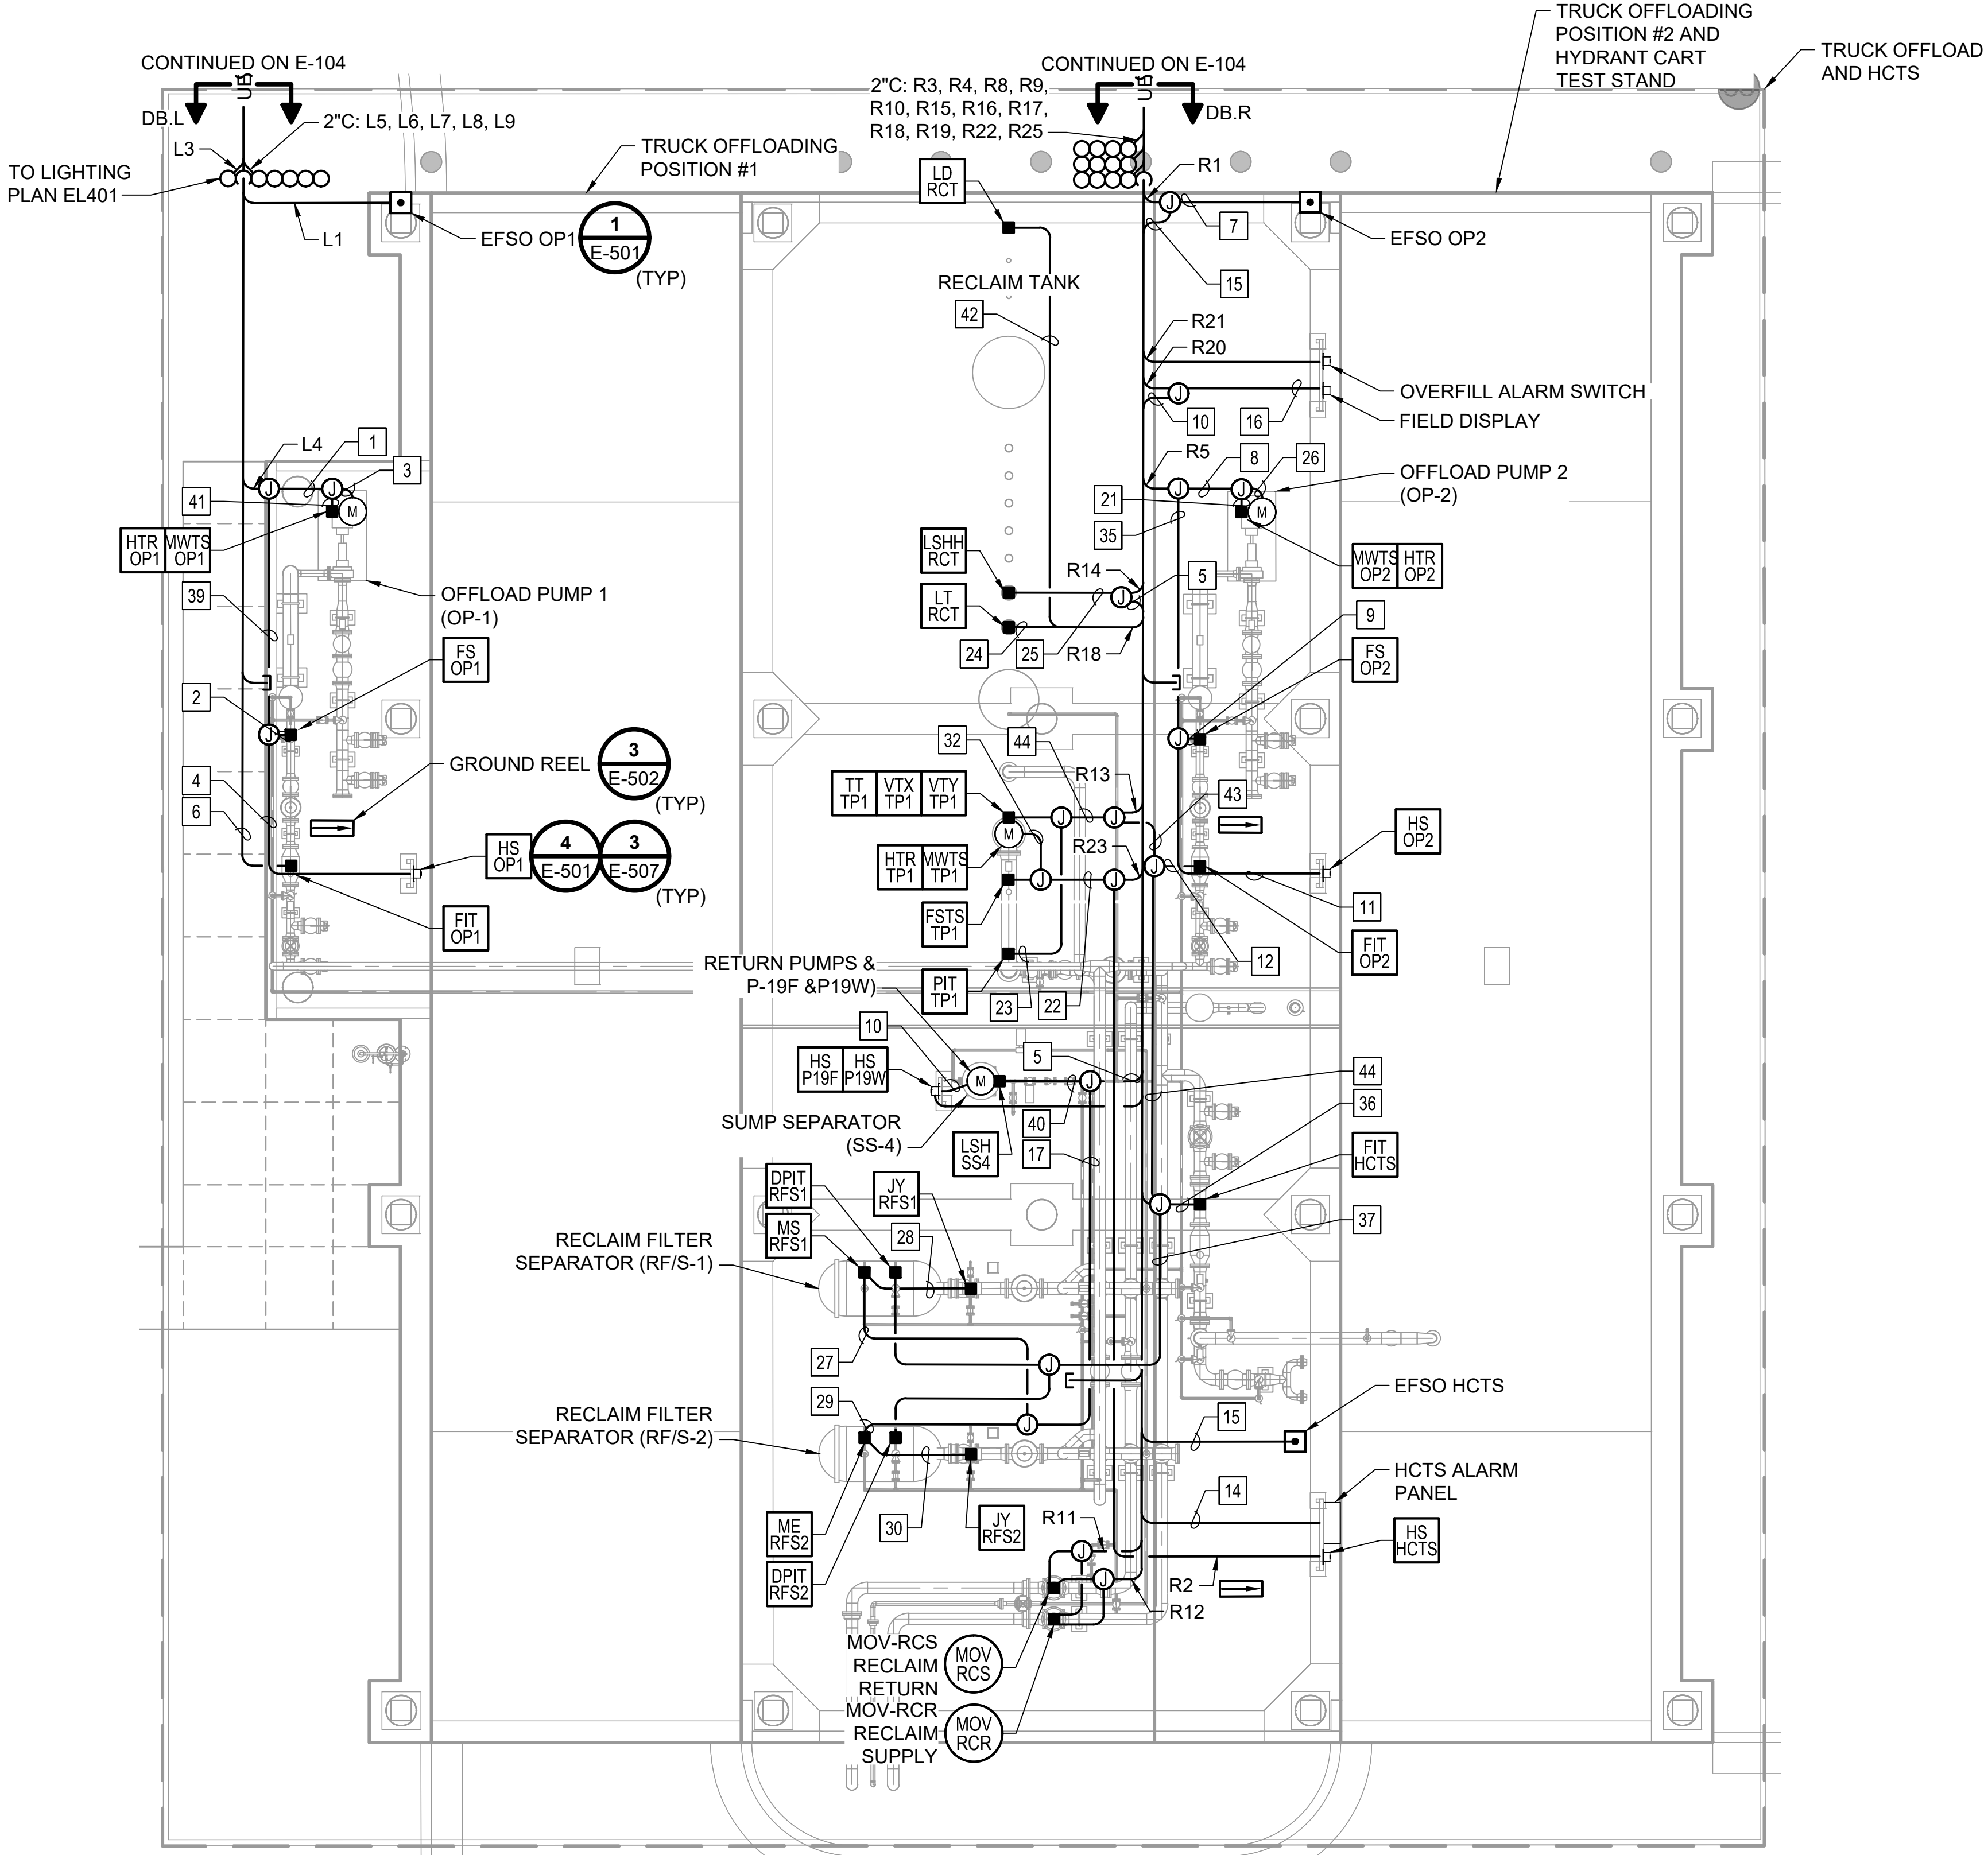

ENLARGED PLAN

ENLARGED PLAN - 5

0 4' 8' 12'
SCALE IN FEET

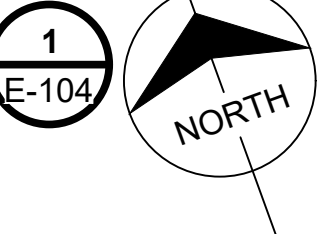

12/20/2023

ISSUED FOR PERMIT ONLY

BURNS MEDONNELL

9400 WARD PARKWAY
KANSAS CITY, MO 64114
816-333-9400
Burns & McDonnell Engineering Co., Inc.

date	04/24/2023	detailed	S. JESBERG
designed	T. RENSHAW	checked	B. WINTER

PDX FUEL COMPANY L.L.C

PORTLAND INTERNATIONAL AIRPORT
5000 NE MARINE DR.
PORTLAND, OREGON 97218


PDX FACILITY IMPROVEMENTS
ENLARGED PLAN - 5

project	153929	contract	
drawing	E-405	rev.	A

file 153929E-405.dwg

NOTE:

1. SEE SHEET E-001 FOR GENERAL NOTES, LEGEND AND ABBREVIATIONS.
2. LIGHTNING PROTECTION SYSTEM FOR THE CANOPY AND OPERATIONS BUILDING SHALL BE PER NFPA 780, UL 96, UL 96A AND SPECIFICATION 26 41 13.

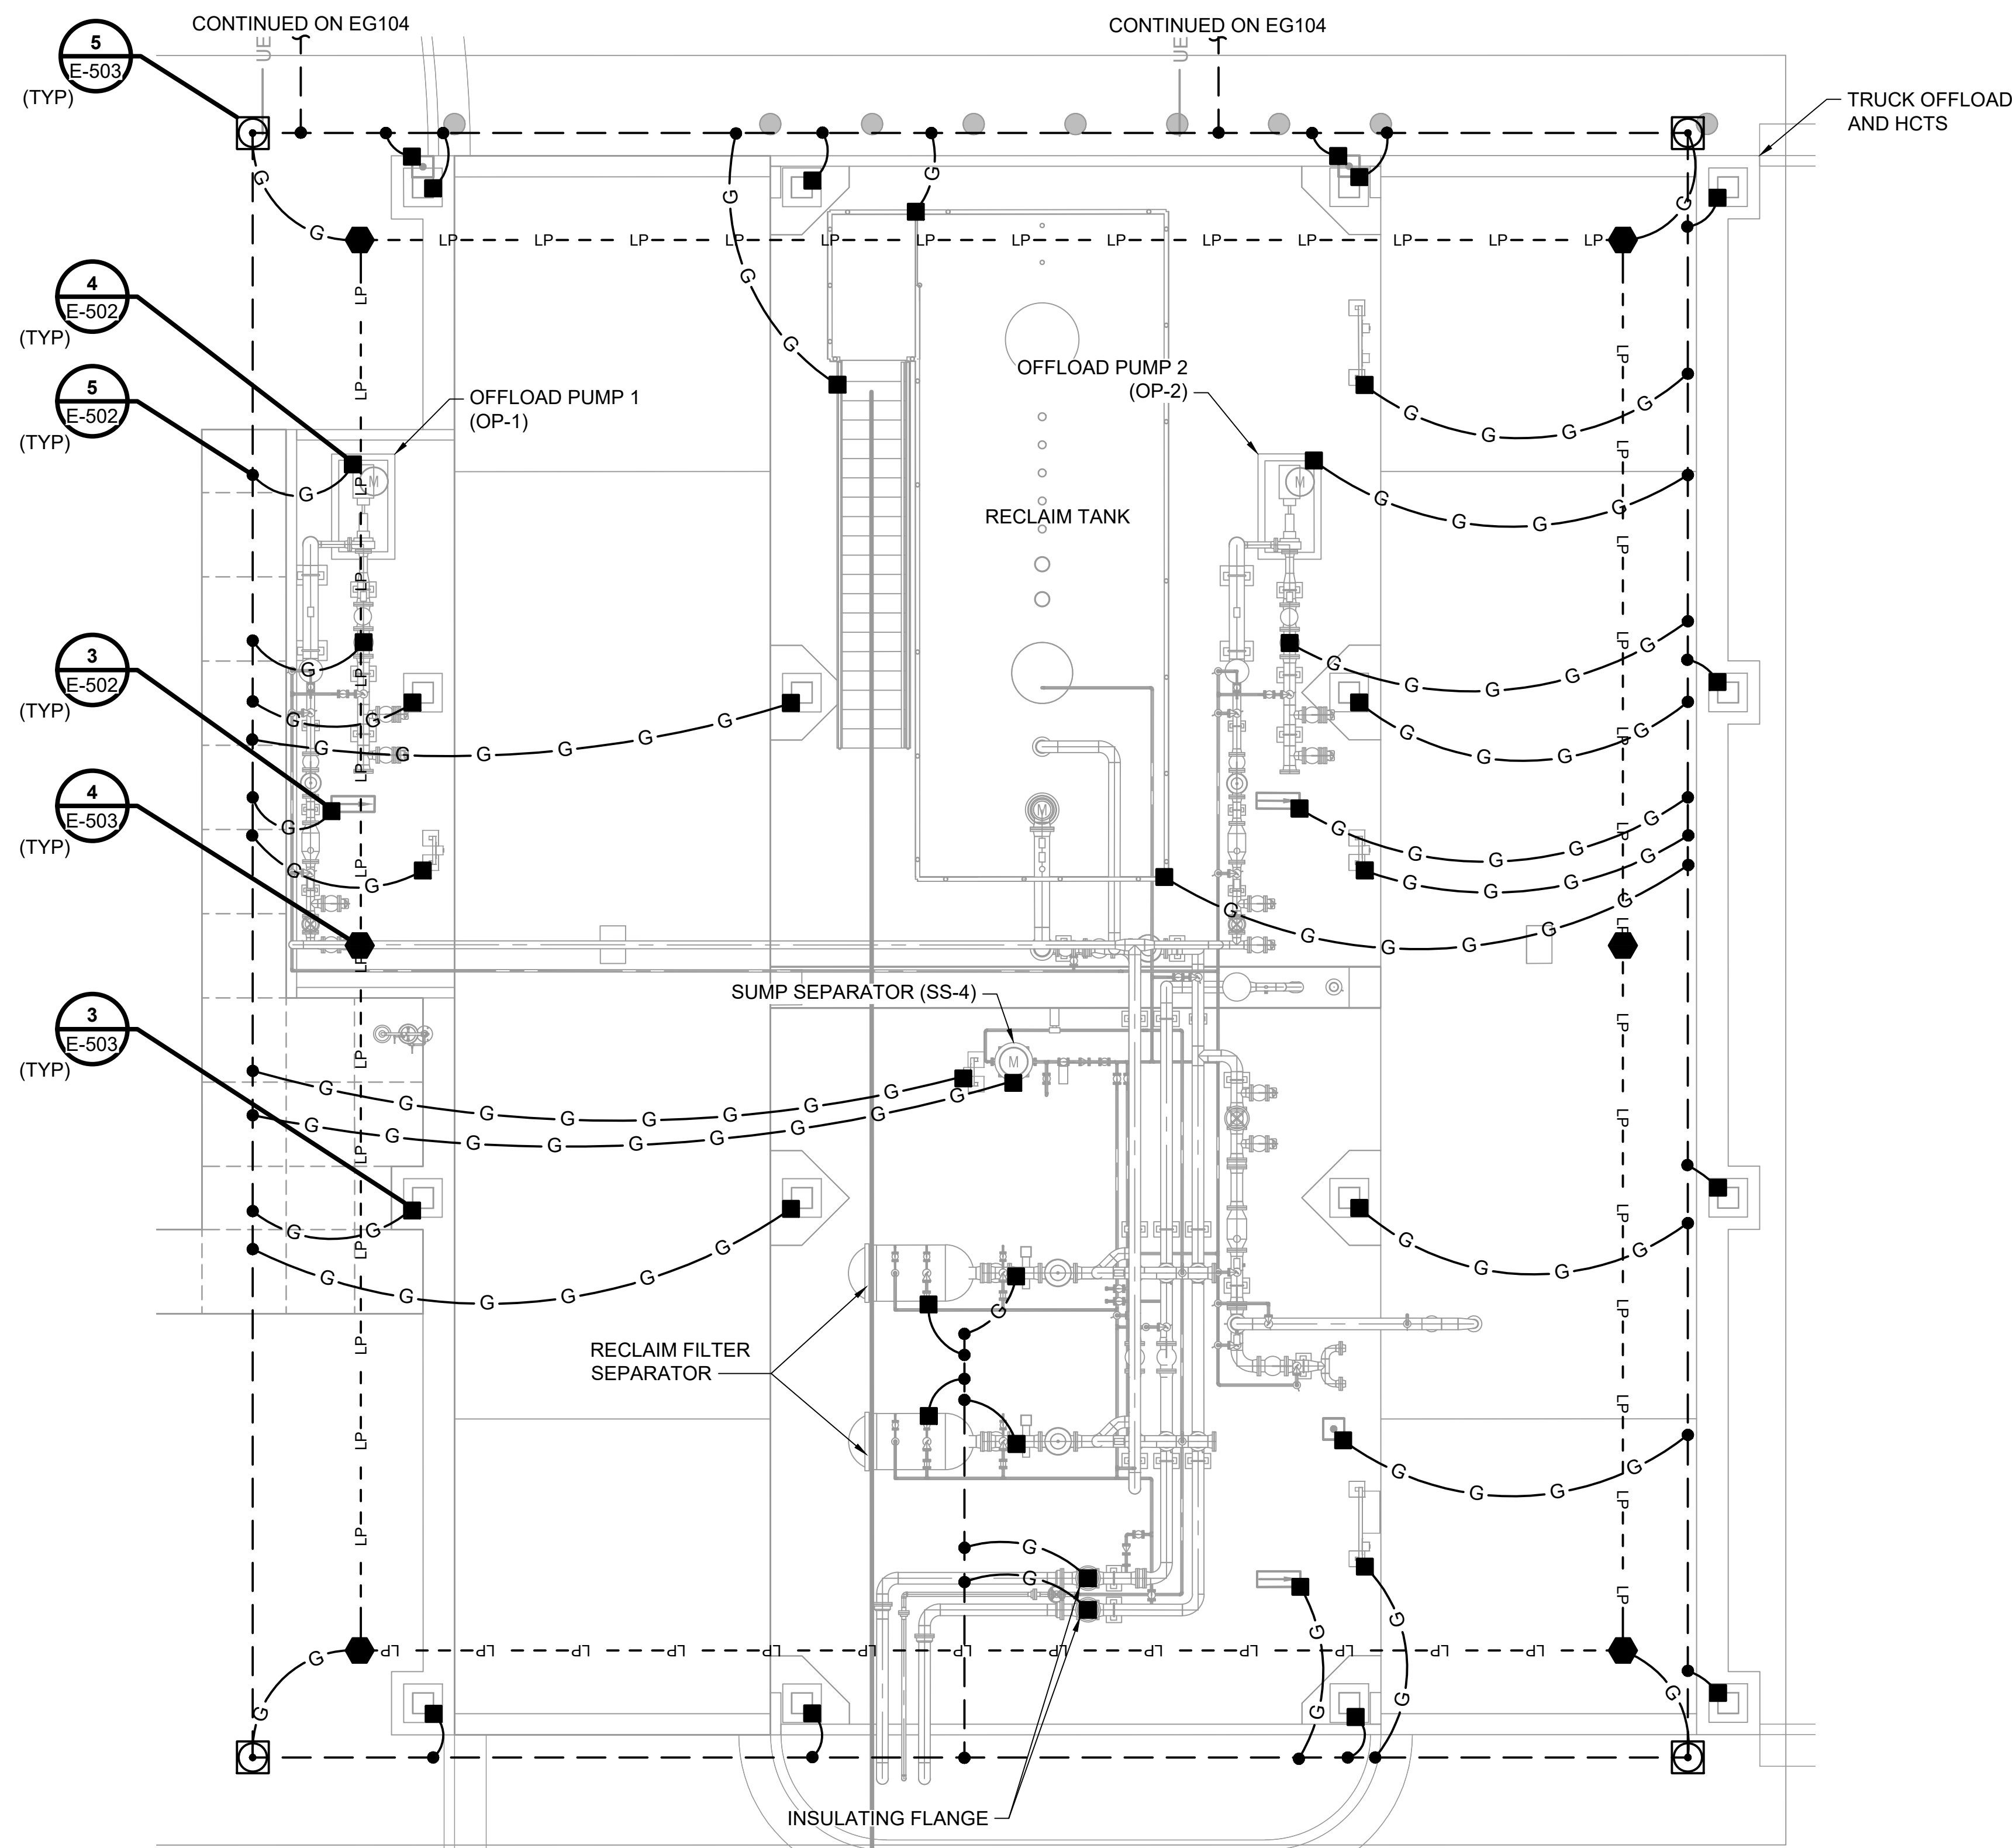

ENLARGED PLAN

**ENLARGED GROUNDING
PLAN - OFFLOAD & HCTS**

A horizontal scale bar with alternating black and white segments. It is marked with the numbers 0, 4', 8', and 12' at regular intervals. Below the bar, the text "SCALE IN FEET" is centered.

1
EG104

no.	date	by	ckd	description
A	12/21/23	TSR	BAW	ISSUED FOR PERMIT

**ISSUED FOR PERMIT
ONLY**



9400 WARD PARKWAY
KANSAS CITY, MO 64114
816-333-9400
Burns & McDonnell Engineering Co., Inc.

date 04/24/2023	detailed S. JESBERG
designed T. RENSHAW	checked B. WINTER

PDX FUEL COMPANY L.L.C


PORTLAND INTERNATIONAL AIRPORT
5000 NE MARINE DR.
PORTLAND, OREGON 97218

PDX FACILITY IMPROVEMENTS
ENLARGED GROUNDING PLAN - OFFLOAD &
HCTS

project	contract
153929	
drawing	rev.


file 153929EG401.dwg

NOTE:
1. SEE SHEET E-001 FOR GENERAL NOTES, LEGEND AND ABBREVIATIONS.

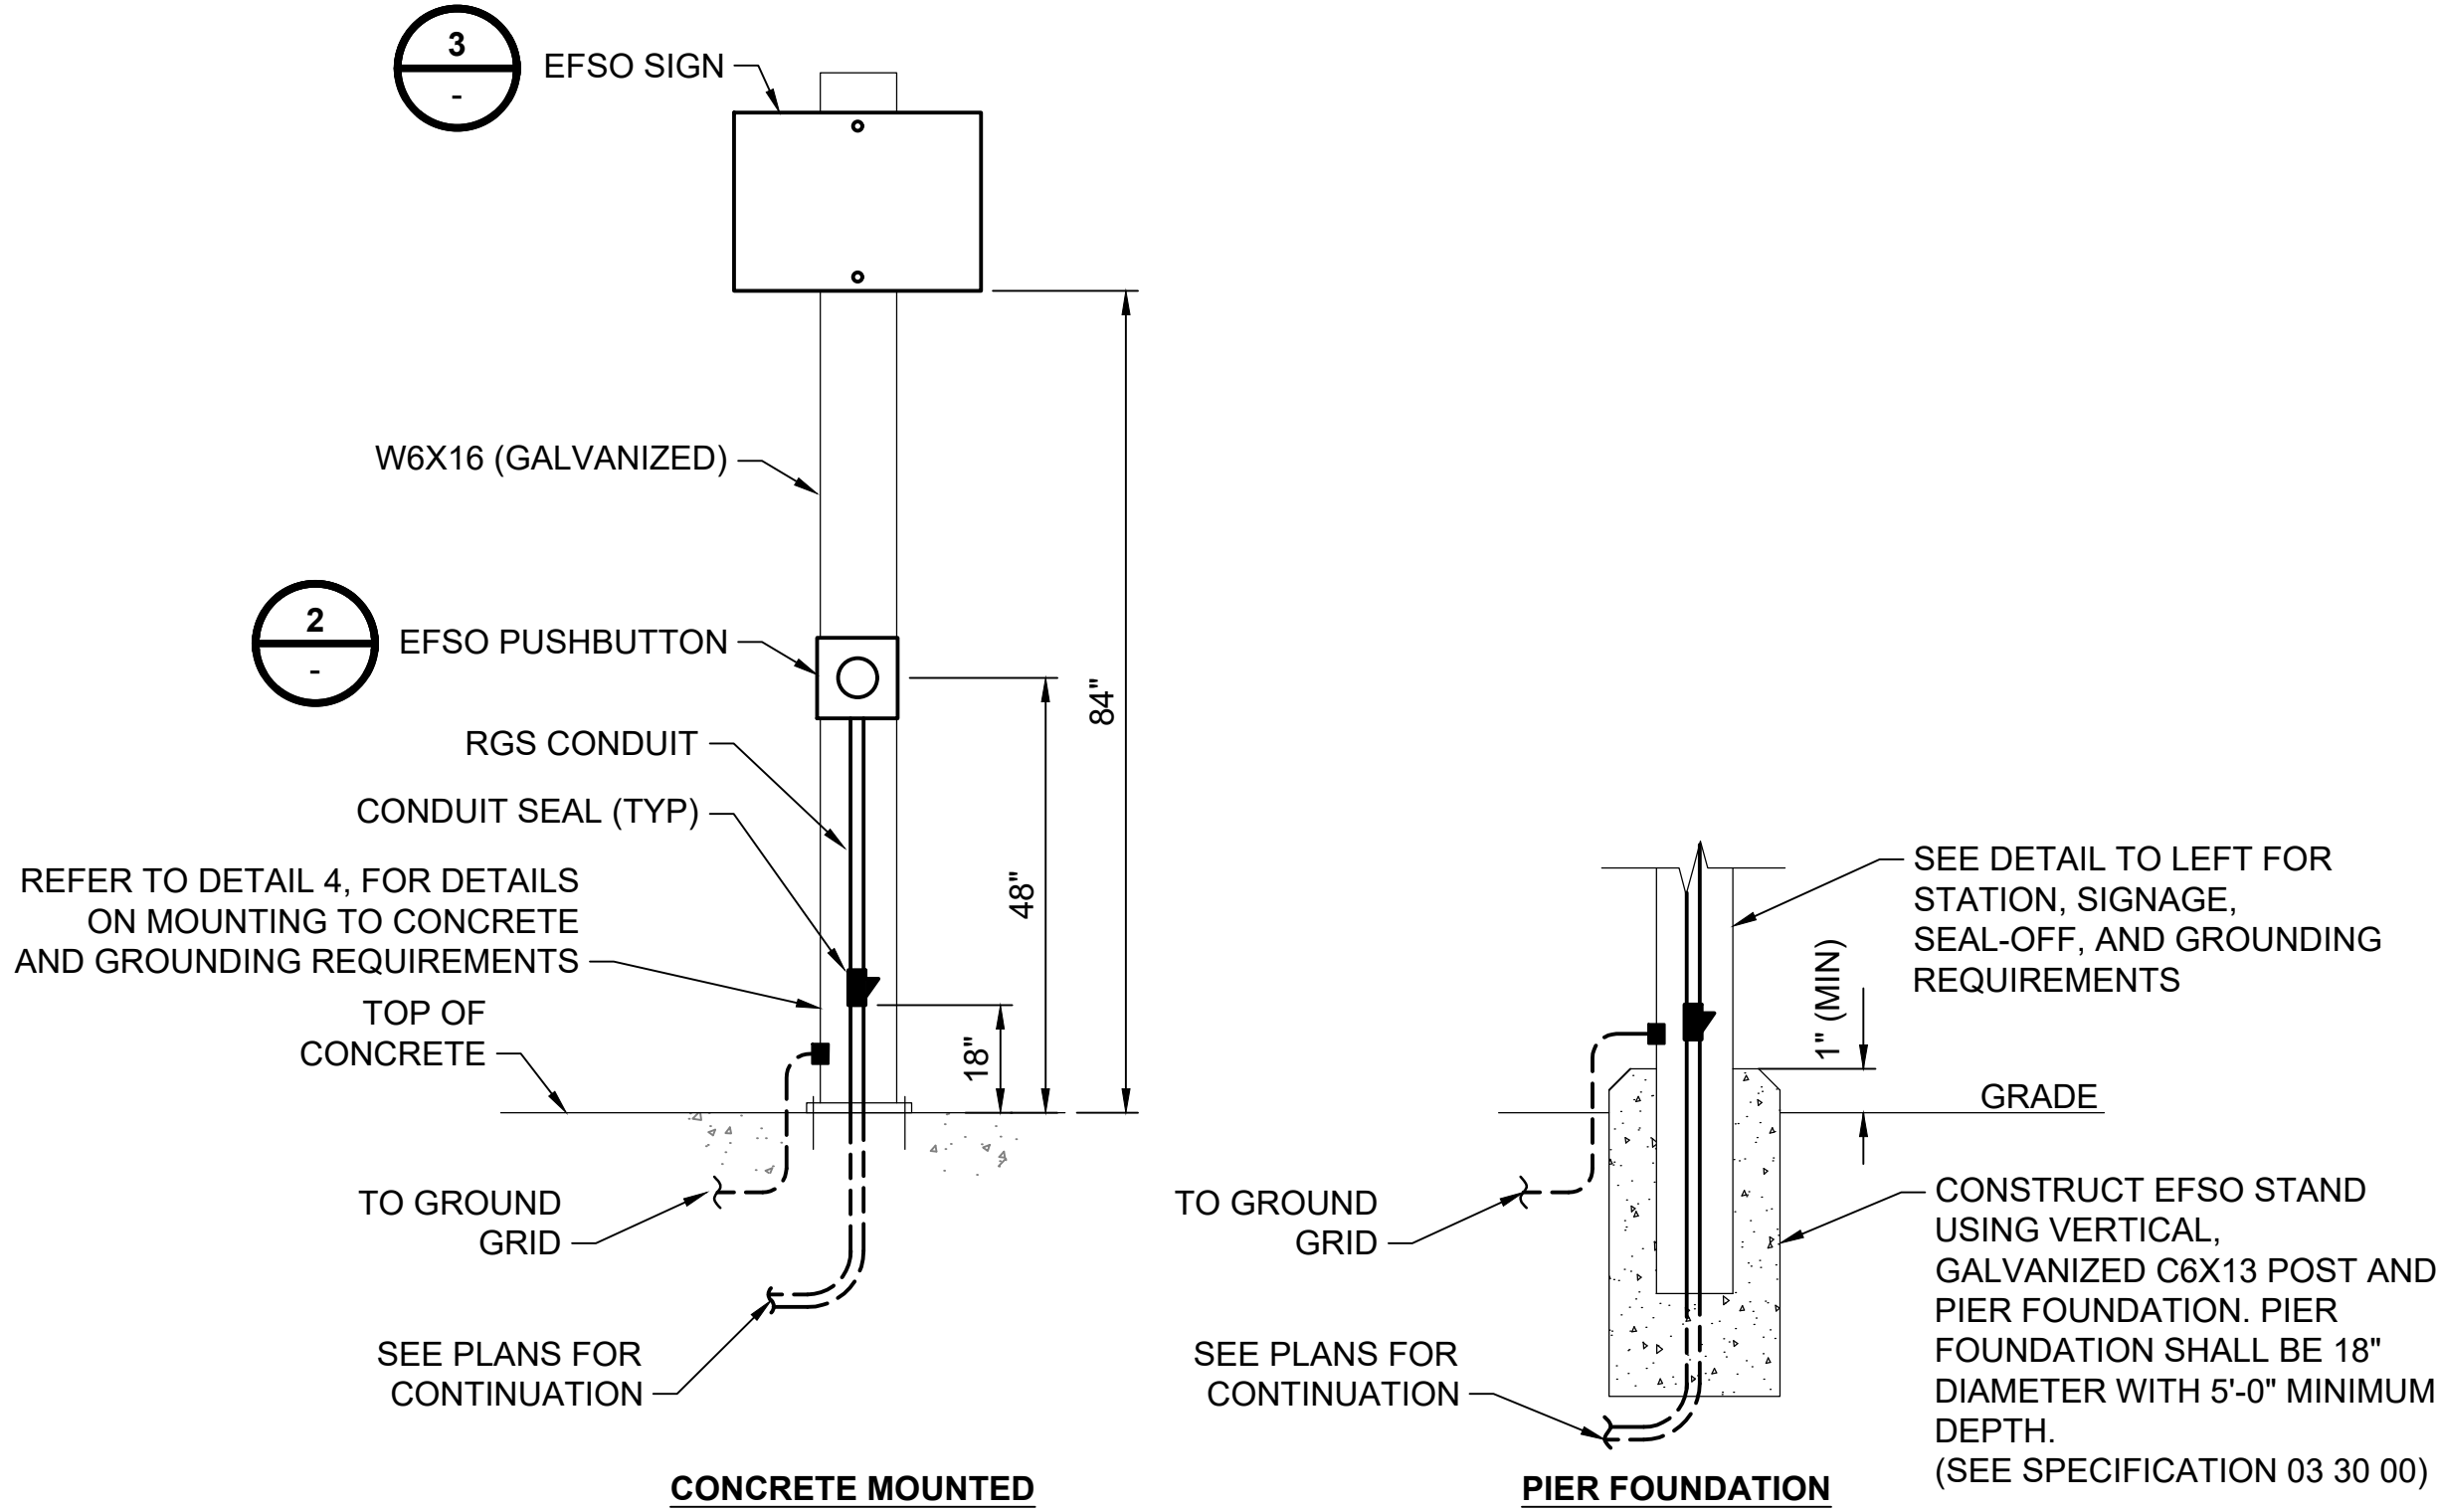


- NOTES:
1. MOUNTING TO CONCRETE (SEE LEFT DETAIL)
2. PIER FOUNDATION IN NON-PAVED AREA (SEE RIGHT DETAIL).

DETAIL
EMERGENCY FUEL SHUTOFF STATION
NOT TO SCALE

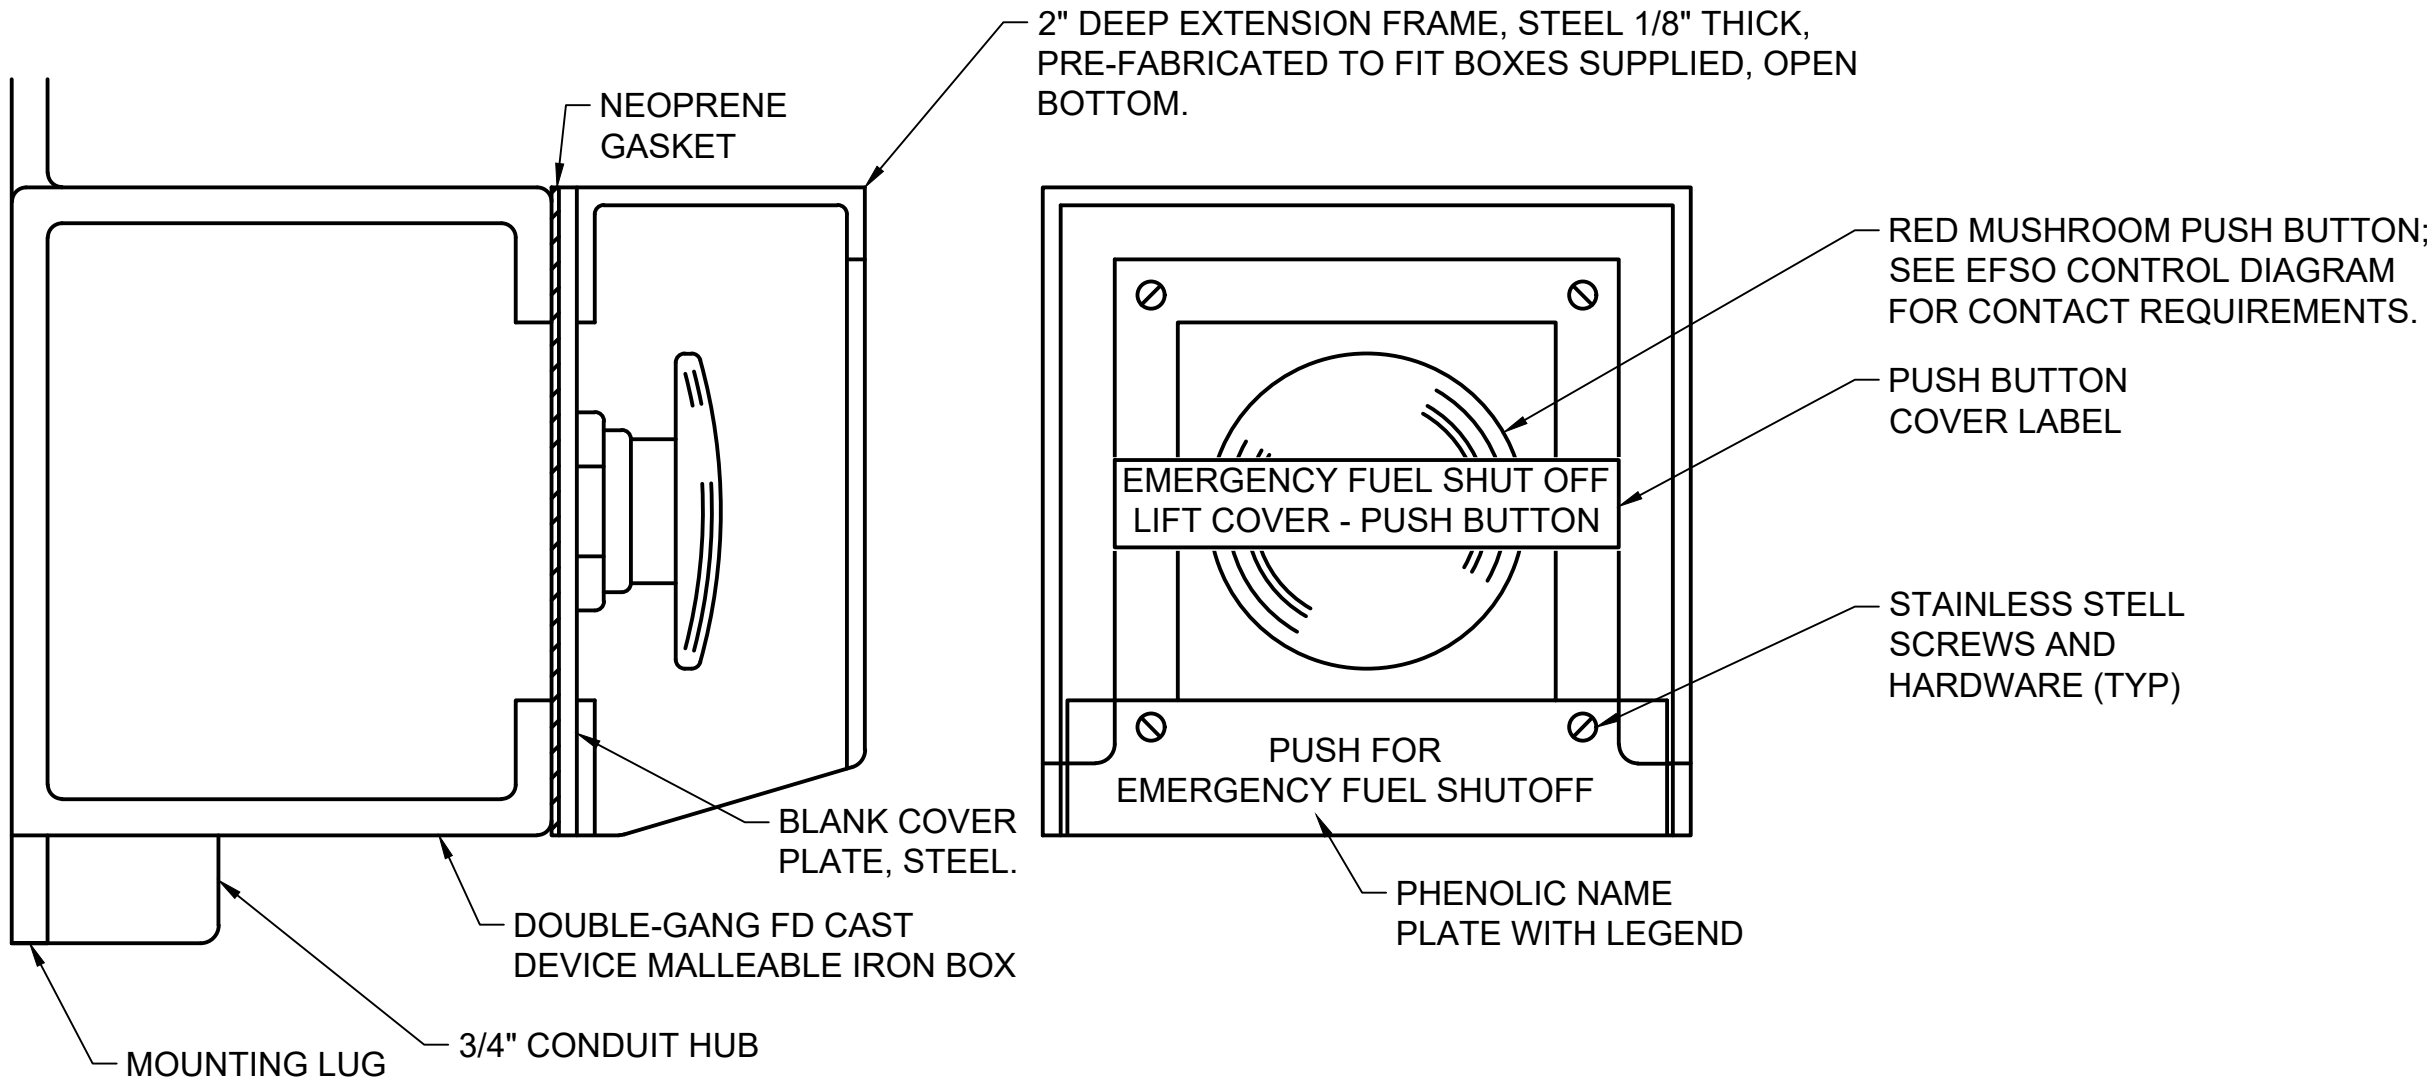


DETAIL
EMERGENCY FUEL SHUTOFF PUSHBUTTON
NOT TO SCALE

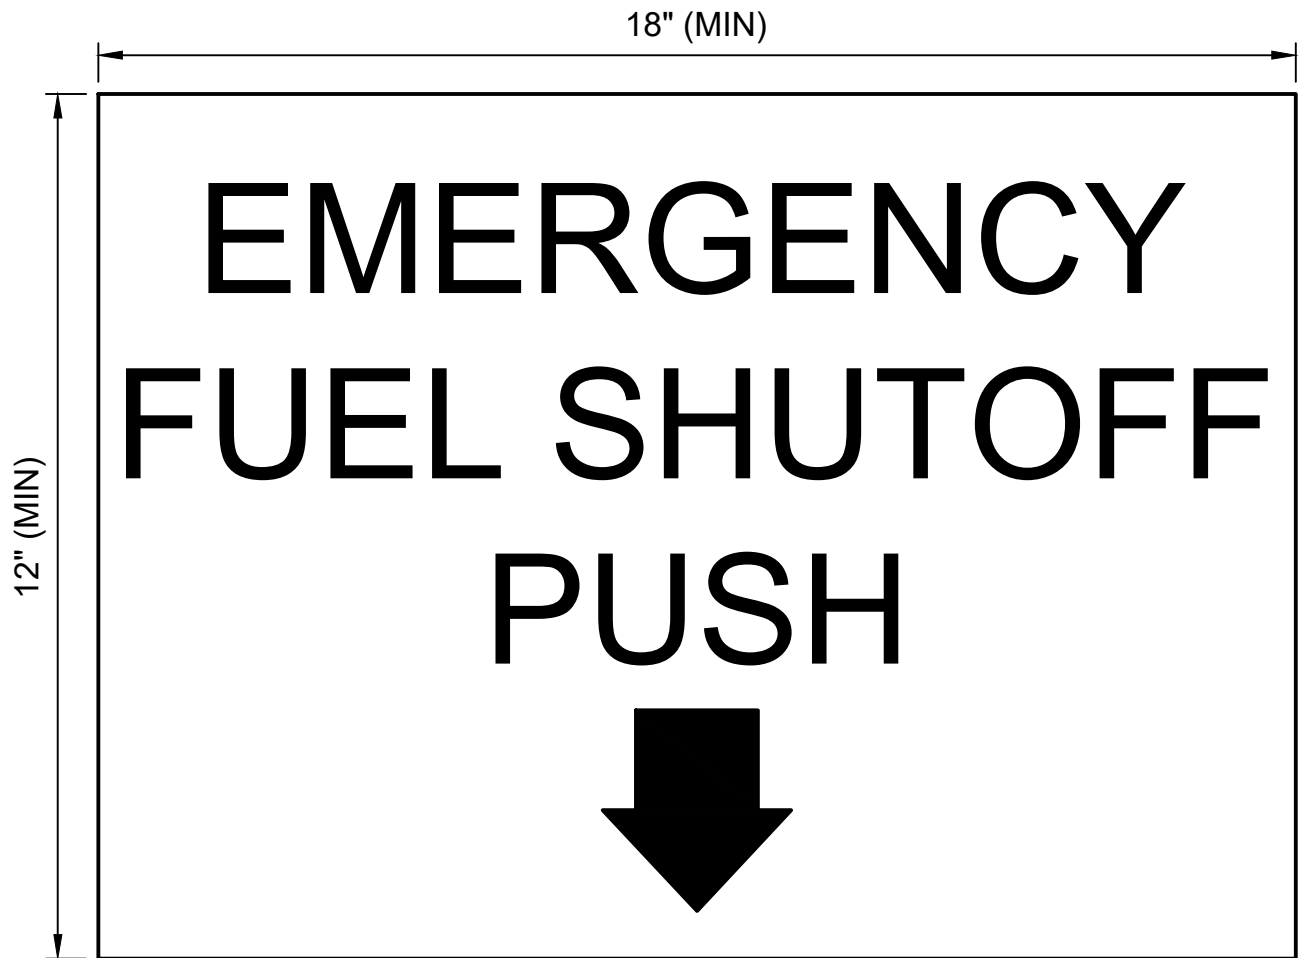


- NOTES:
1. SIGN TO BE REFLECTIVE ALUMINUM, 1/16\"/>

DETAIL
EMERGENCY FUEL SHUTOFF SIGN
NOT TO SCALE

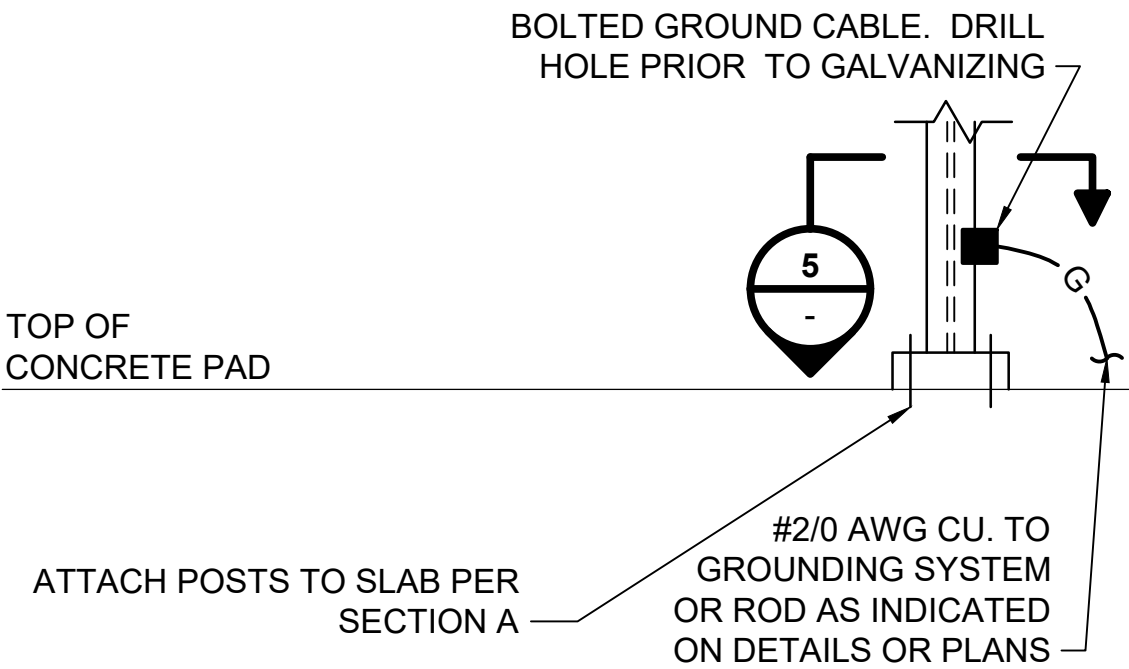

DETAIL
TYPICAL CONCRETE PAD FOUNDATION
NOT TO SCALE

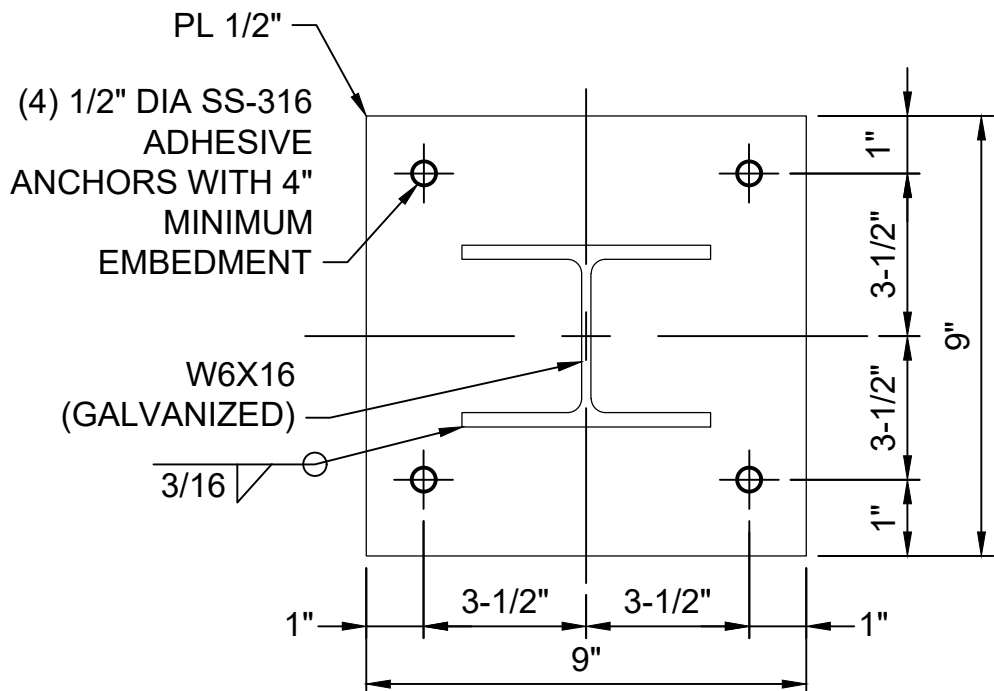

SECTION
EQUIPMENT BASE PLATE
NOT TO SCALE

no.	date	by	ckd	description
A	12/21/23	TSR	BAW	ISSUED FOR PERMIT

ISSUED FOR PERMIT ONLY

**BURNS
MCDONNELL**

9400 WARD PARKWAY
KANSAS CITY, MO 64114
816-333-9400
Burns & McDonnell Engineering Co., Inc.

date	04/24/2023	detailed	S. JESBERG
designed	T. RENSHAW	checked	B. WINTER



PDX FUEL COMPANY L.L.C

PORTLAND INTERNATIONAL AIRPORT
5000 NE MARINE DR.
PORTLAND, OREGON 97218

PDX FACILITY IMPROVEMENTS
ELECTRICAL DETAILS - 1

project	153929	contract	
drawing	E-501	rev.	A

file 153929E-501.dwg

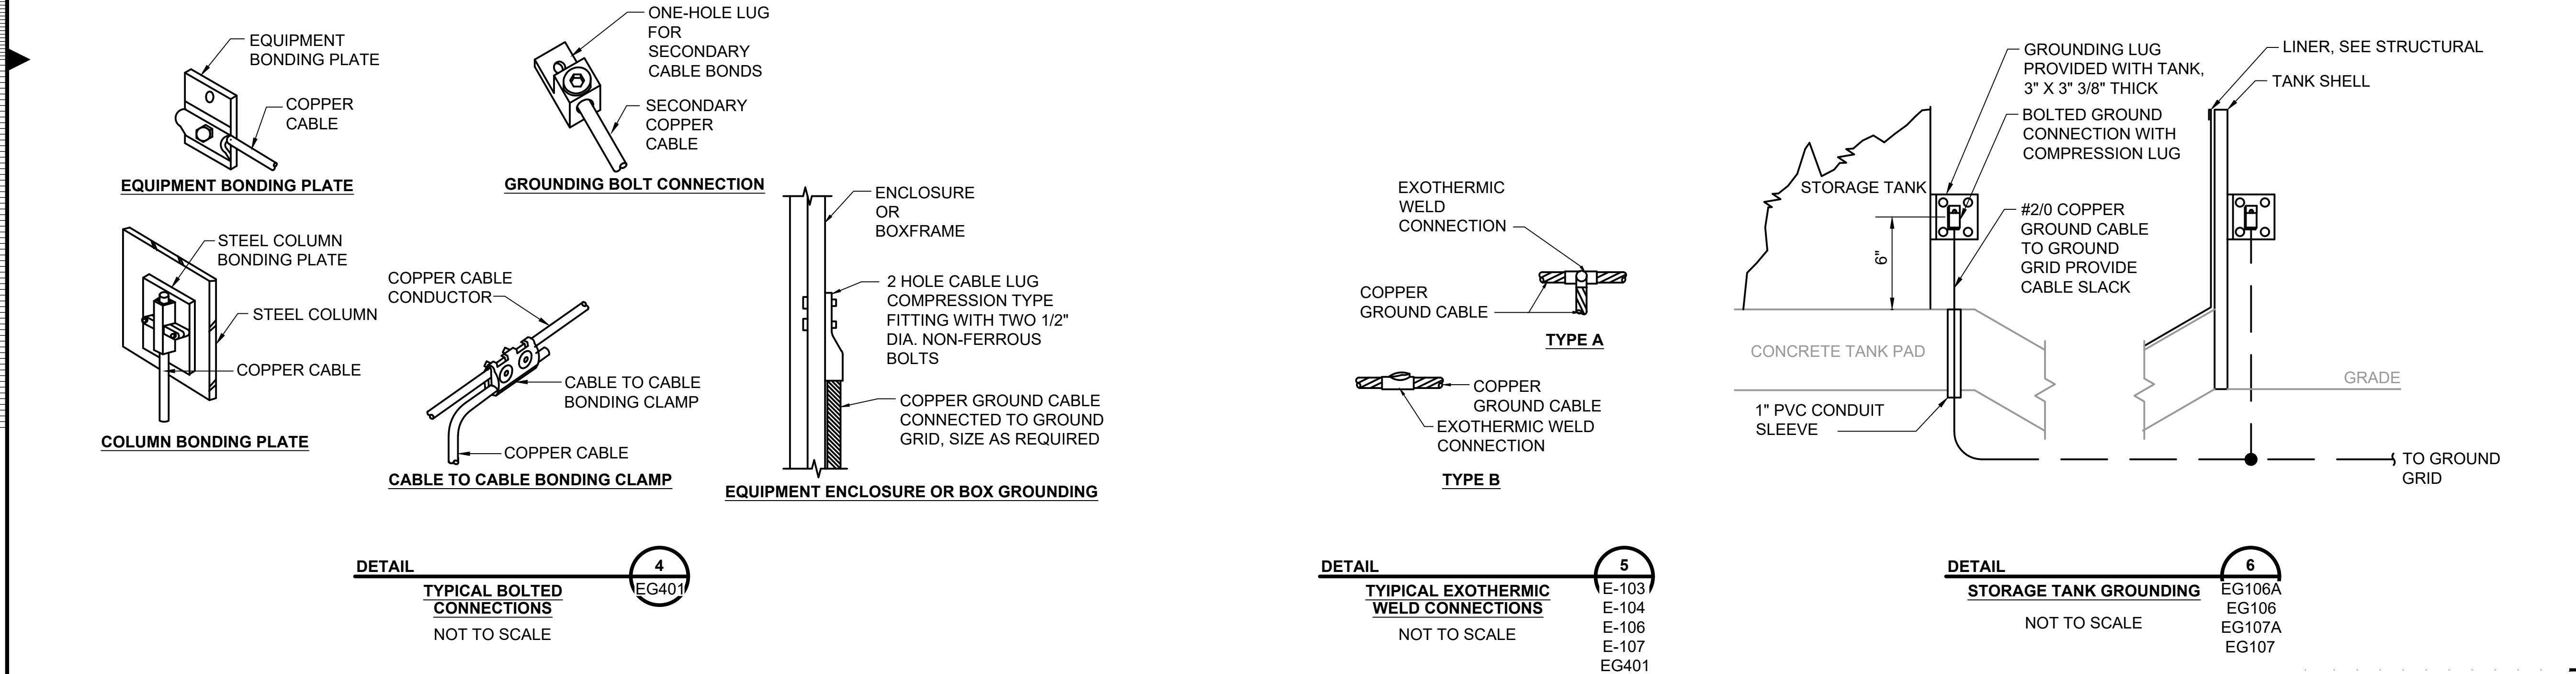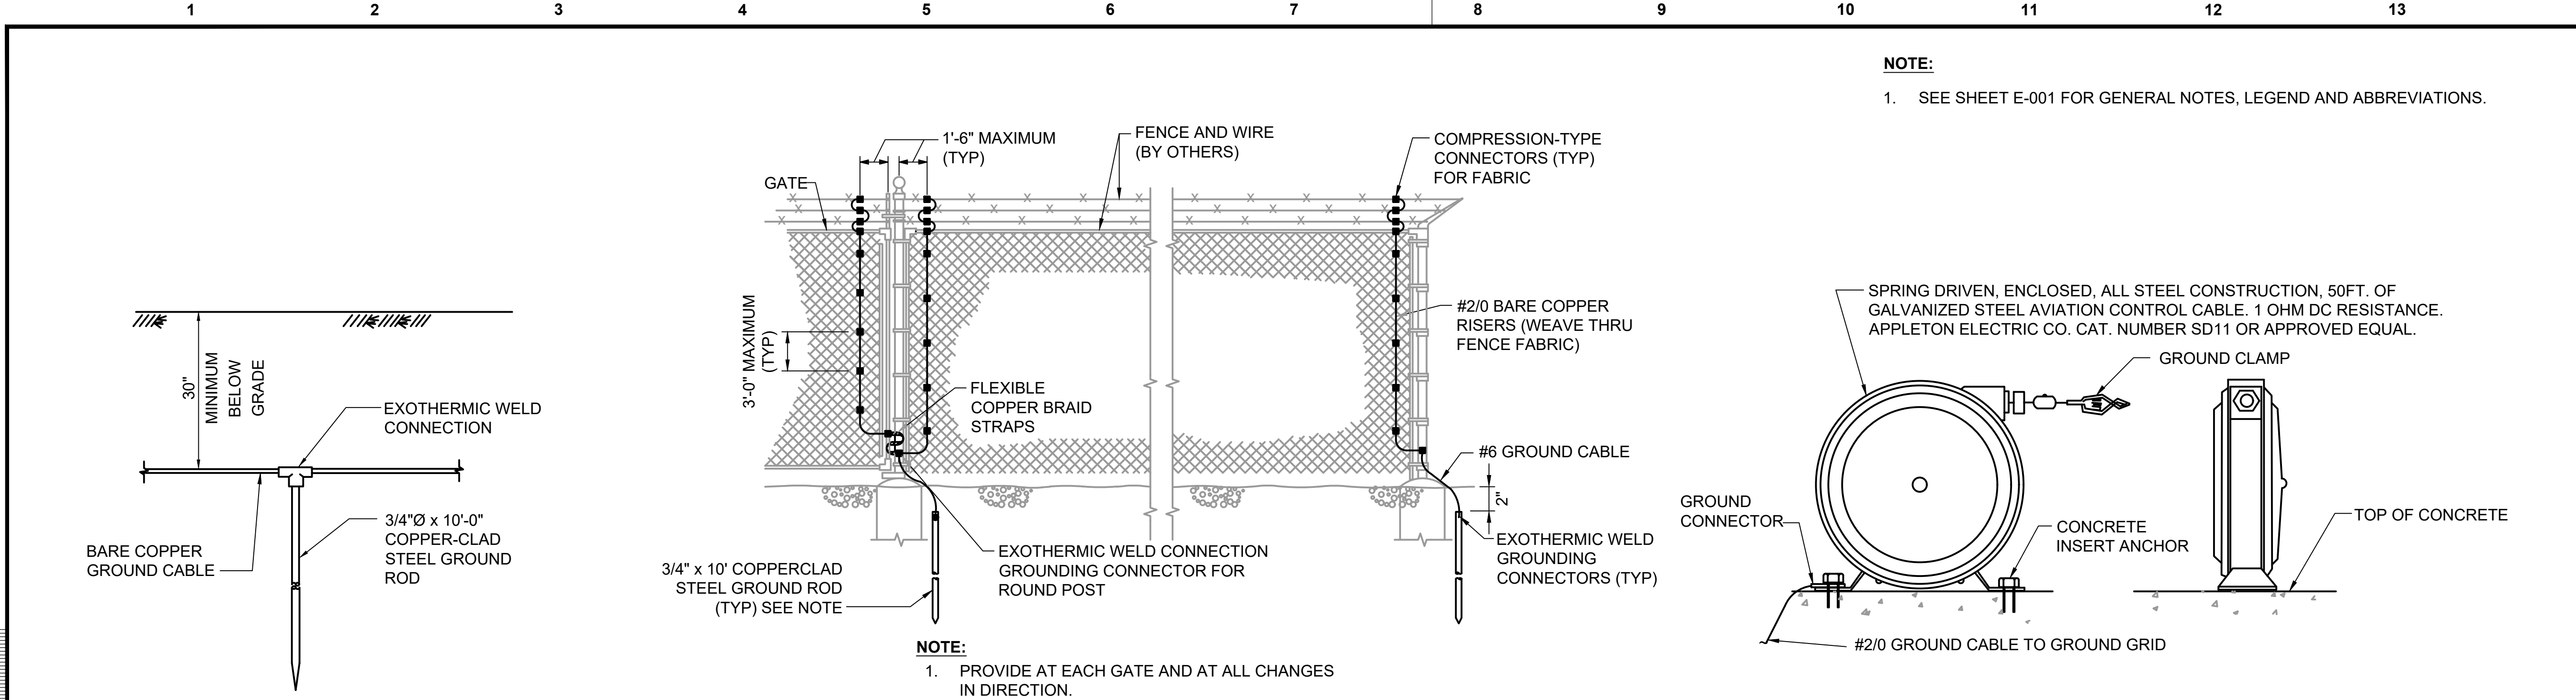

no.	date	by	ckd	description
A	12/21/23	TSR	BAW	ISSUED FOR PERMIT

ISSUED FOR PERMIT ONLY



9400 WARD PARKWAY
KANSAS CITY, MO 64114
816-333-9400
Burns & McDonnell Engineering Co., Inc.

date	04/24/2023	detailed	S. JESBERG
designed	T. RENSHAW	checked	B. WINTER

PDX FUEL COMPANY L.L.C


PORTLAND INTERNATIONAL AIRPORT
5000 NE MARINE DR.
PORTLAND, OREGON 97218

PDX FACILITY IMPROVEMENTS
ELECTRICAL DETAILS - 2

project	153929	contract	
drawing	E-502	rev.	A


file 153929E-502.dwg

NOTES:
1. SEE SHEET E-001 FOR GENERAL NOTES, LEGEND AND ABBREVIATIONS.

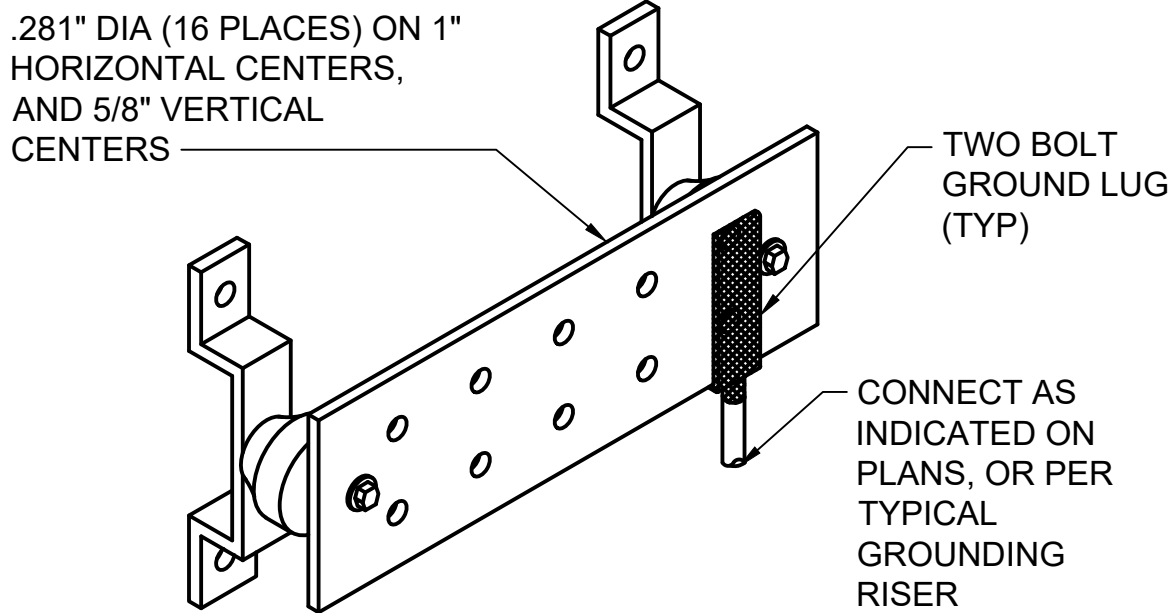


NOTE:
1. TIN PLATED COPPER GROUND BAR WITH WALL MOUNTING BRACKETS AND INSULATORS. DIMENSIONS: 1/4" THICK, 2" HIGH, 10" LENGTH, MOUNT 24" AFF (UON).

DETAIL
GROUNDING BAR DETAIL
NOT TO SCALE

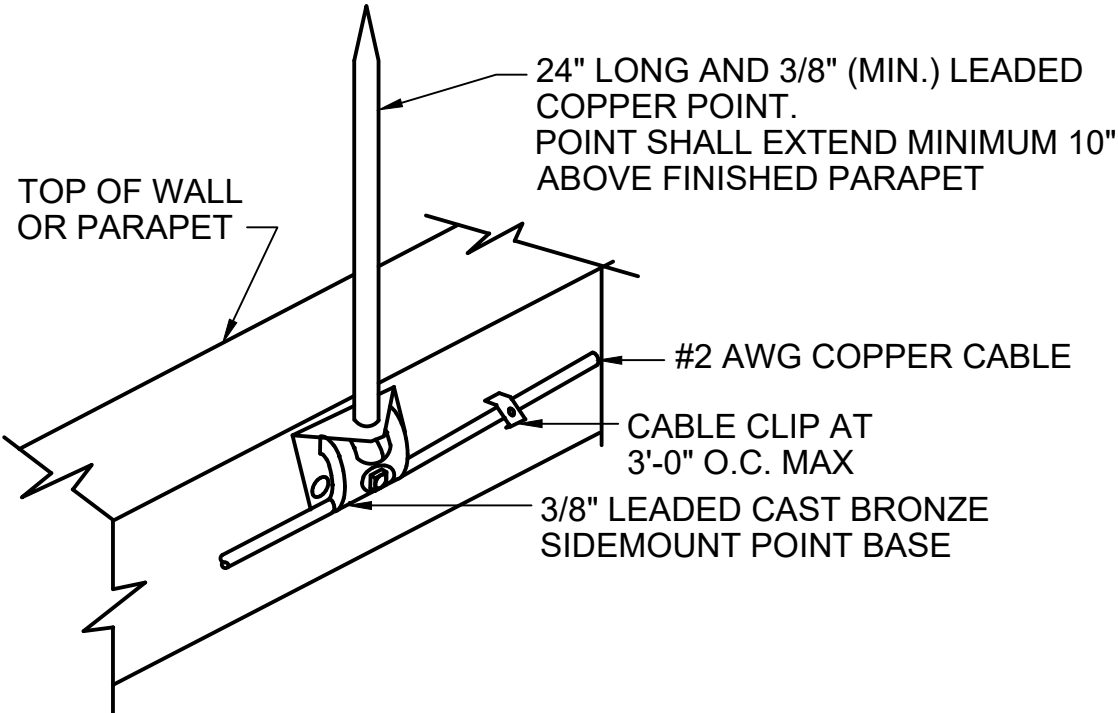


NOTE:
1. AIR TERMINAL TIP SHALL NOT BE LESS THAN 10" ABOVE THE OBJECT/AREA IT IS TO PROTECT. ANY AIR TERMINAL EXCEEDING 24" IN HEIGHT SHALL BE SUPPORTED AT A POINT NOT LESS THAN HALF ITS HEIGHT. ALL MOUNTING HARDWARE SHALL BE STAINLESS STEEL.

DETAIL
SIDE MOUNT AIR TERMINAL
NOT TO SCALE

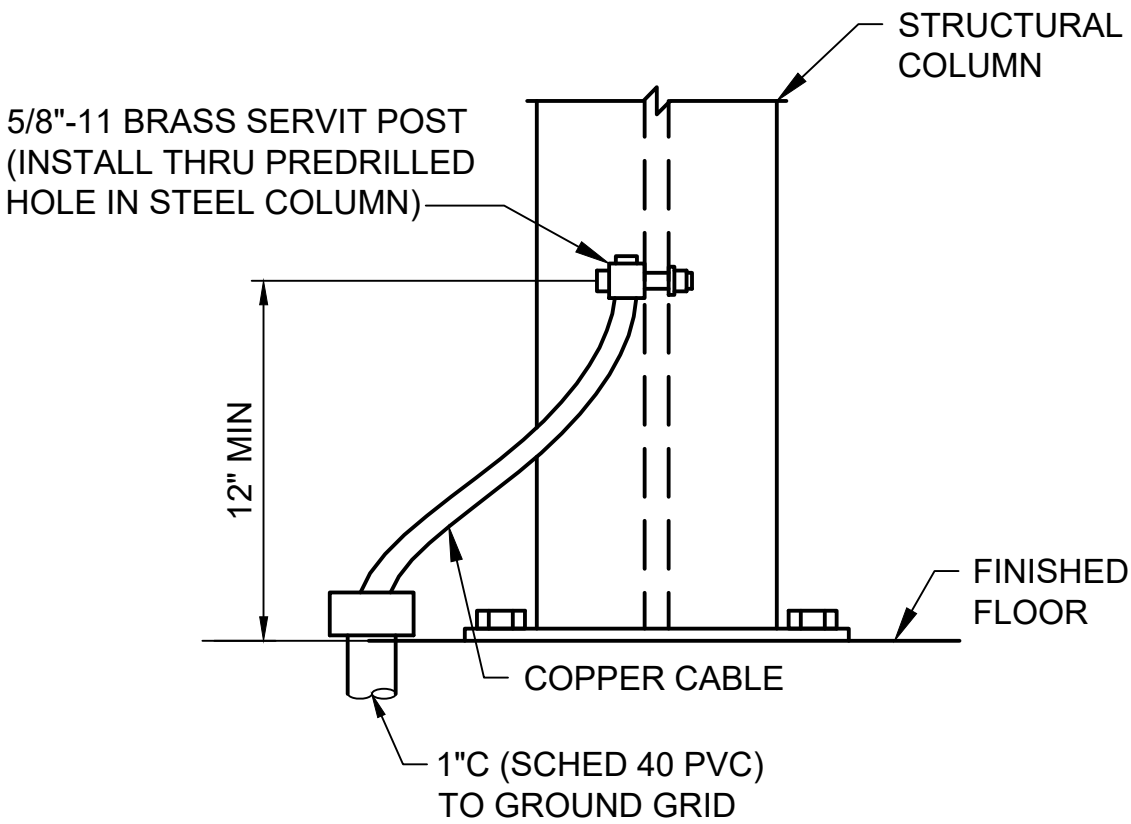


DETAIL
STRUCTURAL STEEL
GROUND CONNECTION
NOT TO SCALE

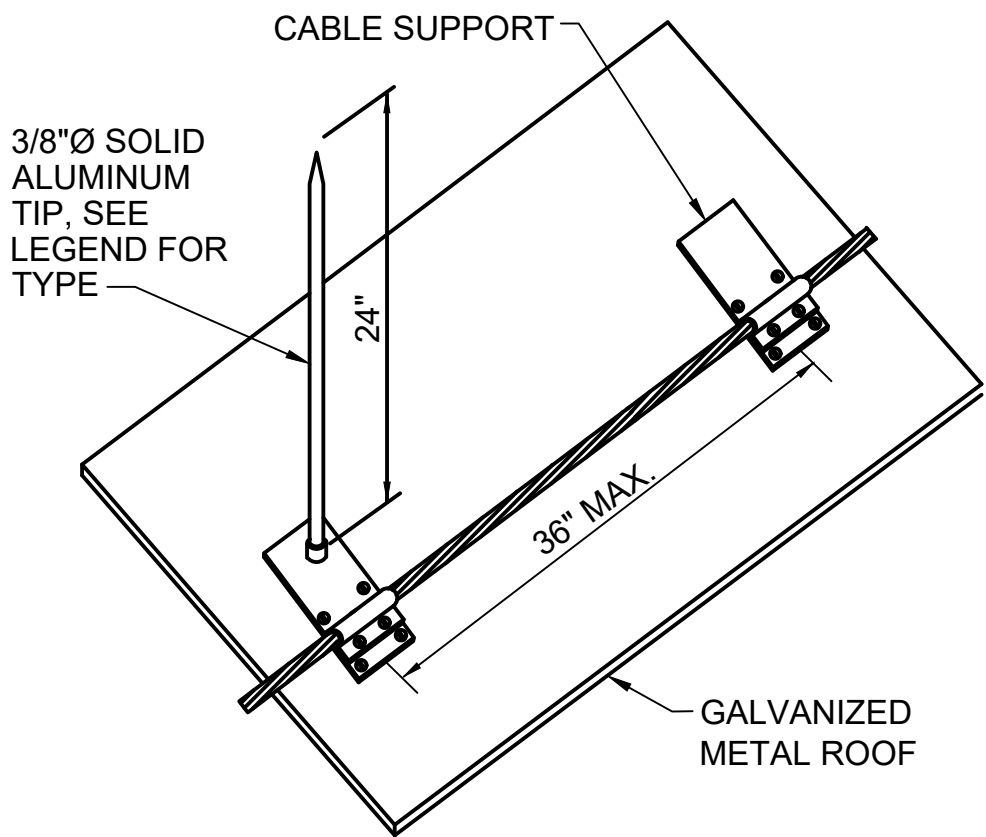

NOTE:
1. AIR TERMINAL TIP SHALL NOT BE LESS THAN 10" ABOVE THE OBJECT/AREA IT IS TO PROTECT. ALL MOUNTING HARDWARE SHALL BE STAINLESS STEEL.

DETAIL
FLAT MOUNT AIR TERMINAL
NOT TO SCALE

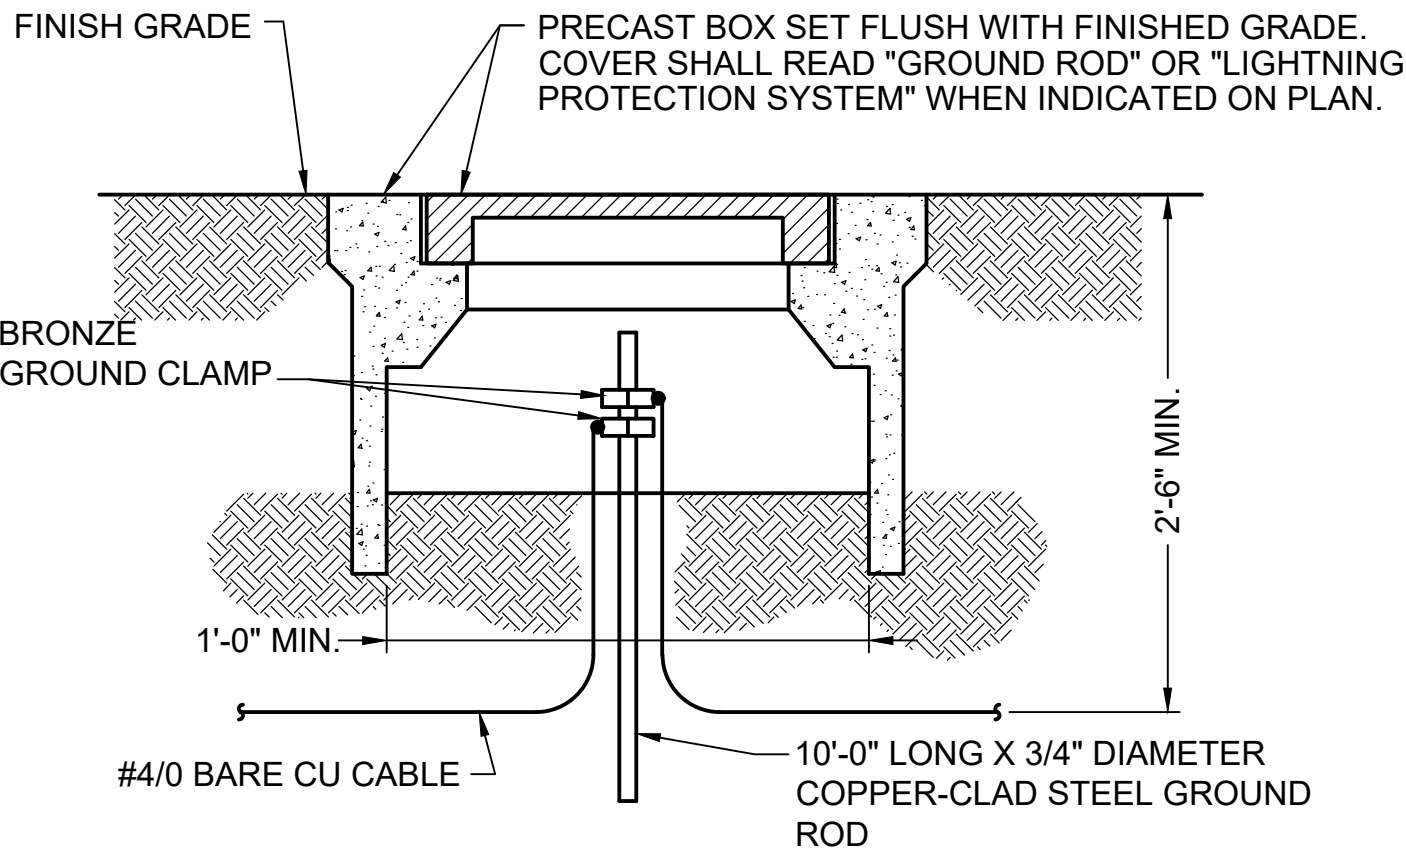

DETAIL
GROUND ROD TEST WELL
NOT TO SCALE

no.	date	by	ckd	description
A	12/21/23	TSR	BAW	ISSUED FOR PERMIT

ISSUED FOR PERMIT
ONLY

**BURNS
MCDONNELL**

9400 WARD PARKWAY
KANSAS CITY, MO 64114
816-333-9400
Burns & McDonnell Engineering Co., Inc.

date	04/24/2023	detailed	S. JESBERG
designed	T. RENSHAW	checked	B. WINTER

PDX FUEL COMPANY L.L.C


PORTLAND INTERNATIONAL AIRPORT
5000 NE MARINE DR.
PORTLAND, OREGON 97218

PDX FACILITY IMPROVEMENTS
ELECTRICAL DETAILS - 3

project	153929	contract	
drawing	E-503	rev.	A


file 153929E-503.dwg

Millimeters
Inches
Scale For Microfilming

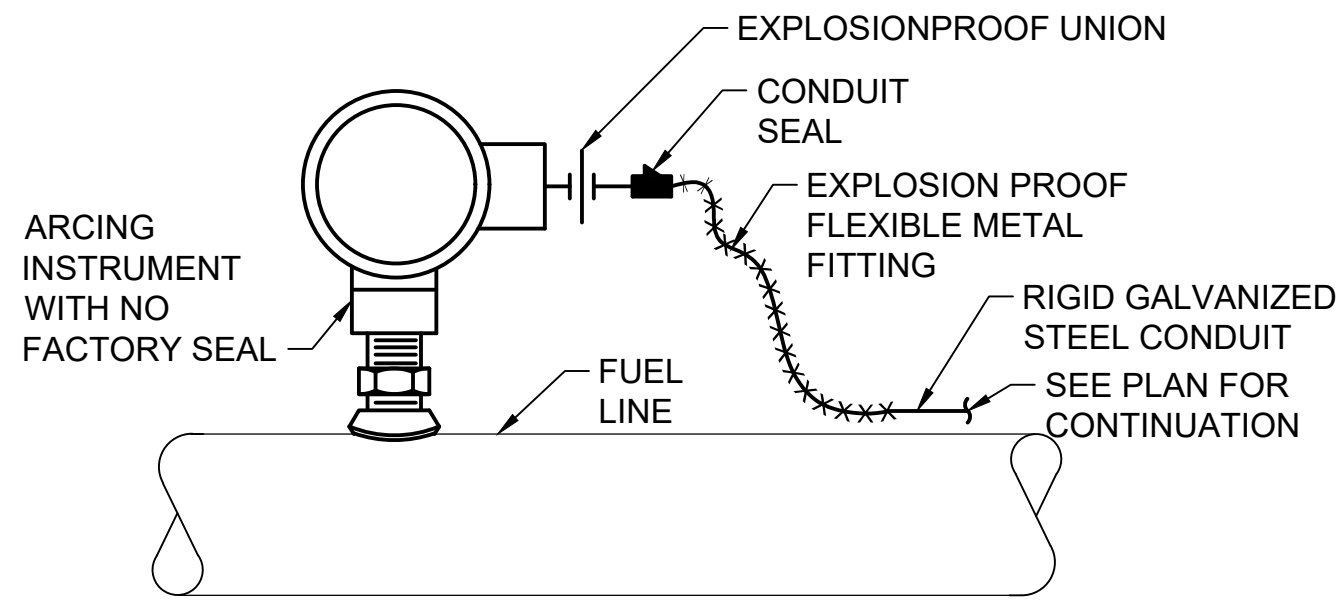


- NOTES:**
- THIS DETAIL APPLIES TO INSTRUMENTS INSTALLED ON TANKS NEAR MANWAYS AND HATCHES.
 - LIST OF ARCING INSTRUMENTS AND INSTRUMENTS WITH PROCESS SEAL:
 - SOLENOID CONTROL VALVE
 - FLOW SWITCH
 - FILTER/SEPARATOR SUMP WATER DETECTION ELECTRONICS BOX
 - CONTROL STATION HAND SWITCHES

DETAIL **1**
TYPICAL CLASS I, DIVISION 1,
GROUP D ARCING
INSTRUMENT ASSEMBLY
NOT TO SCALE

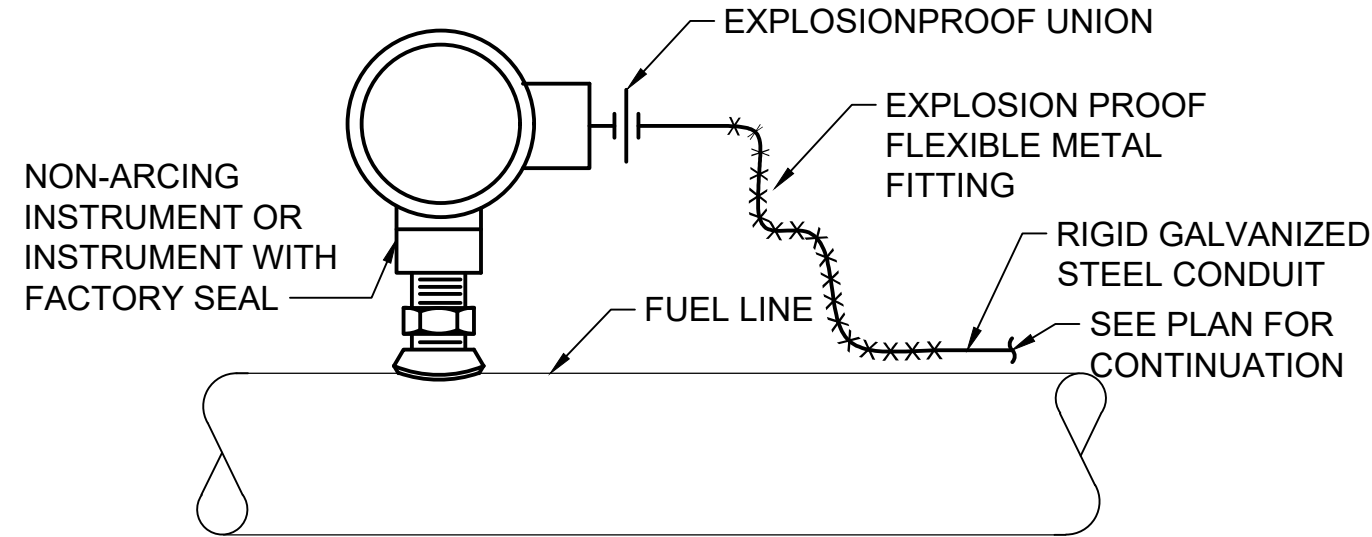


- NOTES:**
- TRANSMITTER MUST BE LABELED AS FACTORY SEALED ON NAMEPLATE.
 - LIST OF FACTORY SEALED OR NON-ARCING INSTRUMENTS:
 - INTRINSICALLY SAFE FILTER/SEPARATOR WATER DETECTION DEVICE
 - PRESSURE TRANSMITTER
 - FLOW TRANSMITTER
 - TEMPERATURE TRANSMITTER
 - RESISTANCE TEMPERATURE DEVICE

DETAIL **2**
TYPICAL CLASS I, DIVISION 1,
GROUP D NON ARCING
INSTRUMENT OR INSTRUMENT
ASSEMBLY WITH FACTORY SEAL
NOT TO SCALE

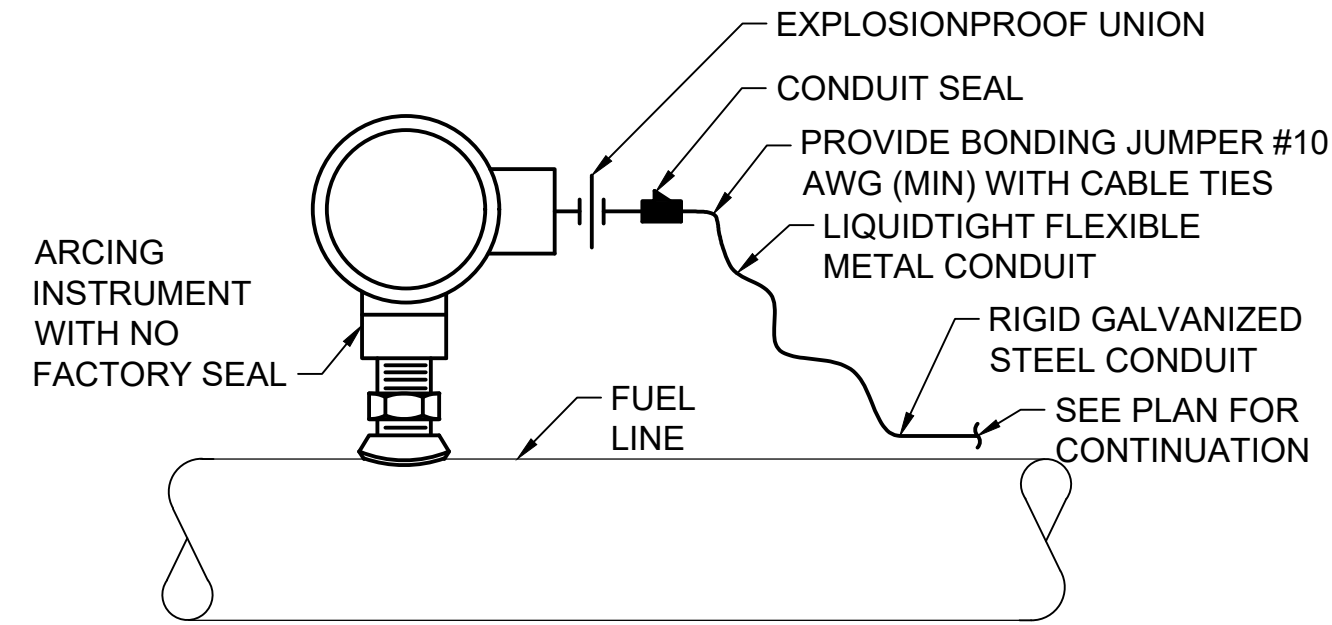


- NOTES:**
- LIST OF ARCING INSTRUMENTS AND INSTRUMENTS WITH PROCESS SEAL:
 - SOLENOID CONTROL VALVE
 - FLOW SWITCH
 - FILTER/SEPARATOR SUMP WATER DETECTION ELECTRONICS BOX
 - CONTROL STATION HAND SWITCHES

DETAIL **3**
TYPICAL CLASS I, DIVISION 2,
GROUP D ARCING
INSTRUMENT ASSEMBLY
NOT TO SCALE

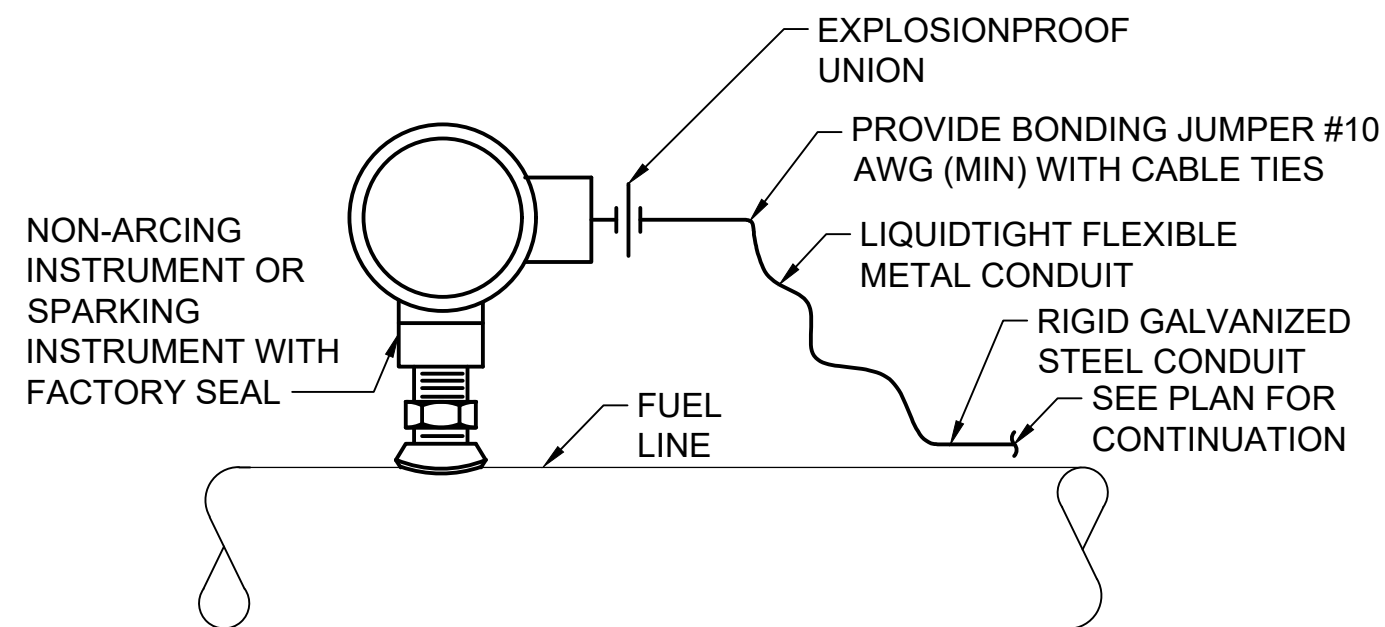


- NOTES:**
- TRANSMITTER MUST BE LABELED AS FACTORY SEALED ON NAMEPLATE.
 - LIST OF FACTORY SEALED OR NON-ARCING INSTRUMENTS:
 - INTRINSICALLY SAFE FILTER/SEPARATOR WATER DETECTION DEVICE
 - PRESSURE TRANSMITTER
 - FLOW TRANSMITTER
 - TEMPERATURE TRANSMITTER
 - RESISTANCE TEMPERATURE DEVICE

DETAIL **4**
TYPICAL CLASS I, DIVISION 2,
GROUP D NON ARCING INSTRUMENT
OR INSTRUMENT ASSEMBLY WITH
FACTORY SEAL
NOT TO SCALE

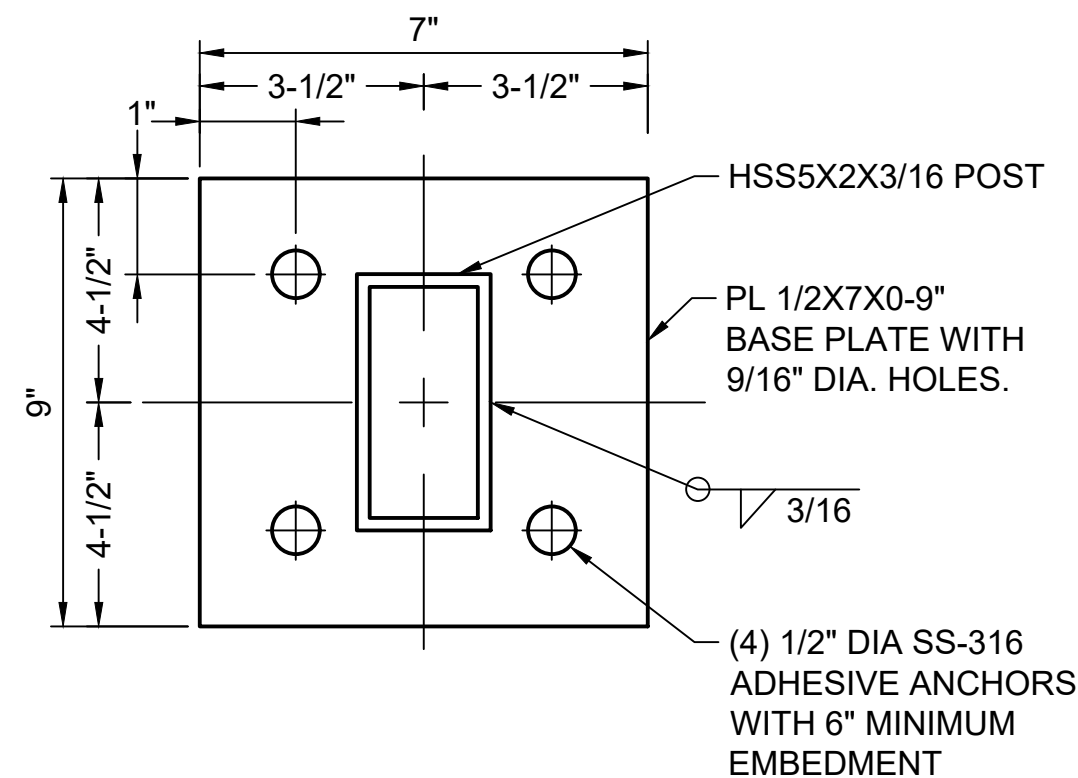

SECTION **5**
RACK SUPPORT BASE
NOT TO SCALE

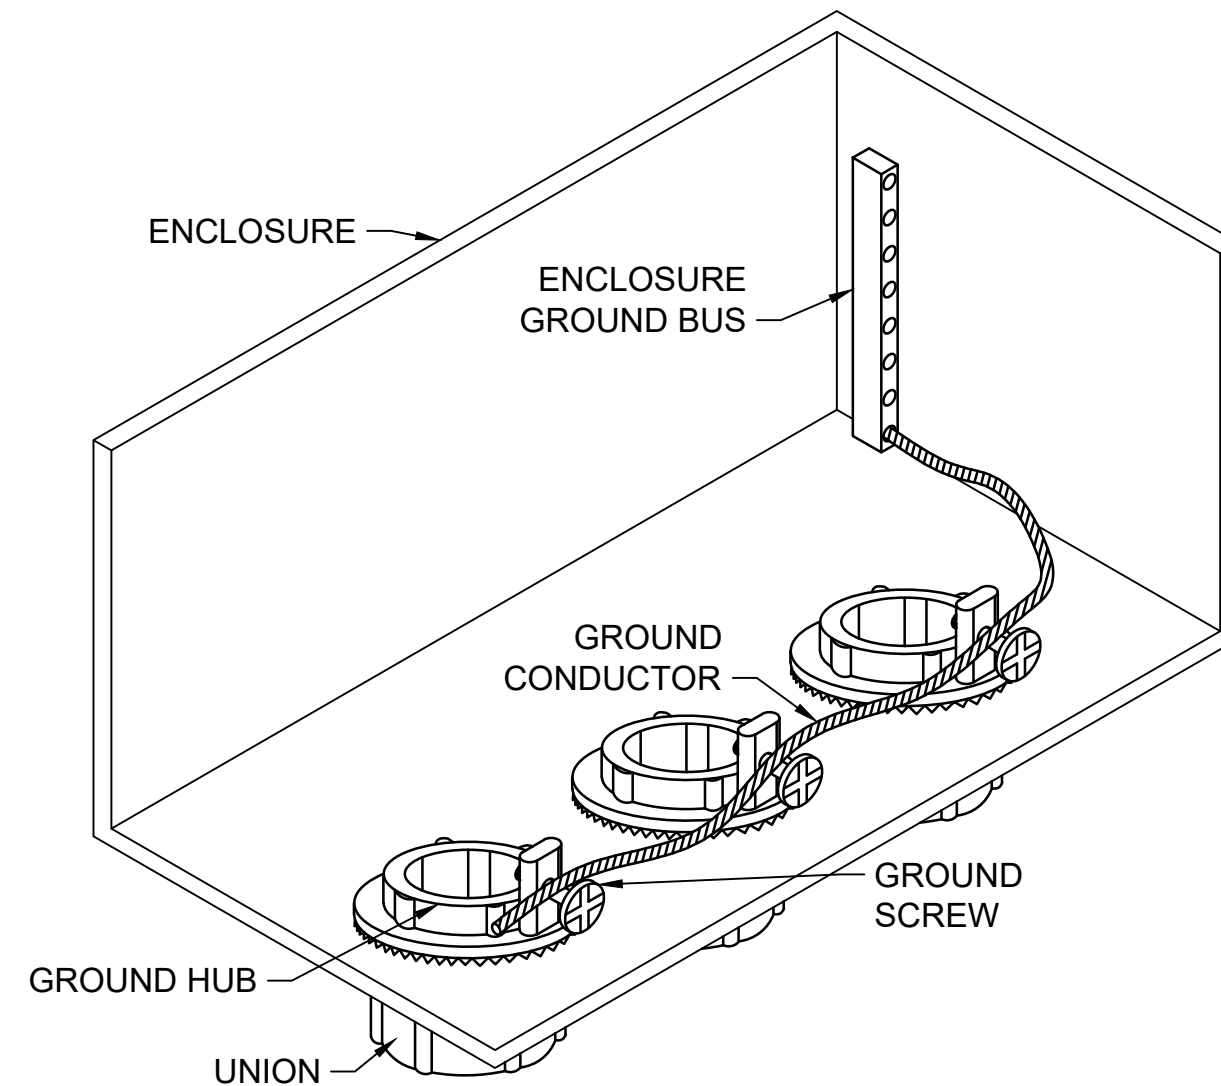

DETAIL **6**
TYPICAL CONDUIT DETAIL
CONNECTION TO ENCLOSURE
NOT TO SCALE

NOTES:

- SEE SHEET E-001 FOR GENERAL NOTES, LEGEND AND ABBREVIATIONS.

no.	date	by	ckd	description
A	12/21/23	TSR	BAW	ISSUED FOR PERMIT

ISSUED FOR PERMIT ONLY

BURNS
MCDONNELL

9400 WARD PARKWAY
KANSAS CITY, MO 64114
816-333-9400
Burns & McDonnell Engineering Co., Inc.

date	04/24/2023	detailed	S. JESBERG
designed	T. RENSHAW	checked	B. WINTER


PDX FUEL COMPANY L.L.C

PORTLAND INTERNATIONAL AIRPORT
5000 NE MARINE DR.
PORTLAND, OREGON 97218

PDX FACILITY IMPROVEMENTS
ELECTRICAL DETAILS - 4

project	153929	contract	
drawing	E-504	rev.	A

file 153929E-504.dwg

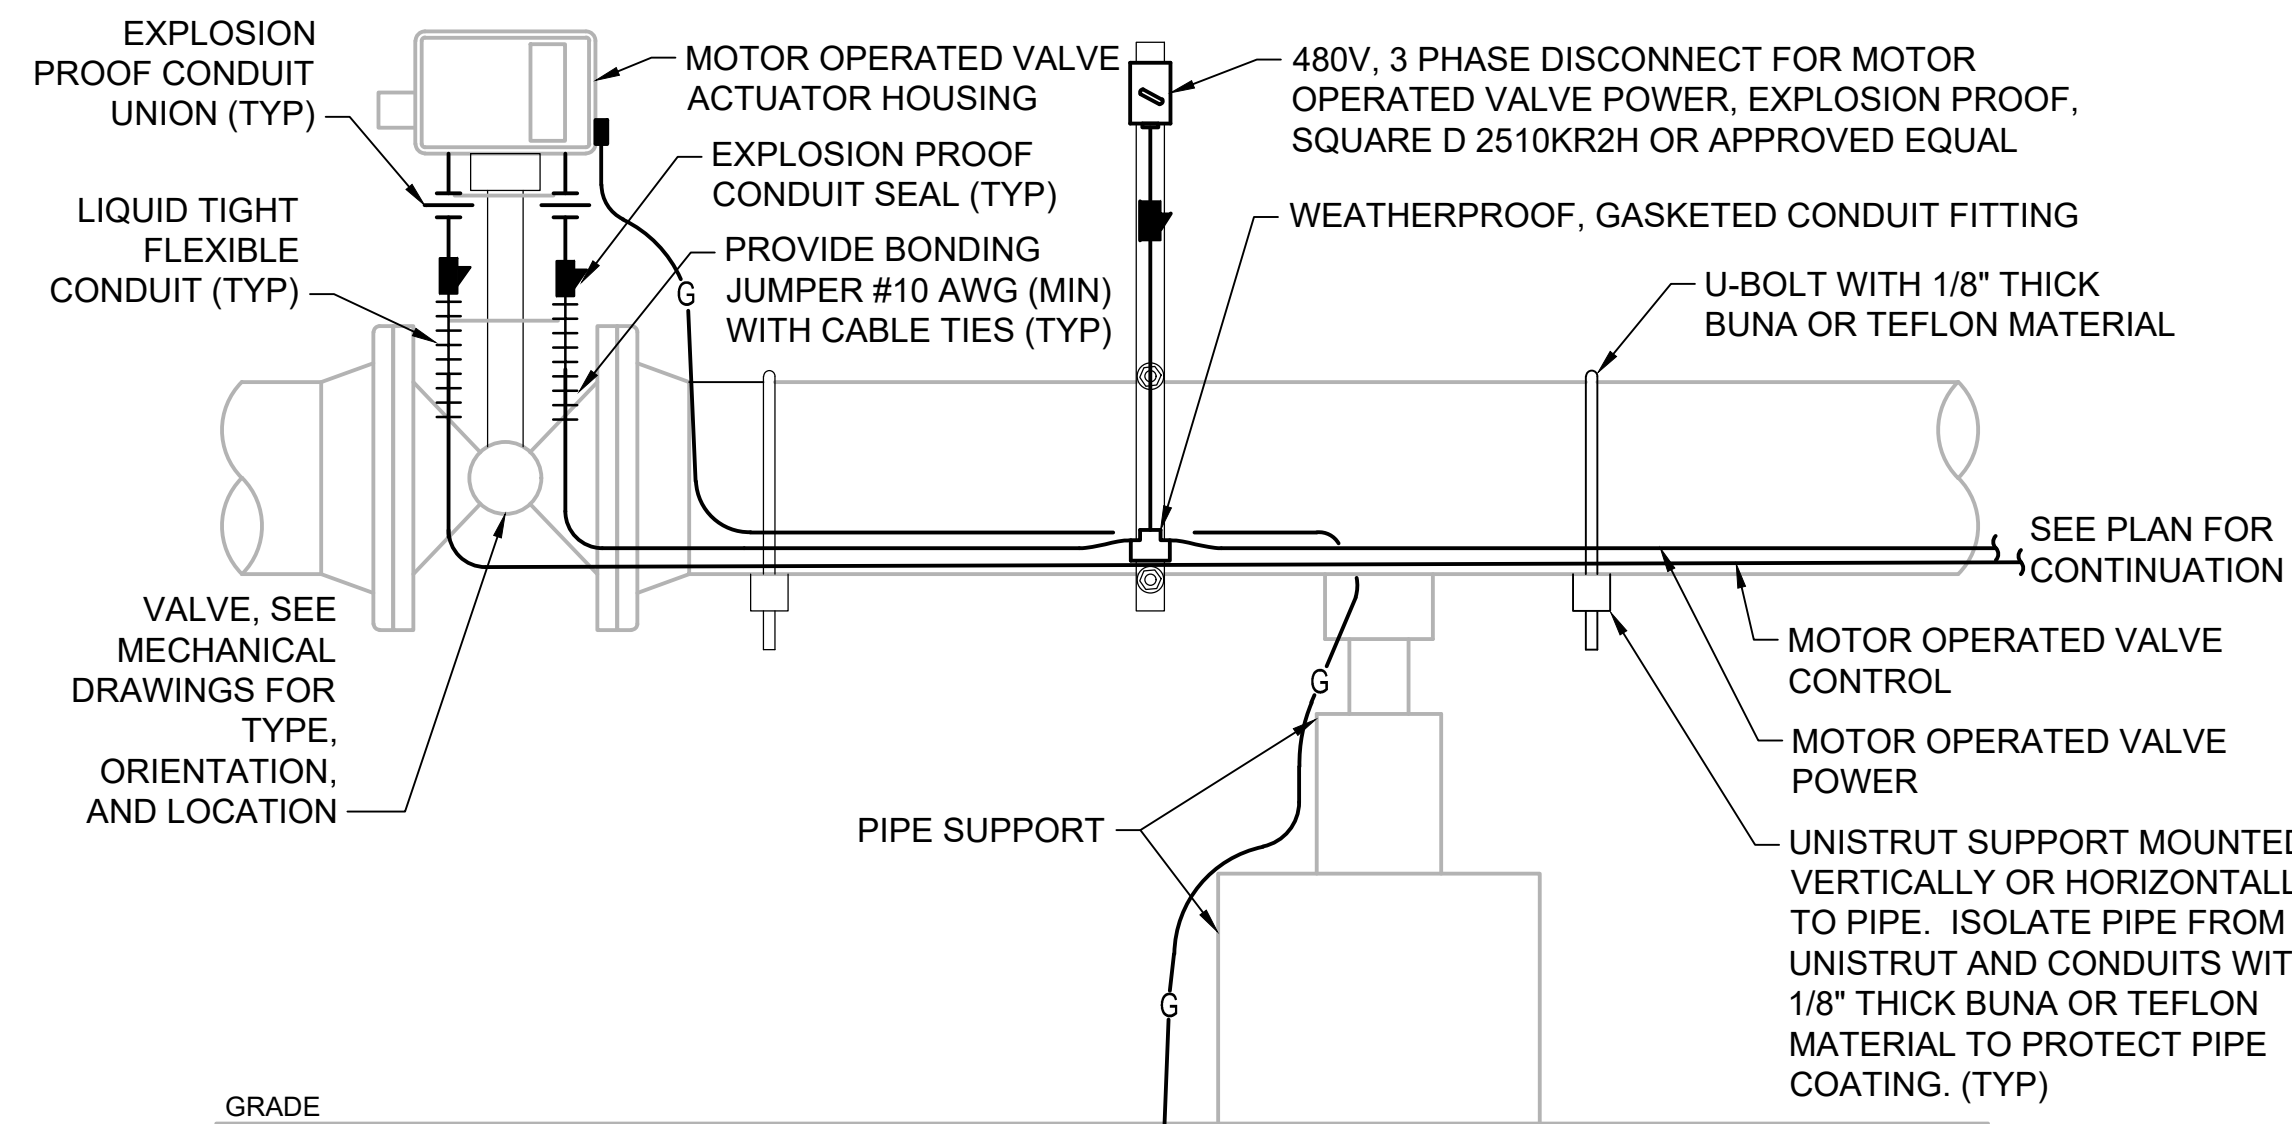


#4/0 AWG COPPER CABLE TO
NEAREST ADJACENT GROUND ROD

DETAIL

**TYPICAL MOTOR
OPERATED VALVE**

NOT TO SCALE

1
-

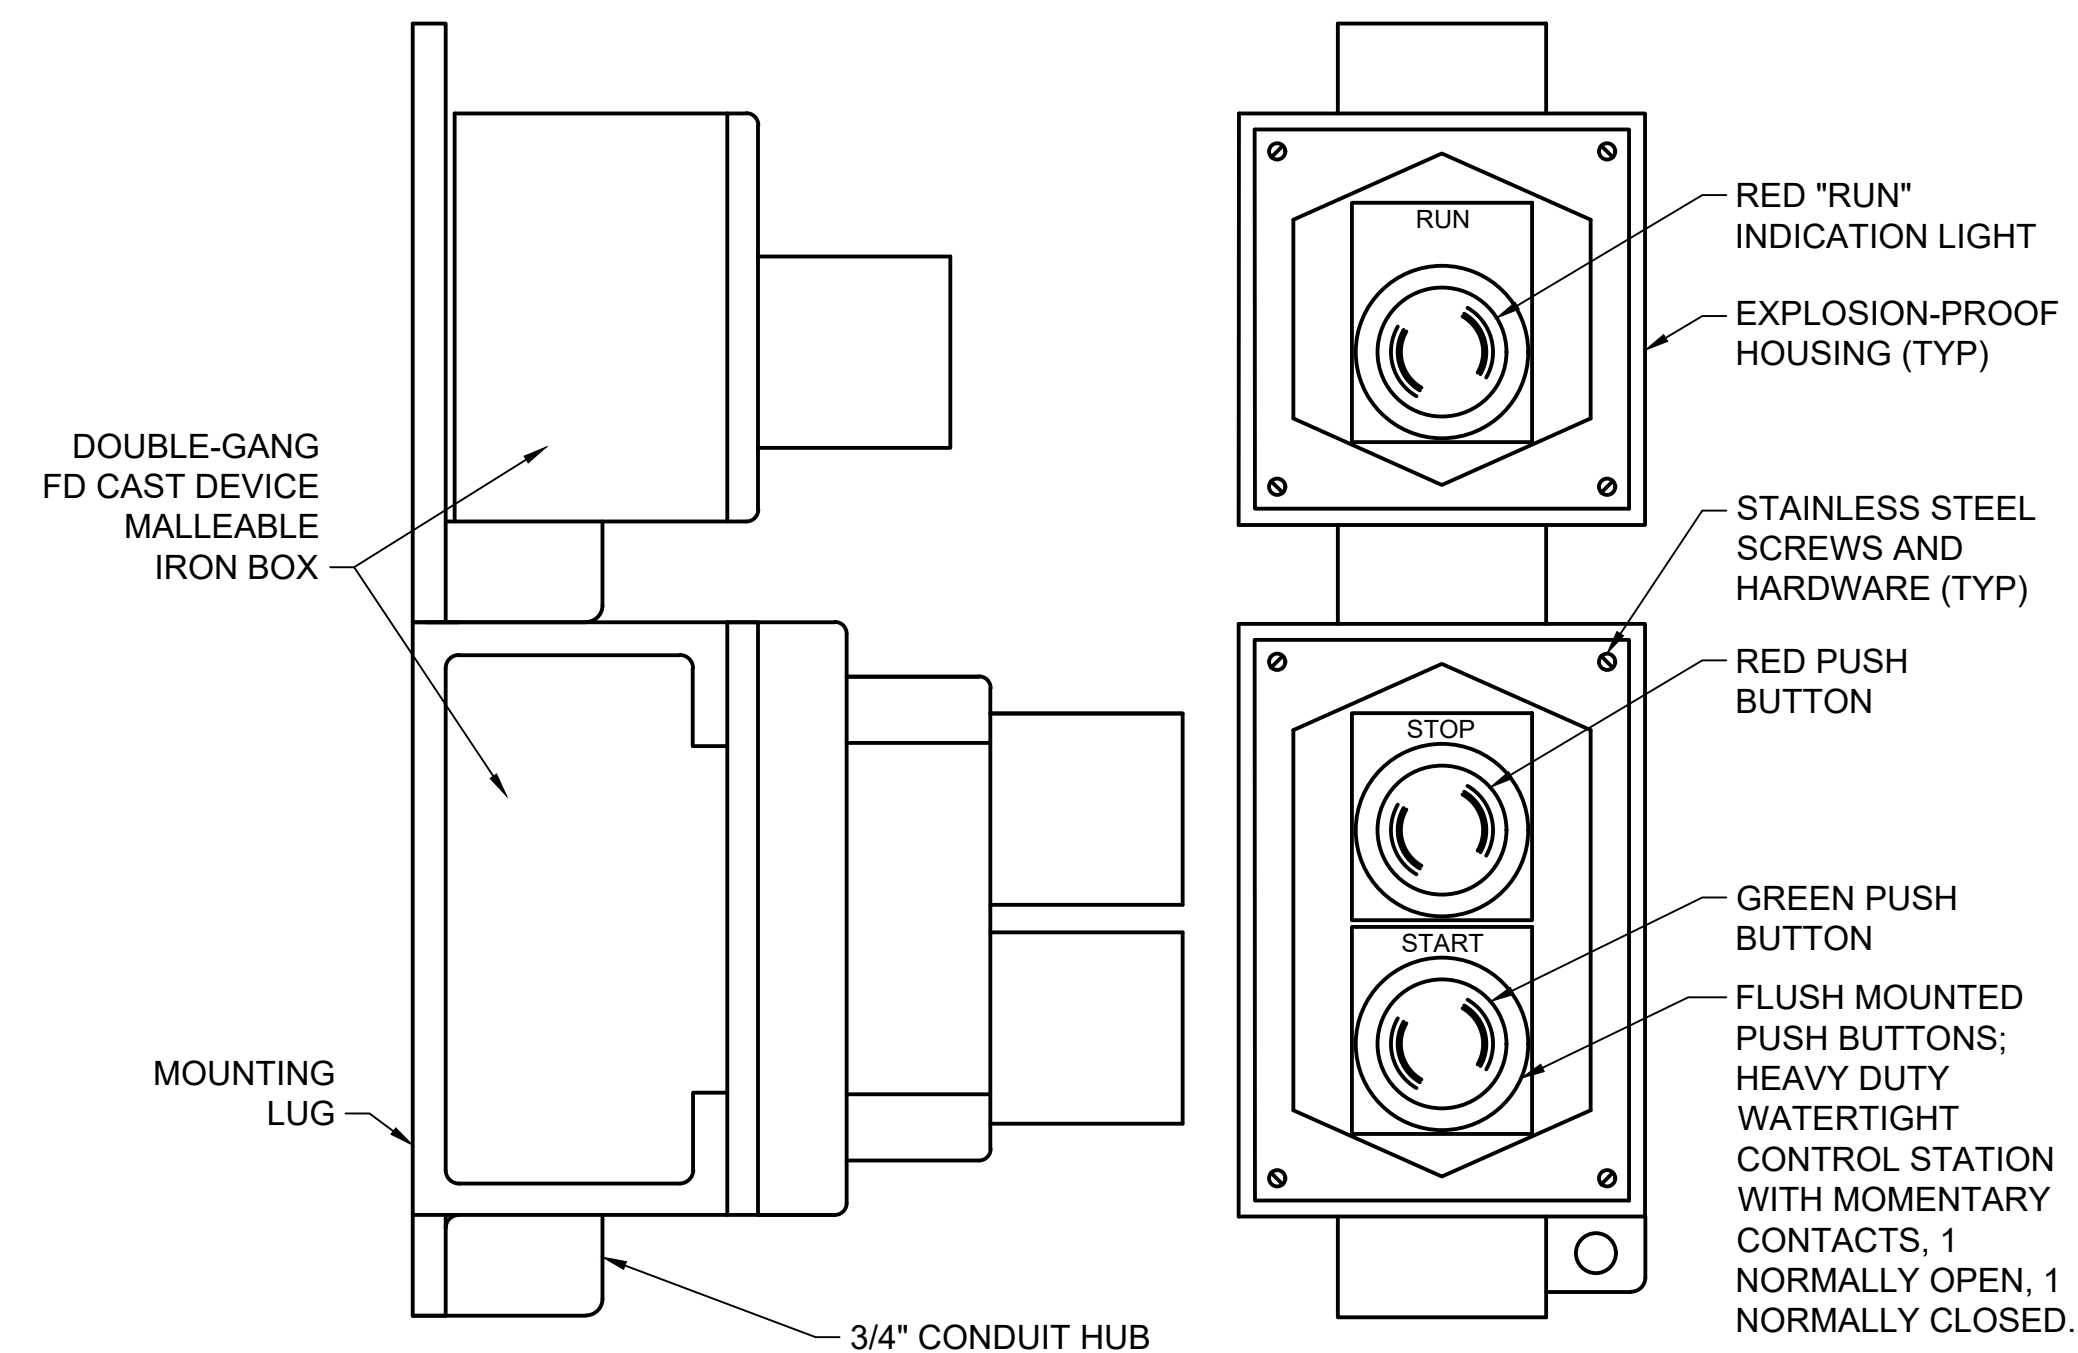

NOTE:


1. STATION SHALL BE A FULLY ASSEMBLED FACTORY SEALED, HEAVY DUTY, COMBINATION PUSHBUTTON AND PILOT LIGHT STATION, EXPLOSION PROOF RATED FOR CLASS I, DIVISION 1 & 2, GROUP D.

DETAIL

PUMP PUSHBUTTON
& PILOT LIGHT

NOT TO SCALE

4
-

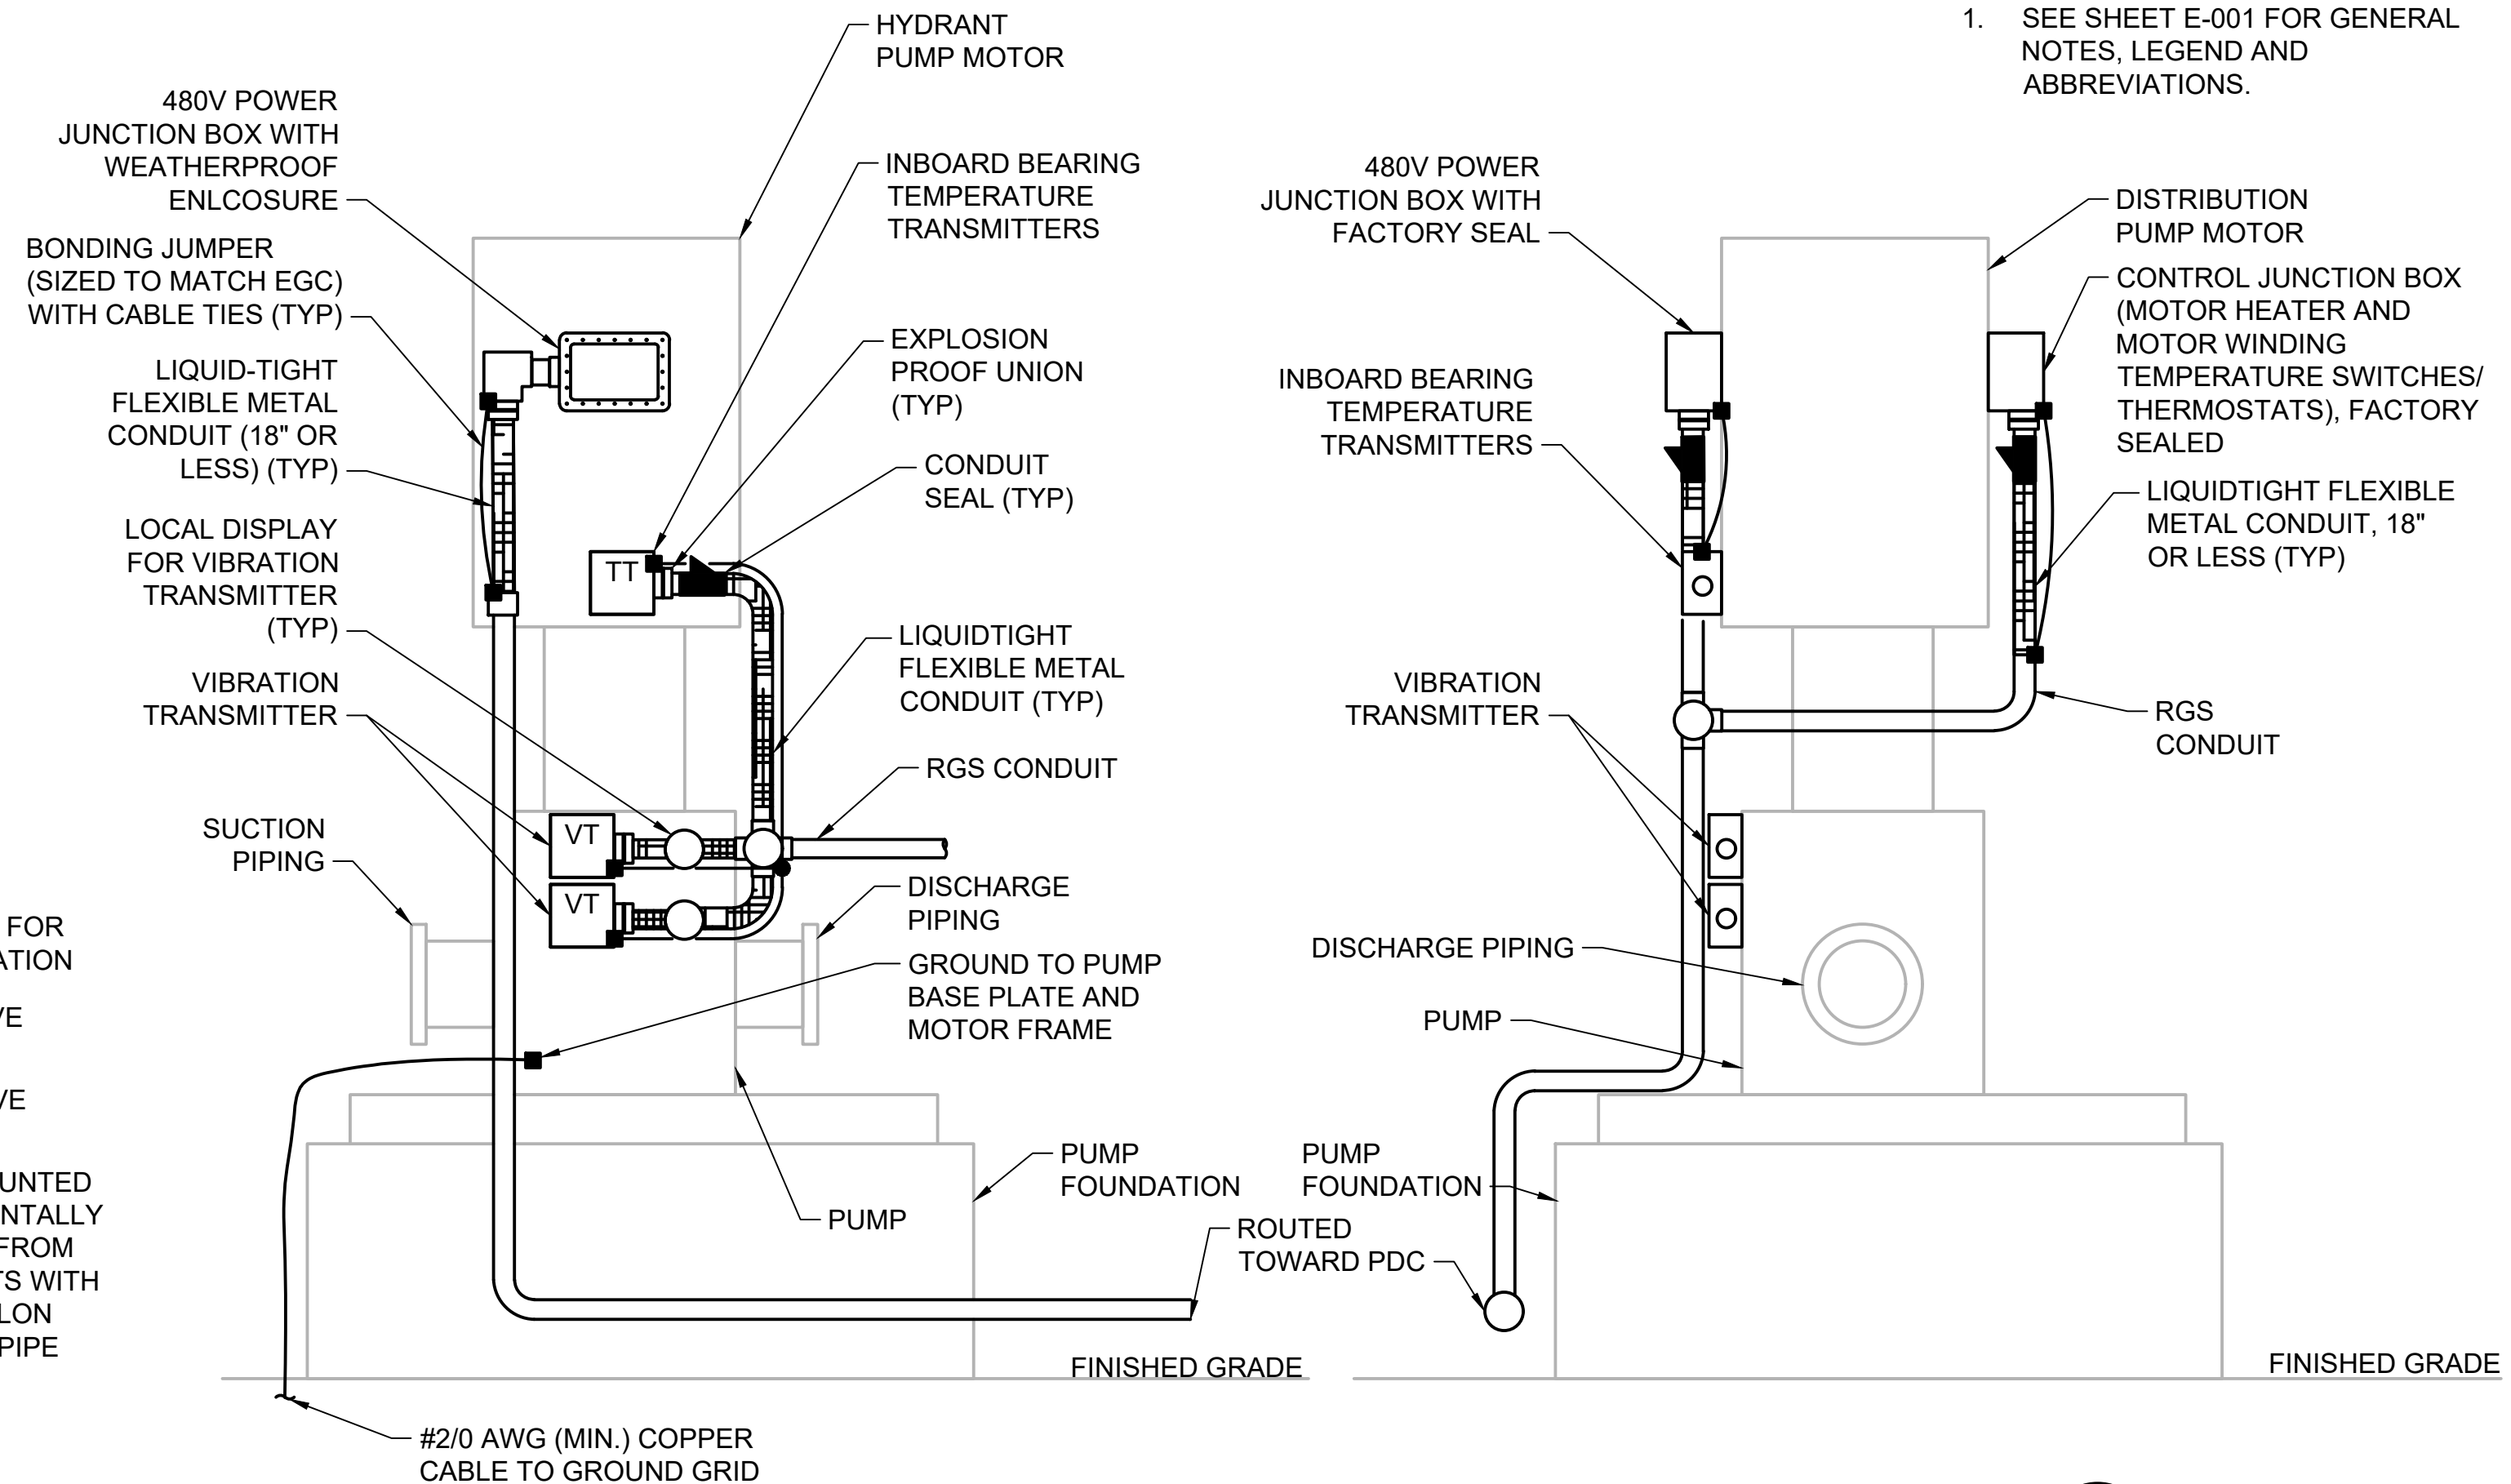


DETAIL

**HCTS PUMP INSTRUMENTATION
AND CONNECTION (SIDE VIEW)**

NOT TO SCALE


2
E-507

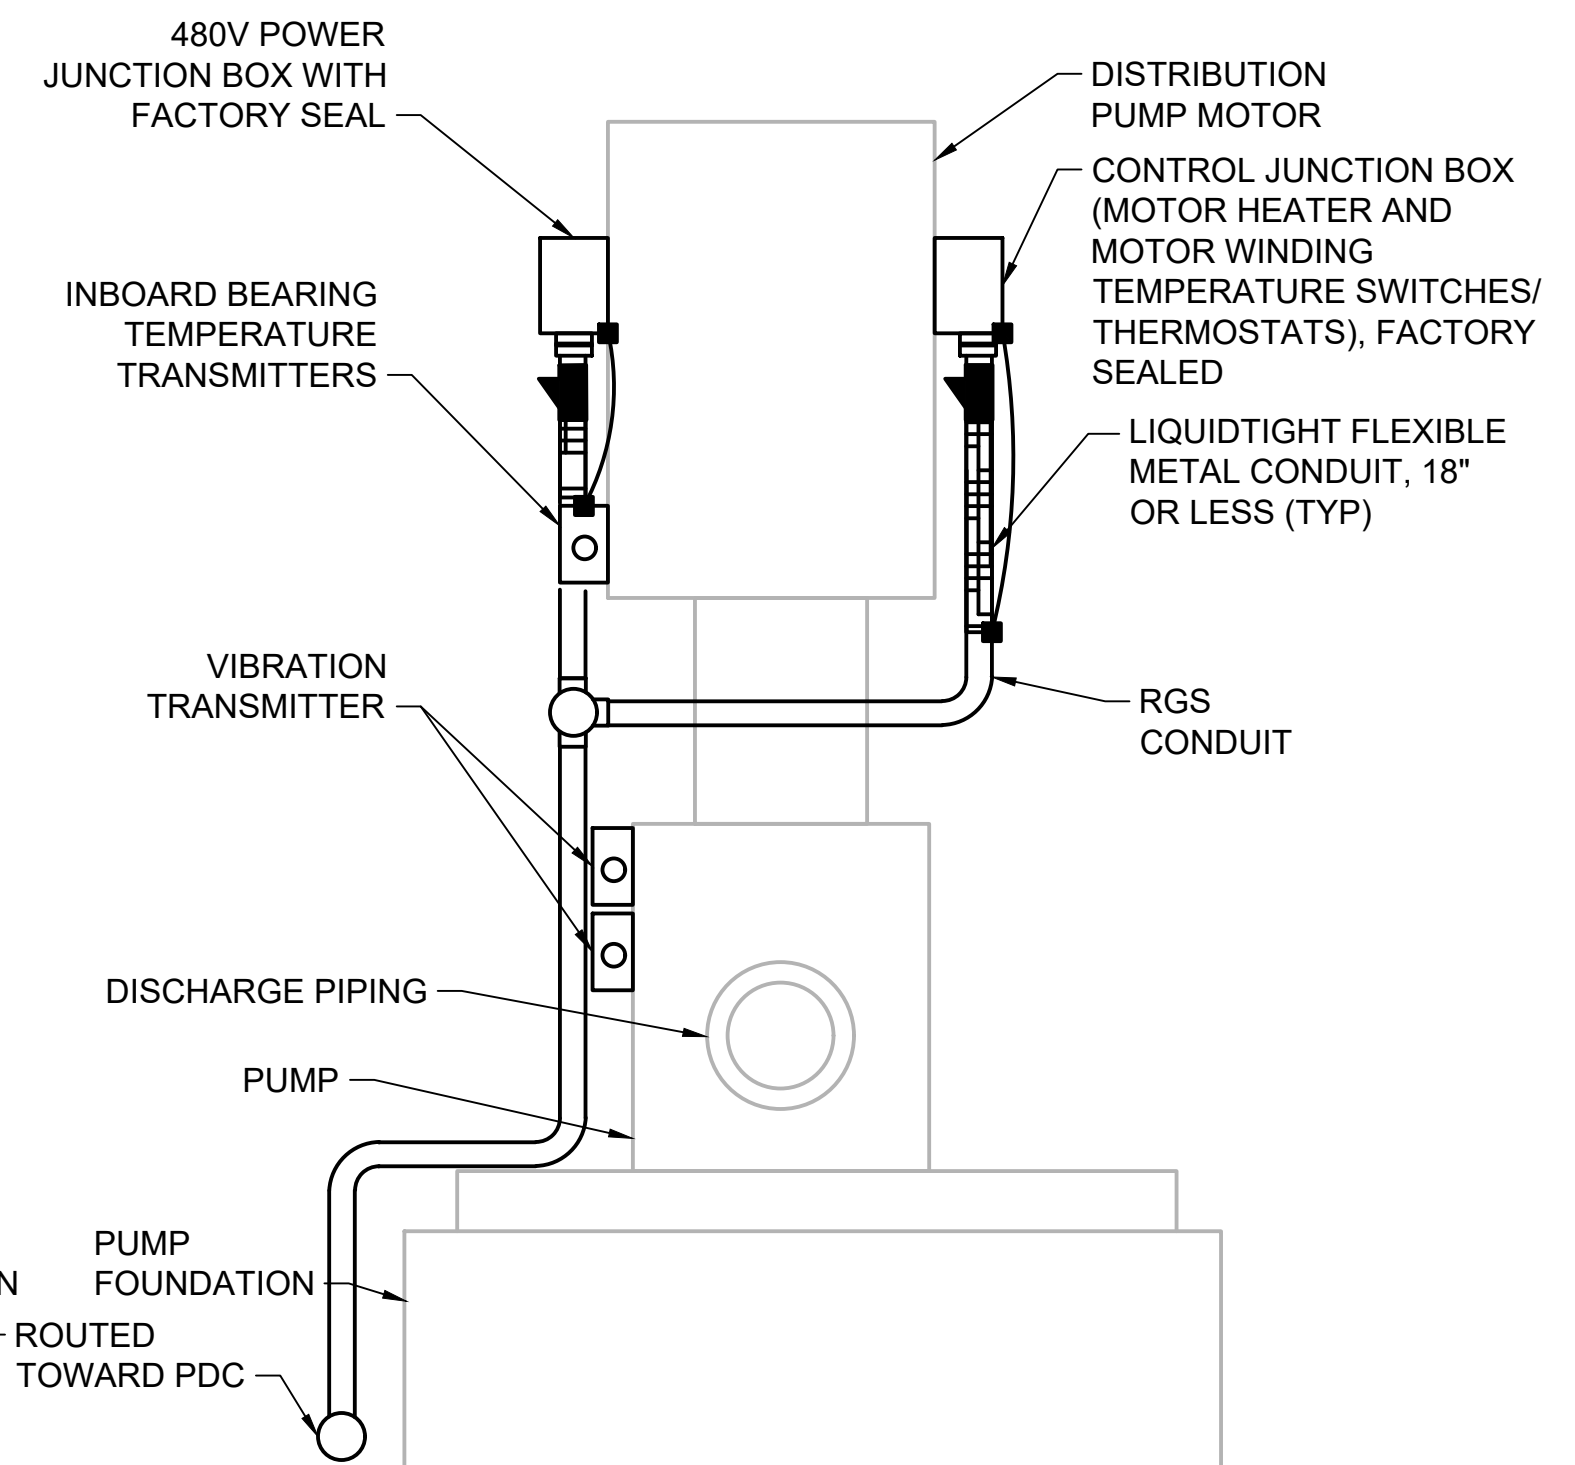

DETAIL 3
HCTS PUMP INSTRUMENTATION
AND CONNECTION (FRONT VIEW) E-507
 NOT TO SCALE

NOTES:

1. SEE SHEET E-001 FOR GENERAL NOTES, LEGEND AND ABBREVIATIONS.

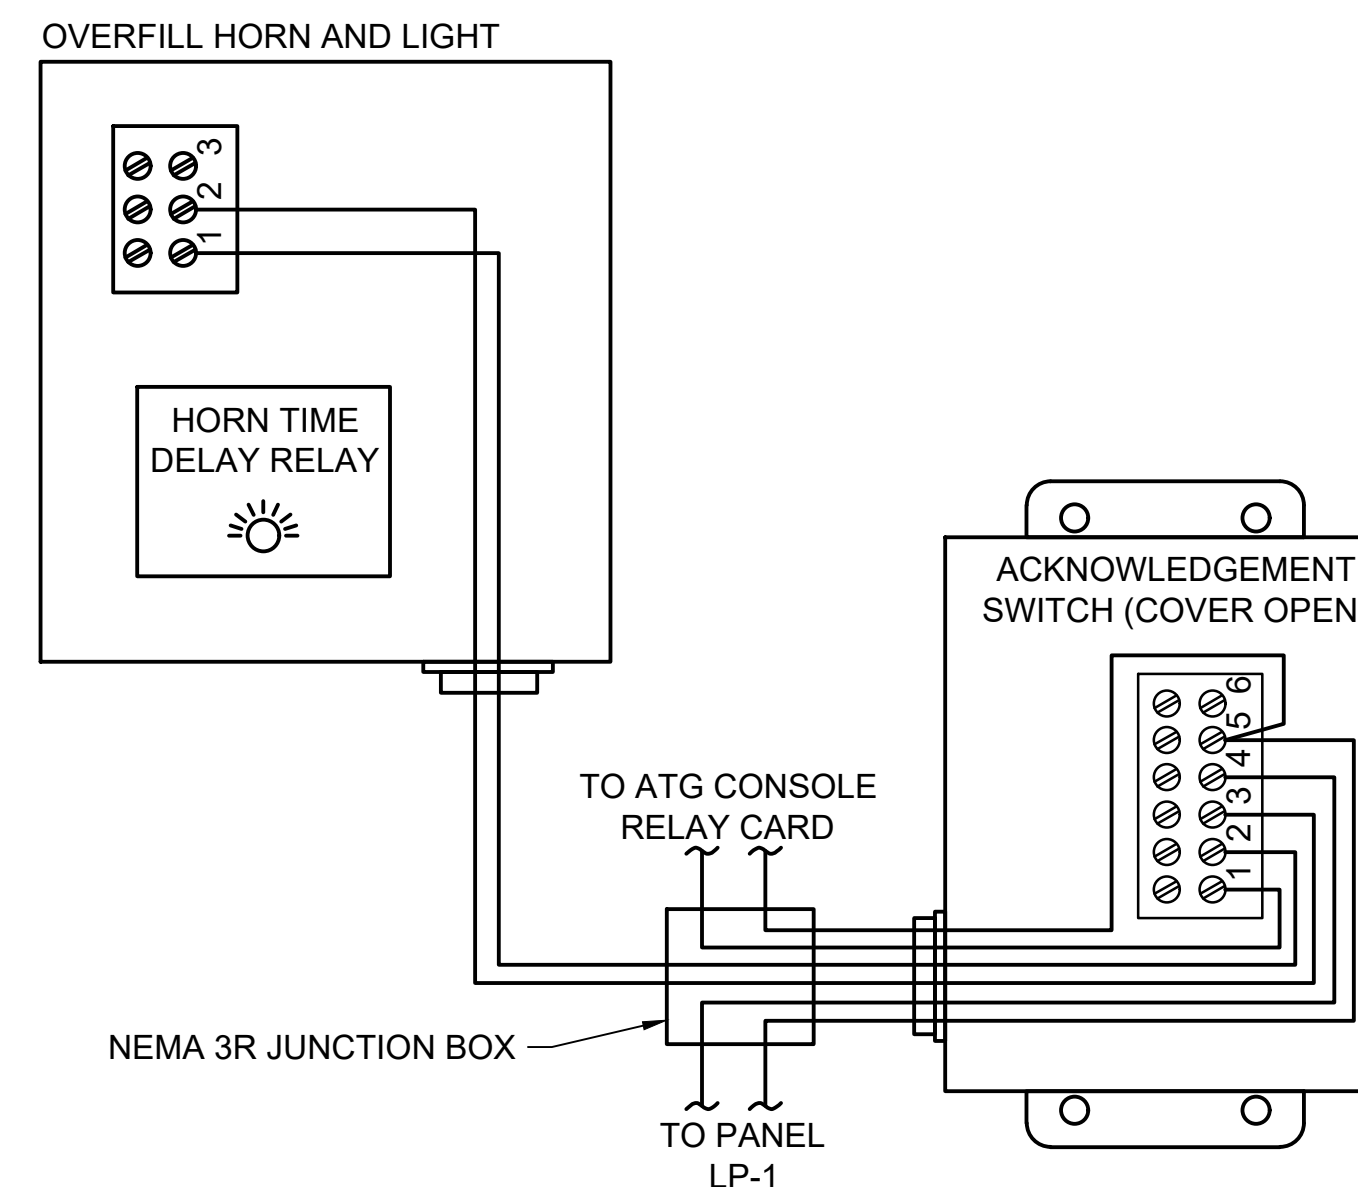

DETAIL

**OVERFILL AND
ACKNOWLEDGMENT
ALARM SWITCH**

NOT TO SCALE

5
-

no.	date	by	ckd	description
A	12/21/23	TSR	BAW	ISSUED FOR PERMIT

**ISSUED FOR PERMIT
ONLY**

**BURNS
MCDONNELL**
9400 WARD PARKWAY
KANSAS CITY, MO 64114
816-333-9400
Burns & McDonnell Engineering Co, Inc.

date 04/24/2023	detailed S. JESBERG
designed T. RENSHAW	checked B. WINTER

PDX FUEL COMPANY L.L.C

PORTLAND INTERNATIONAL AIRPORT
5000 NE MARINE DR.
PORTLAND, OREGON 97218


PDX FACILITY IMPROVEMENTS
ELECTRICAL DETAILS - 5

project	contract
153929	
drawing	rev.

file 153929E-505.dwg

NOTES:

1. SEE SHEET E-001 FOR GENERAL NOTES, LEGEND AND ABBREVIATIONS.
2. REFER TO SHEET E-604 AND E-605 FOR ADDITIONAL DETAILS AND THE EF50 WIRING DIAGRAM.
3. PANEL WAS FURNISHED IN PDX FACILITY UPGRADE PROJECT (2023) PROJECT. REFER TO AS-BUILT CONSTRUCTION DOCUMENTS FOR FURTHER INFORMATION SUCH AS DETAILED WIRING. FABRICATION OF PANEL WAS PERFORMED BY ATGI, ATGI PROJECT NUMBER 34-39, WORK ORDER 22654.8010, DRAWING INDEX PDX-G-003).

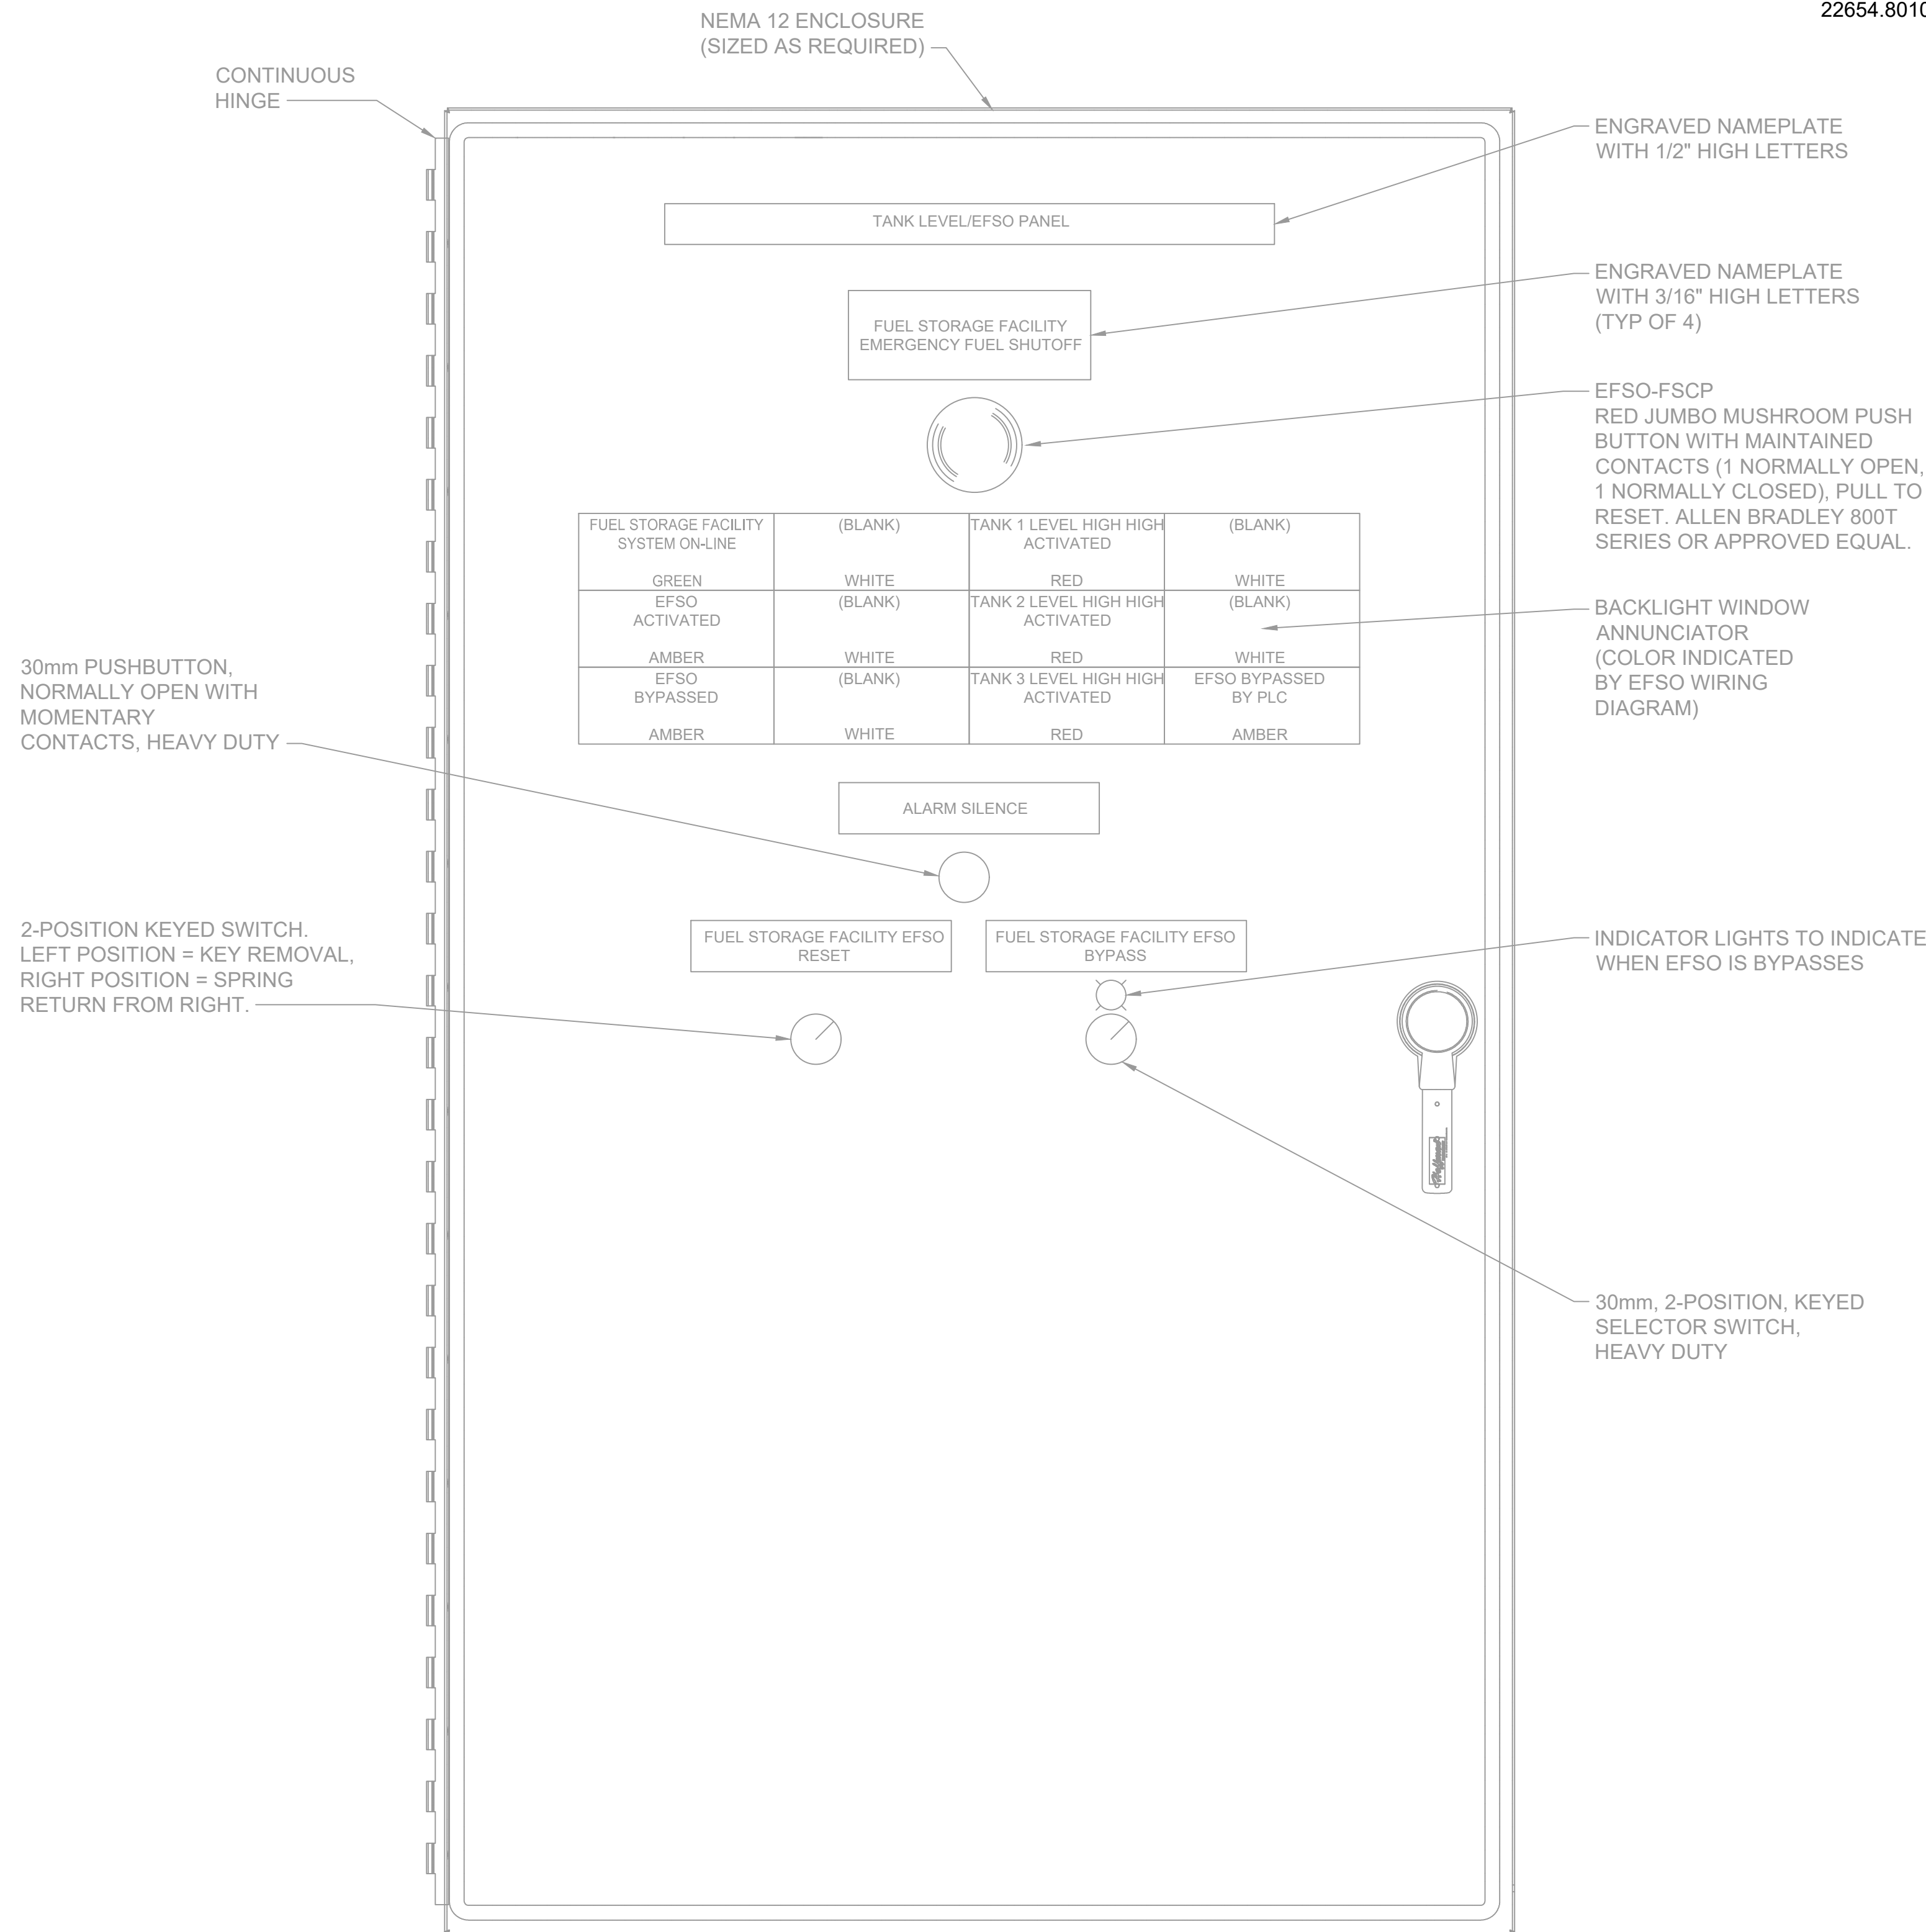

no.	date	by	ckd	description
A	12/21/23	TSR	BAW	ISSUED FOR PERMIT

**ISSUED FOR PERMIT
ONLY**



9400 WARD PARKWAY
KANSAS CITY, MO 64114
816-333-9400
Burns & McDonnell Engineering Co., Inc.

date 04/24/2023	detailed S. JESBERG
designed T. RENSHAW	checked B. WINTER

PDX FUEL COMPANY L.L.C

PORTLAND INTERNATIONAL AIRPORT
5000 NE MARINE DR.
PORTLAND, OREGON 97218

PDX FACILITY IMPROVEMENTS

ELECTRICAL DETAILS - 6

project	contract
153929	
drawing	rev.


file 153929E-506.dwg

12/20/2023

DETAIL


FUEL FACILITY TANK
LEVEL/EFSO PANEL
NOT TO SCALE

1

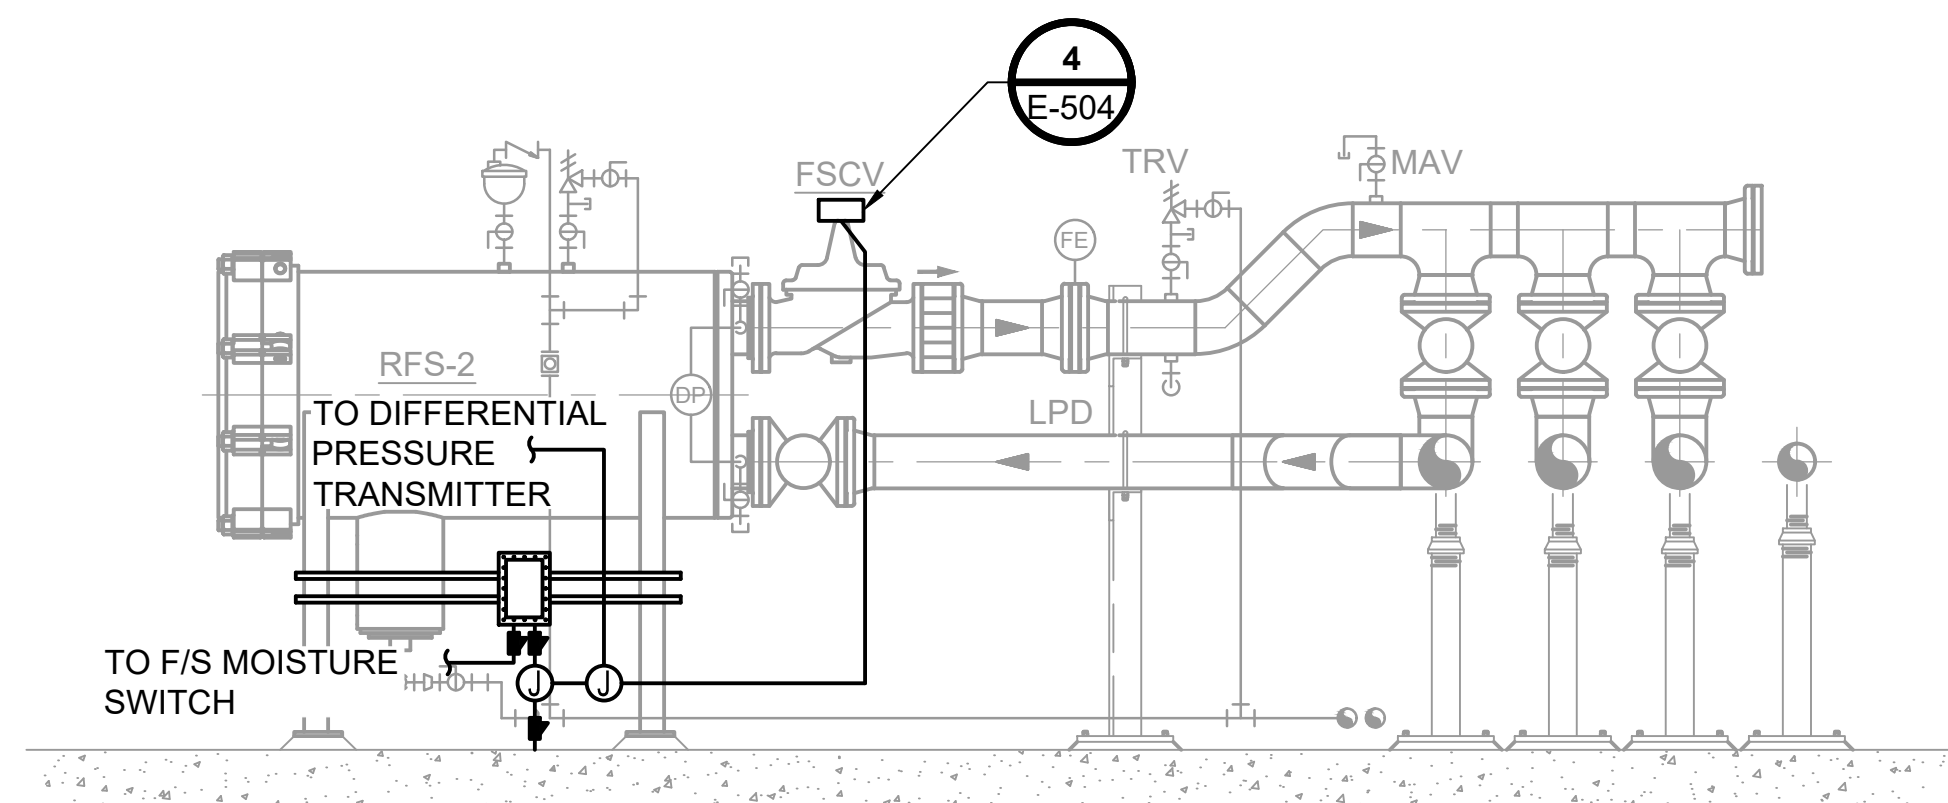

NOTE:
1. CONDUITS SHALL BE PER PLAN DRAWINGS


DETAIL
RECLAIM FILTER SEPARATOR
CROSS SECTION (TYPICAL)
NOT TO SCALE

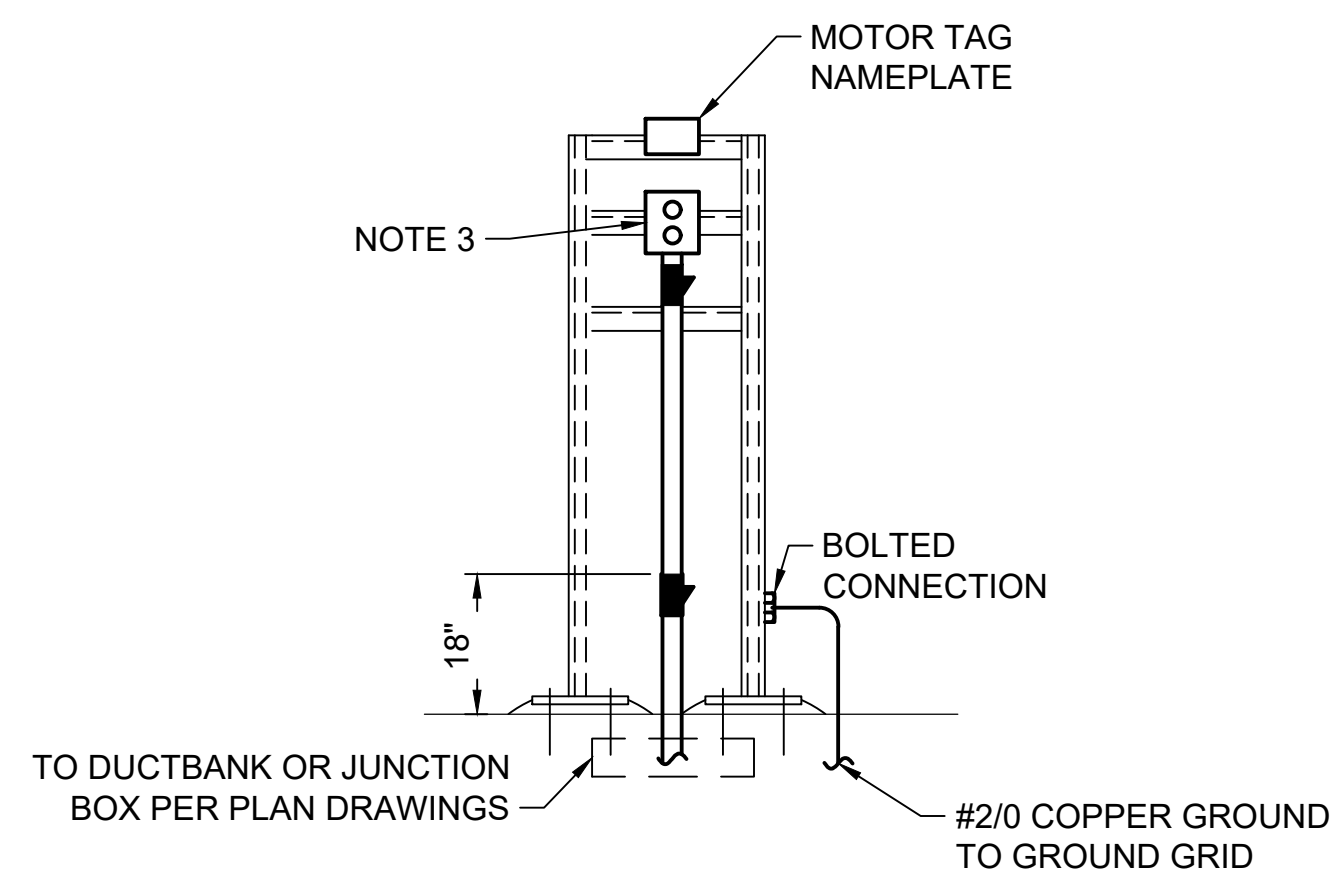

NOTES:

1. EQUIPMENT SHOWN AS REFERENCE. INSTALL EQUIPMENT AS INDICATED ON PLAN.
2. PROVIDE MOTOR TAG NAMEPLATE FOR PUSHBUTTON TO INDICATE FUNCTION.
3. EXPLOSION PROOF START (GREEN)/STOP (RED) PUSHBUTTON, SEE DETAIL 5 ON DWG E-505 FOR ADDITIONAL INFORMATION. RUN INDICATION LIGHT MAY BE REQUIRED, SEE MOTOR STARTER WIRING DIAGRAM.

DETAIL
TYPICAL MOTOR
START/STOP PUSHBUTTON
NOT TO SCALE

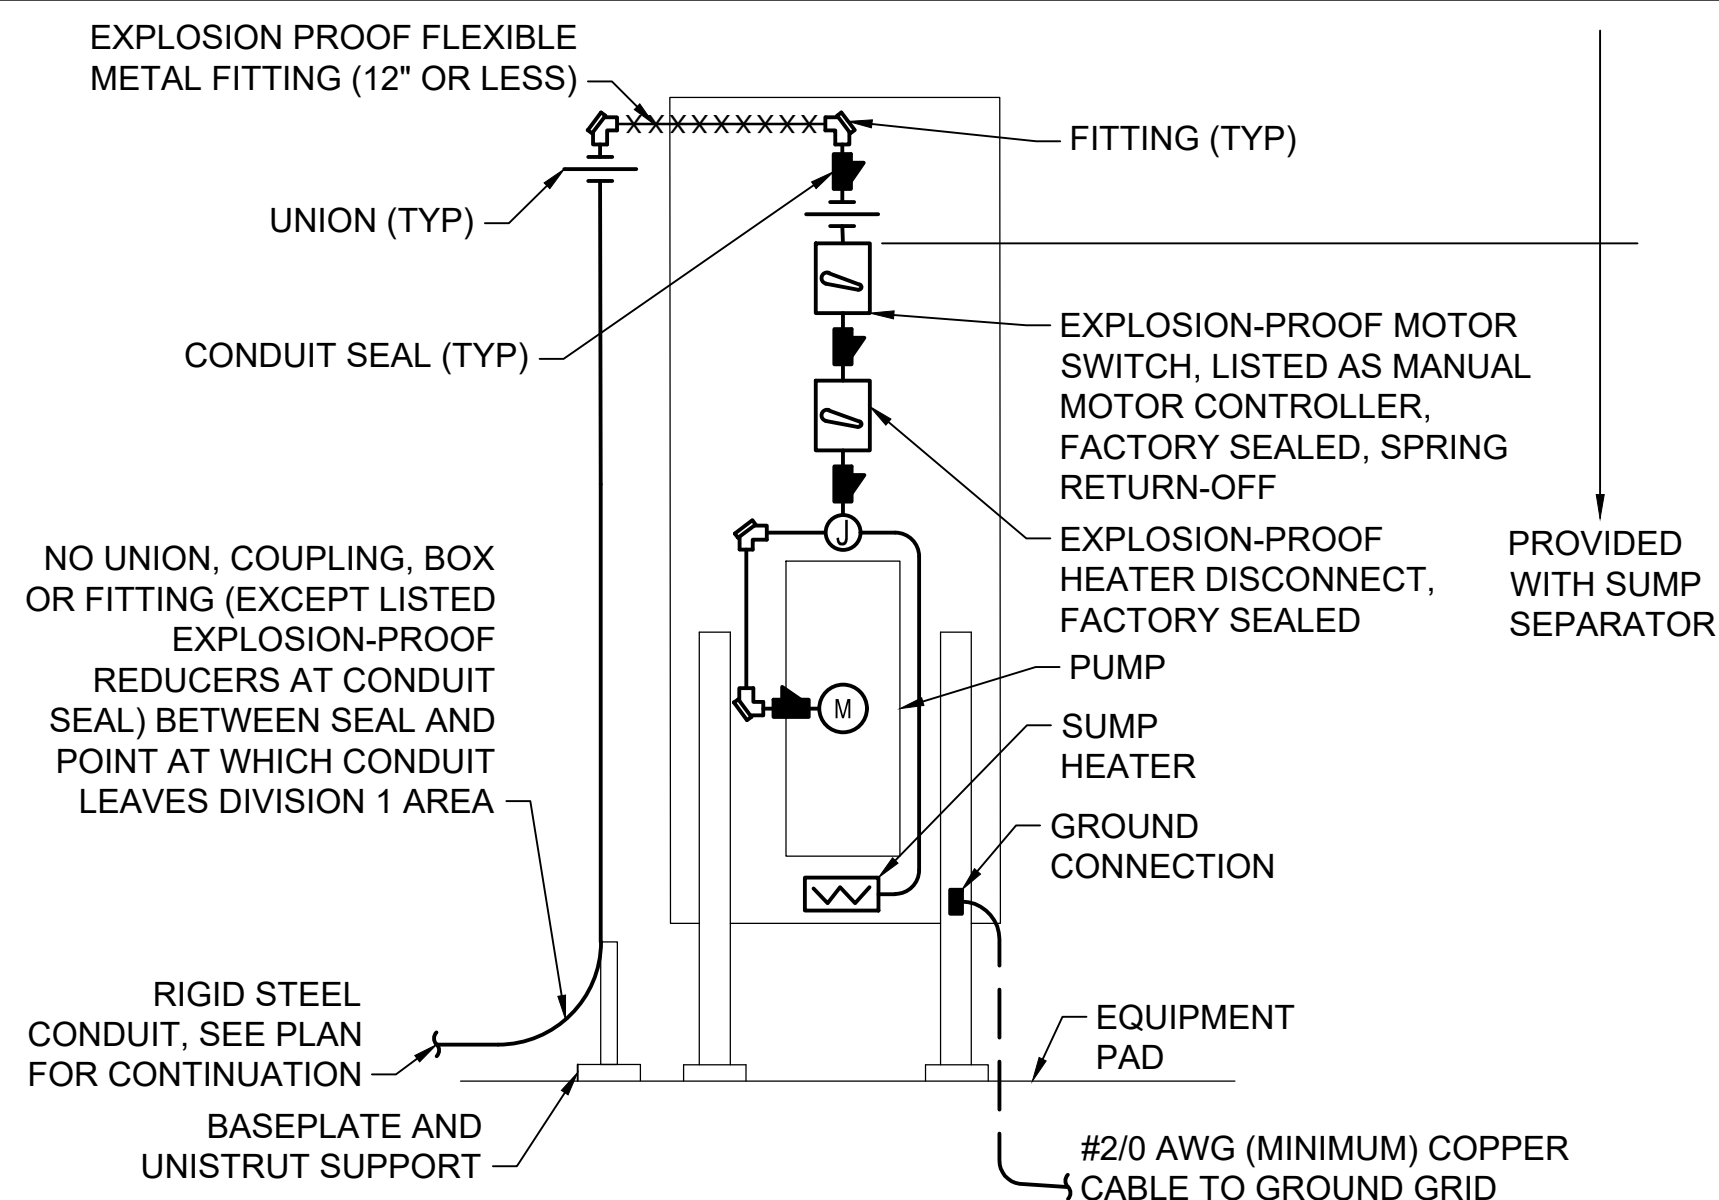

DETAIL

TYPICAL SUMP SEPARATOR

NOT TO SCALE

NOTES:

1. SEE SHEET E-001 FOR
GENERAL NOTES, LEGEND
AND ABBREVIATIONS.

no.	date	by	ckd	description
A	12/21/23	TSR	BAW	ISSUED FOR PERMIT

**ISSUED FOR PERMIT
ONLY**



9400 WARD PARKWAY
KANSAS CITY, MO 64114
816-333-9400
ns & McDonnell Engineering Co, Inc.

date	detailed
04/24/2023	S. JESBERG
designed	checked
T. RENSHAW	B. WINTER

PDX FUEL COMPANY L.L.C


PORTLAND INTERNATIONAL AIRPORT
5000 NE MARINE DR.
PORTLAND, OREGON 97218

PDX FACILITY IMPROVEMENTS
ELECTRICAL DETAILS - 7


project	contract
153929	
drawing	rev.

file 153929E-507.dwg

Millimeters
Inches
Scale For Microfinishing

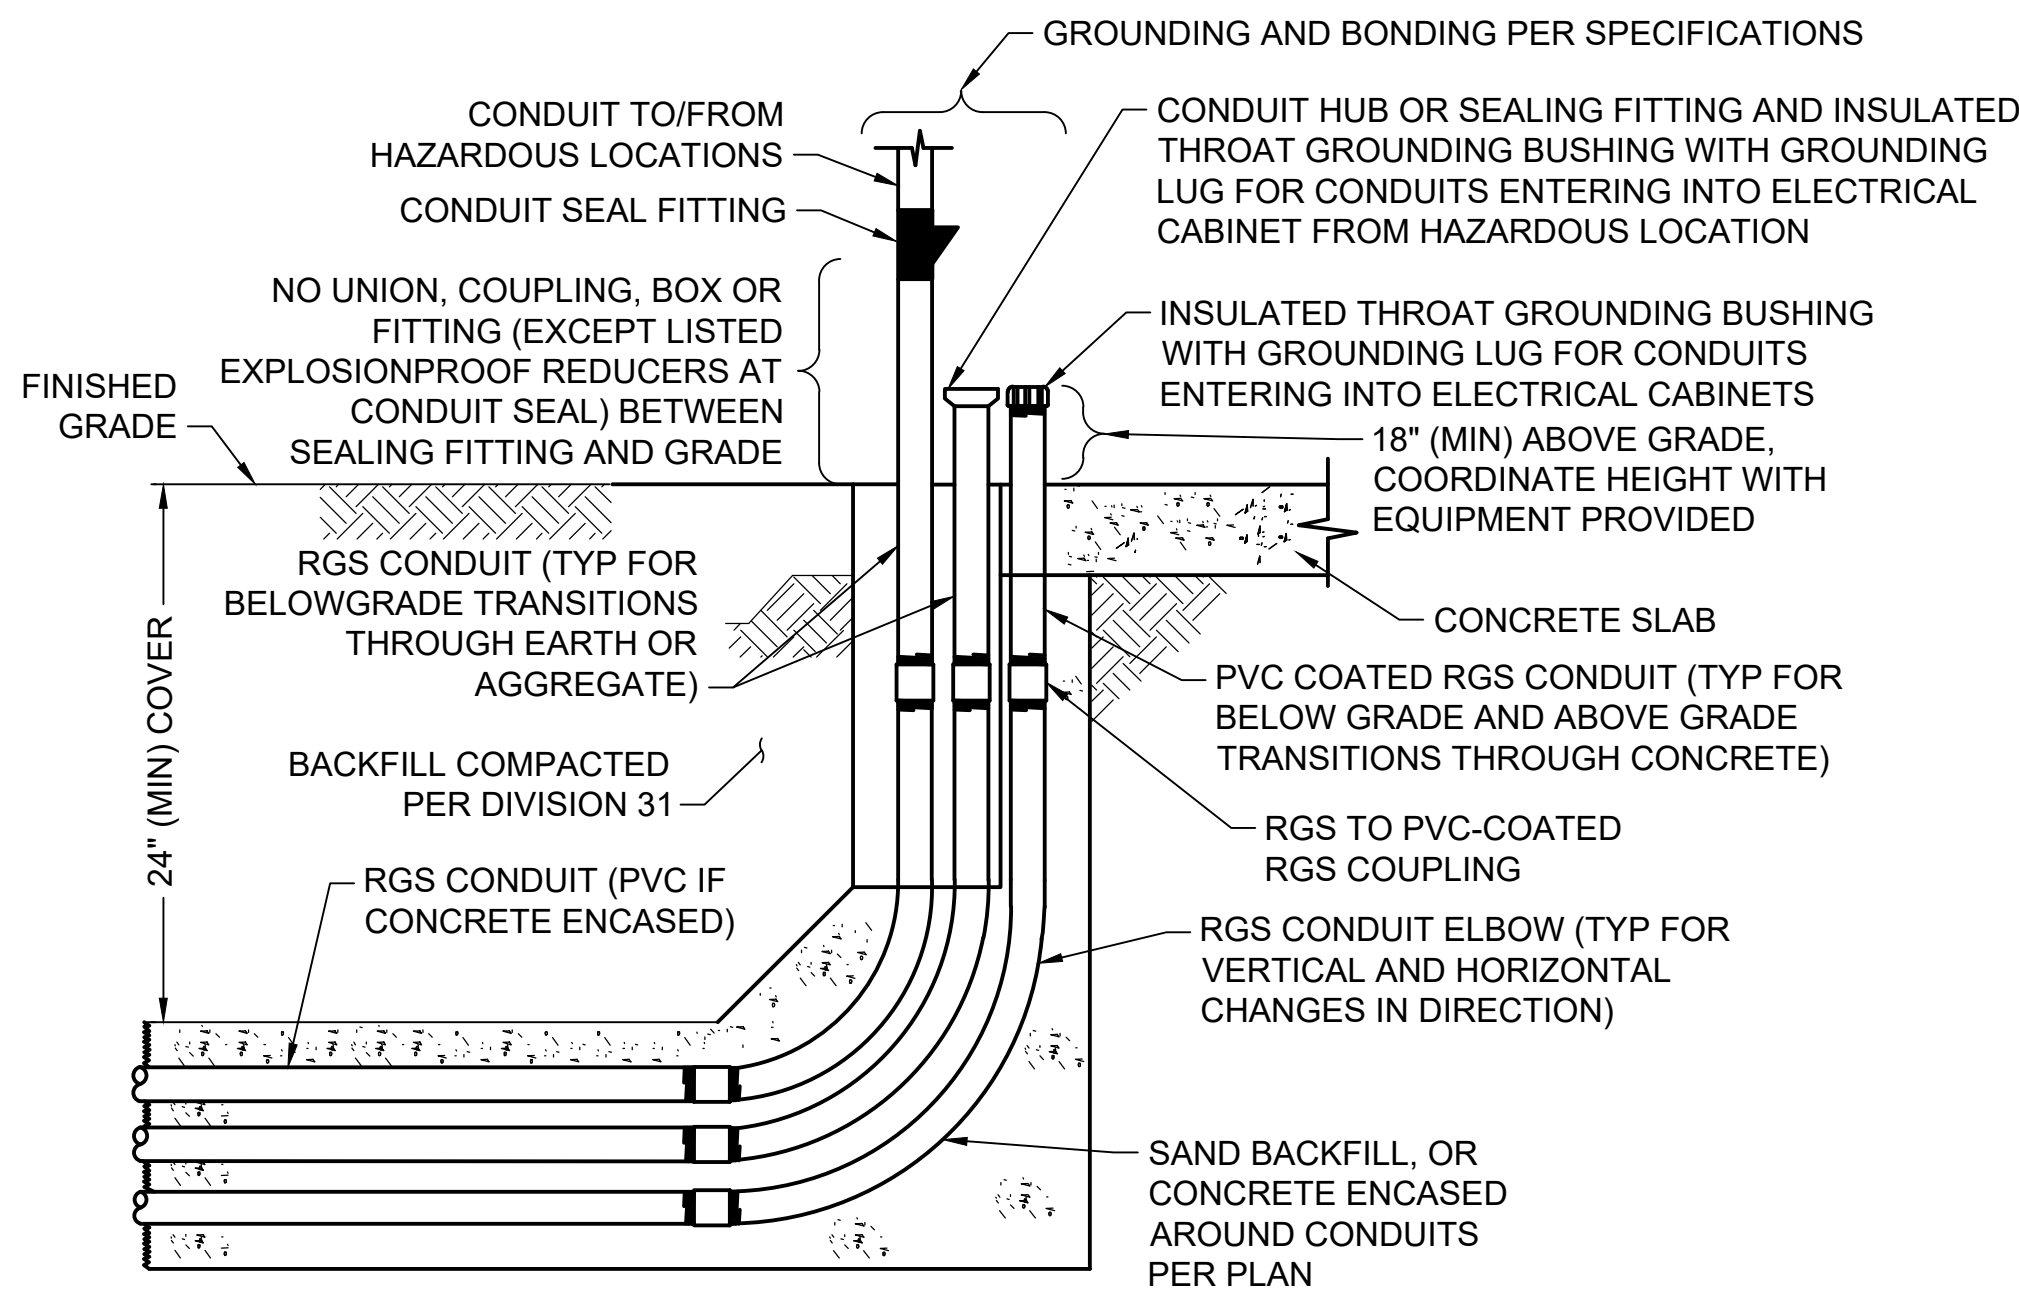


DETAIL
TYPICAL DUCTBANK RISER
NOT TO SCALE

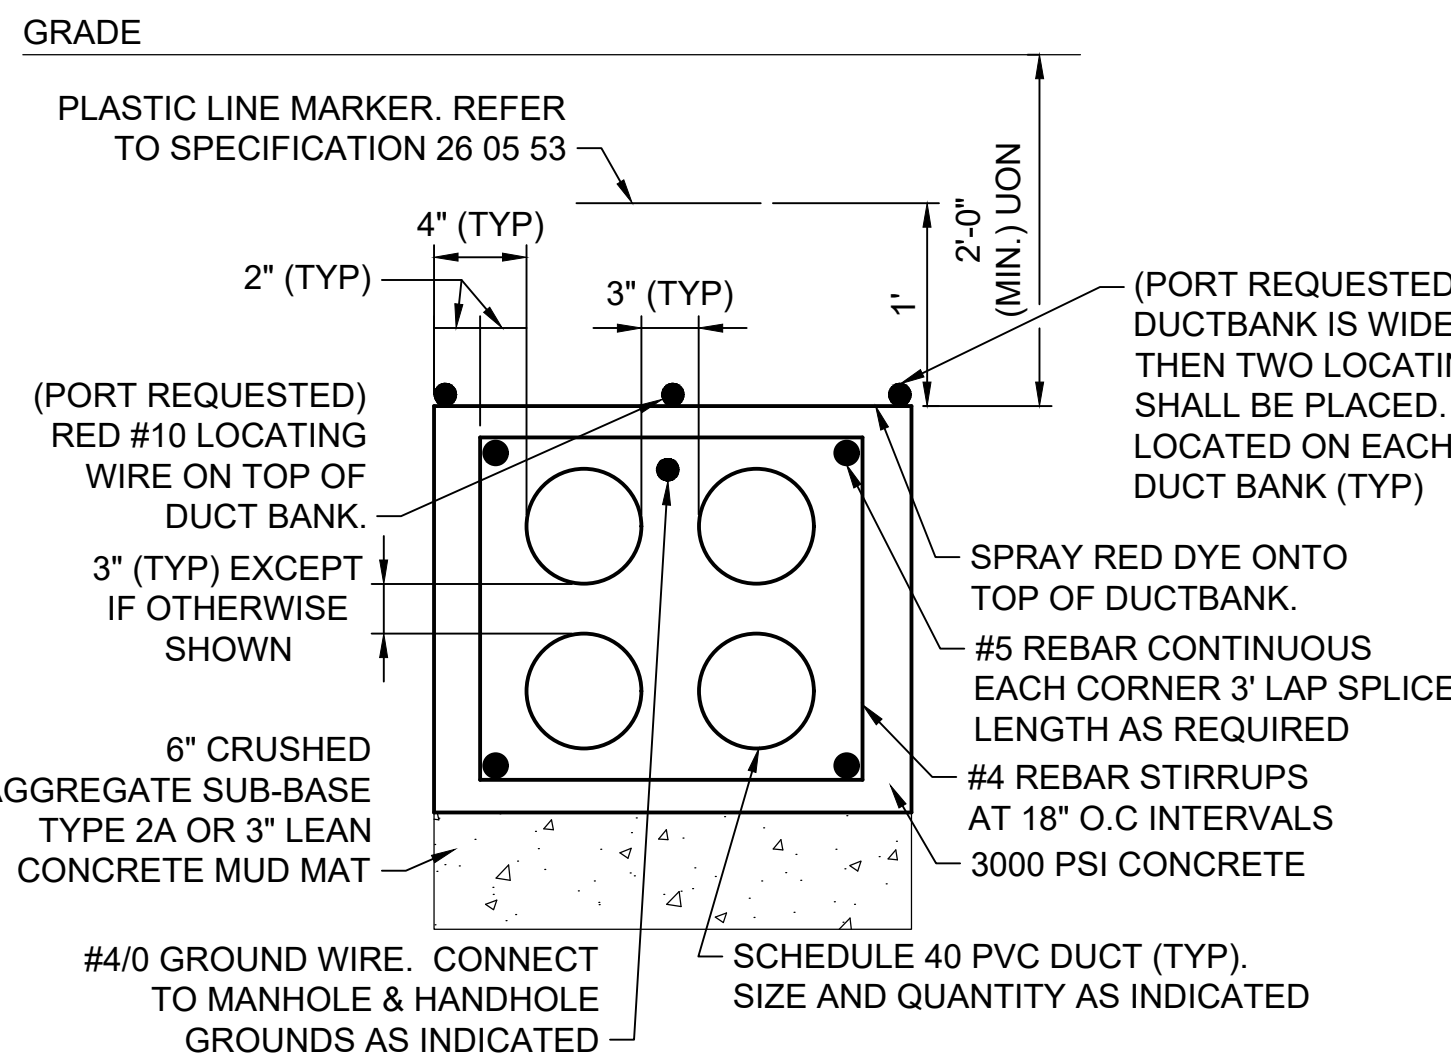


- NOTE:**
1. PROVIDE SIZE AND NUMBER OF CONDUITS AS INDICATED ON PLAN VIEWS OR ON THE DUCTBANK SECTIONS MAINTAINING 4 INCHES OF CONCRETE AROUND THE OUTSIDE CONDUITS AND 3 INCHES BETWEEN CONDUITS.
 2. BACKFILL ONLY AFTER CONCRETE HAS ATTAINED 70% DESIGN STRENGTH.


DETAIL
TYPICAL REINFORCED CONCRETE ENCASED DUCTBANK CONSTRUCTION
NOT TO SCALE

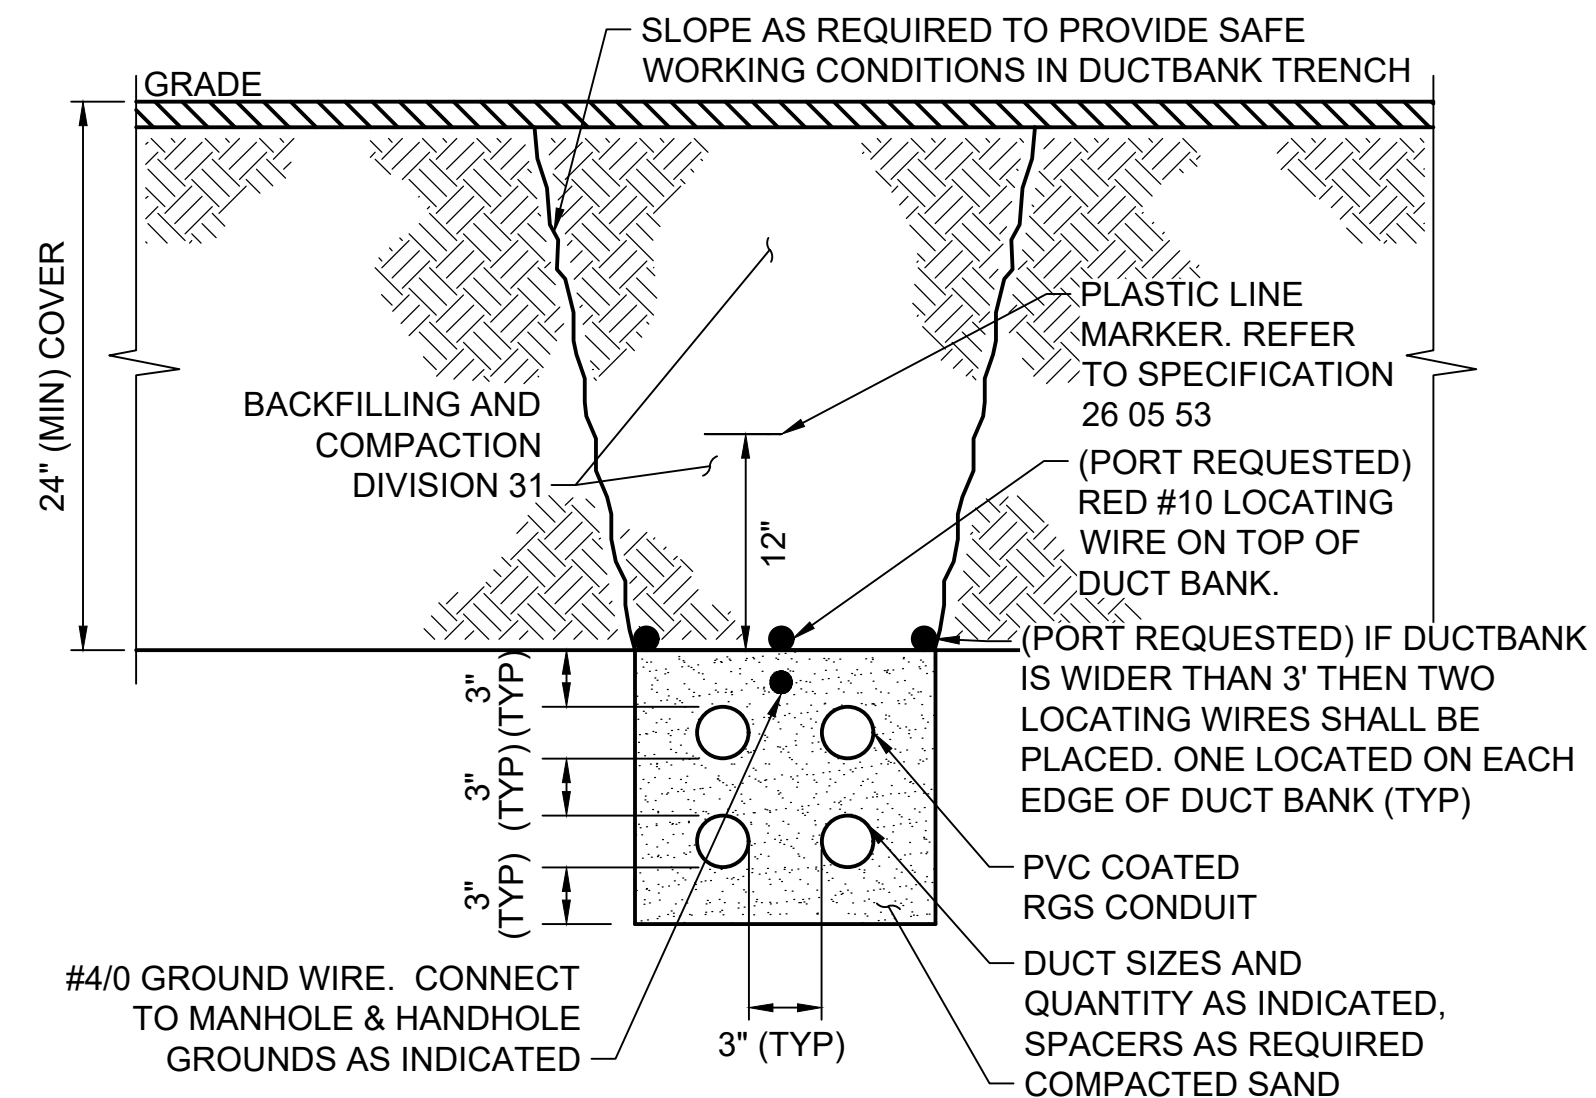


DETAIL
TYPICAL DIRECT BURIED CONDUIT DUCTBANK INSTALLATION DETAIL
NOT TO SCALE

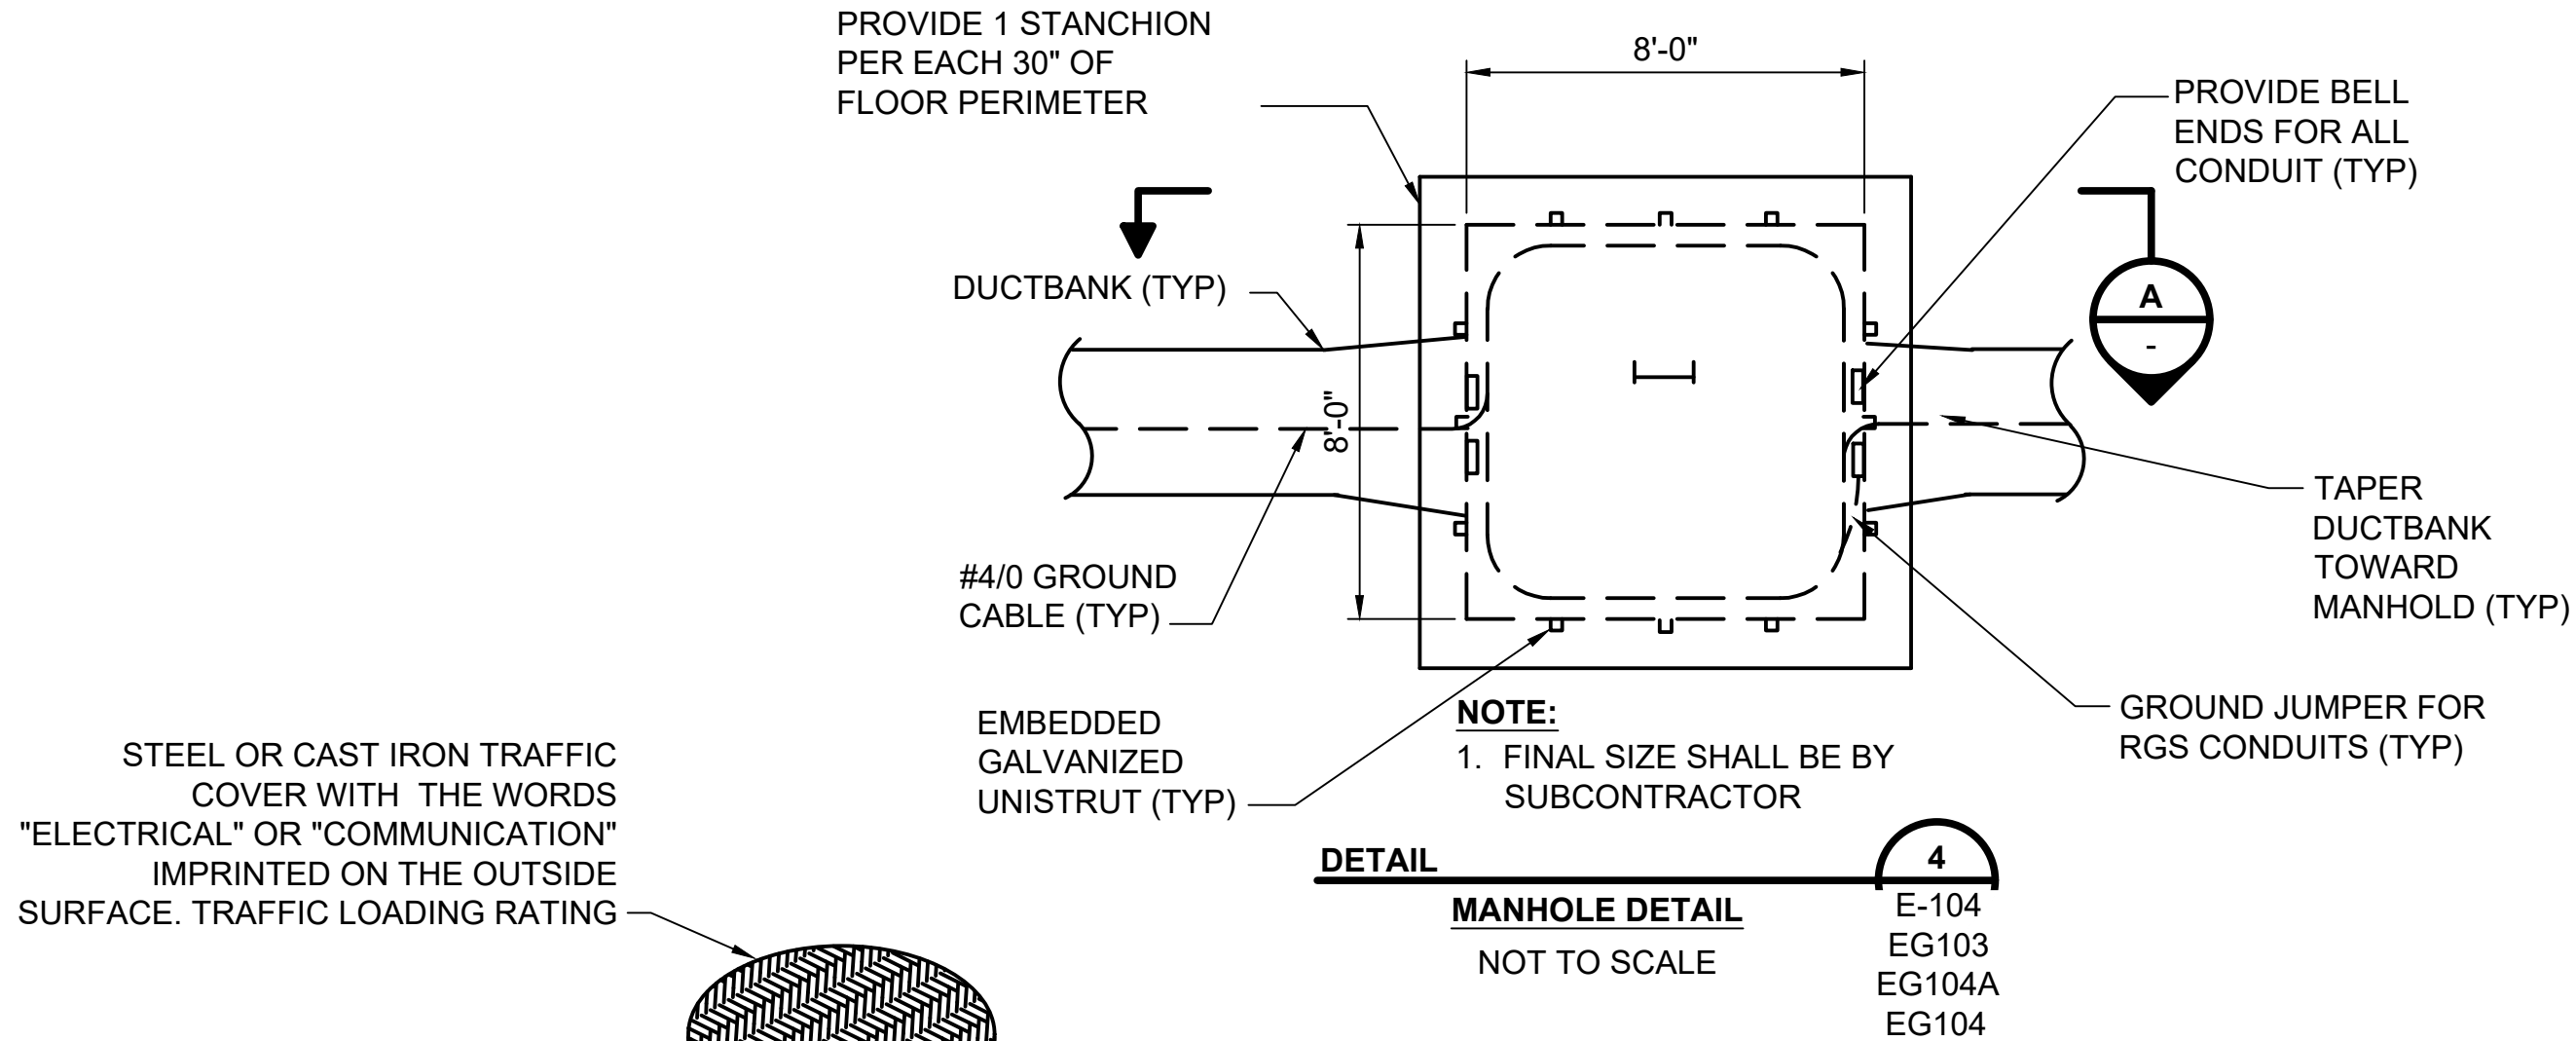


STEEL OR CAST IRON TRAFFIC COVER WITH THE WORDS "ELECTRICAL" OR "COMMUNICATION" IMPRINTED ON THE OUTSIDE SURFACE. TRAFFIC LOADING RATING

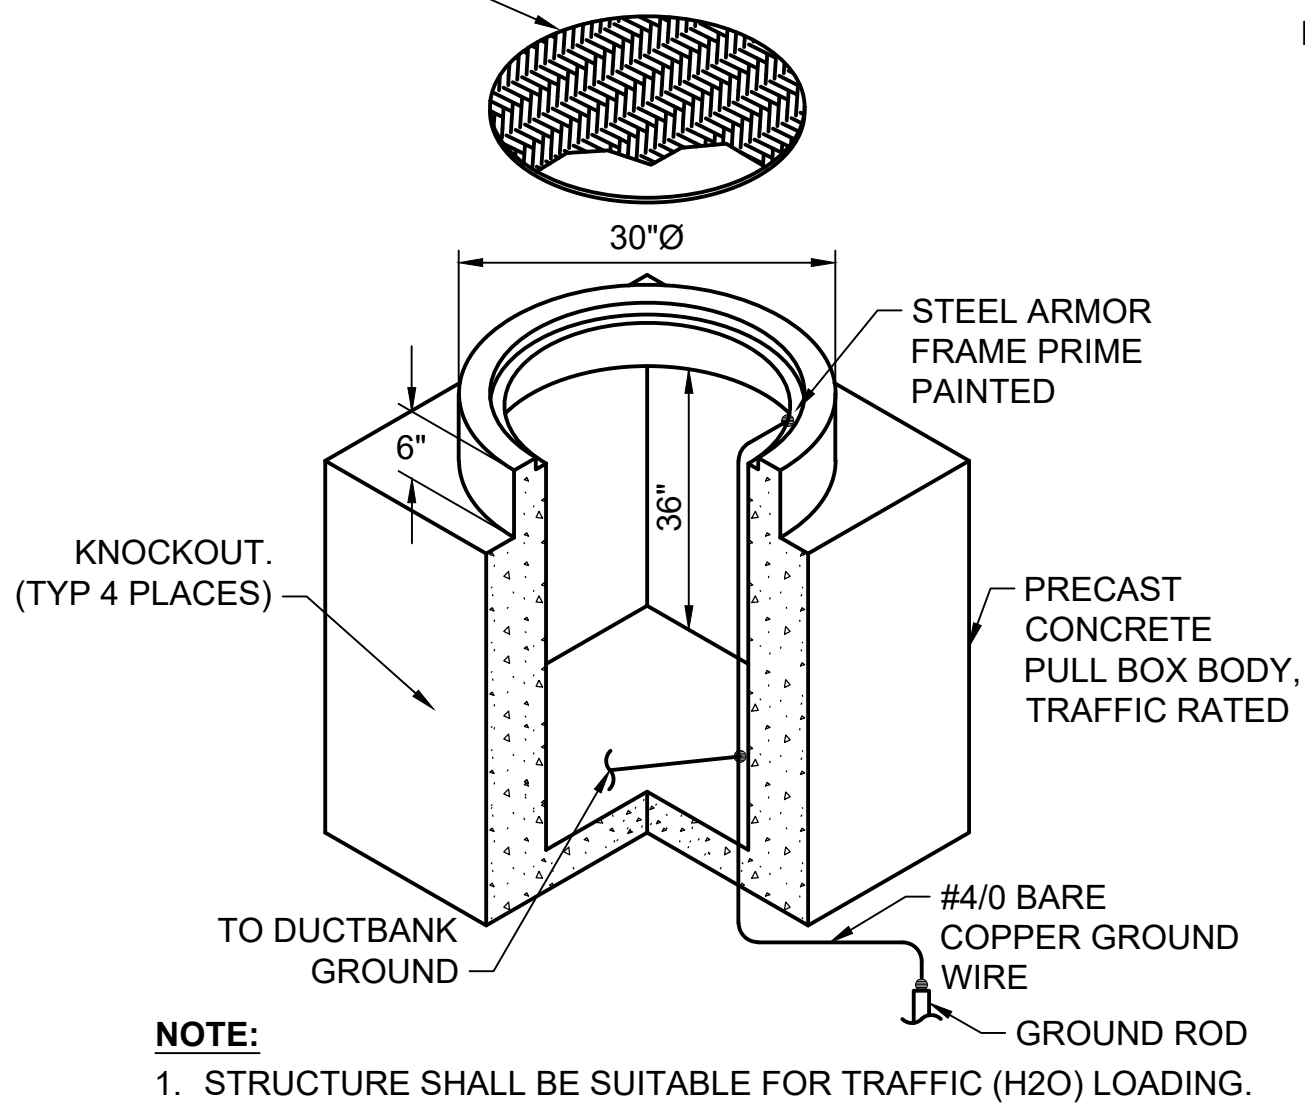

DETAIL
HANDHOLE DETAIL
NOT TO SCALE

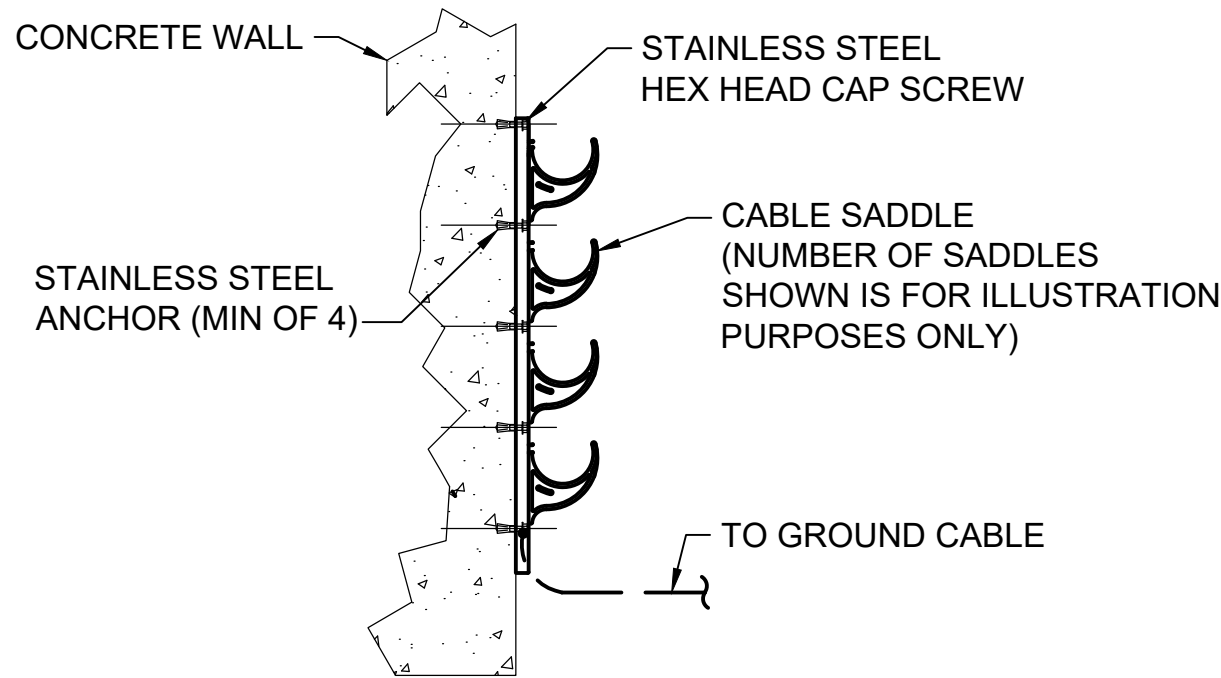

DETAIL
TYPICAL HANDHOLE CABLE RACK DETAIL
NOT TO SCALE

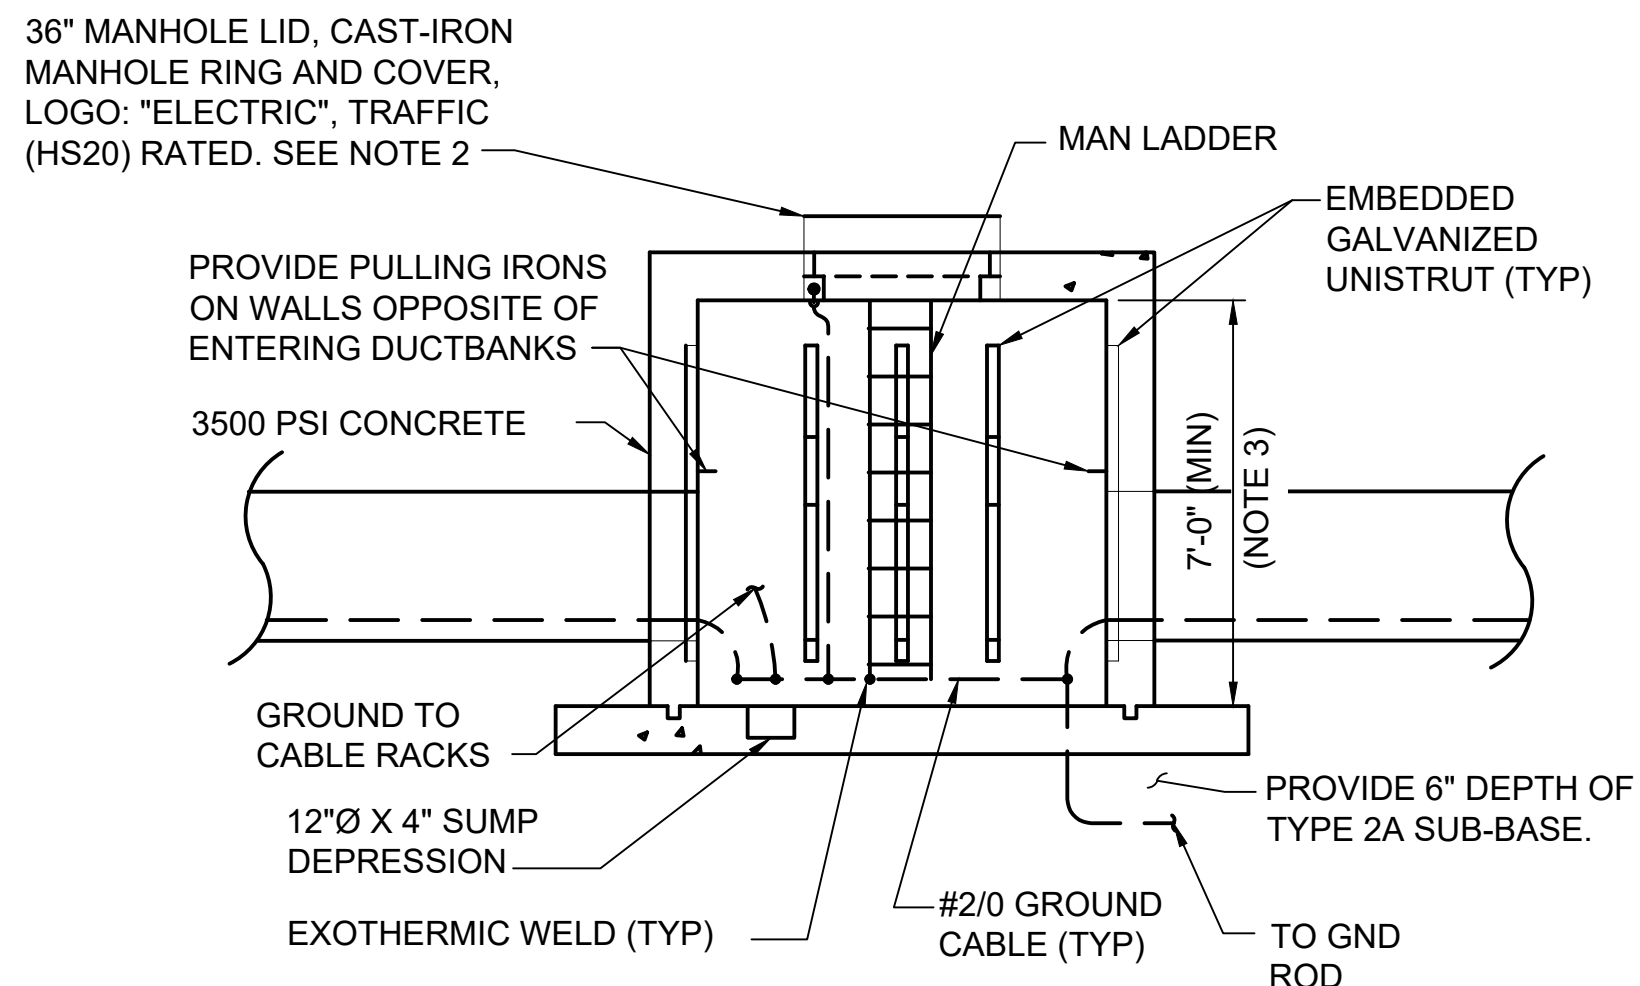

- NOTES:**
1. STRUCTURE SHALL BE DESIGNED FOR TRAFFIC (HS20) LOADING AS WELL AS LOADING CRITERIA ON S-001 AND BUOYANCY CONDITIONS WITH WATER AT GRADE. SUBMIT SEALED DESIGN CALCULATIONS AND SHOP DRAWINGS BY STRUCTURAL ENGINEER FOR APPROVAL.
 2. PROVIDE RISER AS REQUIRED TO ENSURE ENTIRE MANHOLE CONCRETE TOP IS AT GRADE OR BELOW. SEE CIVIL DRAWINGS FOR MORE INFORMATION ON ELEVATIONS OF MANHOLE TOPS AND RISERS.
 3. SEE CIVIL DRAWINGS FOR ACTUAL DEPTH.
 4. PROVIDE 3 PULLING EYES.
 5. MAINTAIN SPACING BETWEEN POWER AND CONTROL CIRCUITS. SEE SPECS AND DUCTBANK CROSS SECTIONS FOR DIMENSIONS.
 6. DESIGN STRUCTURES TO BE WATERTIGHT. SEE DIVISION 7 FOR EXTERIOR WATERPROOFING.

SECTION
TYPICAL MANHOLE DETAIL
NOT TO SCALE

12/20/2023

no.	date	by	ckd	description
A	12/21/23	TSR	BAW	ISSUED FOR PERMIT

ISSUED FOR PERMIT ONLY

**BURNS
McDONNELL**

9400 WARD PARKWAY
KANSAS CITY, MO 64114
816-333-9400
Burns & McDonnell Engineering Co., Inc.

date	detailed
04/24/2023	S. JESBERG
designed	checked
T. RENSHAW	B. WINTER


PDX FUEL COMPANY L.L.C

PORTLAND INTERNATIONAL AIRPORT
5000 NE MARINE DR.
PORTLAND, OREGON 97218

**PDX FACILITY IMPROVEMENTS
ELECTRICAL DETAILS - 8**

project	contract
153929	
drawing	rev.
E-508	A


file 153929E-508.dwg

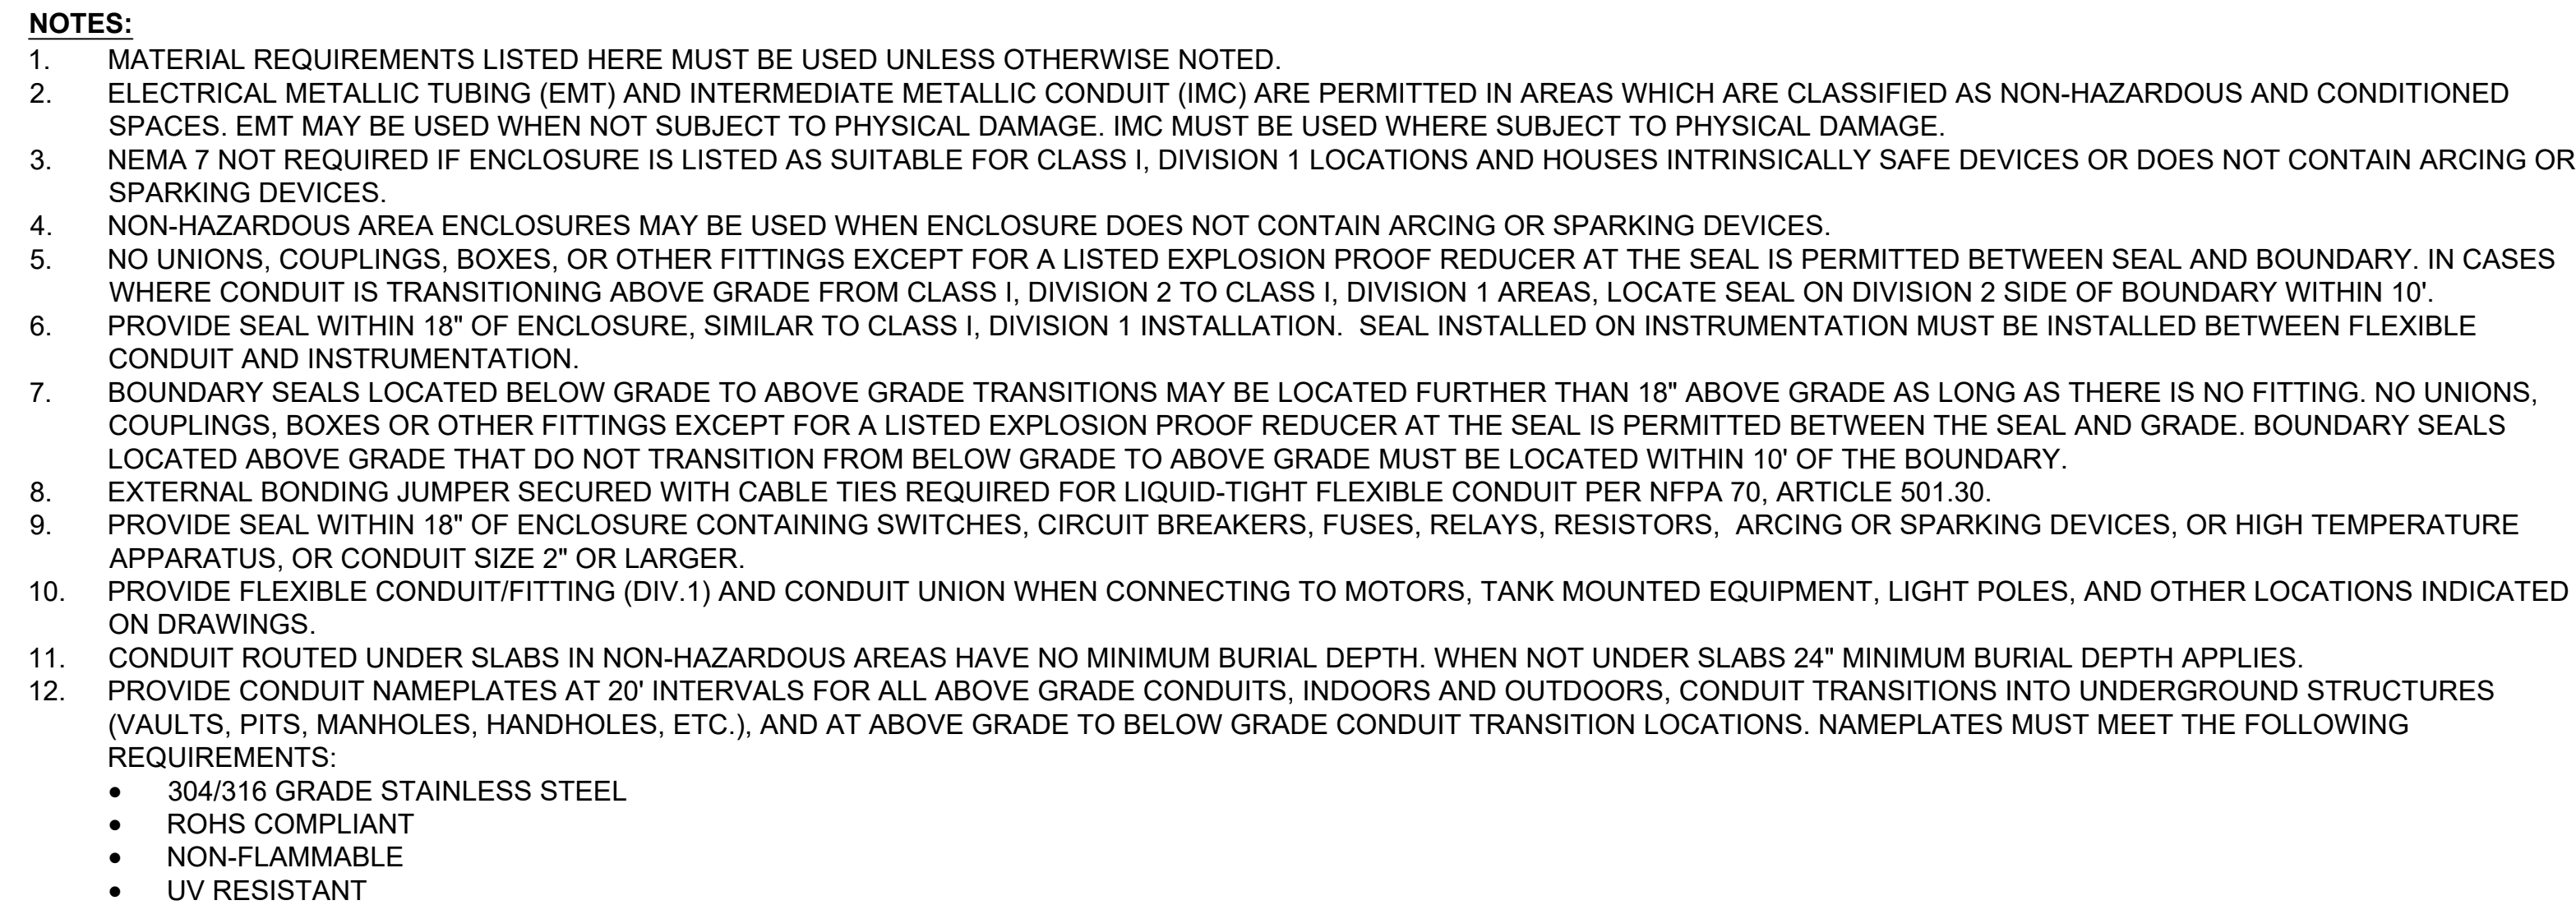

NOT TO SCALE


project	contract
153929	
drawing	rev.
E-510	A
file 153929E-510.dwg	

Millimeters
Scale For Microfilming
Inches

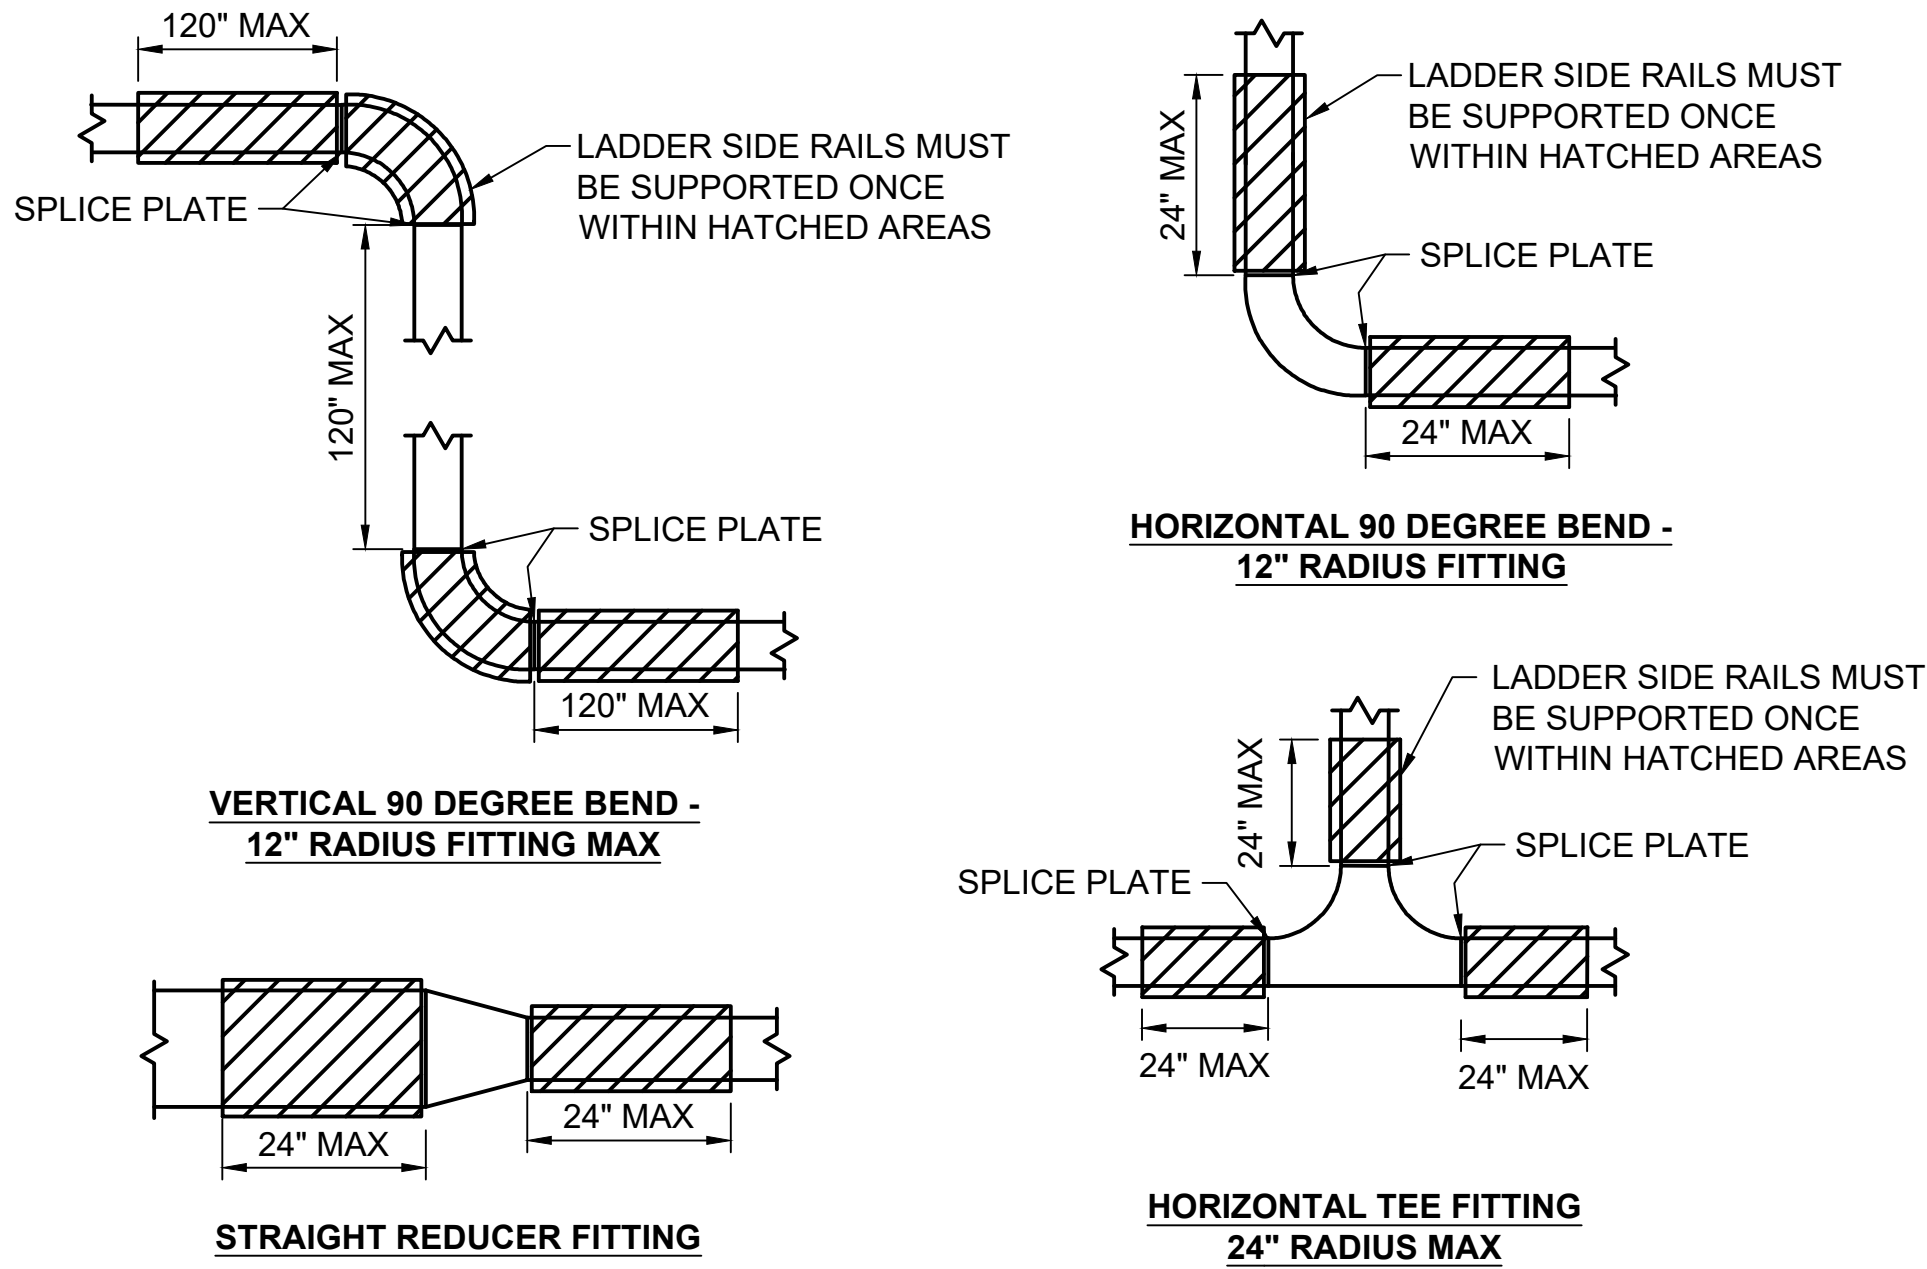


- NOTES:**
1. BASIS OF DESIGN IS BASED ON RECOMMENDED B-LINE SUPPORT LOCATIONS.
 2. PROVIDE SUPPORT FOR EVERY CABLE TRAY VERTICAL/HORIZONTAL TRANSITION AND BEND PER NEMA VE-2 OR RECOMMENDED MANUFACTURER SUPPORT LOCATIONS. PROVIDE SUPPORT ON STRAIGHT RUNS AT MAXIMUM 20' INTERVALS. SEE STRUCTURAL DRAWINGS FOR TYPICAL CABLE TRAY SUPPORT.

DETAIL 1
CABLE TRAY FITTING SUPPORT LOCATIONS
NOT TO SCALE

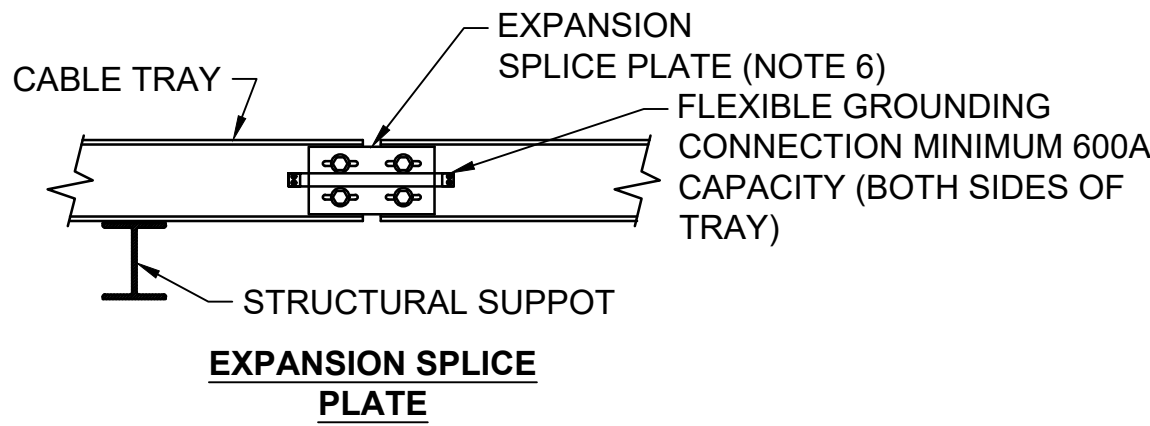


- NOTES:**
1. BOLTS SHALL BE INSERTED FROM INSIDE THE TRAY.
 2. ALL CONNECTIONS SHALL BE MADE WRENCH TIGHT.
 3. PAINT OR OTHER NON-CONDUCTIVE COATING SHALL BE REMOVED AT THE POINT OF CONTACT, OR A FASTENER THAT WILL PENETRATE THE COATING SHALL BE USED.
 4. ALL CONNECTIONS SHALL BE COATED WITH ANTI-OXIDANT COMPOUND.
 5. USE MATERIALS NOT SUBJECT TO CORROSION FROM THE ENVIRONMENT OR APPLICATION.
 6. EXPANSION SPLICE PLATE TO OCCUR EVERY 52' ON STRAIGHT RUNS. SET GAP PER NEMA VE 2, FIGURE 4.13B.

DETAIL 2
CABLE TRAY SPLICE PLATE
NOT TO SCALE

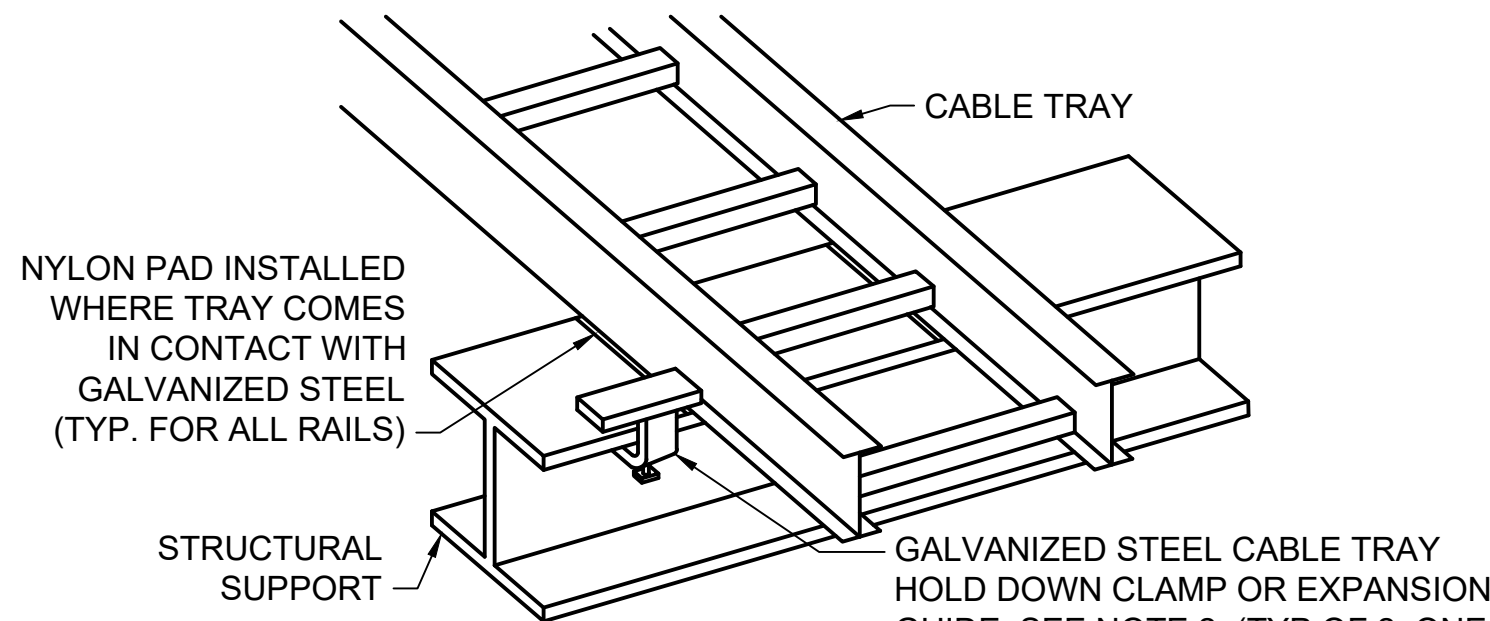


- NOTES:**
1. REFER TO STRUCTURAL DRAWINGS FOR SUPPORT AND FOUNDATION DETAILS AND ELEVATIONS.
 2. INSTALL CABLE TRAY HOLD DOWN CLAMP AND EXPANSION GUIDES PER NEMA VE-2.

DETAIL 3
CABLE TRAY HOLD DOWN CLAMP
NOT TO SCALE

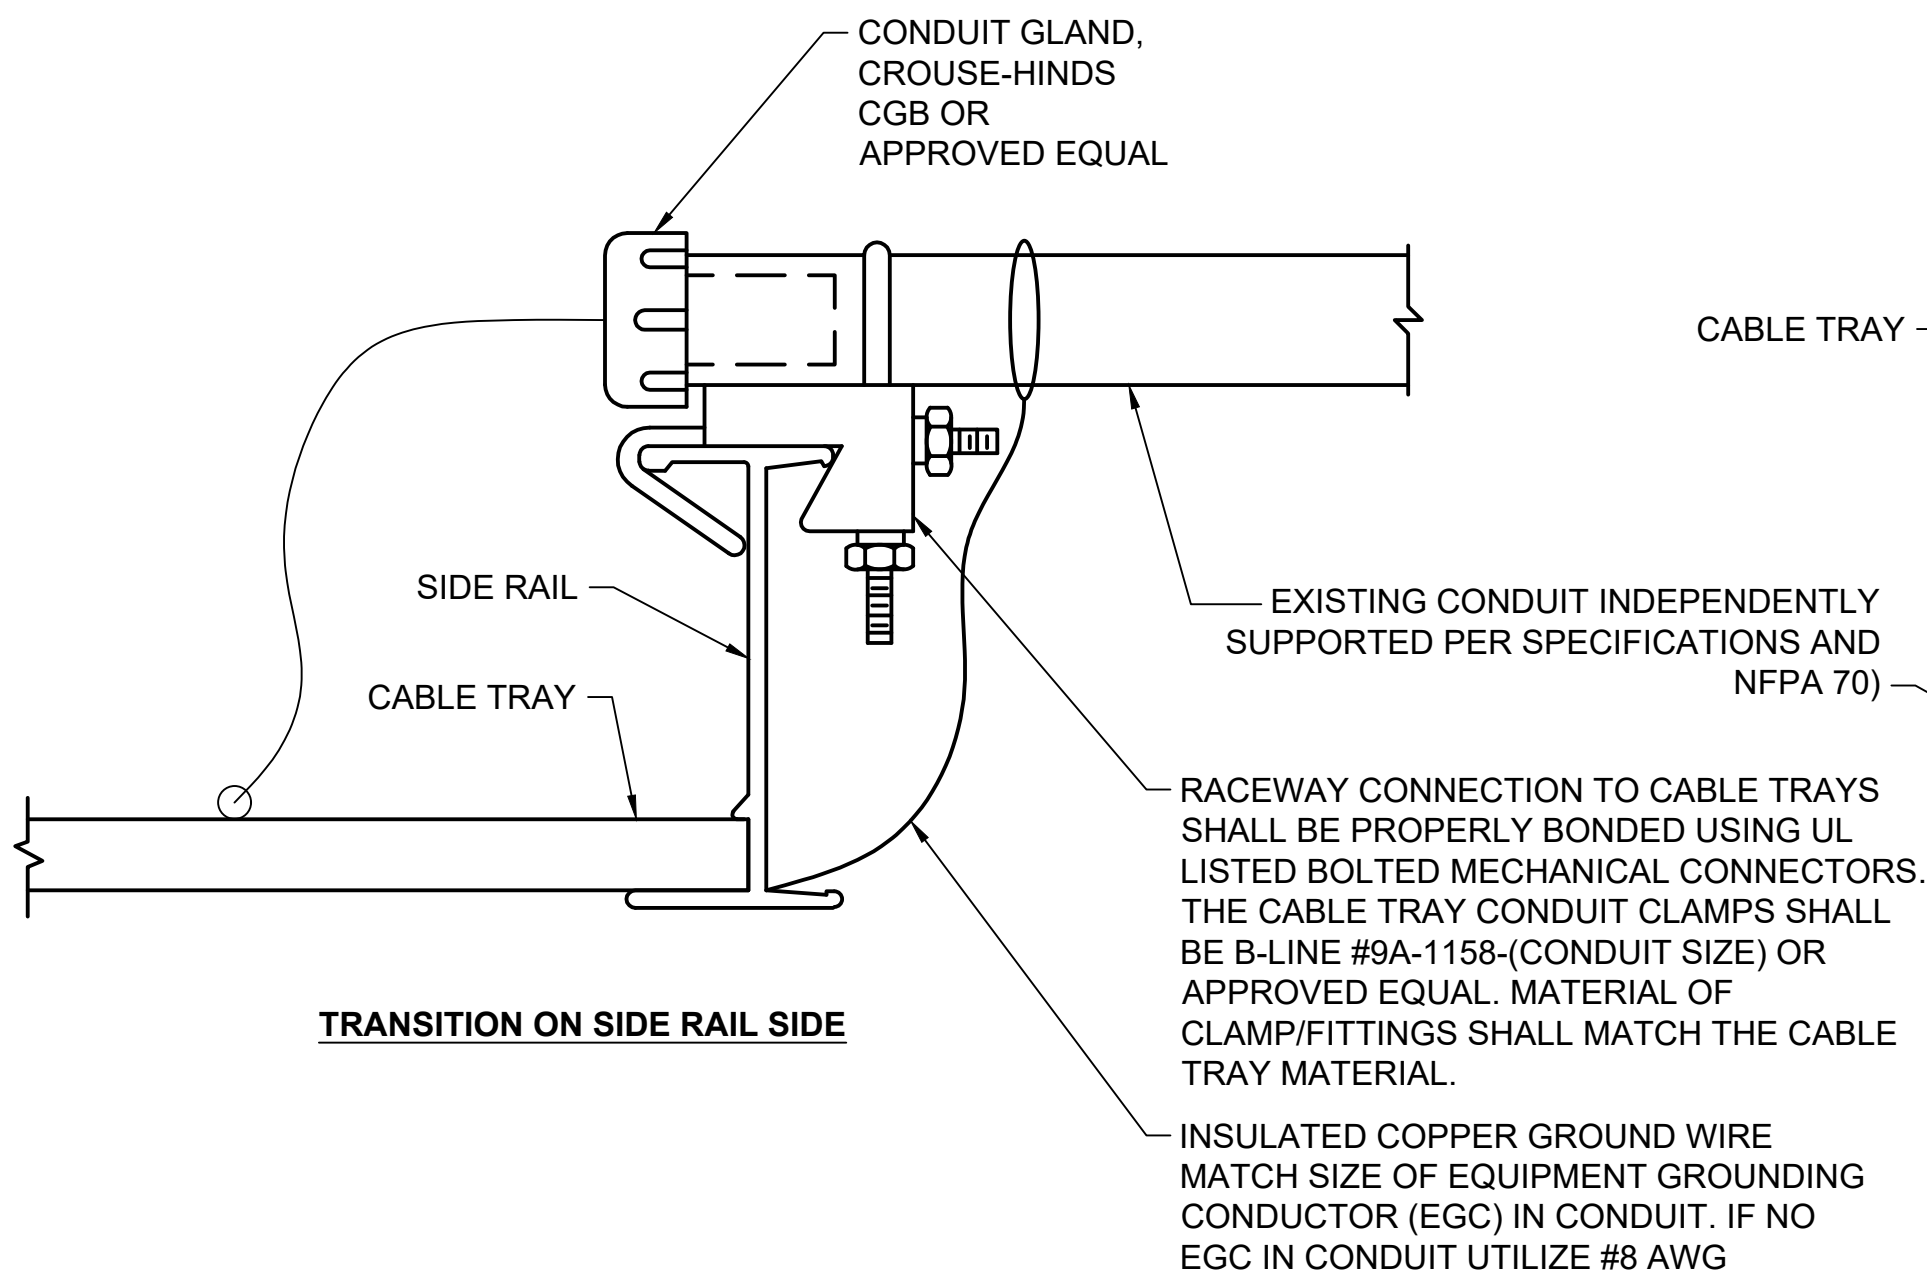


TRANSITION ON SIDE RAIL SIDE

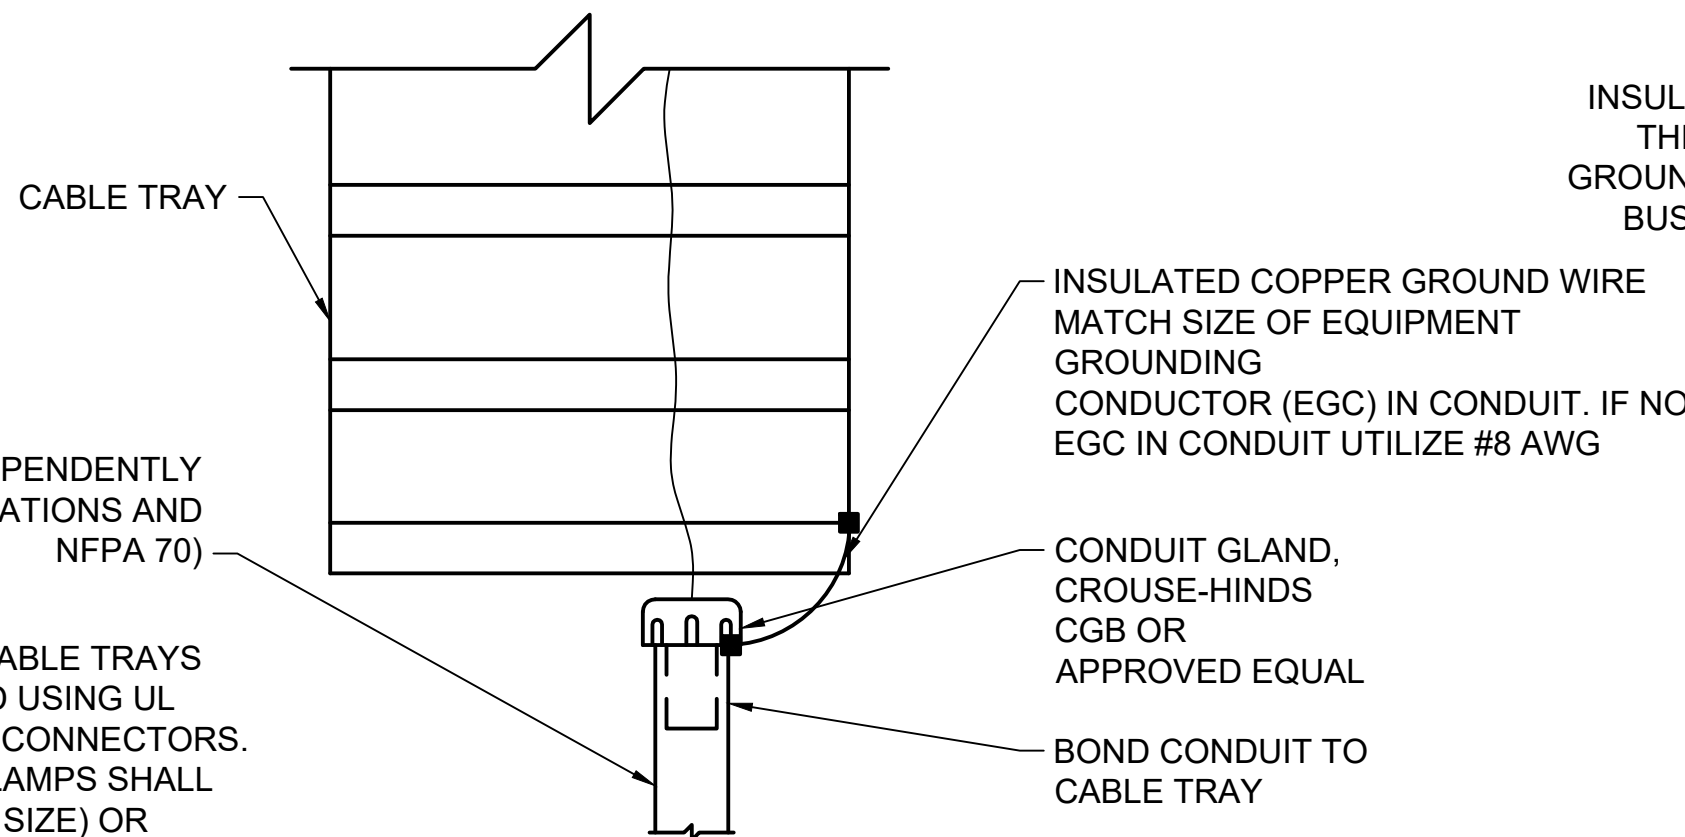

TRANSITION ON CABLE TRAY END

DETAIL 4
CONDUIT TO CABLE TRAY TRANSITION
NOT TO SCALE

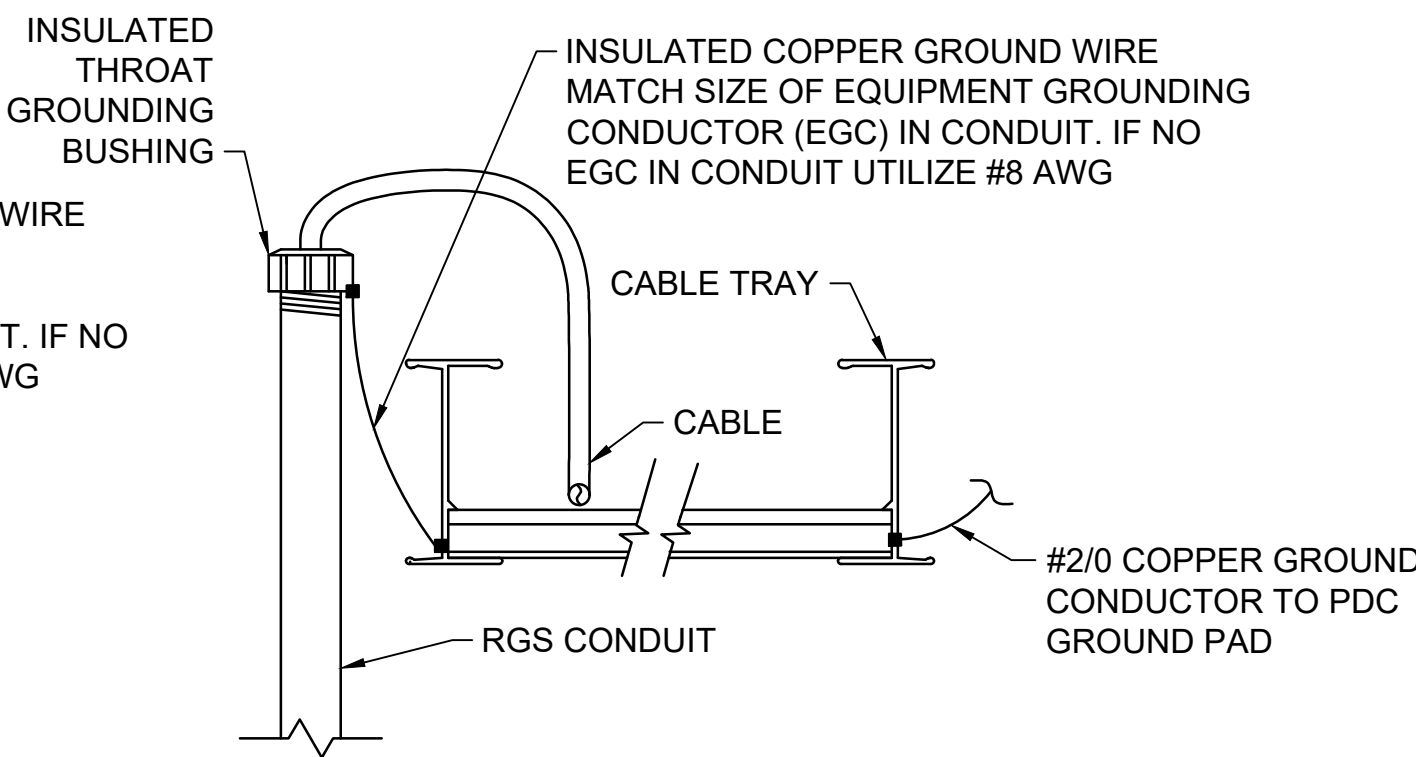

CABLE TO CONDUIT TRANSITION (INSIDE PDC)

12/20/2023

no.	date	by	ckd	description
A	12/21/23	TSR	BAW	ISSUED FOR PERMIT

ISSUED FOR PERMIT ONLY

BURNS MEDONNELL

9400 WARD PARKWAY
KANSAS CITY, MO 64114
816-333-9400
Burns & McDonnell Engineering Co., Inc.

date	04/24/2023	detailed	S. JESBERG
designed	T. RENSHAW	checked	B. WINTER


PDX FUEL COMPANY L.L.C

PORTLAND INTERNATIONAL AIRPORT
5000 NE MARINE DR.
PORTLAND, OREGON 97218

PDX FACILITY IMPROVEMENTS
ELECTRICAL DETAILS - 11


project	153929	contract	
drawing	E-511	rev.	A

file 153929E-511.dwg

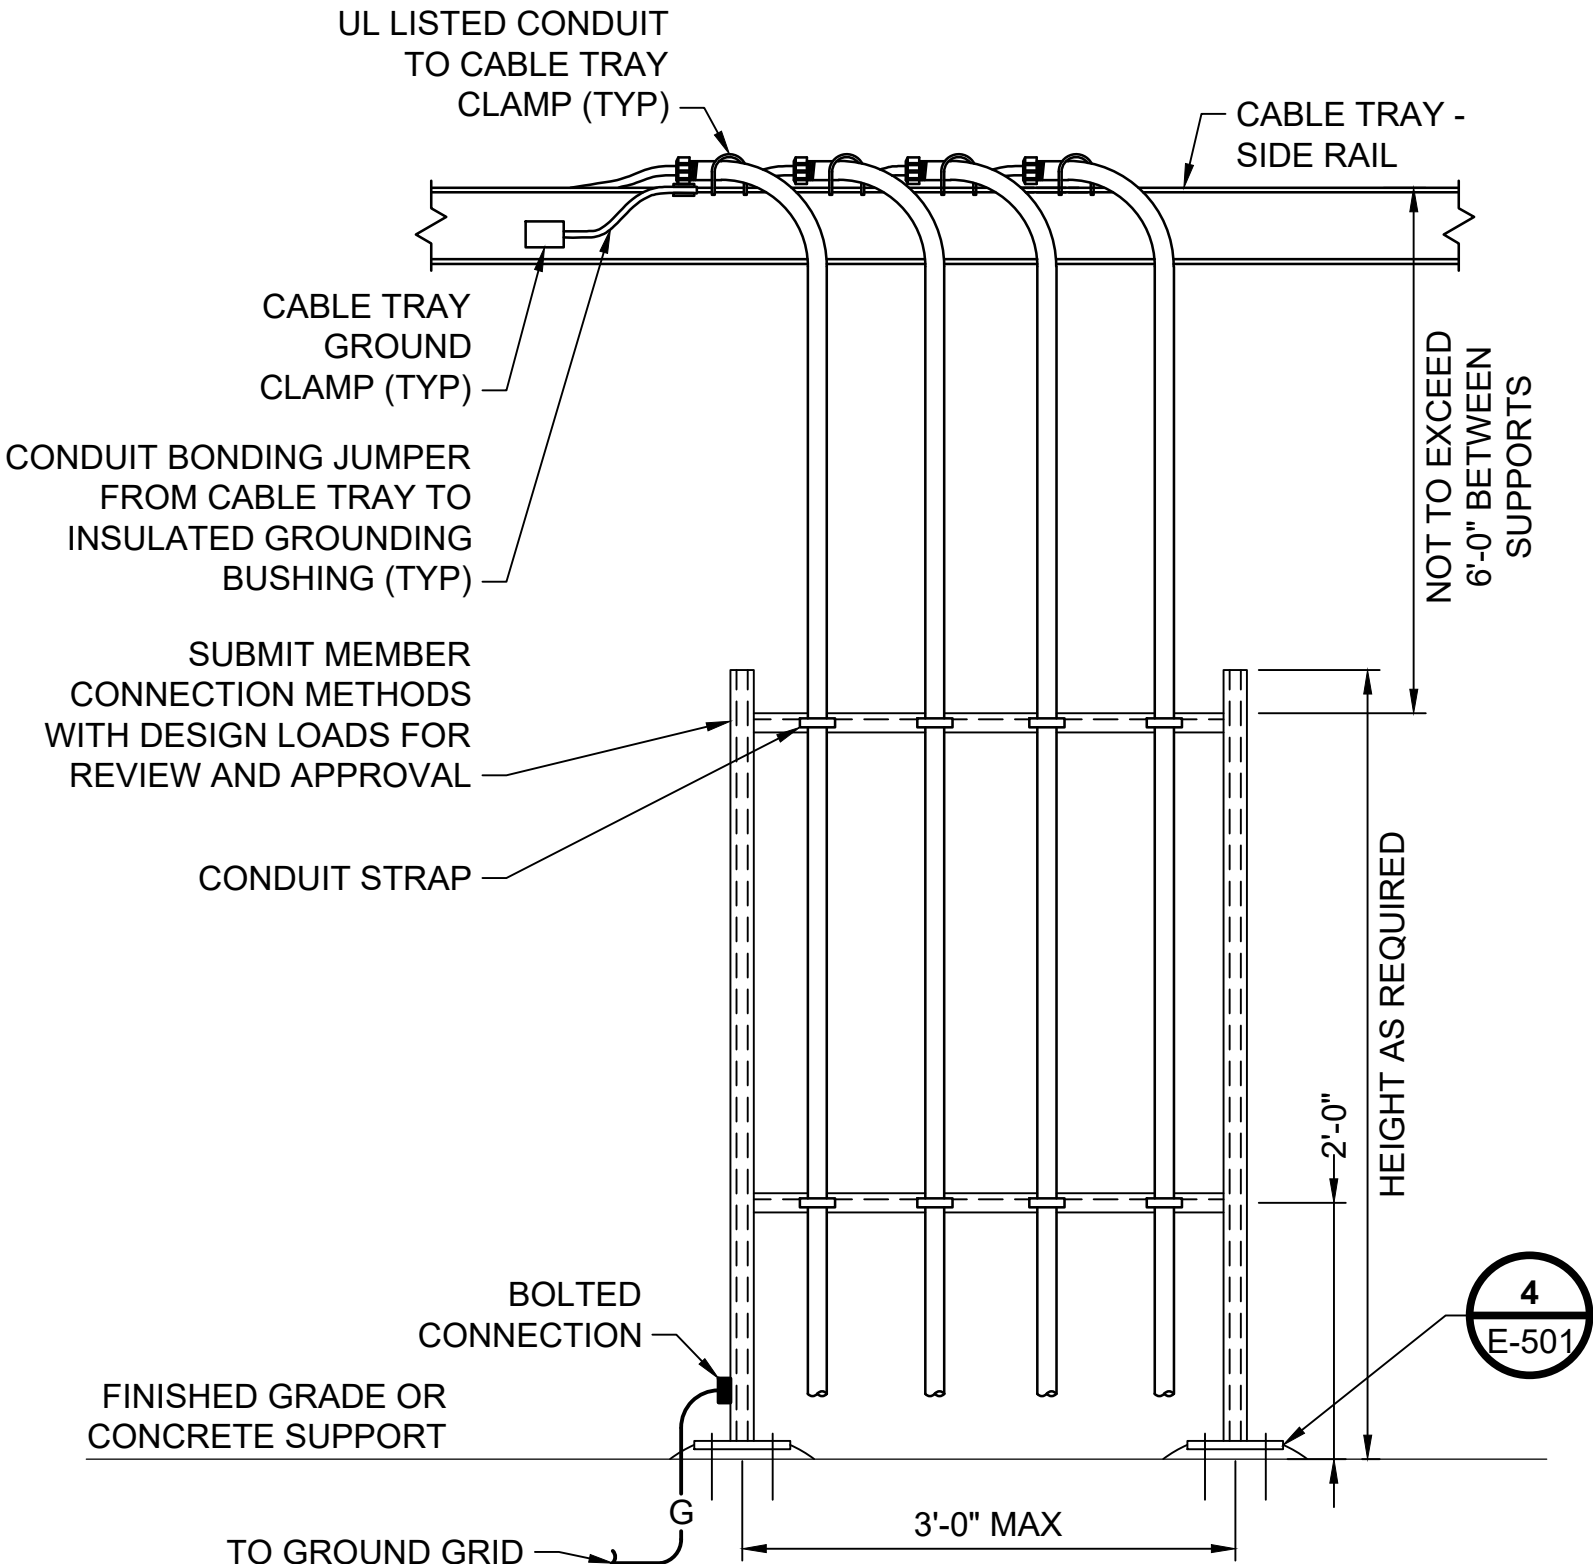


- NOTES:**
1. PROVIDE ADDITIONAL VERTICAL AND HORIZONTAL STRUTS AS NEEDED TO SUPPORT THE QUANTITY OF CONDUITS AND CABLES TO CABLE TRAY.
 2. WHERE CONCRETE FOUNDATIONS ARE UNAVAILABLE, ANCHOR/SUPPORT FROM CONCRETE PIERS SIMILAR TO DETAIL 4 ON SHEET E-501.
 3. DETAIL SPECIFICALLY SHOWS CONDUIT QUANTITIES FOR PUMP TRAIN CIRCUITS. FOR OTHER USES, RUN CONDUIT QUANTITIES AS NEEDED.


DETAIL 1
CABLE TRAY TO STRUCTURAL RACK DETAIL
NOT TO SCALE

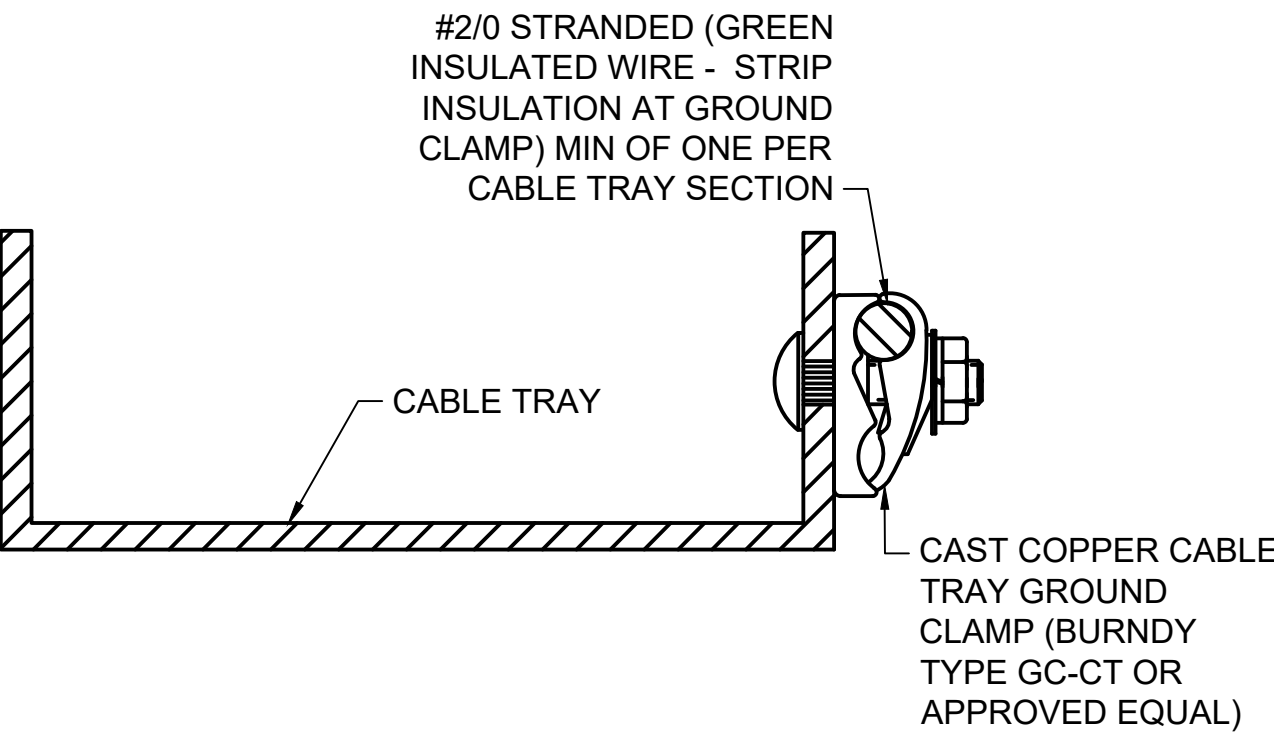

DETAIL 4
CABLE TRAY GROUNDING CLAMP
NOT TO SCALE

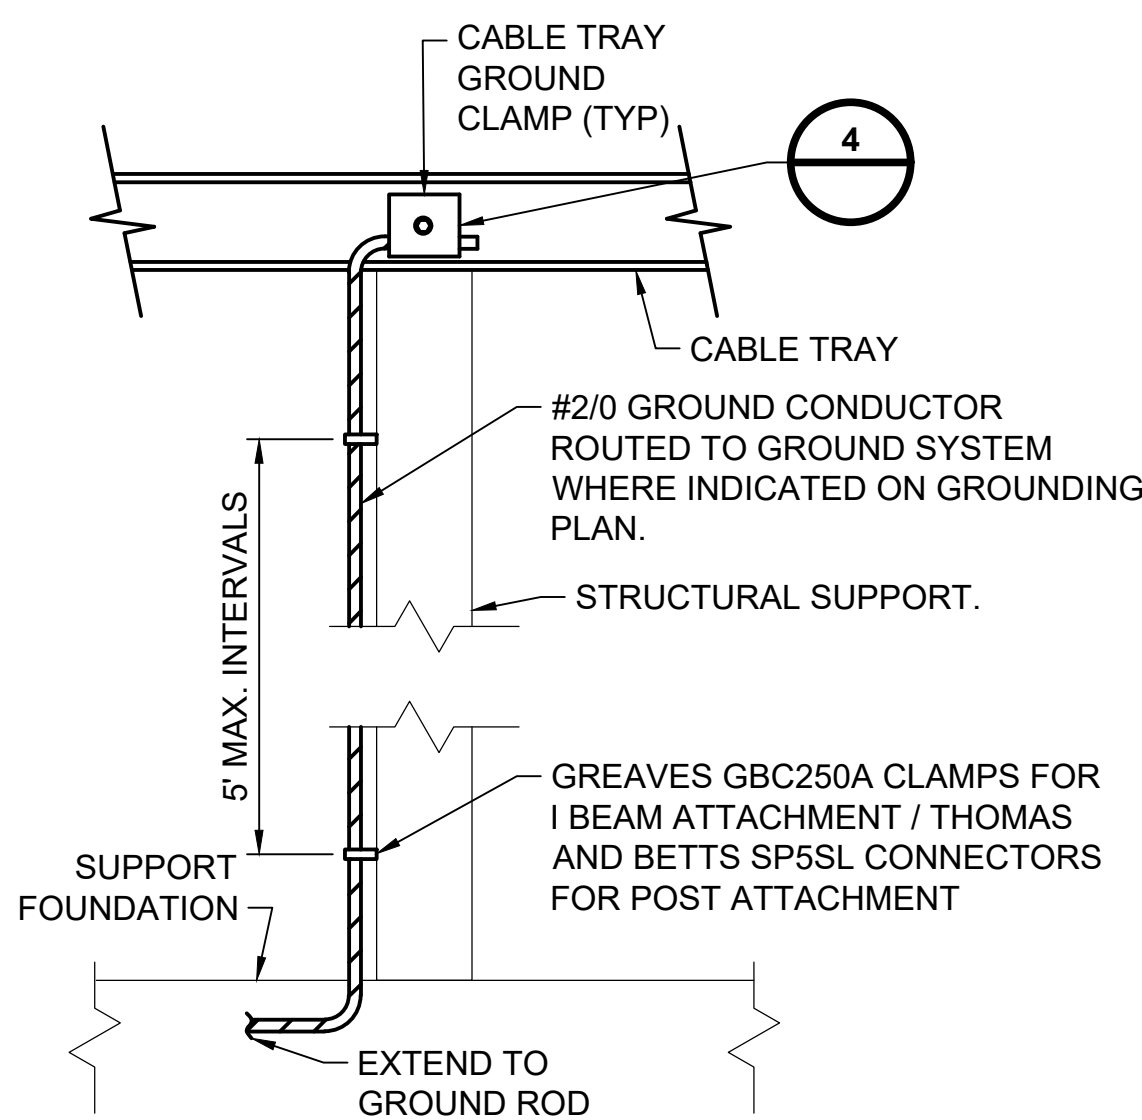

DETAIL 2
CABLE TRAY GROUNDING DETAIL
NOT TO SCALE

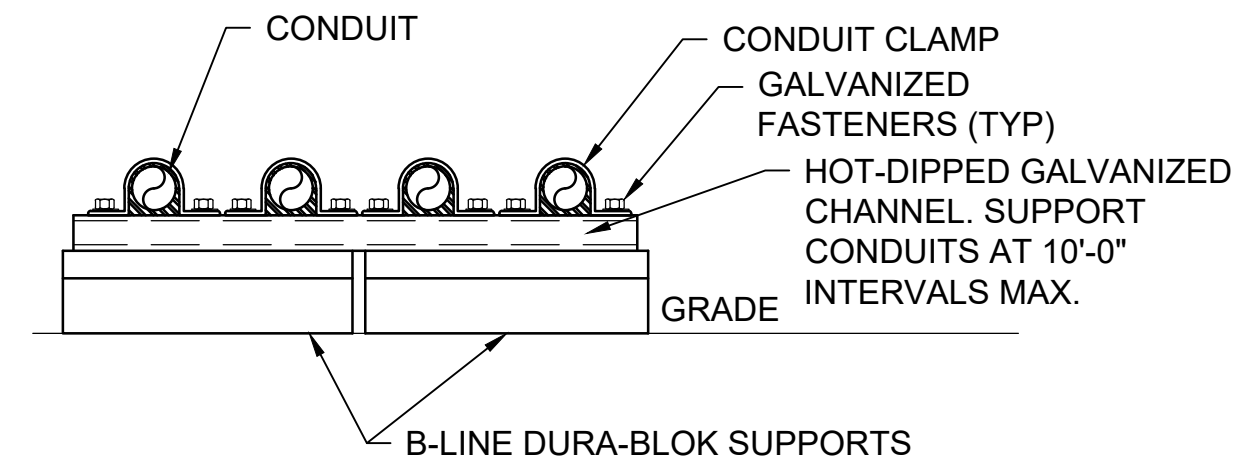

- NOTE:**
1. PROVIDE CONDUIT SUPPORT INSIDE TANK CONTAINMENT AREA AS REQUIRED. SUPPORT CONDUIT AT A MAXIMUM OF 10' INTERVALS BETWEEN SUPPORT LOCATIONS. PROVIDE SUPPORTS IN MANNER ALLOWING CONDUIT TO BE INSTALLED FLAT.

DETAIL 3
TANK AREA CONDUIT SUPPORT
NOT TO SCALE

Millimeters

Scale For Microfilming

Inches

12/20/2023

no.	date	by	ckd	description
A	12/21/23	TSR	BAW	ISSUED FOR PERMIT

ISSUED FOR PERMIT ONLY

BURNS McDONNELL
9400 WARD PARKWAY
KANSAS CITY, MO 64114
816-333-9400
Burns & McDonnell Engineering Co., Inc.

date	04/24/2023	detailed	S. JESBERG
designed	T. RENSHAW	checked	B. WINTER


PDX FUEL COMPANY L.L.C

PORTLAND INTERNATIONAL AIRPORT
5000 NE MARINE DR.
PORTLAND, OREGON 97218

PDX FACILITY IMPROVEMENTS
ELECTRICAL DETAILS - 12

project	153929	contract	
drawing	E-512	rev.	A

file 153929E-512.dwg

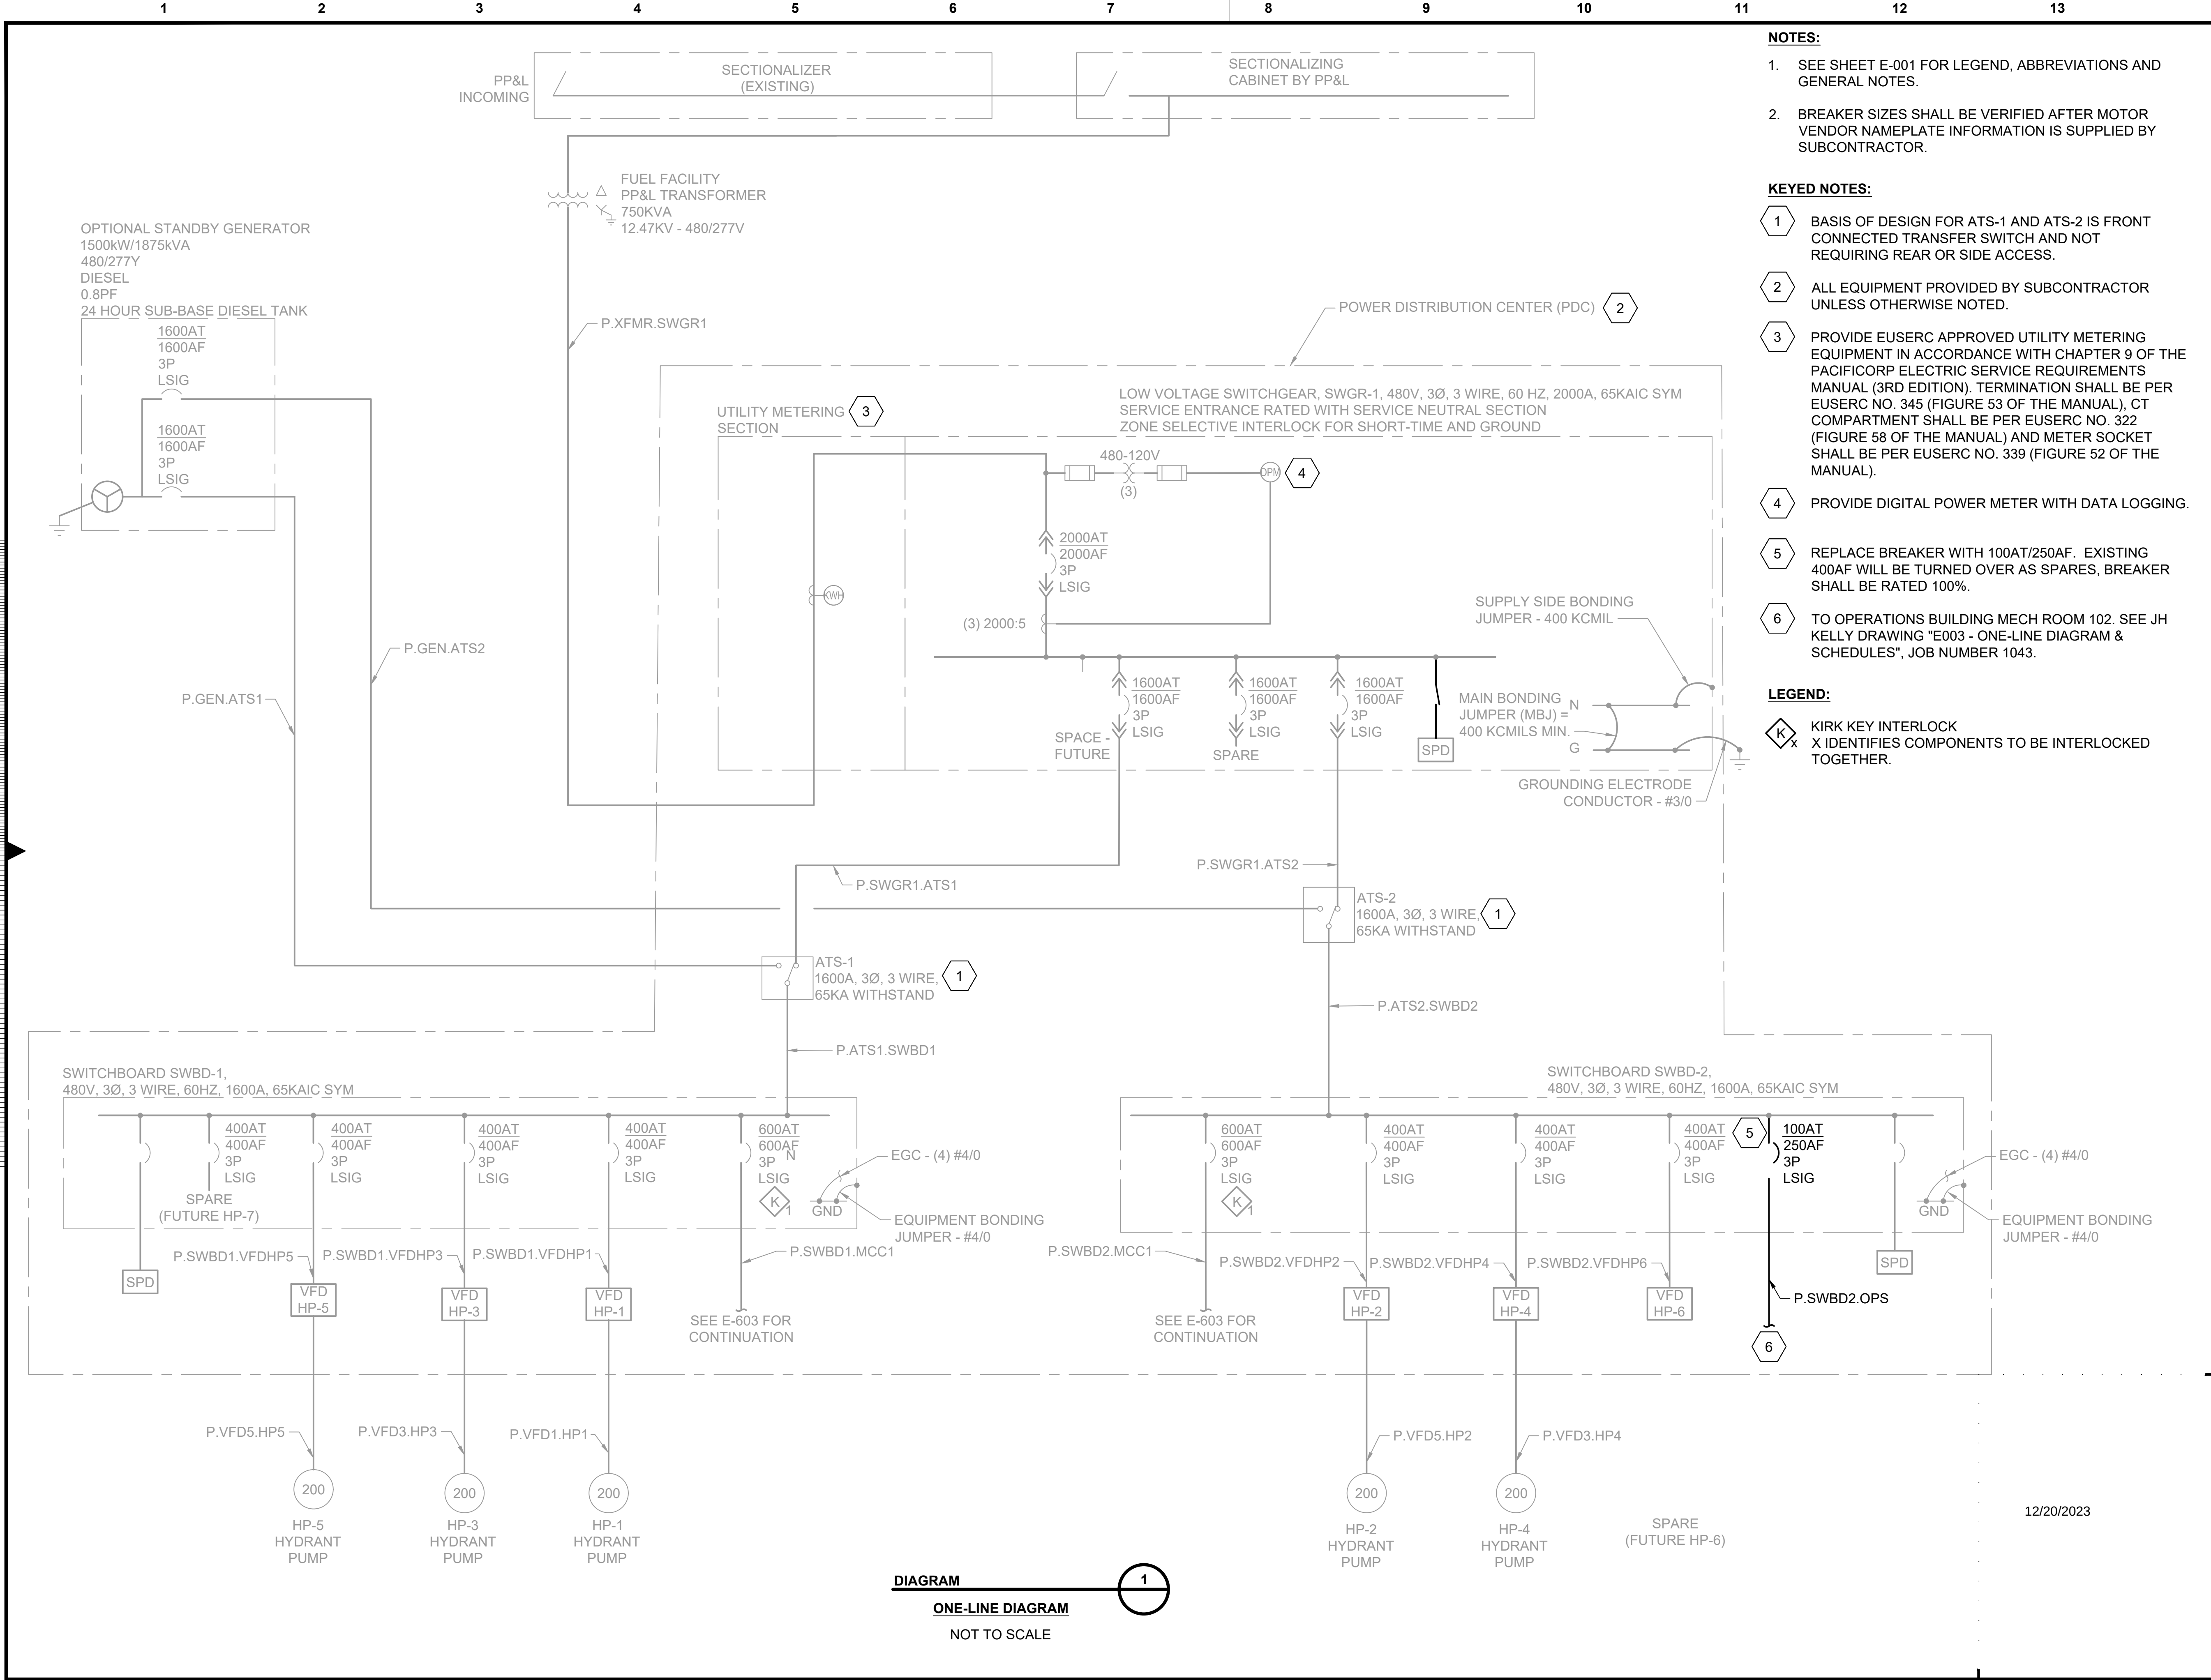

- NOTES:**
- SEE SHEET E-001 FOR LEGEND, ABBREVIATIONS AND GENERAL NOTES.
 - BREAKER SIZES SHALL BE VERIFIED AFTER MOTOR VENDOR NAMEPLATE INFORMATION IS SUPPLIED BY SUBCONTRACTOR.
- KEYED NOTES:**
- BASIS OF DESIGN FOR ATS-1 AND ATS-2 IS FRONT CONNECTED TRANSFER SWITCH AND NOT REQUIRING REAR OR SIDE ACCESS.
 - ALL EQUIPMENT PROVIDED BY SUBCONTRACTOR UNLESS OTHERWISE NOTED.
 - PROVIDE EUSERC APPROVED UTILITY METERING EQUIPMENT IN ACCORDANCE WITH CHAPTER 9 OF THE PACIFICORP ELECTRIC SERVICE REQUIREMENTS MANUAL (3RD EDITION). TERMINATION SHALL BE PER EUSERC NO. 345 (FIGURE 53 OF THE MANUAL), CT COMPARTMENT SHALL BE PER EUSERC NO. 322 (FIGURE 58 OF THE MANUAL) AND METER SOCKET SHALL BE PER EUSERC NO. 339 (FIGURE 52 OF THE MANUAL).
 - PROVIDE DIGITAL POWER METER WITH DATA LOGGING.
 - REPLACE BREAKER WITH 100AT/250AF. EXISTING 400AF WILL BE TURNED OVER AS SPARES, BREAKER SHALL BE RATED 100%.
 - TO OPERATIONS BUILDING MECH ROOM 102. SEE JH KELLY DRAWING "E003 - ONE-LINE DIAGRAM & SCHEDULES", JOB NUMBER 1043.

- LEGEND:**
- KIRK KEY INTERLOCK
X IDENTIFIES COMPONENTS TO BE INTERLOCKED TOGETHER.

no.	date	by	ckd	description
A	12/21/23	TSR	BAW	ISSUED FOR PERMIT

ISSUED FOR PERMIT
ONLY



9400 WARD PARKWAY
KANSAS CITY, MO 64114
816-333-9400
Burns & McDonnell Engineering Co., Inc.

date	04/24/2023	detailed	S. JESBERG
designed	T. RENSHAW	checked	B. WINTER

PDX FUEL COMPANY L.L.C


PORTLAND INTERNATIONAL AIRPORT
5000 NE MARINE DR.
PORTLAND, OREGON 97218

PDX FACILITY IMPROVEMENTS
ONE-LINE DIAGRAM - 1

project	153929	contract	
drawing	E-602	rev.	A

file 153929E-602.dwg

Millimeters
Scale For Microfinning
Inches

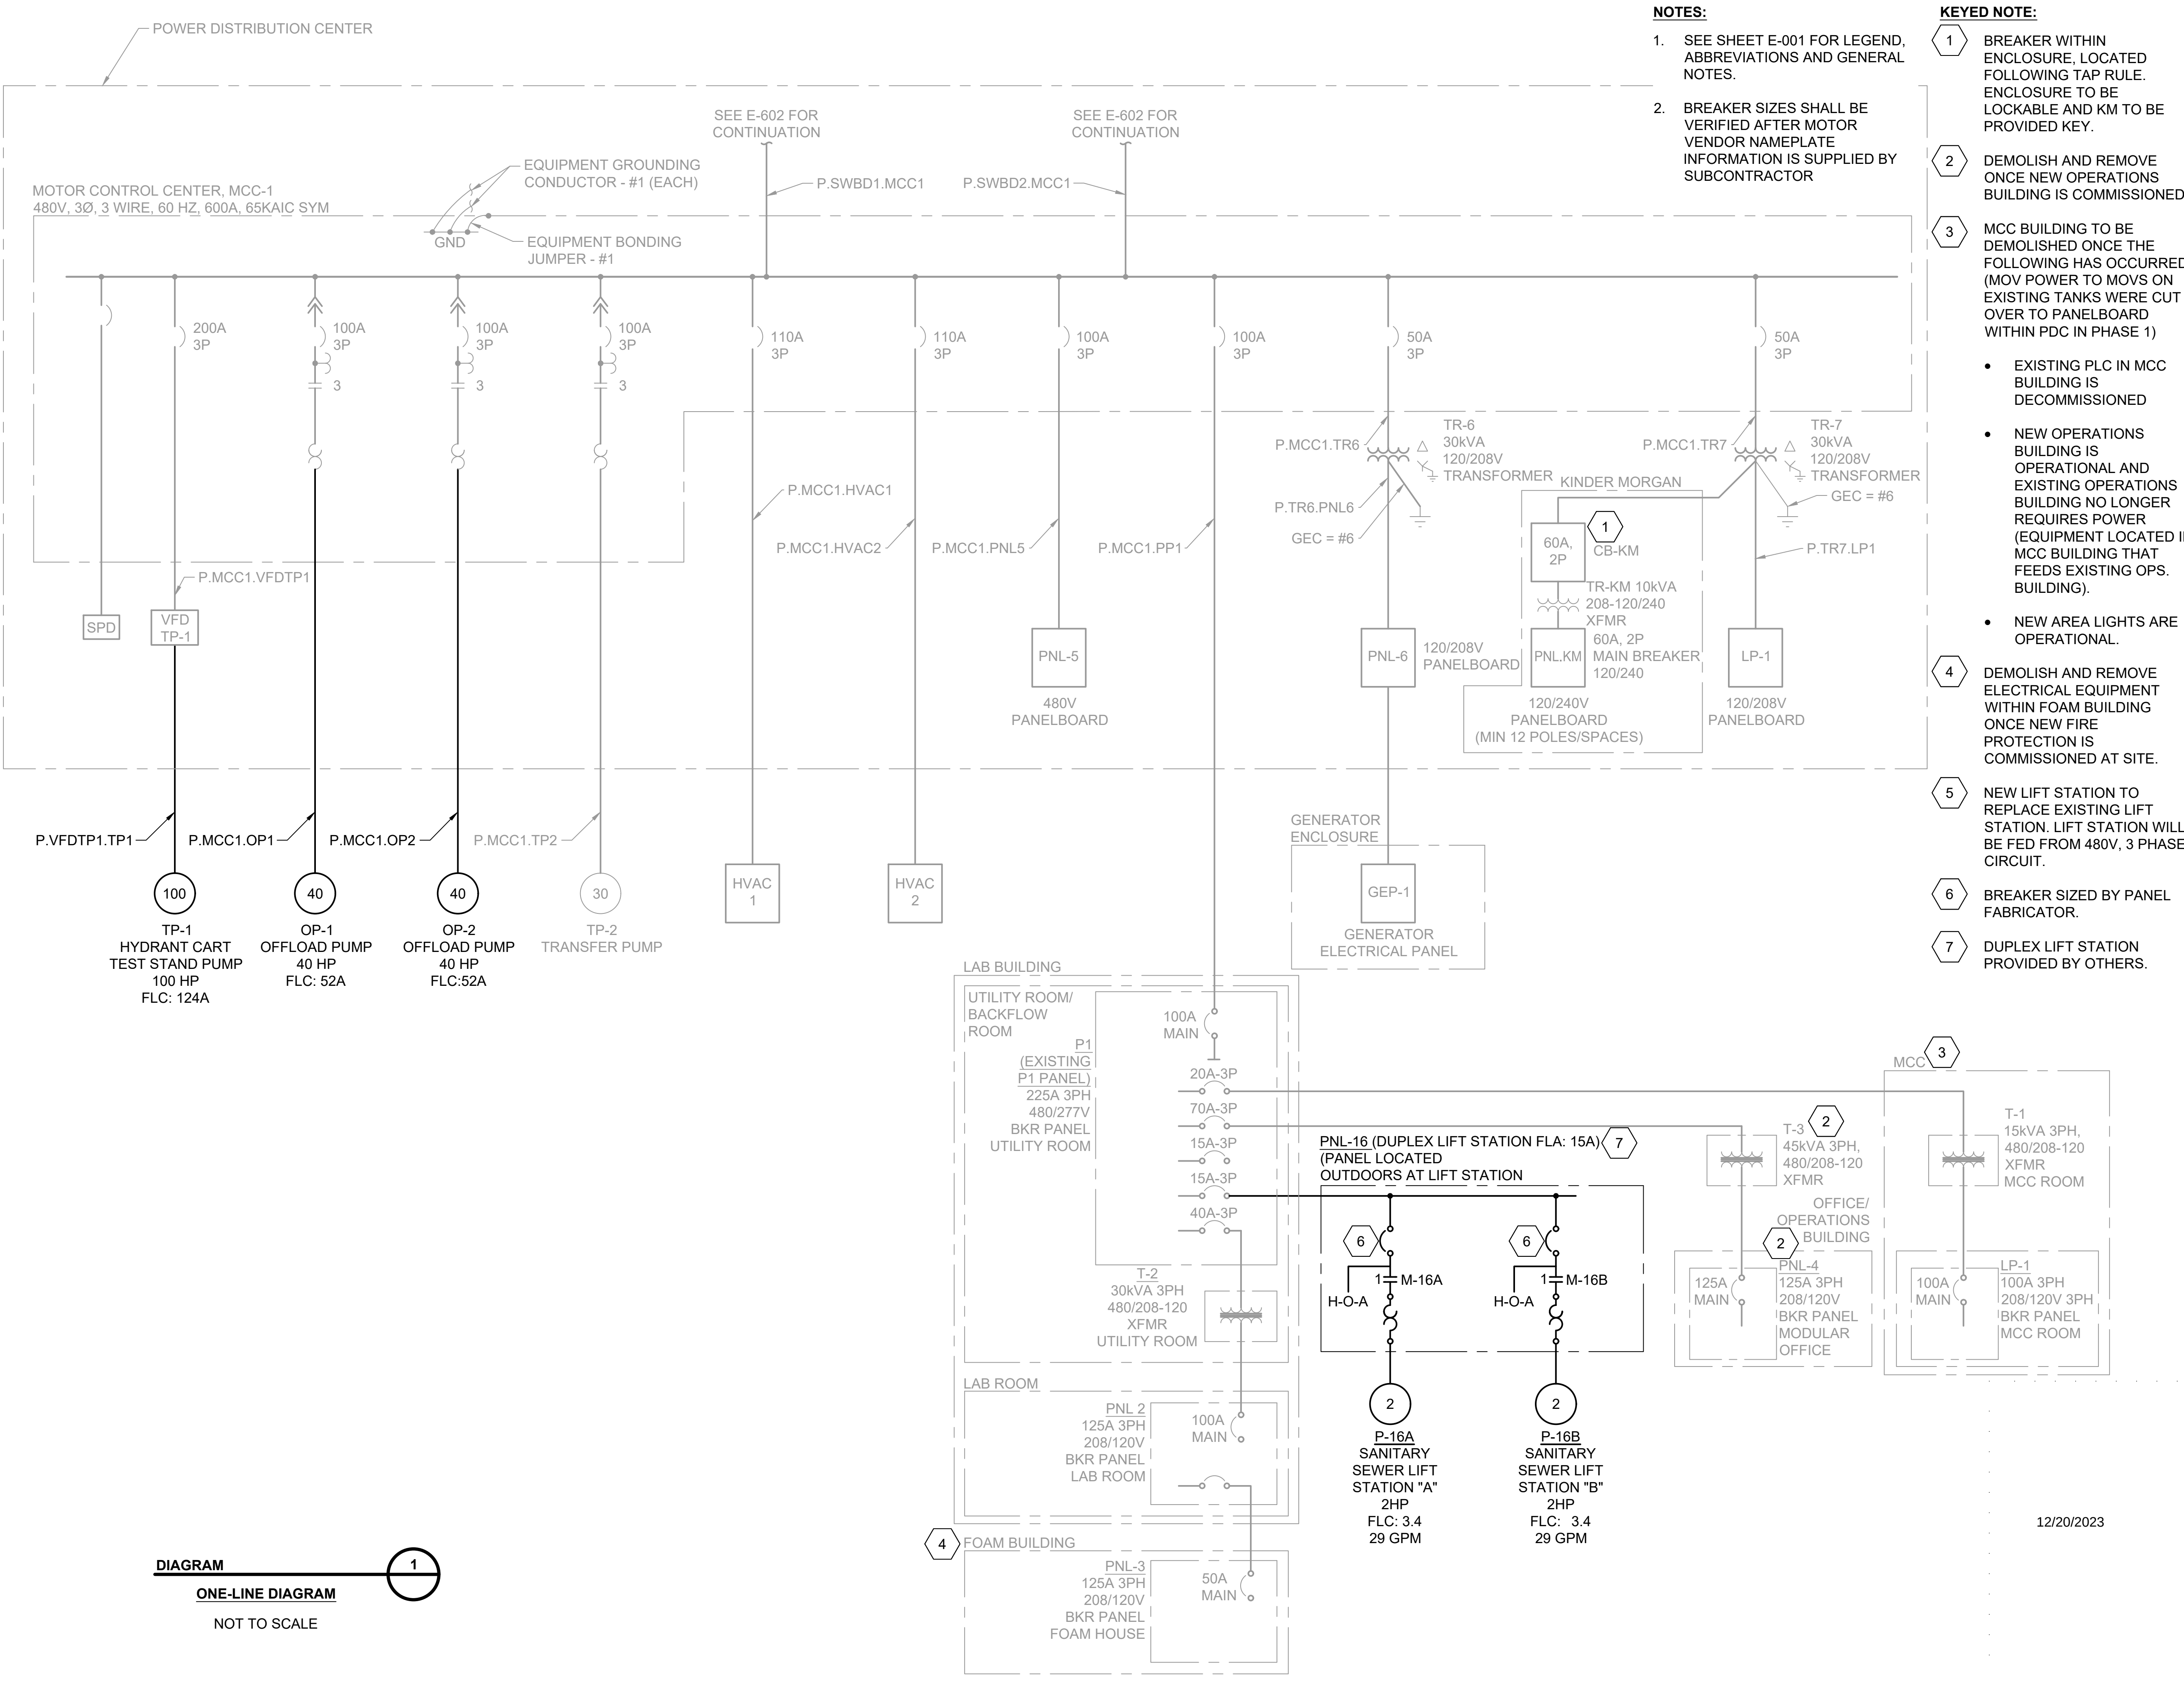

- NOTES:**
- SEE SHEET E-001 FOR LEGEND, ABBREVIATIONS AND GENERAL NOTES.
 - BREAKER SIZES SHALL BE VERIFIED AFTER MOTOR VENDOR NAMEPLATE INFORMATION IS SUPPLIED BY SUBCONTRACTOR

- KEYED NOTE:**
- BREAKER WITHIN ENCLOSURE, LOCATED FOLLOWING TAP RULE. ENCLOSURE TO BE LOCKABLE AND KM TO BE PROVIDED KEY.
 - DEMOLISH AND REMOVE ONCE NEW OPERATIONS BUILDING IS COMMISSIONED.
 - MCC BUILDING TO BE DEMOLISHED ONCE THE FOLLOWING HAS OCCURRED: (MOV POWER TO MOV'S ON EXISTING TANKS WERE CUT OVER TO PANELBOARD WITHIN PDC IN PHASE 1)
 - EXISTING PLC IN MCC BUILDING IS DECOMMISSIONED
 - NEW OPERATIONS BUILDING IS OPERATIONAL AND EXISTING OPERATIONS BUILDING NO LONGER REQUIRES POWER (EQUIPMENT LOCATED IN MCC BUILDING THAT FEEDS EXISTING OPS. BUILDING).
 - NEW AREA LIGHTS ARE OPERATIONAL.
 - DEMOLISH AND REMOVE ELECTRICAL EQUIPMENT WITHIN FOAM BUILDING ONCE NEW FIRE PROTECTION IS COMMISSIONED AT SITE.
 - NEW LIFT STATION TO REPLACE EXISTING LIFT STATION. LIFT STATION WILL BE FED FROM 480V, 3 PHASE CIRCUIT.
 - BREAKER SIZED BY PANEL FABRICATOR.
 - DUPLEX LIFT STATION PROVIDED BY OTHERS.

DIAGRAM

ONE-LINE DIAGRAM

NOT TO SCALE

no.	date	by	ckd	description
A	12/21/23	TSR	BAW	ISSUED FOR PERMIT

**ISSUED FOR PERMIT
ONLY**

**BURNS
McDONNELL**

9400 WARD PARKWAY
KANSAS CITY, MO 64114
816-333-9400
Burns & McDonnell Engineering Co, Inc.

date	04/24/2023	detailed	S. JESBERG
designed	T. RENSHAW	checked	B. WINTER

PDX FUEL COMPANY L.L.C

PORTLAND INTERNATIONAL AIRPORT
5000 NE MARINE DR.
PORTLAND, OREGON 97218

PDX FACILITY IMPROVEMENTS
ONE-LINE DIAGRAM - 2

project	153929	contract	
drawing	E-603	rev.	A

file 153929E-603.dwg

Millimeters
Scale For Microfining
Inches


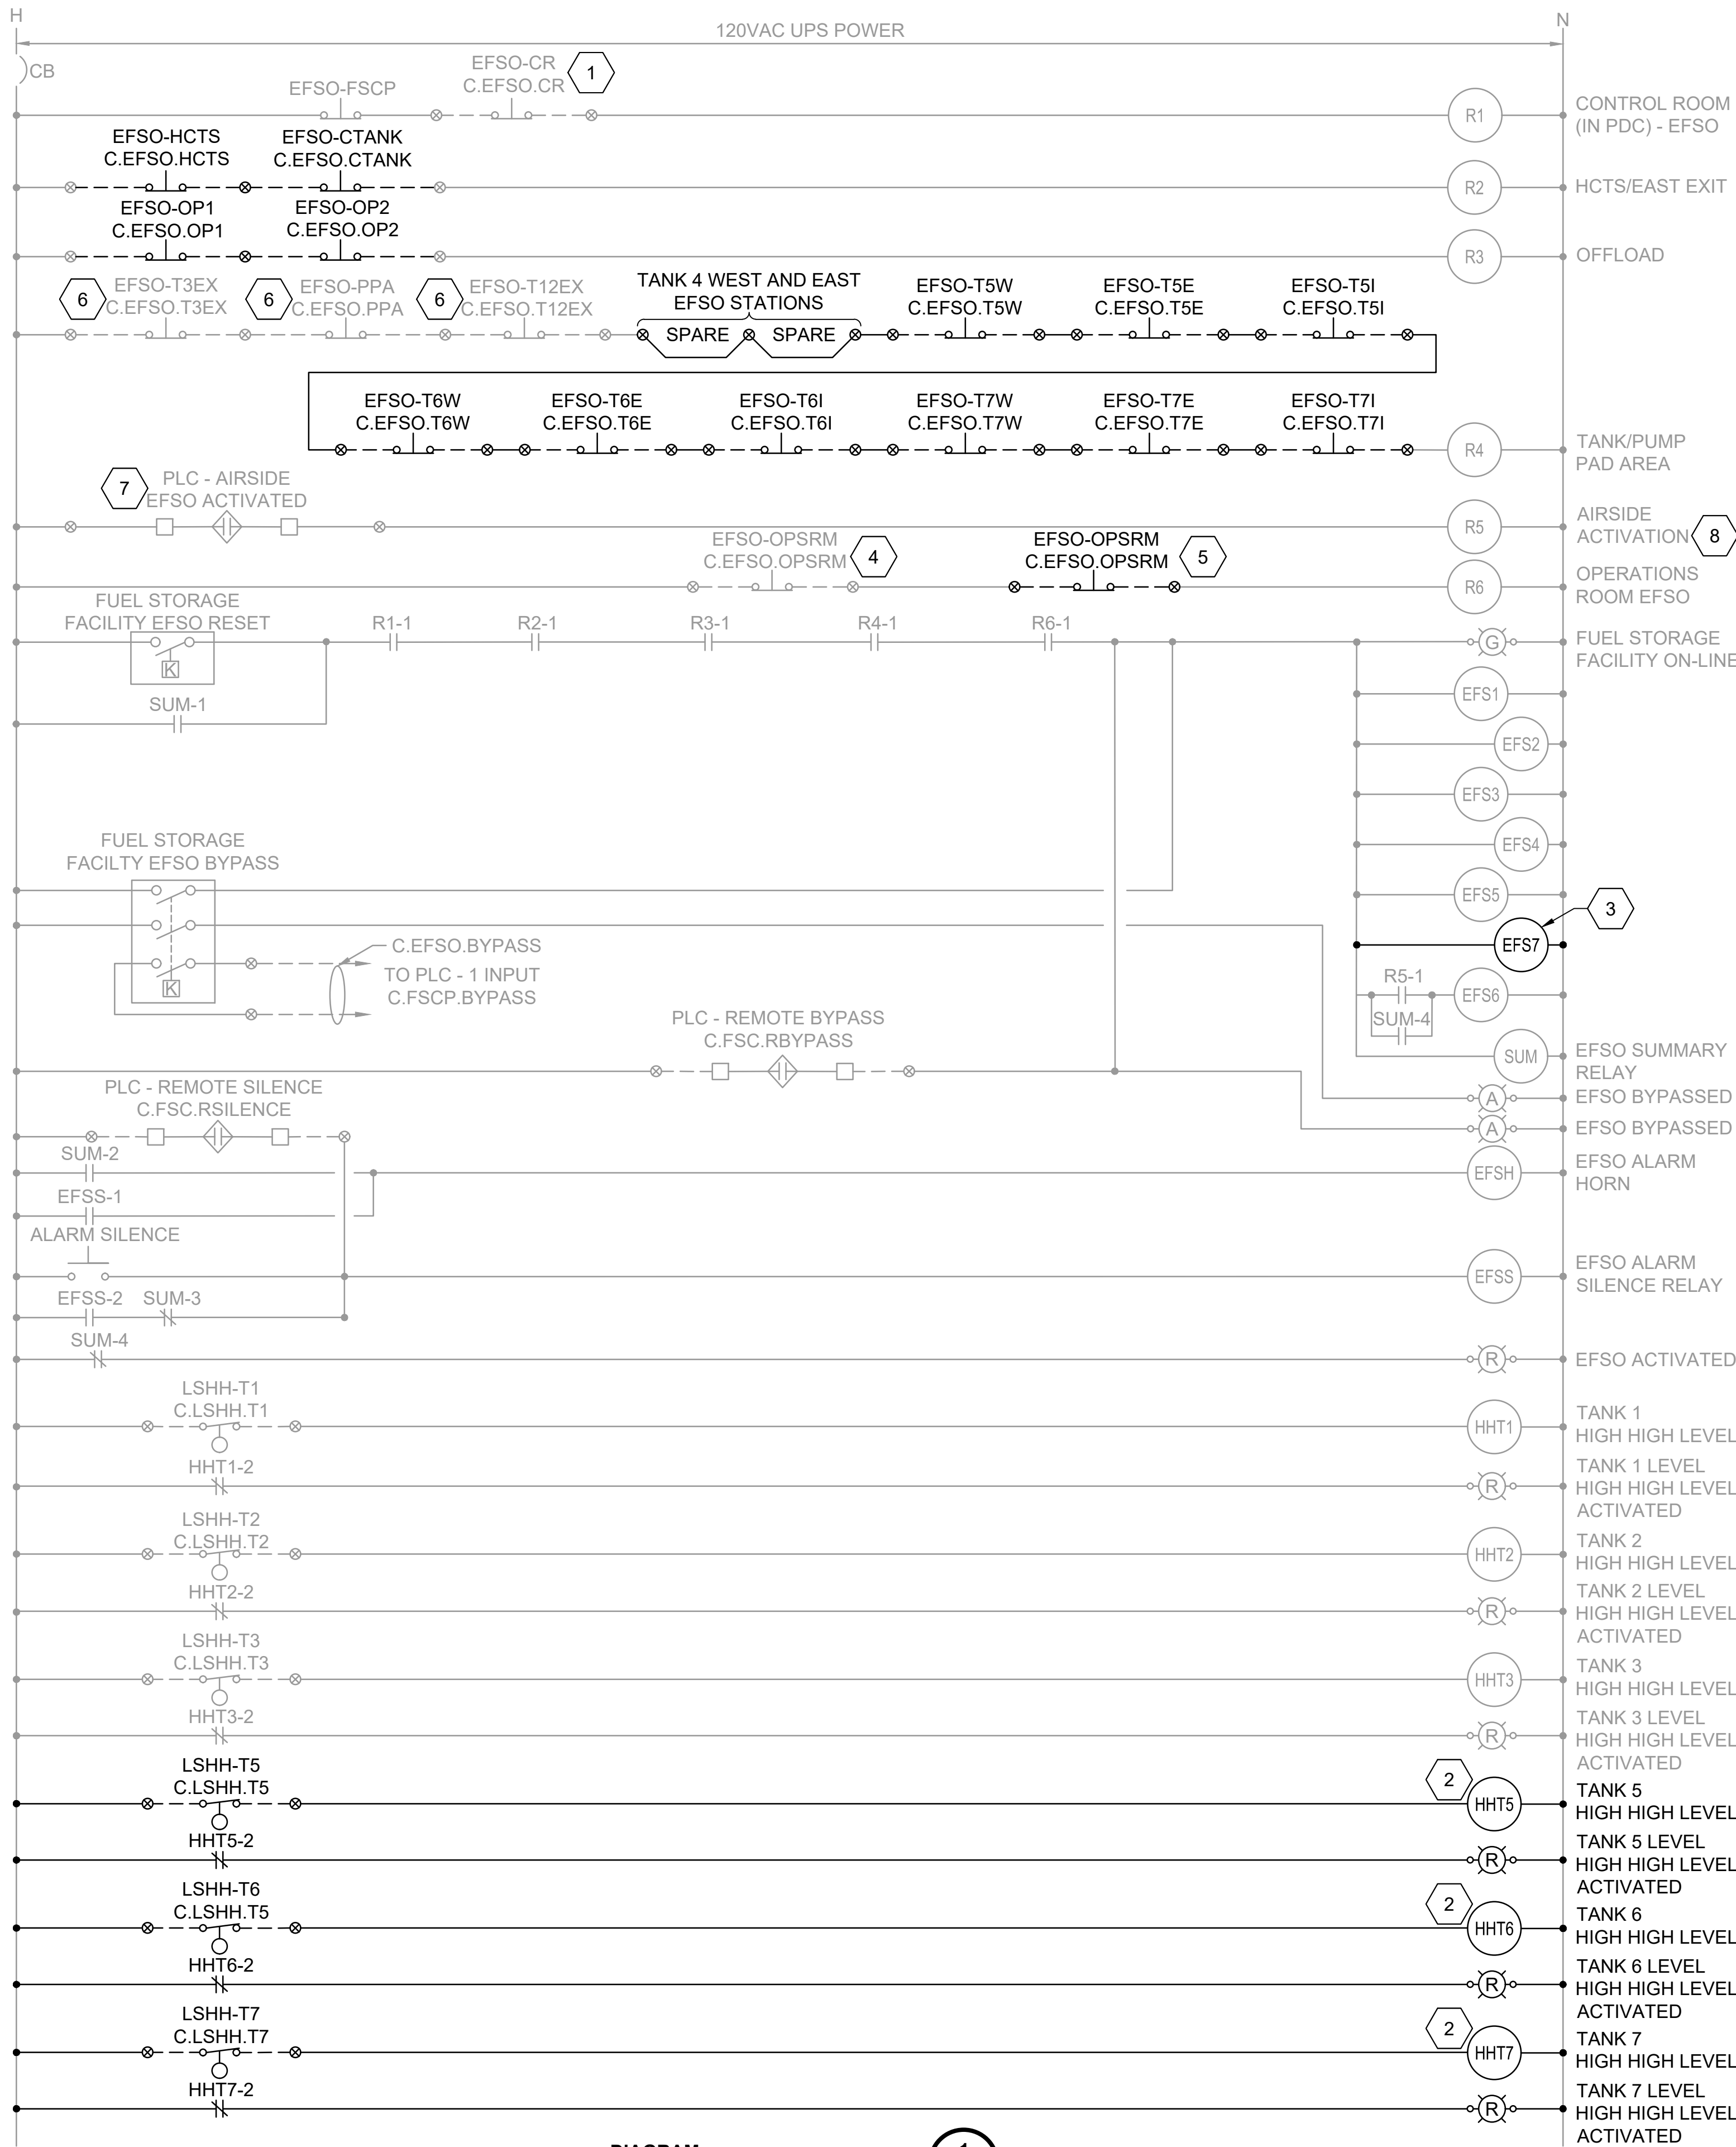


DIAGRAM
WIRING DIAGRAM - FUEL FACILITY
TANK LEVEL/EFSO SYSTEM
NOT TO SCALE

NOTES:

- PANEL WAS FURNISHED IN PDX FACILITY UPGRADE PROJECT (2023) PROJECT. REFER TO AS-BUILT CONSTRUCTION DOCUMENTS FOR FURTHER INFORMATION SUCH AS DETAILED WIRING. FABRICATION OF PANEL WAS PERFORMED BY ATGI, ATGI PROJECT NUMBER 34-39, WORK ORDER 22654.8010, DRAWING INDEX PDX-G-003).
- SEE SHEET E-001 FOR GENERAL NOTES, LEGEND AND ABBREVIATIONS.
- REFER TO DETAIL 1 AND 2 ON DRAWING E-501 FOR EFSO STATION CONSTRUCTION.
- REFER TO DRAWING E-506 FOR PANEL ELEVATION.
- CERTAIN DEVICES ARE LOCATED IN THE FIELD. REFER TO PLAN DRAWINGS FOR LOCATIONS.
- REFER TO E-605 FOR TANK AND EFSO CONTACTS INFORMATION.

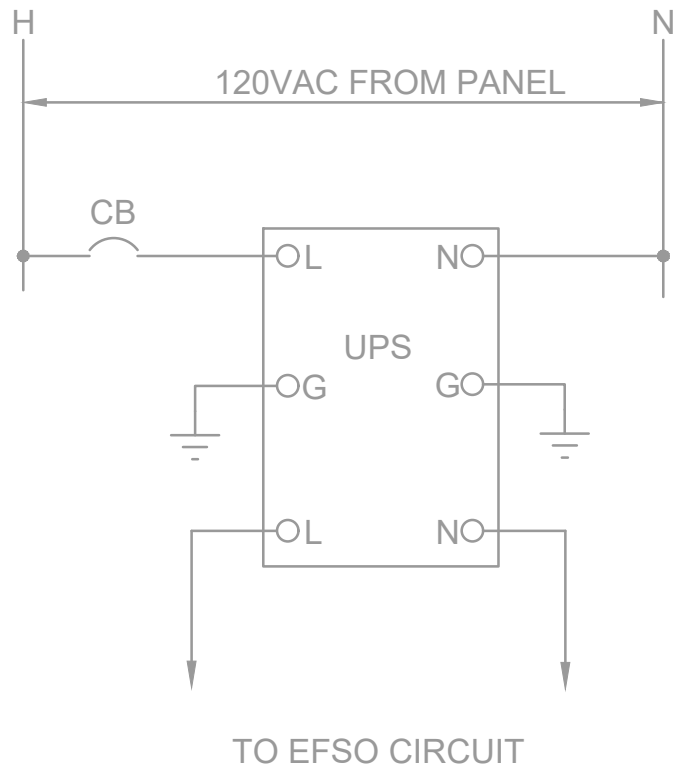

KEYED NOTES:

- PUSHBUTTONS LOCATED IN PDC-01, AT FUEL STORAGE FACILITY.
- GENERAL PURPOSE RELAY, 4 POLE WITH 10A RATED CONTACTS, 120V COIL, MANUAL OPERATOR AND PILOT LIGHT.
- EFSO RELAY, HEAVY DUTY INDUSTRIAL 6 POLE CONTROL RELAY, 10 AMP CONVERTIBLE CONTACTS, 120V COIL.
- DEMOLISH PUSHBUTTON. PUSHBUTTON LOCATED IN EXISTING OPERATIONS ROOM AT FUEL STORAGE FACILITY. PRIOR TO DEMOLITION OF EXISTING OPERATIONS BUILDING, JUMPER ACROSS AND REMOVE THIS PUSHBUTTON SO IT IS REMOVED FROM RELAY, R6, LOGIC.
- PUSHBUTTON LOCATED IN OPERATIONS ROOM AT FUEL STORAGE FACILITY.
- DEMOLISH PUSHBUTTON PRIOR TO DEMOLITION OF TANKS 1, 2 AND 3, JUMPER ACROSS AND REMOVE PUSHBUTTONS SO THEY ARE REMOVED FROM RELAY, R4, LOGIC. INLET AND OUTLET MOV LABELING WILL BE AS FOLLOWS:
CIRCUIT #: C.EFSO.MOV4A (FUTURE), C.EFSO.MOV4B (FUTURE) DESCRIPTION: TANK 4 INLET ESD TERMINAL (FUTURE), TANK 4 OUTLET ESD TERMINAL (FUTURE)
- AIRSIDE EFSO ACTIVATION SIGNAL COMES FROM FUEL STORAGE FACILITY PLC. RE-PURPOSED FOR MOV ESD TERMINALS ON THE INLET AND OUTLET VALVE. LABELING WILL BE AS FOLLOWS:
CIRCUIT #: C.EFSO.MOV6A, C.EFSO.MOV6B DESCRIPTION: TANK 6 INLET ESD TERMINAL, TANK 6 OUTLET ESD TERMINAL.
- RELABEL TO "AIRSIDE EFSO STATUS"

LEGEND:

- ⊗ TERMINAL IN BULK FUEL FACILITY EFSO PANEL

no.	date	by	ckd	description
A	12/21/23	TSR	BAW	ISSUED FOR PERMIT

ISSUED FOR PERMIT ONLY



9400 WARD PARKWAY
KANSAS CITY, MO 64114
816-333-9400
Burns & McDonnell Engineering Co., Inc.

date	04/24/2023	detailed	S. JESBERG
designed	T. RENSHAW	checked	B. WINTER

PDX FUEL COMPANY L.L.C

PORTLAND INTERNATIONAL AIRPORT
5000 NE MARINE DR.
PORTLAND, OREGON 97218

PDX FACILITY IMPROVEMENTS
FUEL FACILITY TANK LEVEL AND EFSO DIAGRAM




















project	153929	contract	
drawing	E-604	rev.	A

file 153929E-604.dwg

Millimeters

Scale For Microfinning

Inches

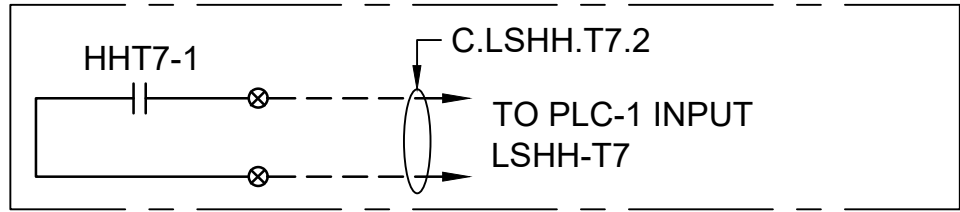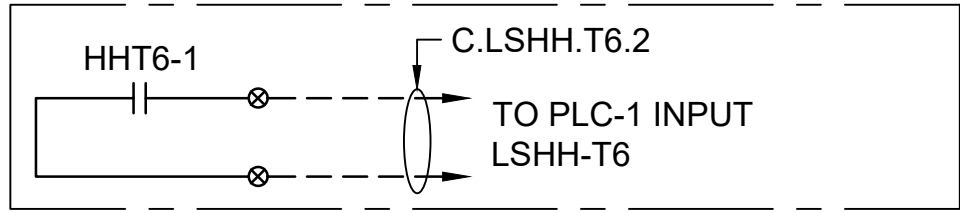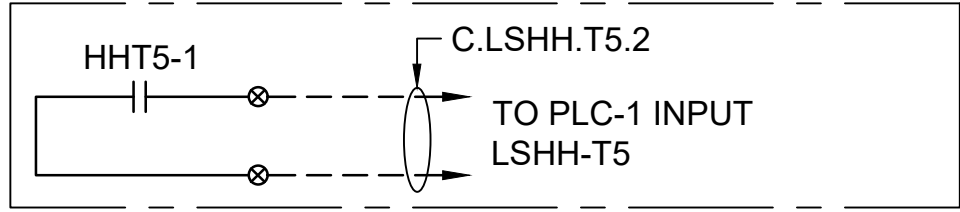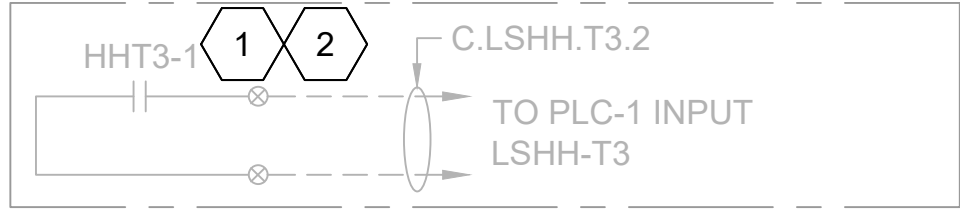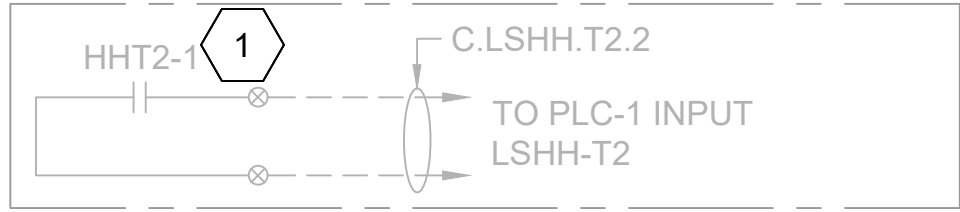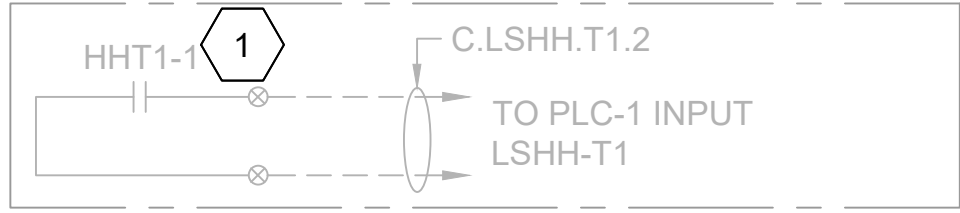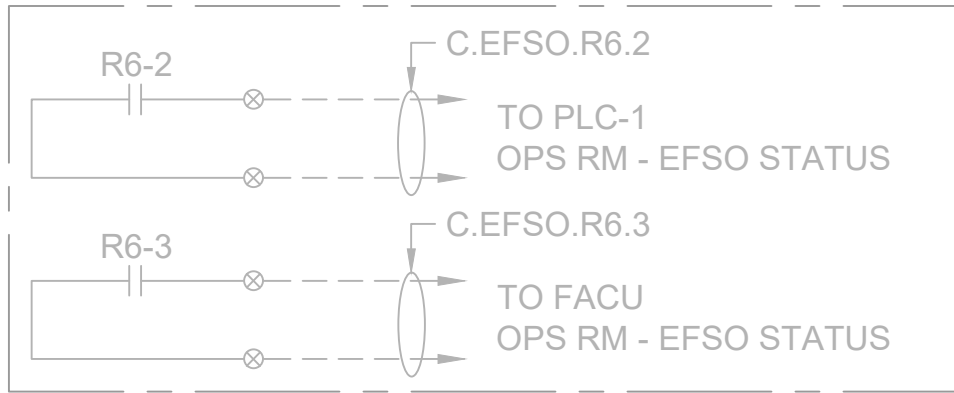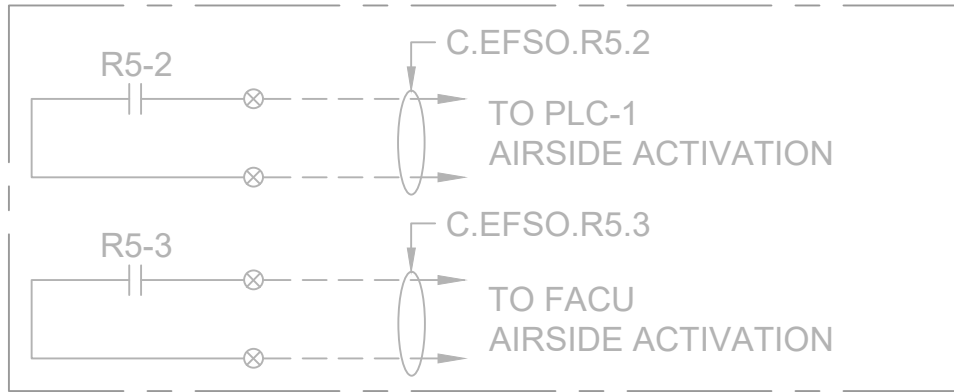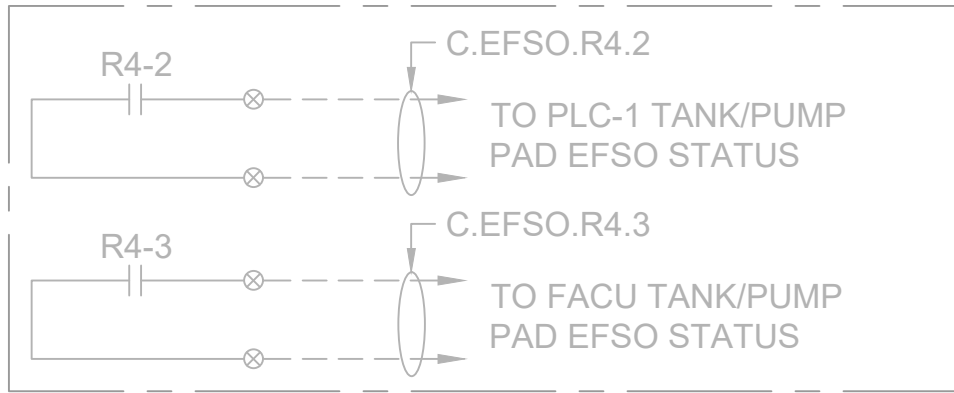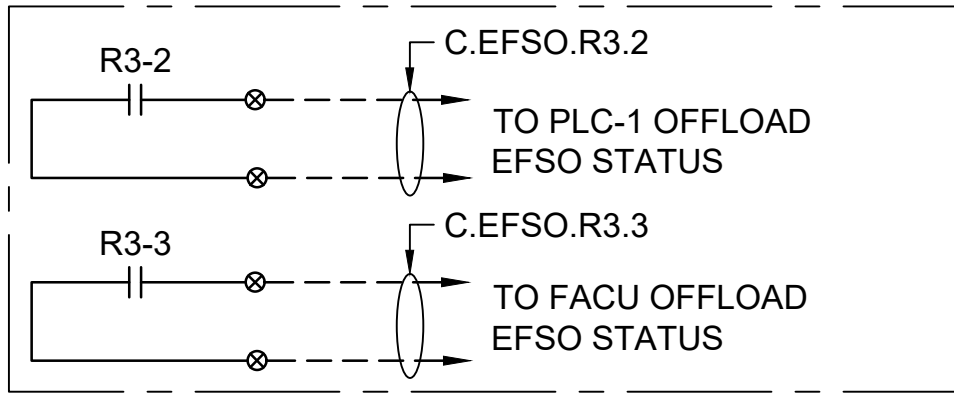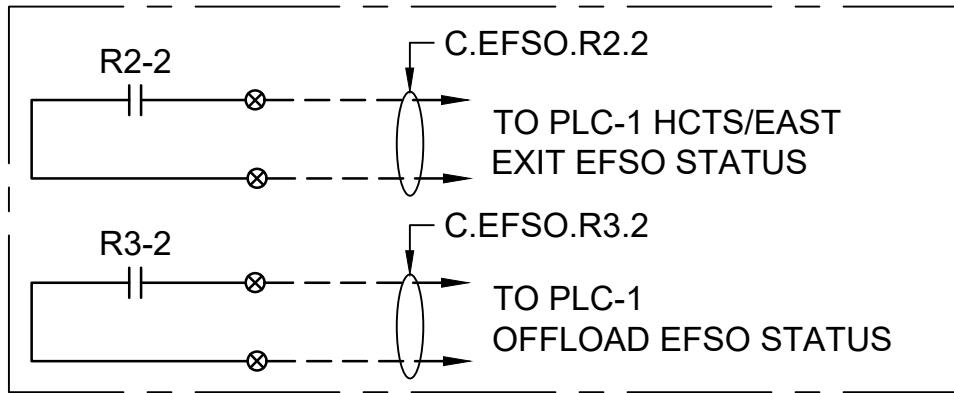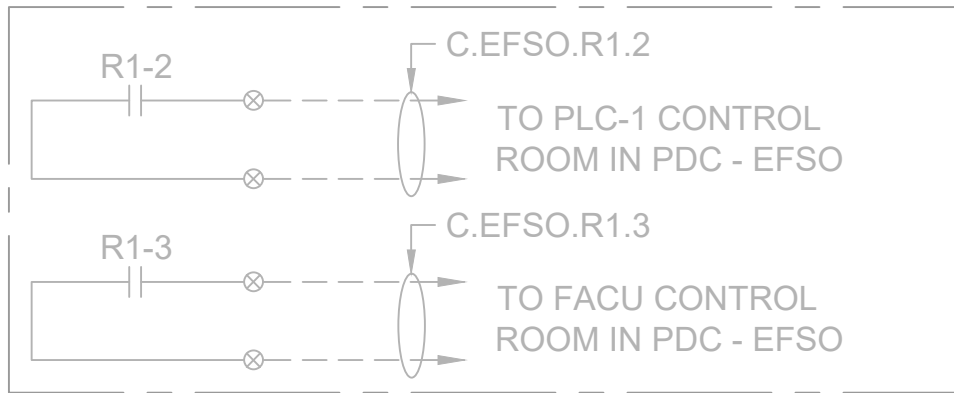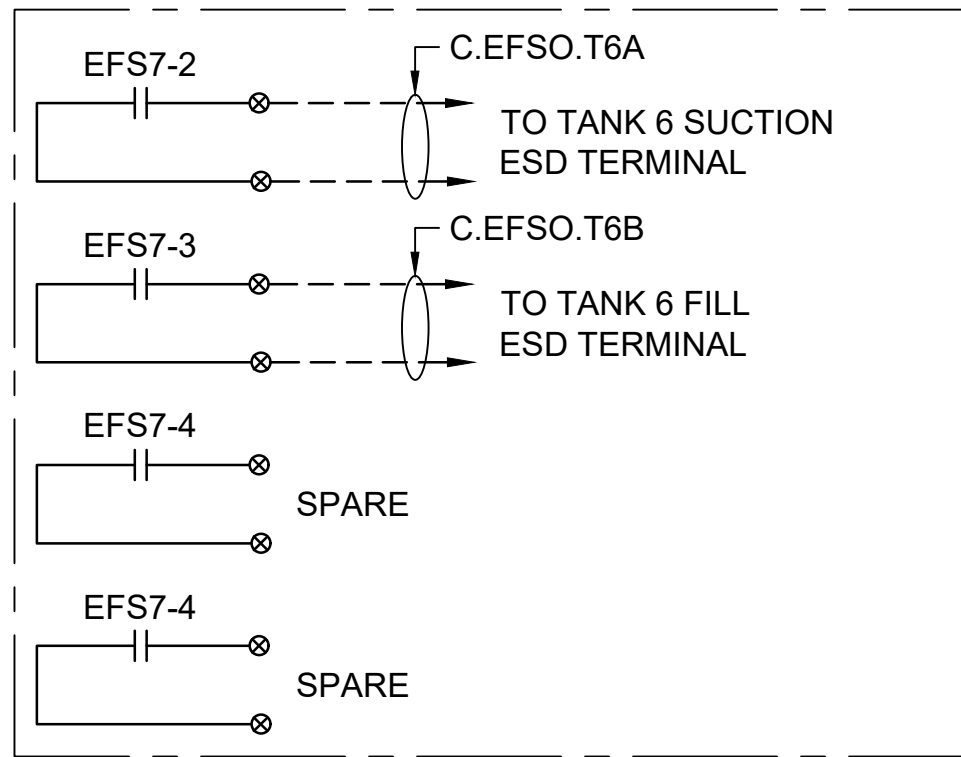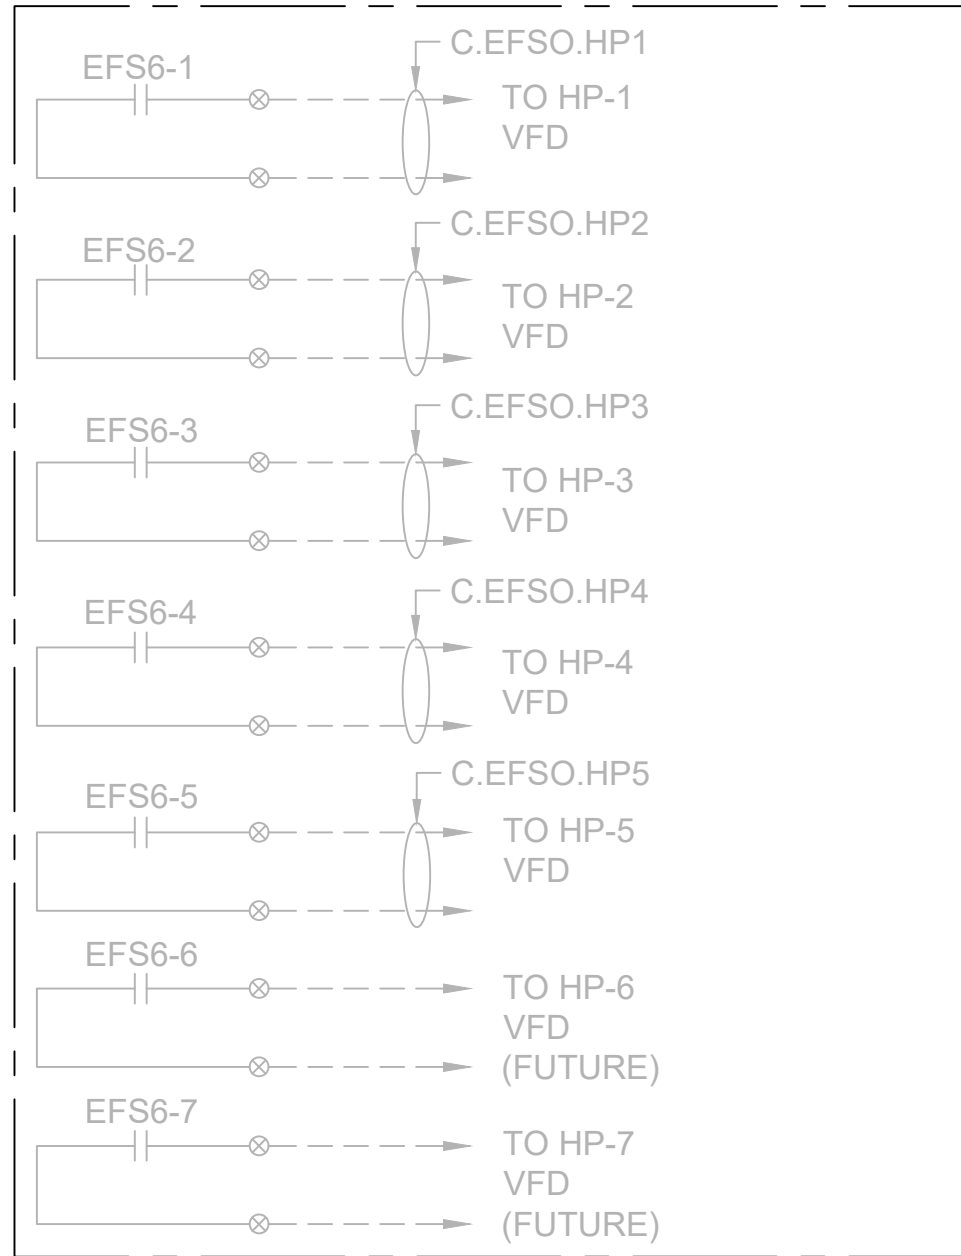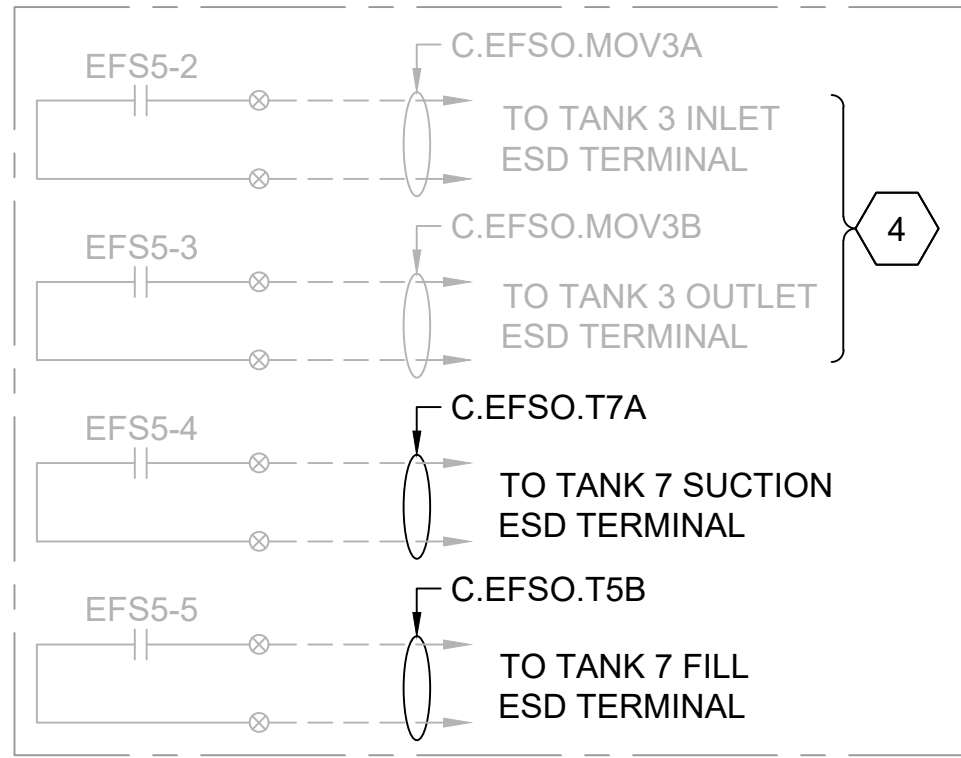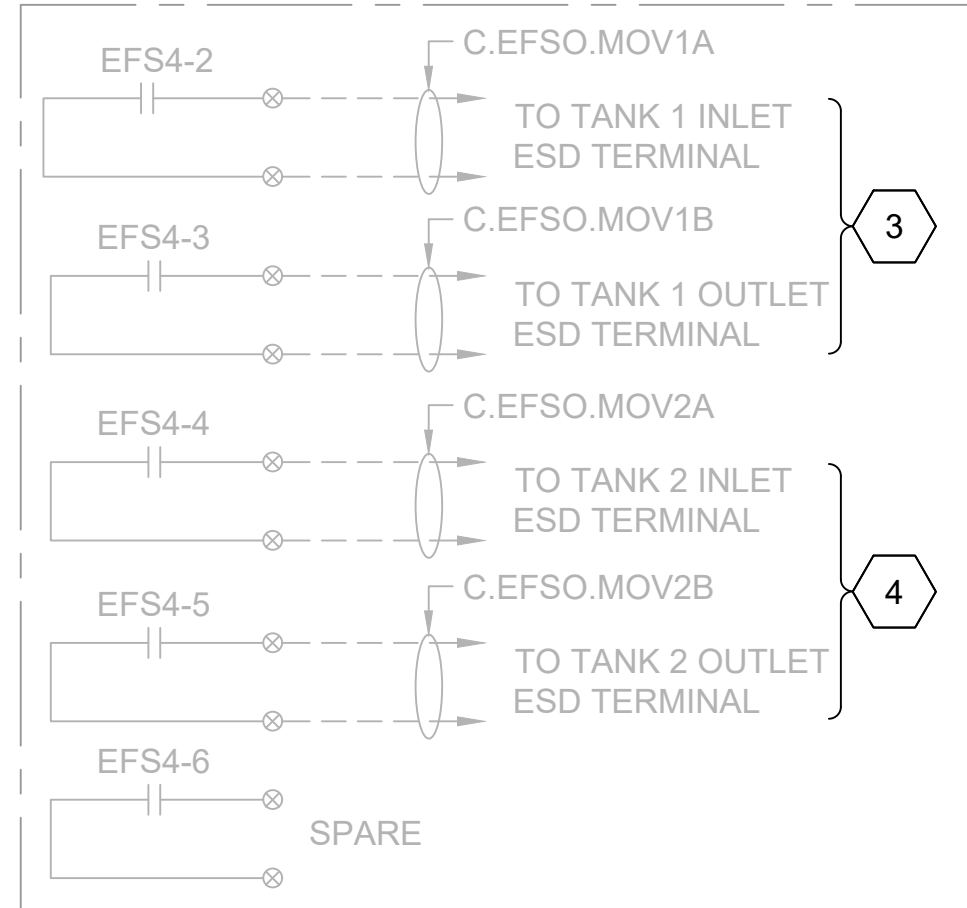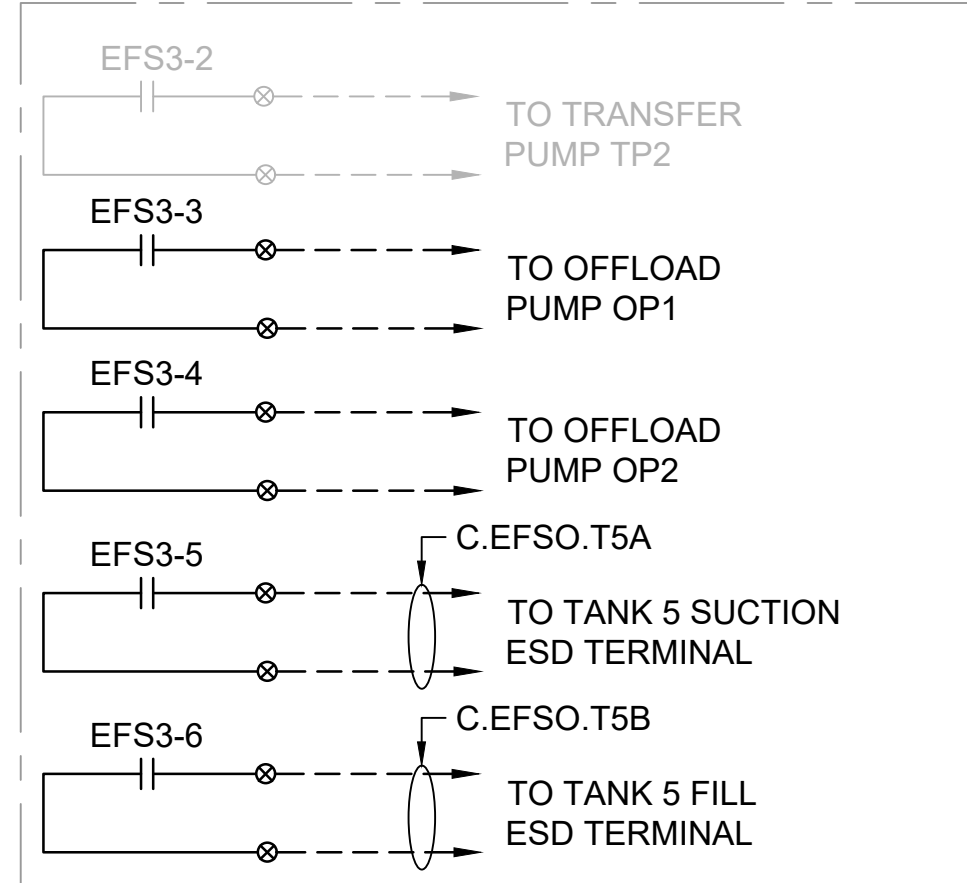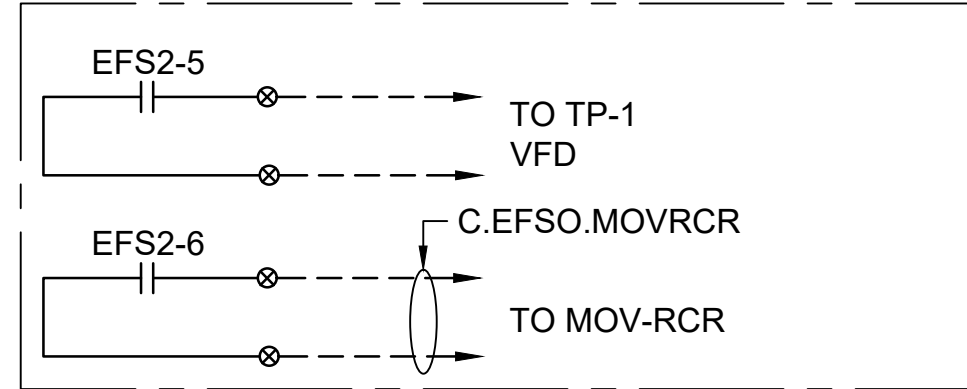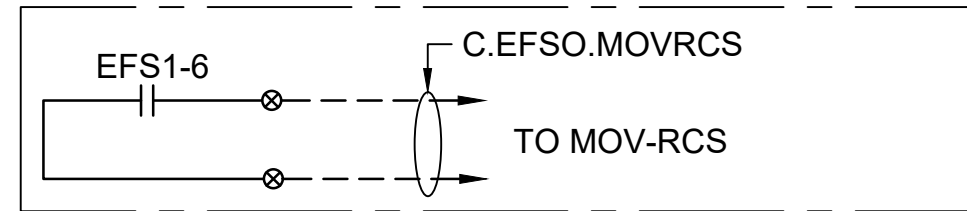

CONTACTS ON COMMON RELAY COIL (TYP)

DIAGRAM

WIRING DIAGRAM - FUEL FACILITY TANK LEVEL/EFSO CONTACTS

NOT TO SCALE

1

NOTES:

- SEE SHEET E-001 FOR GENERAL NOTES, LEGEND AND ABBREVIATIONS.
- REFER TO DETAIL 1 AND 2 ON DRAWING E-501 FOR EFSO STATION CONSTRUCTION.
- REFER TO DRAWING E-506 FOR PANEL ELEVATION.
- CERTAIN DEVICES ARE LOCATED IN THE FIELD. REFER TO PLAN DRAWINGS FOR LOCATIONS.

KEYED NOTES:

- ONCE TANKS 1, 2 AND 3 ARE DEMOLISHED AND REMOVED DEMOLISH AND REMOVE ALL FIELD WIRING TO STORAGE TANKS. IDENTIFY CONTACTS AS SPARE. KEEP WIRING BETWEEN PANEL AND PLC CABINET. IDENTIFY CABLES AS SPARE.
- LABEL CONTACT AS "HHT4-1 - FUTURE".
- ONCE TANK 1 IS DEMOLISHED, CONTACTS ARE TO BE RESERVED FOR FUTURE TANK 4, ESD TERMINALS ON THE INLET AND OUTLET MOVS. LABELING WILL BE AS FOLLOWS:
CIRCUIT #: C.EFSO.MOV4A (FUTURE), C.EFSO.MOV4B (FUTURE)
DESCRIPTION: TANK 4 INLET ESD TERMINAL (FUTURE), TANK 4 OUTLET ESD TERMINAL (FUTURE)
- ONCE TANK IS DEMOLISHED, CONTACTS ARE TO BE MADE SPARE. REMOVE WIRING ON CONTACTS. LABELING WILL BE AS FOLLOWS:
CIRCUIT #: N/A
DESCRIPTION: SPARE

LEGEND:

- ⊗ TERMINAL IN BULK FUEL FACILITY EFSO PANEL

no.	date	by	ckd	description
A	12/21/23	TSR	BAW	ISSUED FOR PERMIT

ISSUED FOR PERMIT ONLY

BURNS MEDONNELL

9400 WARD PARKWAY
KANSAS CITY, MO 64114
816-333-9400
Burns & McDonnell Engineering Co., Inc.

date	04/24/2023	detailed	S. JESBERG
designed	T. RENSHAW	checked	B. WINTER


PDX FUEL COMPANY L.L.C

PORTLAND INTERNATIONAL AIRPORT
5000 NE MARINE DR.
PORTLAND, OREGON 97218

PDX FACILITY IMPROVEMENTS
FUEL FACILITY TANK LEVEL AND EFSO CONTACTS

project	153929	contract	
drawing	E-605	rev.	A


file 153929E-605.dwg

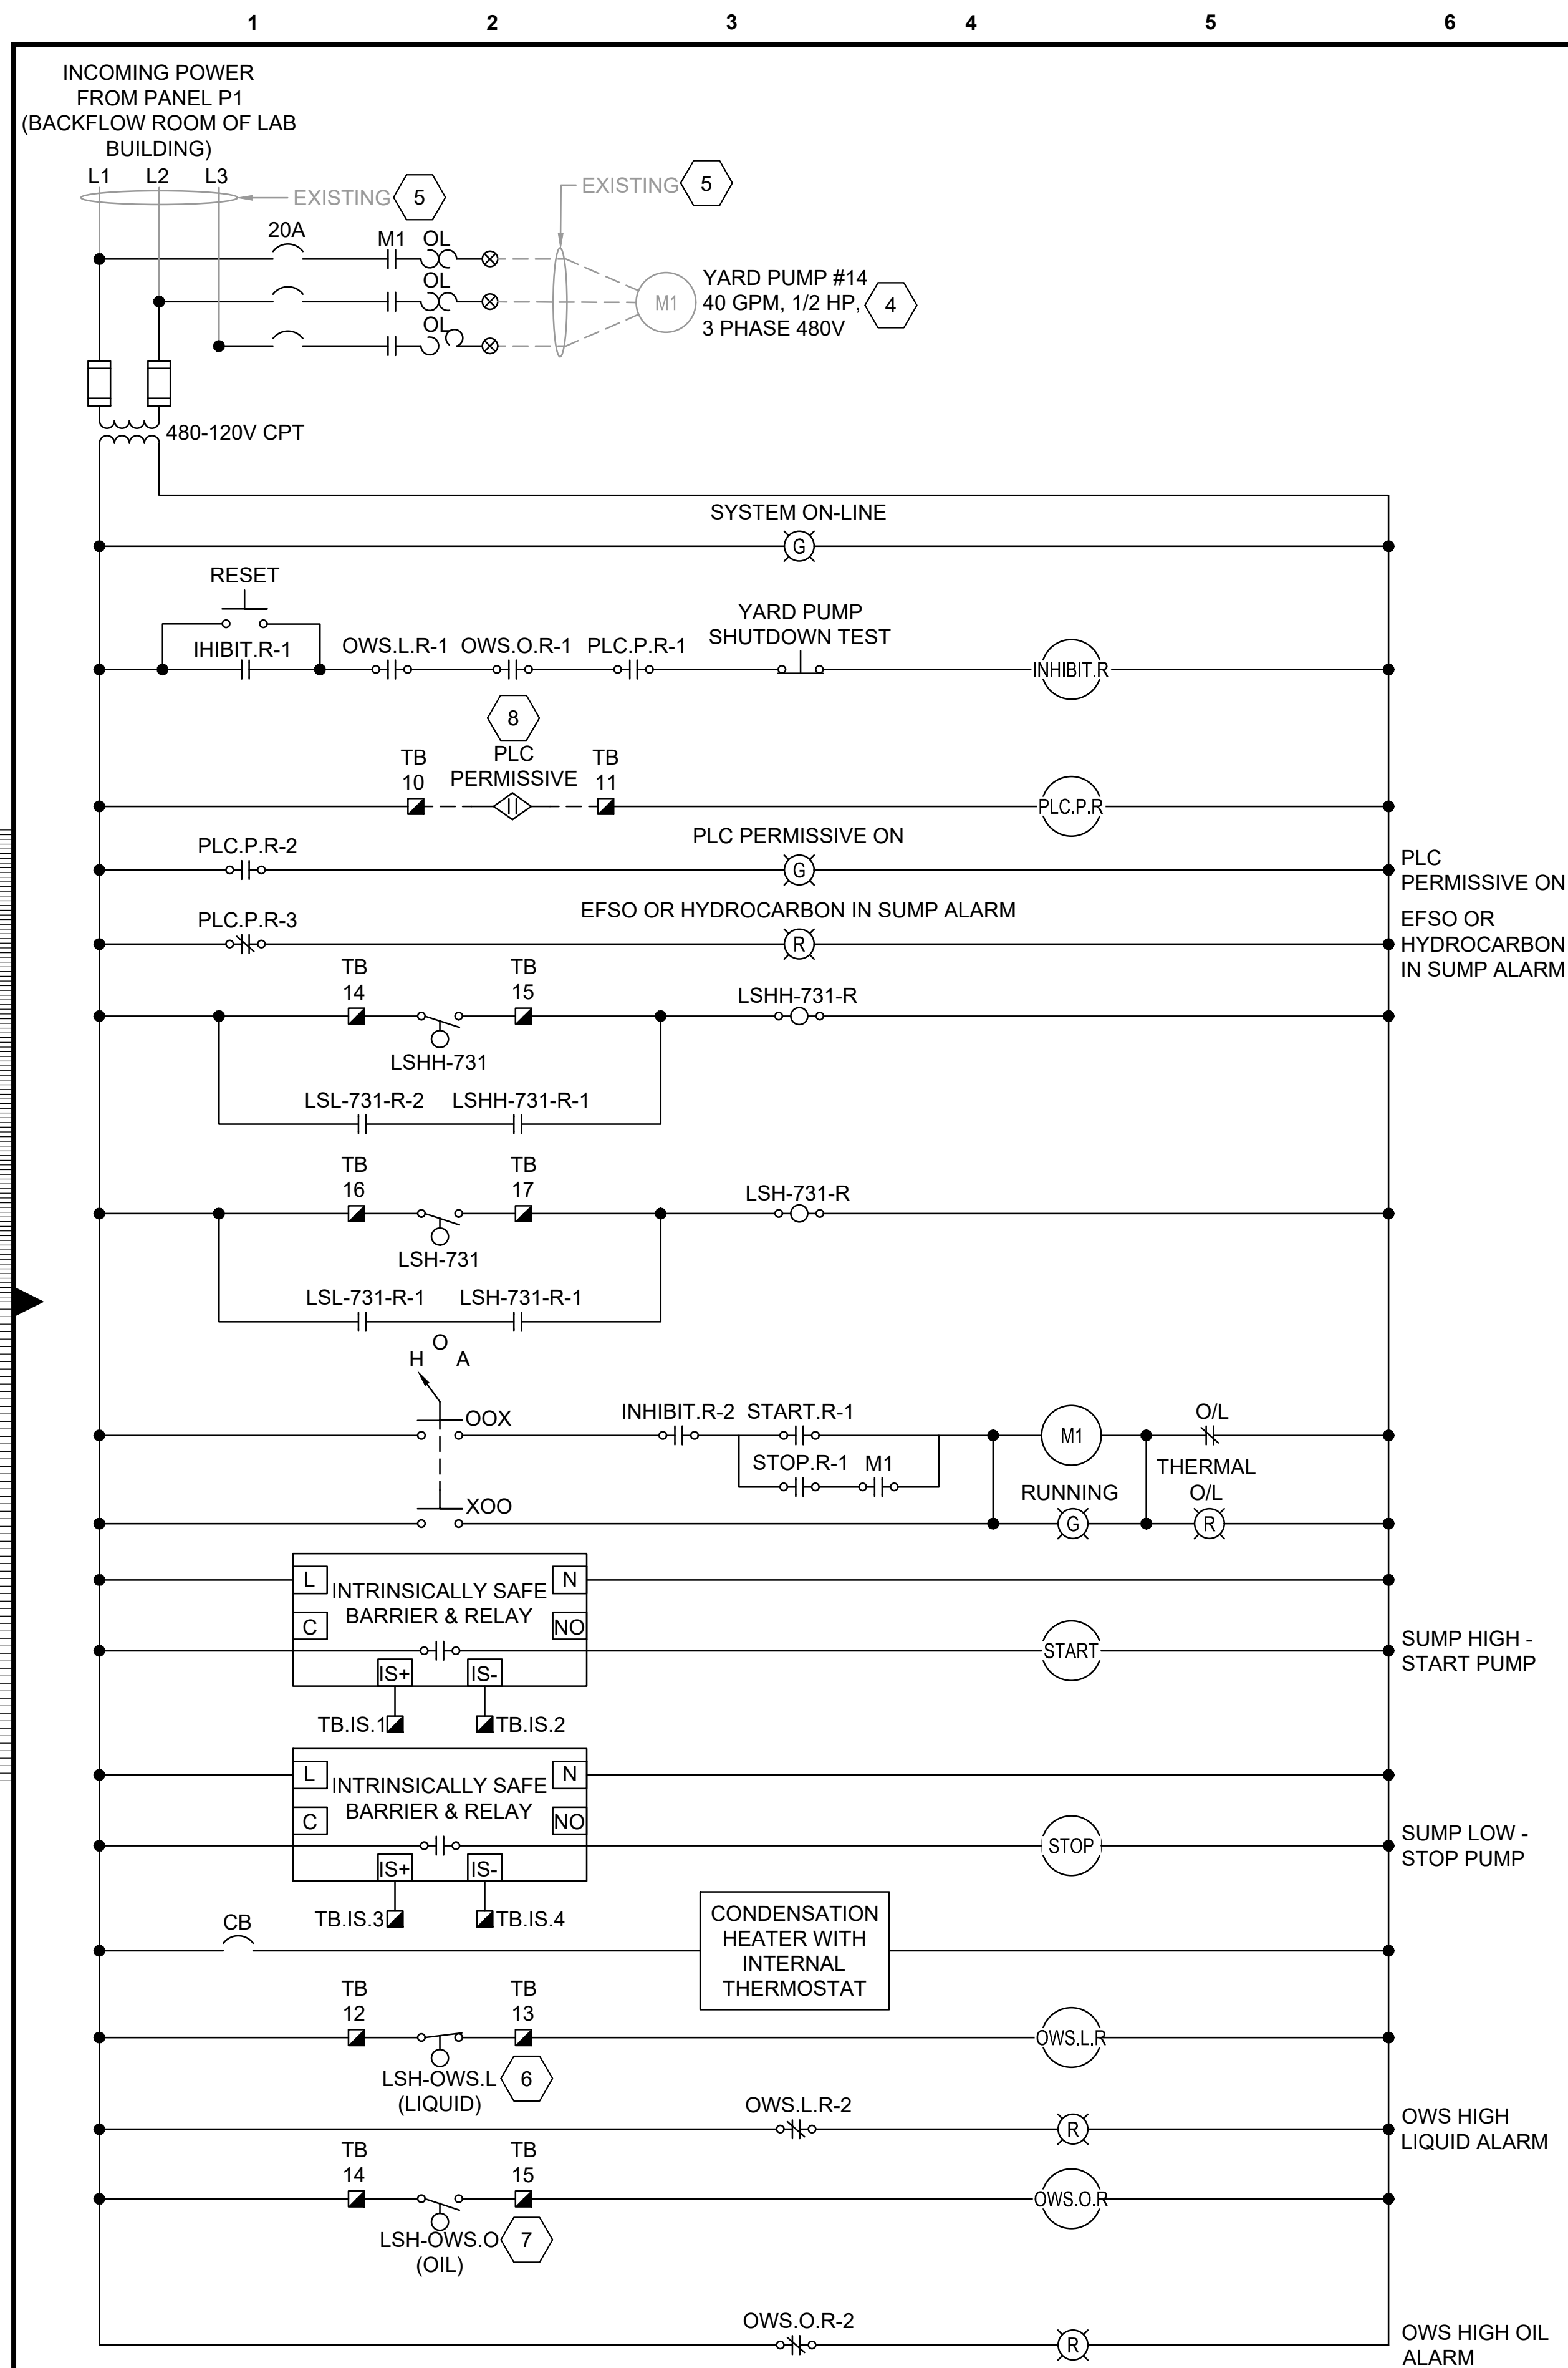

DETAIL

CONTROL DIAGRAM -
CONTAINMENT SUMP PANEL

NOT TO SCALE

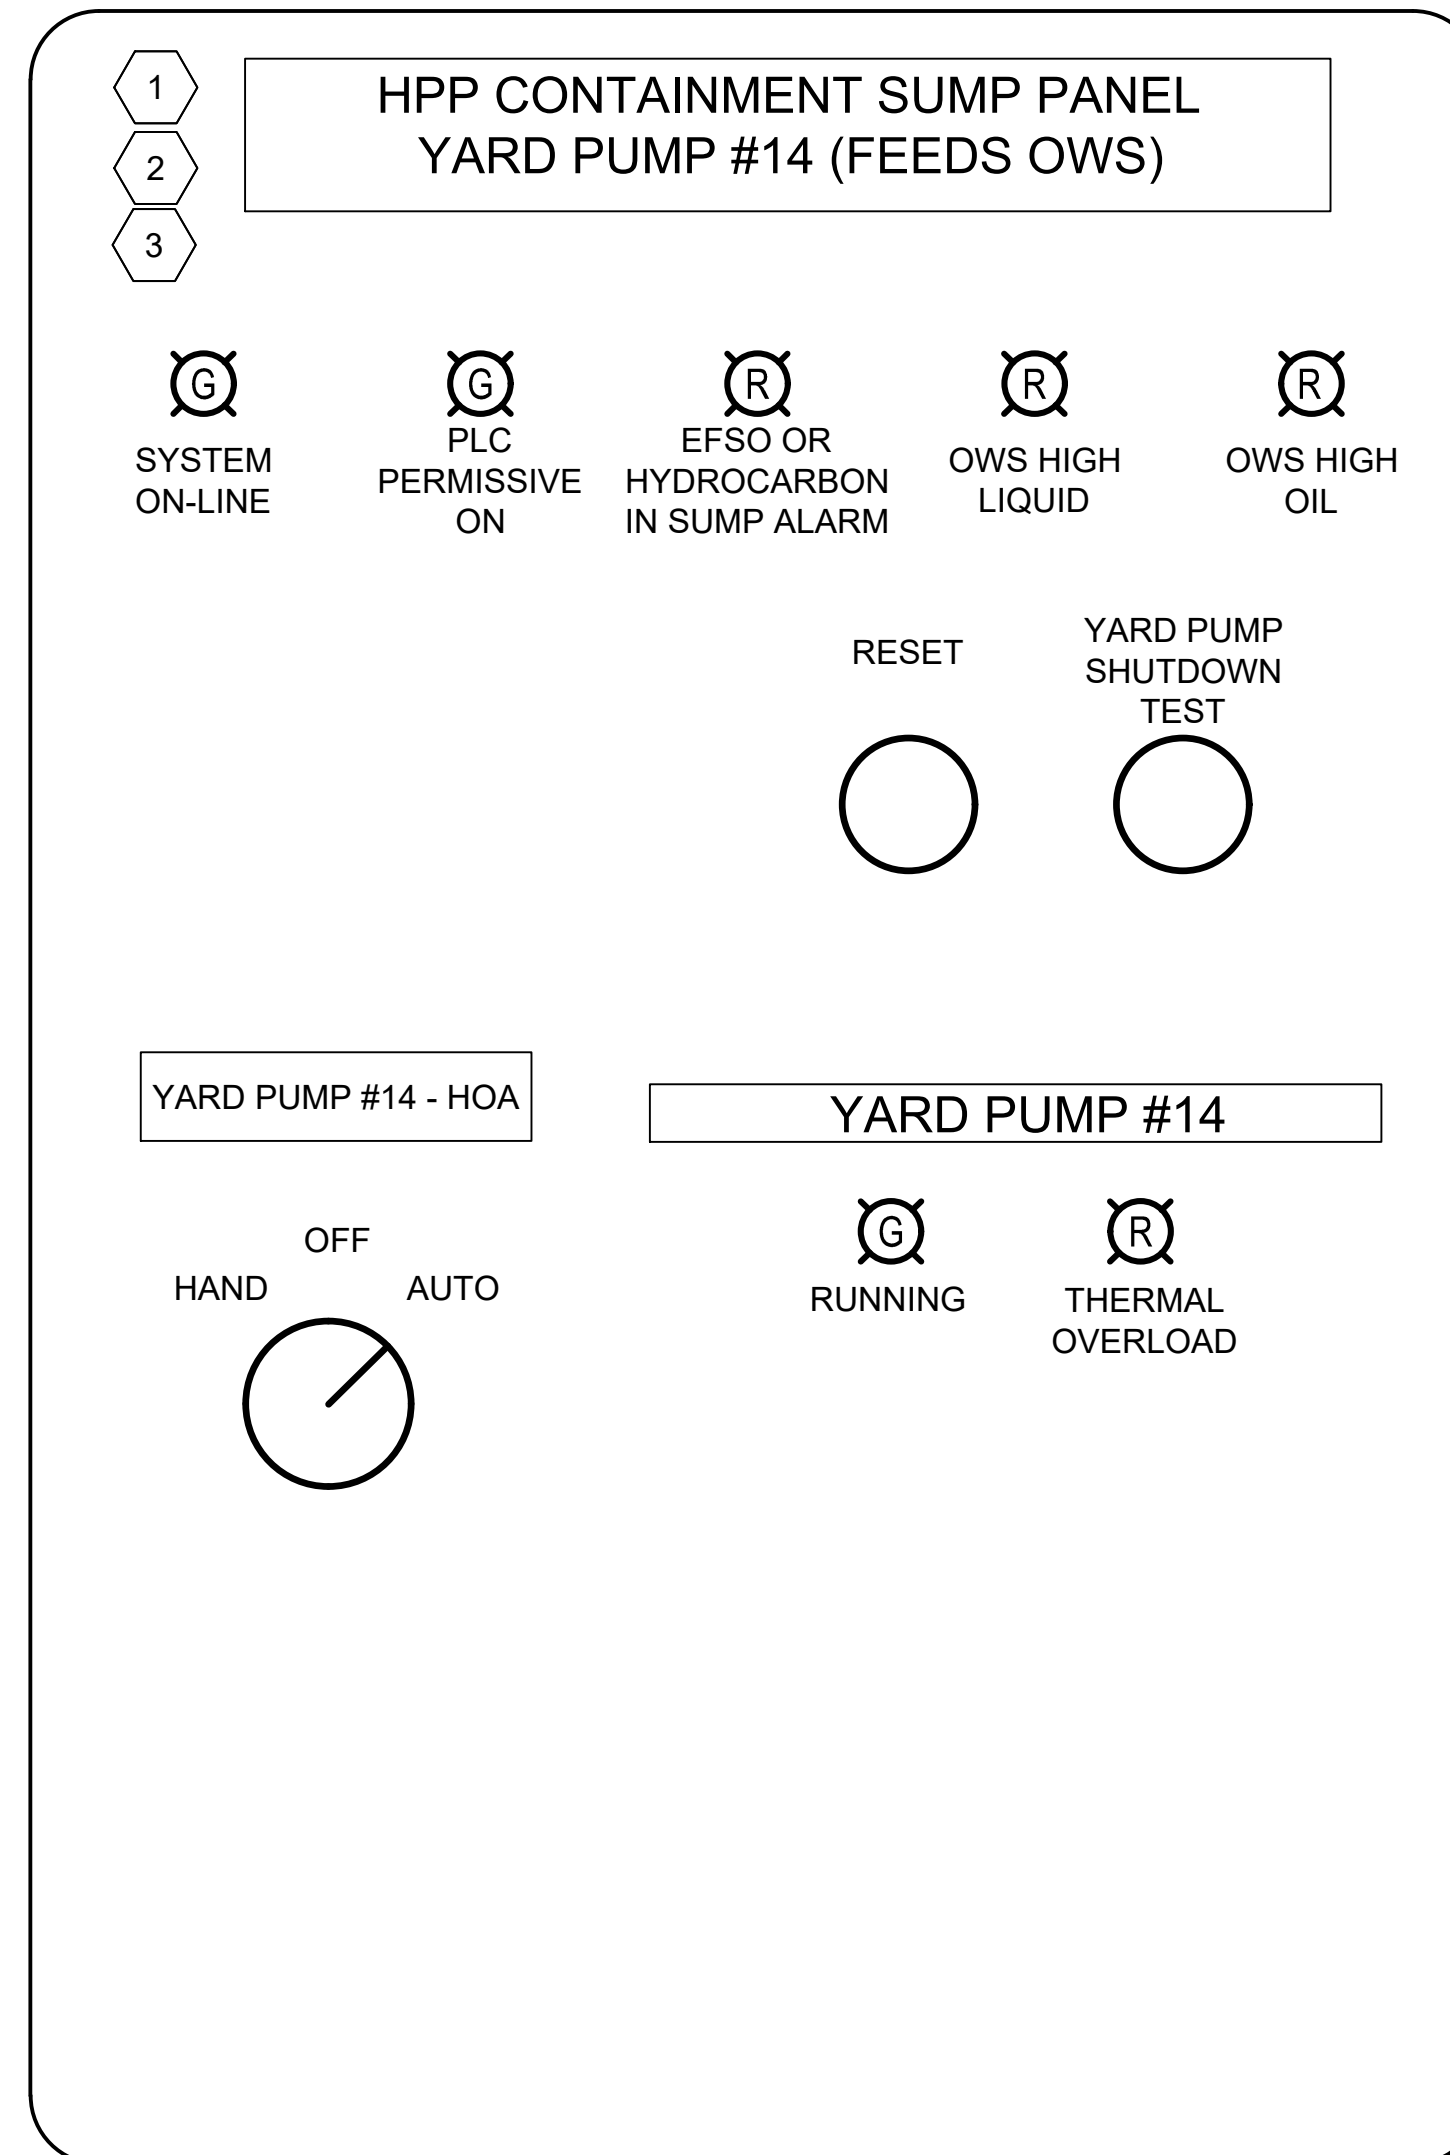

DETAIL


CONTAINMENT SUMP
PANEL LAYOUT
NOT TO SCALE

NOTES:

1. THE HPP CONTAINMENT SUMP PANEL IS FURNISHED UNDER 33 56 45 – ABOVEGROUND OIL WATER SEPARATOR.

KEYED NOTES:

- 1 HPP CONTAINMENT SUMP PANEL SHALL BE NEMA 4X, STAINLESS STEEL.
- 2 THE CONTAINMENT SUMP PANEL IS RESPONSIBLE FOR STARTING AND STOPPING YARD PUMP #14 AUTOMATICALLY BASED ON SUMP PIT LEVEL FLOATS. THE SUMP PANEL IS ALSO RESPONSIBLE FOR INHIBITING / PREVENTING THE YARD PUMP FROM RUNNING IF THE OWS ENCOUNTERS A HIGH LIQUID OR HIGH OIL ALARM. THE HIGH OIL AND HIGH LIQUID ALARMS ARE PASSED ONTO THE PLC AS INPUTS. THE SUMP PANEL IS ALSO RESPONSIBLE FOR INHIBITING / PREVENTING THE YARD PUMP FROM RUNNING IF THE PLC PERMISSIVE IS REMOVED. THE PLC PERMISSIVE WILL BE REMOVED IF AN EFSSO HAS OCCURRED OR IF HYDROCARBONS HAVE BEEN DETECTED IN THE SUMP. THE SUMP FLOATS SHALL BE INTRINSICALLY SAFE AND SUITABLE FOR USE IN A CLASS 1 DIVISION 1 GROUP D HAZARDOUS LOCATION. THE SUMP PANEL SHALL BE UL LISTED TO 508A AND UL 698A.
- 3 SUBMIT PANEL DRAWINGS FOR APPROVAL. THE SUMP PANEL SHALL BE UL LISTED TO UL 508A AND UL698A (I.S. CIRCUITS).
- 4 HORSEPOWER BASED ON 1994 RECORD DRAWING, M2 "BULK FUEL STORAGE EXPANSION 94-1014"
- 5 INVESTIGATE EXISTING MOTOR NAMEPLATE HORSEPOWER, FULL LOAD CURRENT, TRIP SETTING ON MOTOR CIRCUIT PROTECTOR, HEATER MODEL NUMBER AND CONDUCTOR SIZES. DISCUSS RESULTS WITH ENGINEER.
- 6 FLOAT CONTACTS OPEN ON RISING LEVEL / ABOVE SET POINT.
- 7 FLOAT CONTACTS OPEN ON FALLING LEVEL / BELOW SET POINT.
- 8 PLC PERMISSIVE CONTACTS ARE NORMALLY OPEN CONTACTS. CONTACTS OPEN WHEN AN EFSSO HAS OCCURRED OR HYDROCARBONS ARE DETECTED WITHIN SUMP.

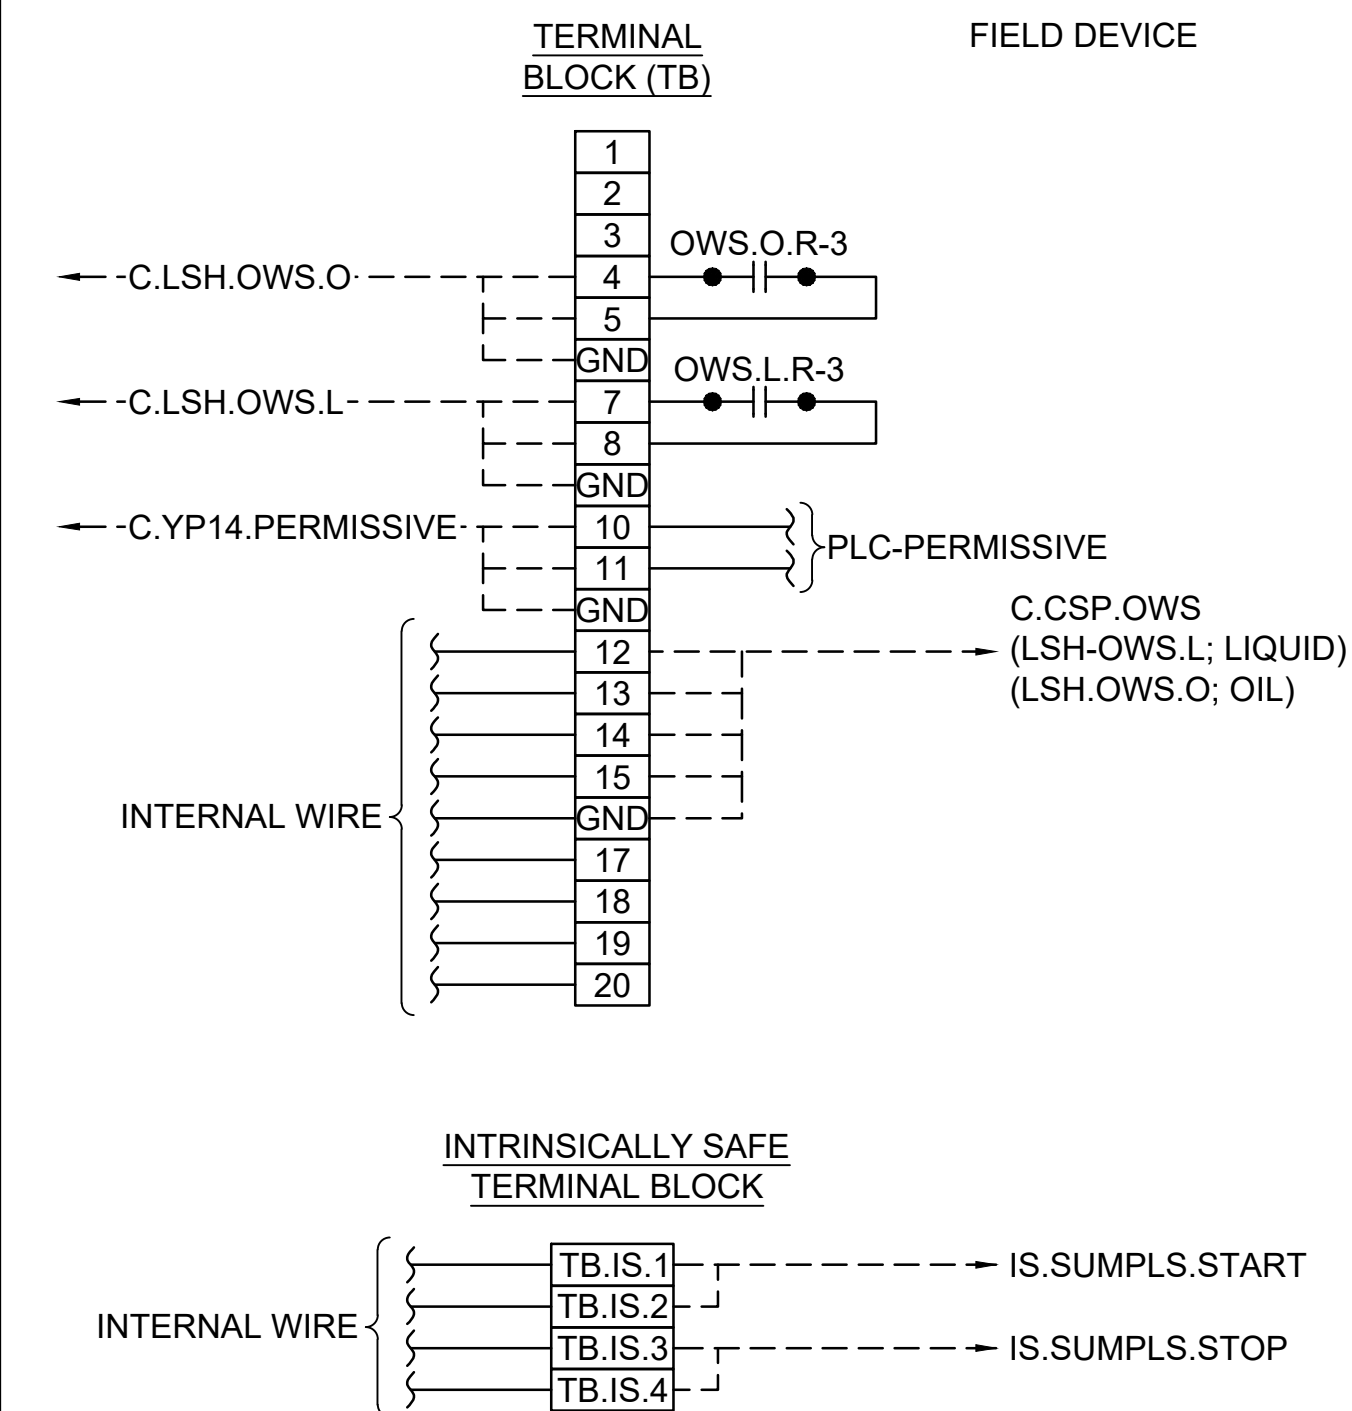

no.	date	by	ckd	description
A	12/21/23	TSR	BAW	ISSUED FOR PERMIT

**ISSUED FOR PERMIT
ONLY**



9400 WARD PARKWAY
KANSAS CITY, MO 64114
816-333-9400
s & McDonnell Engineering Co, Inc.

date 04/24/2023	detailed S. JESBERG
designed T. RENSHAW	checked B. WINTER


PDX FUEL COMPANY L.L.C

PORTLAND INTERNATIONAL AIRPORT
5000 NE MARINE DR.
PORTLAND, OREGON 97218

PDX FACILITY IMPROVEMENTS
OWS LIFT STATION

project	contract
153929	
drawing	rev.

file 153929E-606.dwg

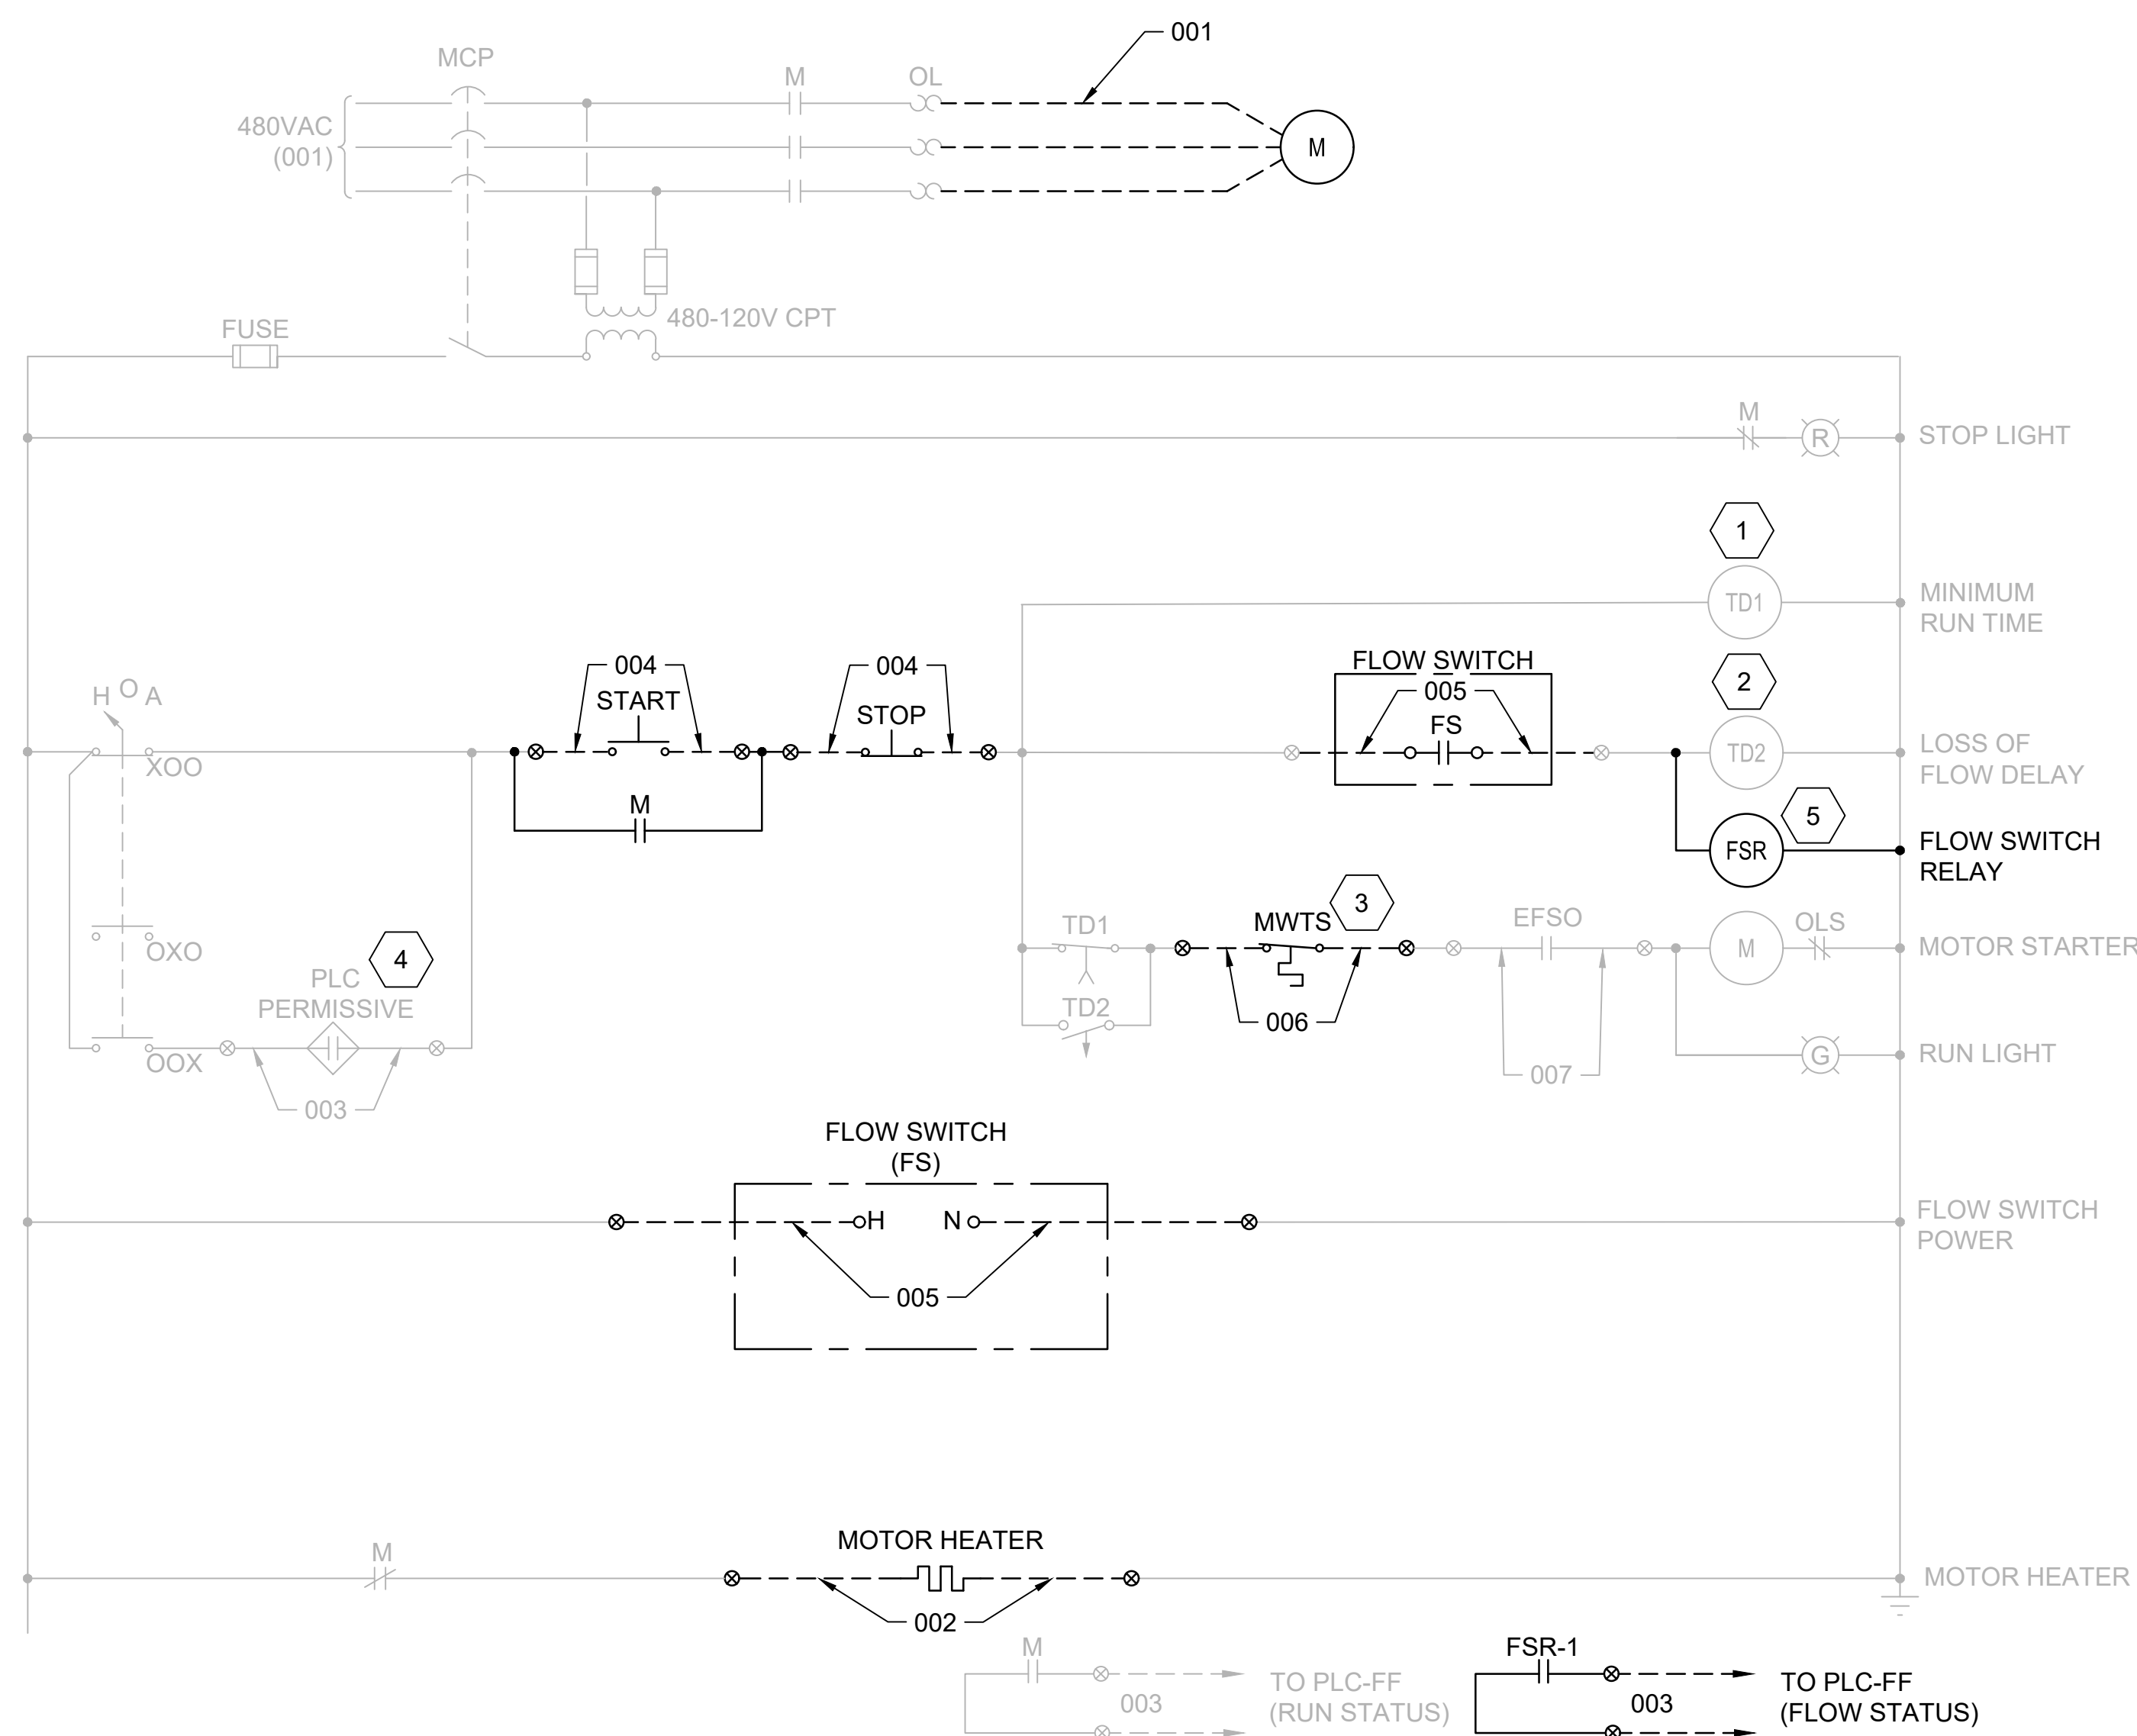

CORRESPONDING CIRCUIT NUMBERS							
	001	002	003	004	005	006	007
OP-1	P.MCC1.OP1	C.HTR.OP1	C.FSC.OP1	C.HS.OP1	C.FS.OP1	C.MWTS.OP1	C.EFSO.MCC.OP1
OP-2	P.MCC1.OP2	C.HTR.OP2	C.FSC.OP2	C.HS.OP2	C.FS.OP2	C.MWTS.OP2	C.EFSO.MCC.OP2

DETAIL

WIRING DIAGRAM -
MOTOR CONTROLLER
(OP-1) (OP-2)
NOT TO SCALE

1

- NOTES:**

1. SEE SHEET E-001 FOR GENERAL NOTES, LEGEND AND ABBREVIATIONS.

KEYED NOTES:

- 1 TD1 CONTACT SHALL BE NORMALLY CLOSED, DELAY TO OPEN WHEN TD1 RELAY IS ENERGIZED. DELAY SHALL BE ADJUSTABLE FROM 1-60 SECONDS. INITIAL SETTING SHALL BE 10 SECONDS, ADJUST AS NECESSARY.
- 2 TD2 CONTACT SHALL BE NORMALLY OPEN, CLOSING ON TD2 ENERGIZATION AND DELAY TO OPEN ON TD2 DE-ENERGIZATION. DELAY SHALL BE ADJUSTABLE FROM 1-60 SECONDS. INITIAL SETTING SHALL BE 5 SECONDS, ADJUST AS NECESSARY.
- 3 MOTOR WINDING TEMPERATURE SWITCH. WINDING TEMPERATURE SWITCH SHALL BE WIRED DIRECTLY BETWEEN THE OFFLOAD PUMP AND THE MOTOR CONTROL BUCKET.
- 4 PLC PERMISSIVE SHALL BE PROGRAMMED SUCH THAT THE OFFLOAD PUMP SHALL NOT BE ALLOWED TO START OR SHALL BE DE-ENERGIZED IF THE TANK HIGH-HIGH LEVEL ALARM IS DETECTED ON THE RECEIVING TANK.
- 5 INSTALL NEW RELAY FOR FLOW SWITCH STATUS.

no.	date	by	ckd	description
A	12/21/23	TSR	BAW	ISSUED FOR PERMIT

**ISSUED FOR PERMIT
ONLY**



9400 WARD PARKWAY
KANSAS CITY, MO 64114
816-333-9400
s & McDonnell Engineering Co.

date	detailed
04/24/2023	S. JESBERG
designed	checked
T. RENSHAW	B. WINTER


PDX FUEL COMPANY L.L.C

PORTLAND INTERNATIONAL AIRPORT
5000 NE MARINE DR.
PORTLAND, OREGON 97218

PDX FACILITY IMPROVEMENTS OFFLOAD PUMP SCHEMATIC

project	contract
153929	
drawing	rev.

file 153929E-612.dwg

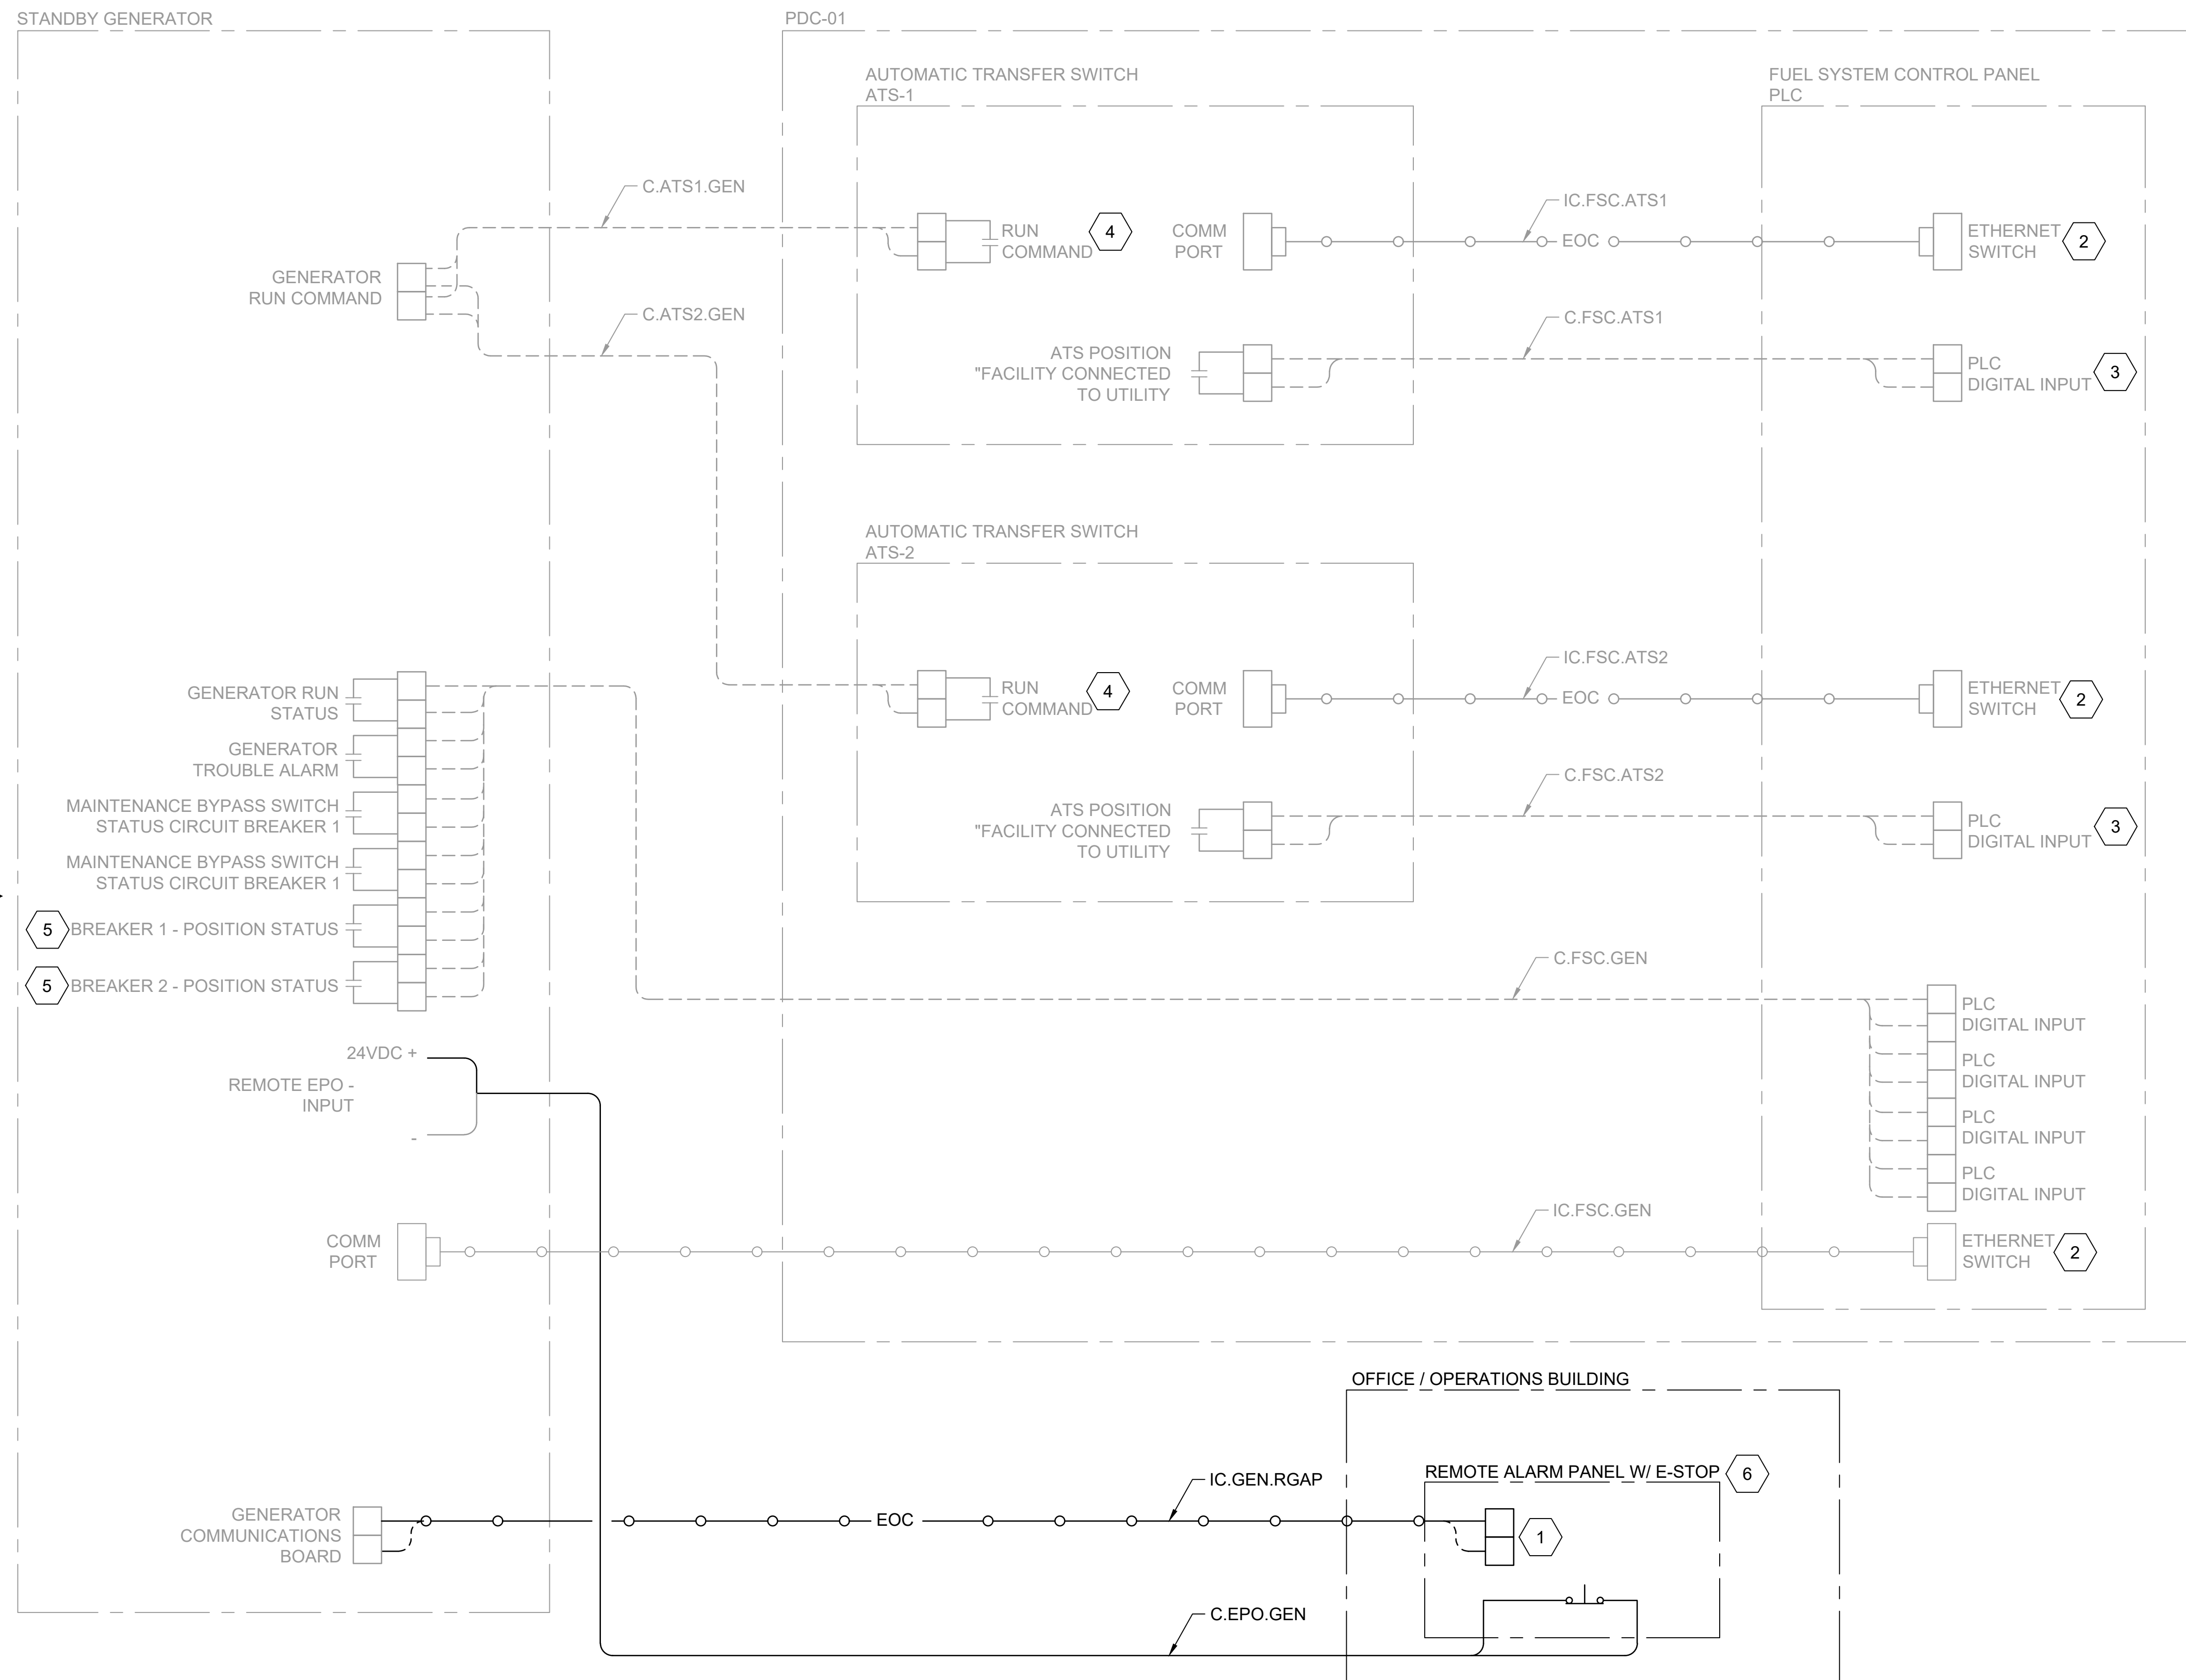

NOTES:

1. SEE SHEET E-001 FOR GENERAL NOTES, LEGEND AND ABBREVIATIONS.

KEYED NOTES:

- 1 SEE SPECIFICATION 25 90 01, 3.09 FOR NOTIFICATION REQUIREMENTS. THE FOLLOWING SIGNALS ARE RECEIVED:
 1. LUBE OIL TEMPERATURE HIGH
 2. LUBE OIL LOW PRESSURE
 3. WATER JACKET TEMPERATURE HIGH
 4. WATER JACKET TEMPERATURE LOW
 5. FUEL LEVEL LOW
 6. LOW COOLANT LEVEL
 7. OVERSPEED
 8. OVERCRANK
- 2 SEE SPECIFICATION 25 90 01, 3.09 FOR NOTIFICATION REQUIREMENTS. THE FOLLOWING SIGNALS ARE RECEIVED:
 1. FACILITY CONNECTED TO NORMAL POWER
 2. FACILITY CONNECTED TO DIESEL GENERATOR POWER
- 3 WIRED NORMALLY OPEN.
CONTACT CLOSED = "FACILITY CONNECTED TO UTILITY"
CONTACT OPEN = "FACILITY NOT CONNECTED TO UTILITY"
- 4 WIRED NORMALLY OPEN.
CONTACT CLOSED = "START GENERATOR"
CONTACT OPEN = "STOP GENERATOR"
- 5 WIRED NORMALLY OPEN.
CONTACT CLOSED = "BREAKER CLOSED"
CONTACT OPEN = "BREAKER OPEN"
- 6 PROVIDE 120V POWER FROM NEAREST SOURCE

LEGEND (THIS SHEET ONLY):

— — — WIRING PROVIDED BY SUBCONTRACTOR

no.	date	by	ckd	description
A	12/21/23	TSR	BAW	ISSUED FOR PERMIT

**ISSUED FOR PERMIT
ONLY**



9400 WARD PARKWAY
KANSAS CITY, MO 64114
816-333-9400

Burns & McDonnell Engineering Co, Inc.

date	detailed
04/24/2023	S. JESBERG
designed	checked
T. RENSHAW	B. WINTER

PDX FUEL COMPANY L.L.C

PORTLAND INTERNATIONAL AIRPORT
5000 NE MARINE DR.
PORTLAND, OREGON 97218

PDX FACILITY IMPROVEMENTS

WIRING DIAGRAM - GENERATORS


project	contract
153929	
drawing	rev.

file 153929E-618.dwg

Millimeters

Scale For Microfilming

Inches

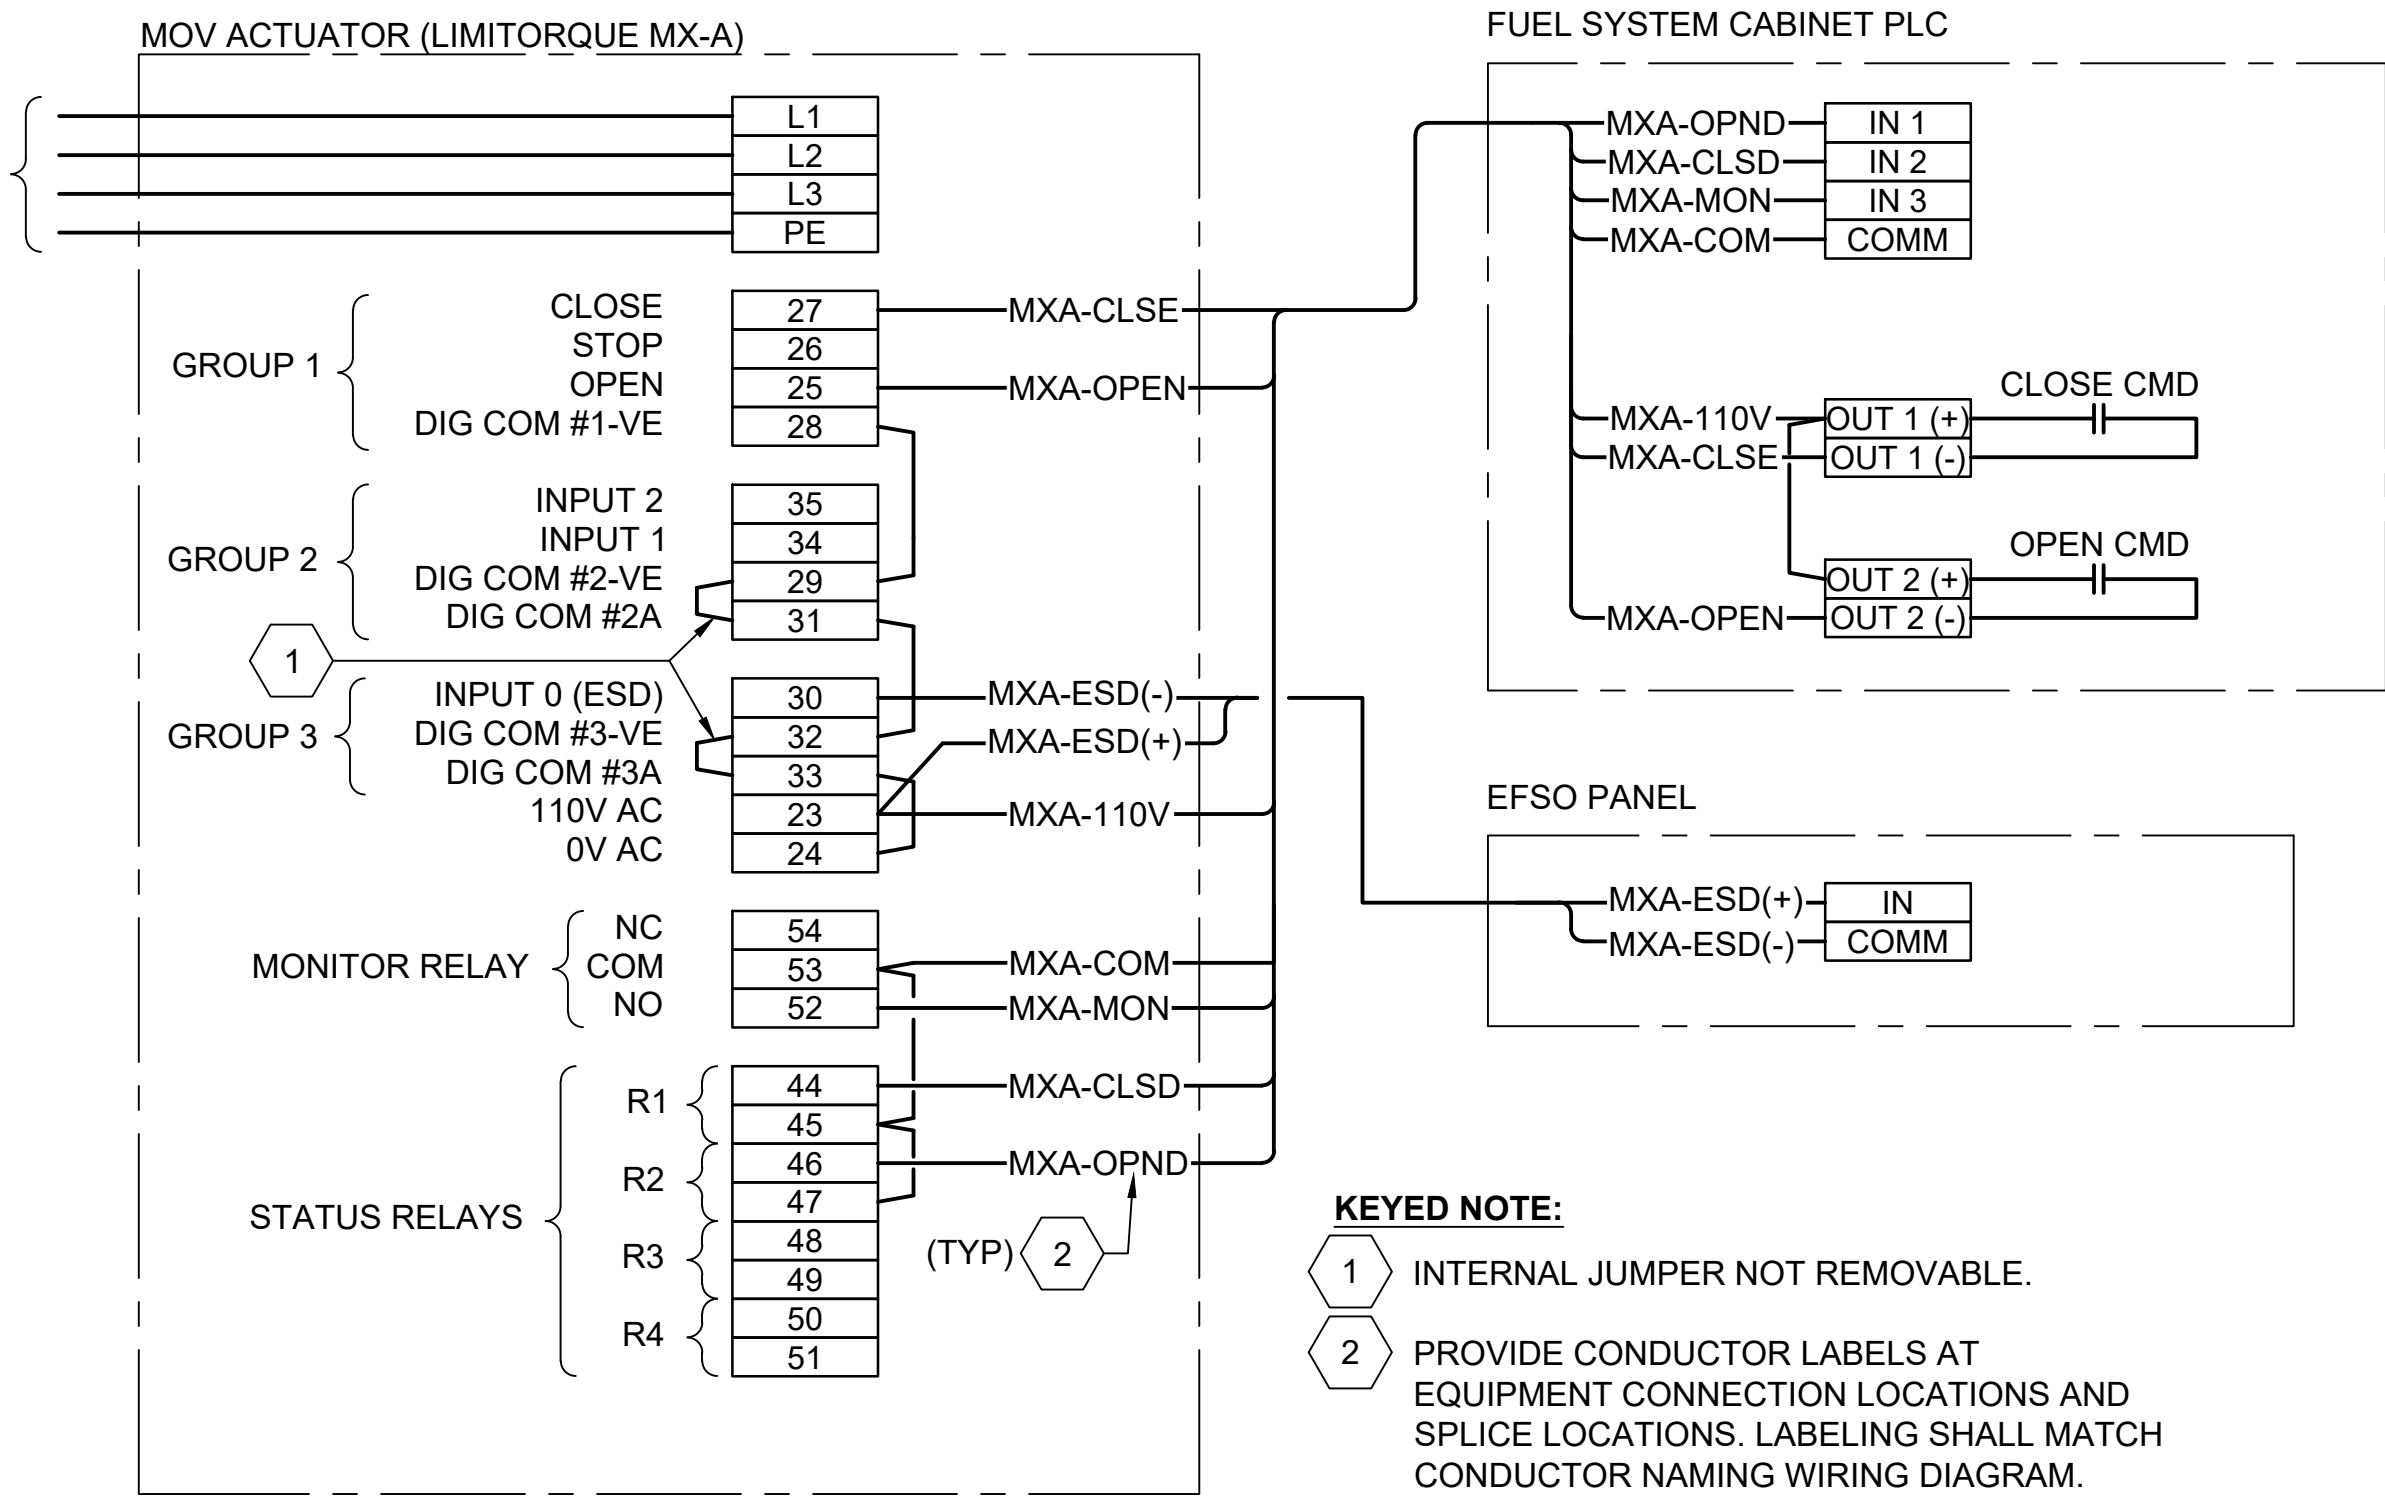

KEYED NOTE:


1 INTERNAL JUMPER NOT REMOVABLE.

2 PROVIDE CONDUCTOR LABELS AT EQUIPMENT CONNECTION LOCATIONS AND SPLICE LOCATIONS. LABELING SHALL MATCH CONDUCTOR NAMING WIRING DIAGRAM.

DIAGRAM

1
-

WIRING DIAGRAM -
RECLAIM TANK SUCTION
NOZZLE MOV
NOT TO SCALE

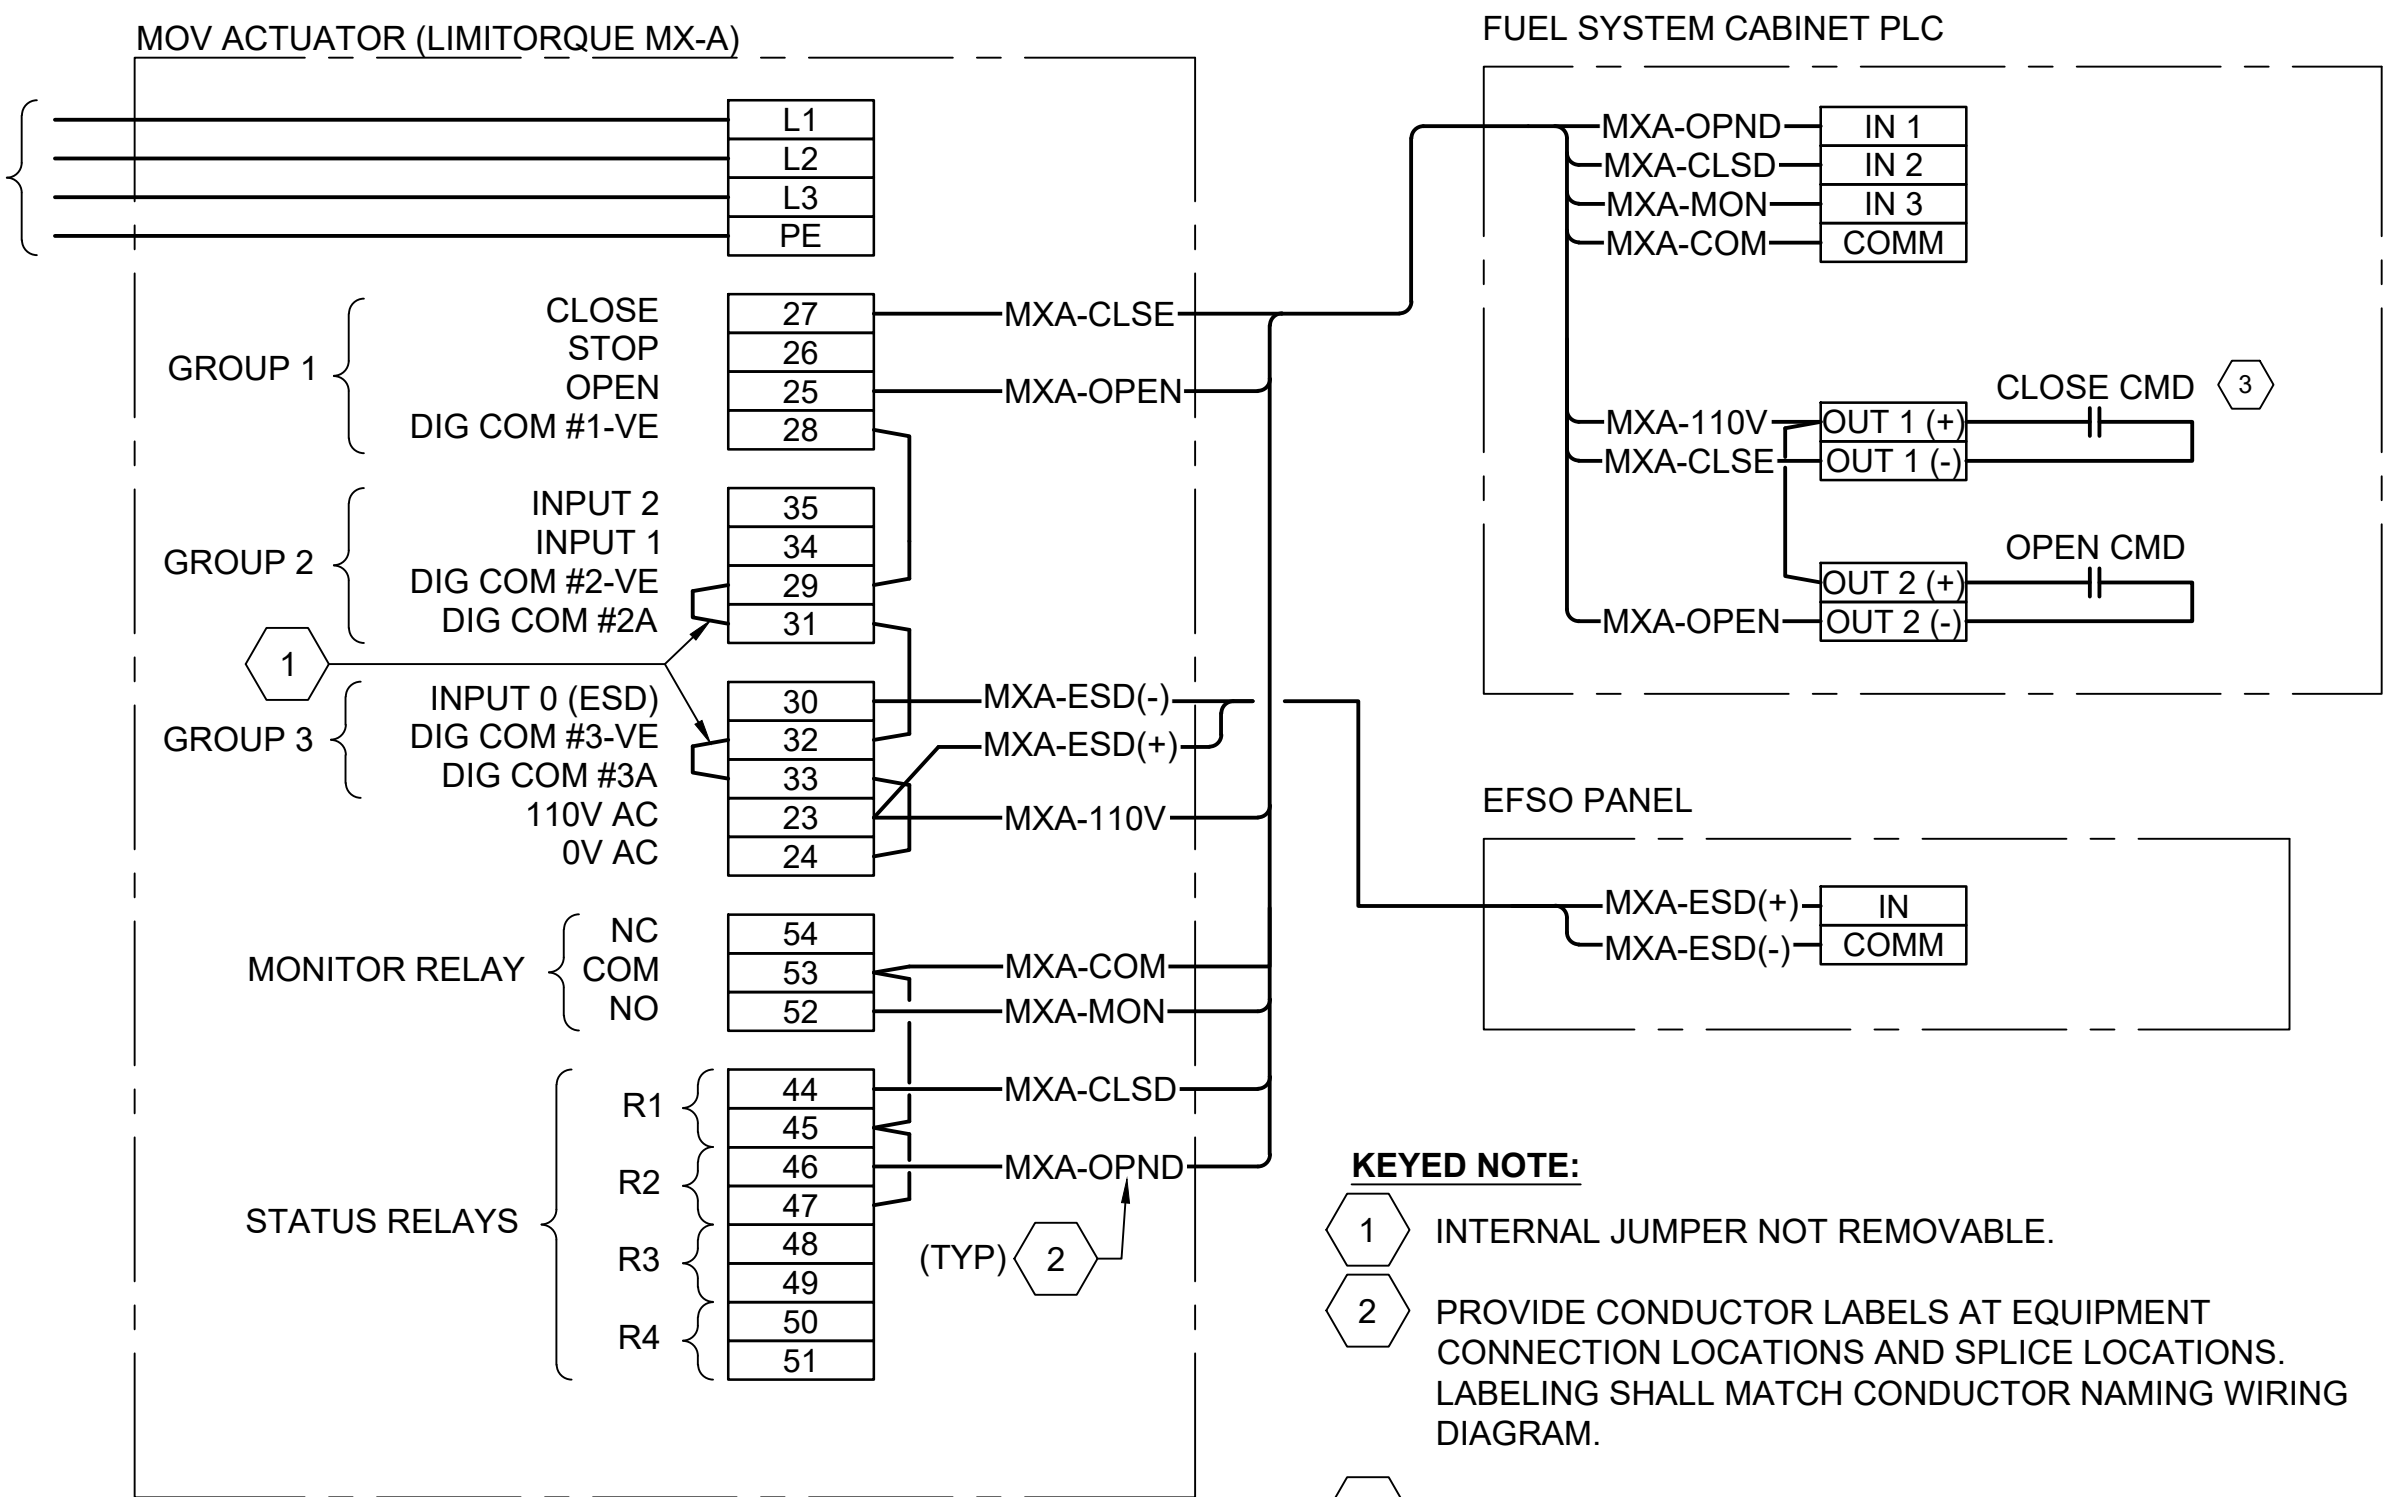

KEYED NOTE:

1 INTERNAL JUMPER NOT REMOVABLE.


2 PROVIDE CONDUCTOR LABELS AT EQUIPMENT CONNECTION LOCATIONS AND SPLICE LOCATIONS. LABELING SHALL MATCH CONDUCTOR NAMING WIRING DIAGRAM.

3 HCTS LSHH LEVEL SWITCH SHALL INTERLOCK WITH THE CLOSE COMMAND SUCH THAT THE MOV SHALL CLOSE IF THE LEVEL SWITCH IS ACTIVATED AND SHALL NOT OPEN AGAIN UNTIL THE LEVEL SWITCH IS DEACTIVATED.

DIAGRAM

2
-


WIRING DIAGRAM -
RECLAIM TANK FILL NOZZLE MOV
NOT TO SCALE

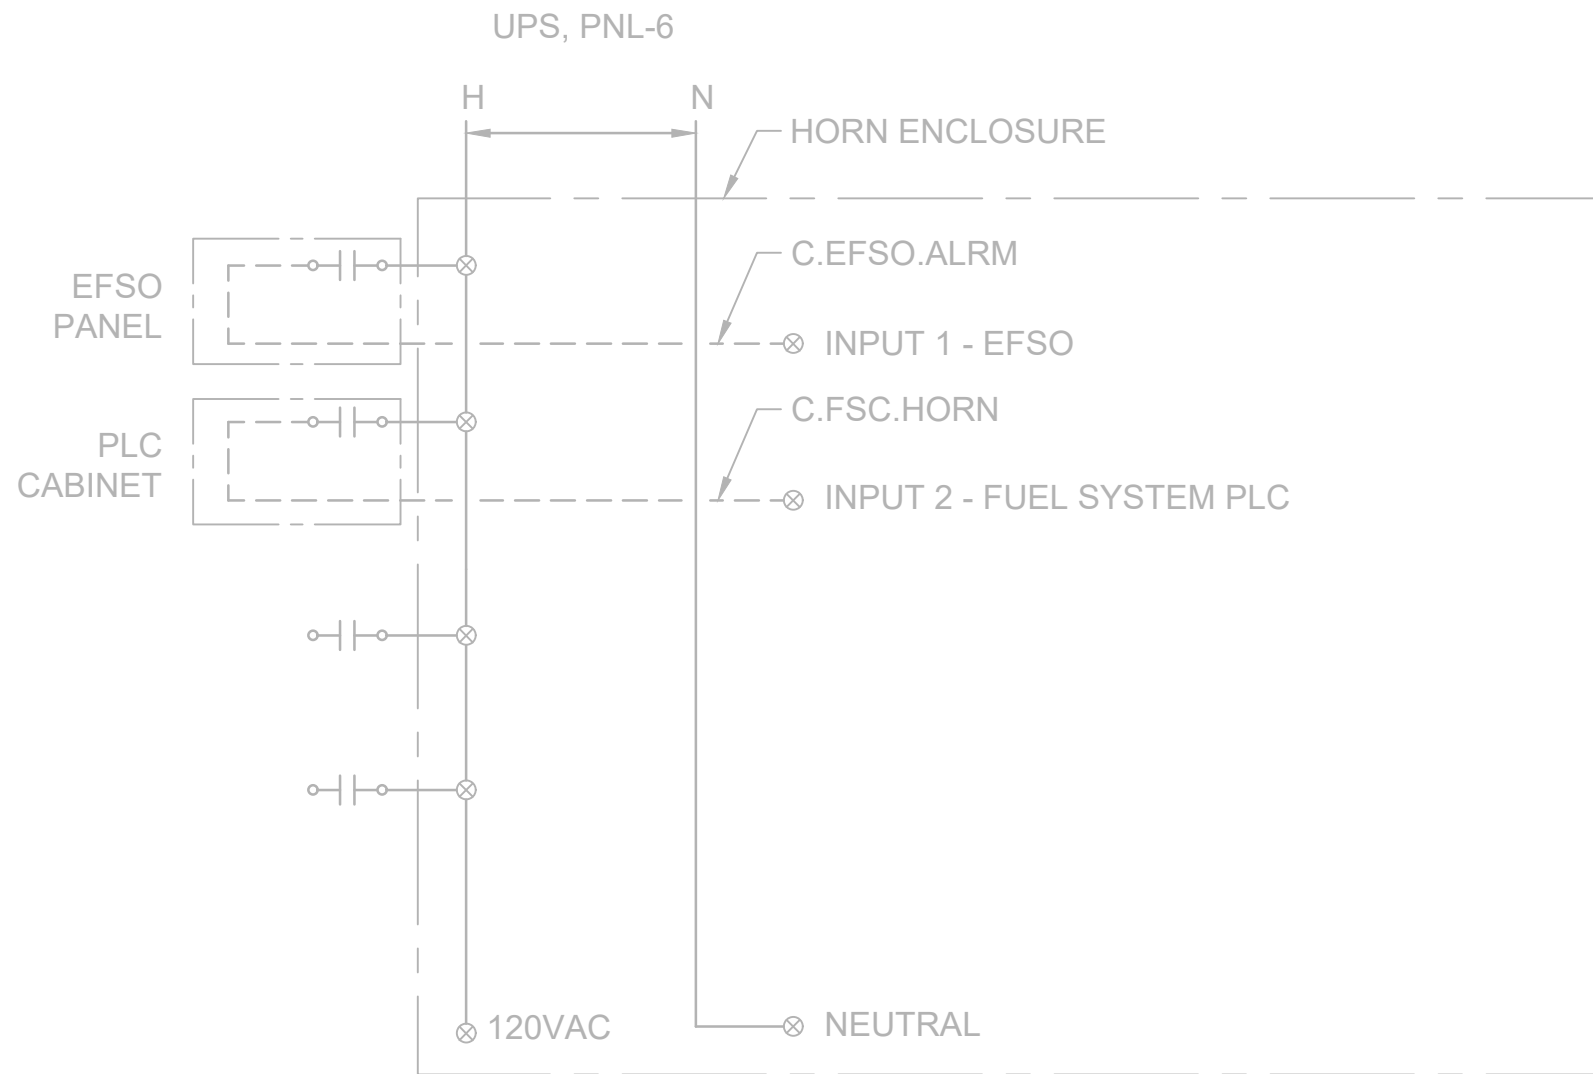

DIAGRAM

3
-

ALARM HORN
WIRING DIAGRAM
NOT TO SCALE

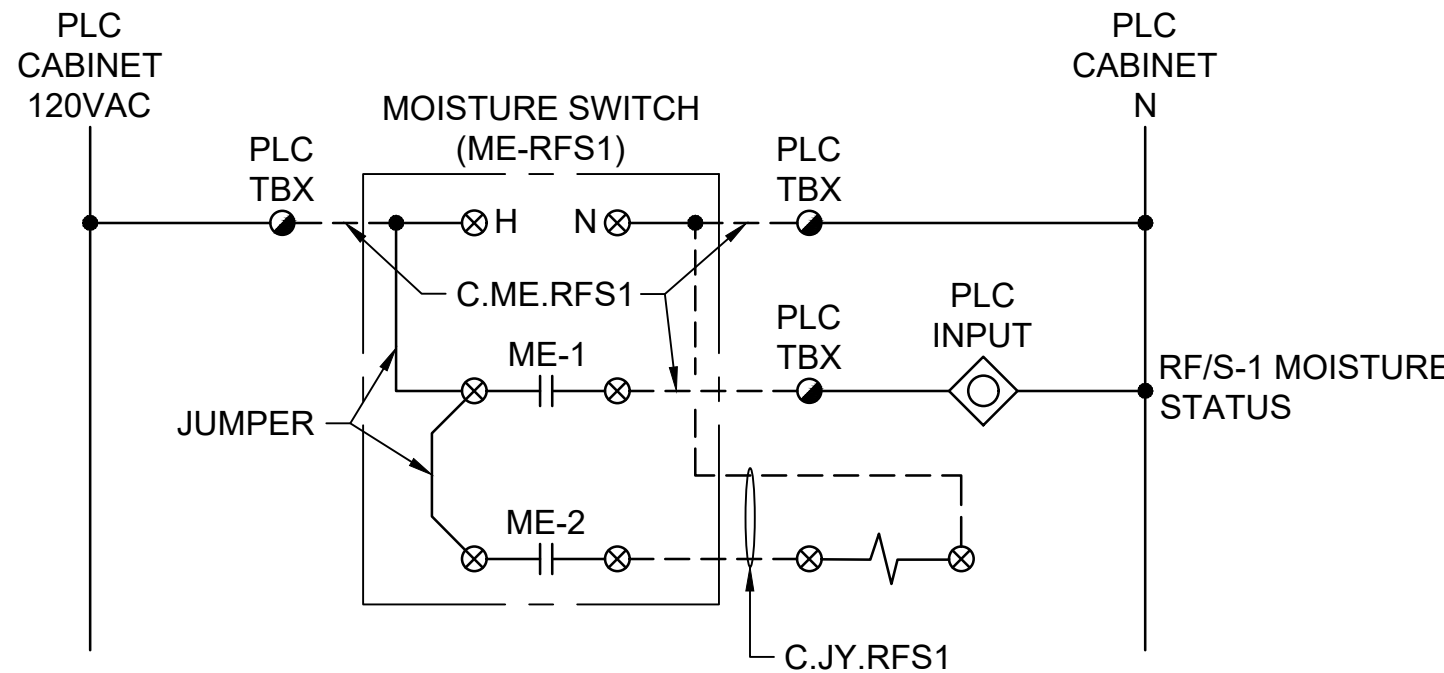

DIAGRAM

4
-

MOISTURE SENSOR - RECLAIM
FILTER SEPARATOR
NOT TO SCALE

NOTES:

1. SEE SHEET E-001 FOR GENERAL NOTES, LEGEND AND ABBREVIATIONS.

LEGEND (THIS SHEET ONLY):

● PLC TERMINAL FOR FIELD WIRING

no.	date	by	ckd	description
A	12/21/23	TSR	BAW	ISSUED FOR PERMIT

ISSUED FOR PERMIT
ONLY

**BURNS
MCDONNELL**

9400 WARD PARKWAY
KANSAS CITY, MO 64114
816-333-9400
Burns & McDonnell Engineering Co., Inc.

date	04/24/2023	detailed	S. JESBERG
designed	T. RENSHAW	checked	B. WINTER

PDX FUEL COMPANY L.L.C

PORTLAND INTERNATIONAL AIRPORT
5000 NE MARINE DR.
PORTLAND, OREGON 97218

PDX FACILITY IMPROVEMENTS
WIRING DIAGRAM - MOVs

project	153929	contract	
drawing	E-619	rev.	A


file 153929E-619.dwg

KEYED NOTES:

- 1 SIZE BASED ON VENDOR EQUIPMENT SELECTIONS.
- 2 THE PANEL SHALL INCLUDE DIN-RAIL MOUNTED SURGE PROTECTION PER UL1449 WITH PLUGGABLE REPLACEABLE SPD ELEMENTS.
- 3 THE ENTIRE PANEL AND ALL ITS COMPONENTS SHALL BE LISTED AND ASSEMBLED IN A UL 508A CERTIFIED SHOP AND SHALL BE RATED FOR INSTALLATION IN CLASS 1 DIVISION 2 AREA, OUTDOOR RATED, NEMA 4X STAINLESS STEEL.

LEGEND (THIS SHEET ONLY):


- TERMINAL IN PLC OR ALARM PANEL

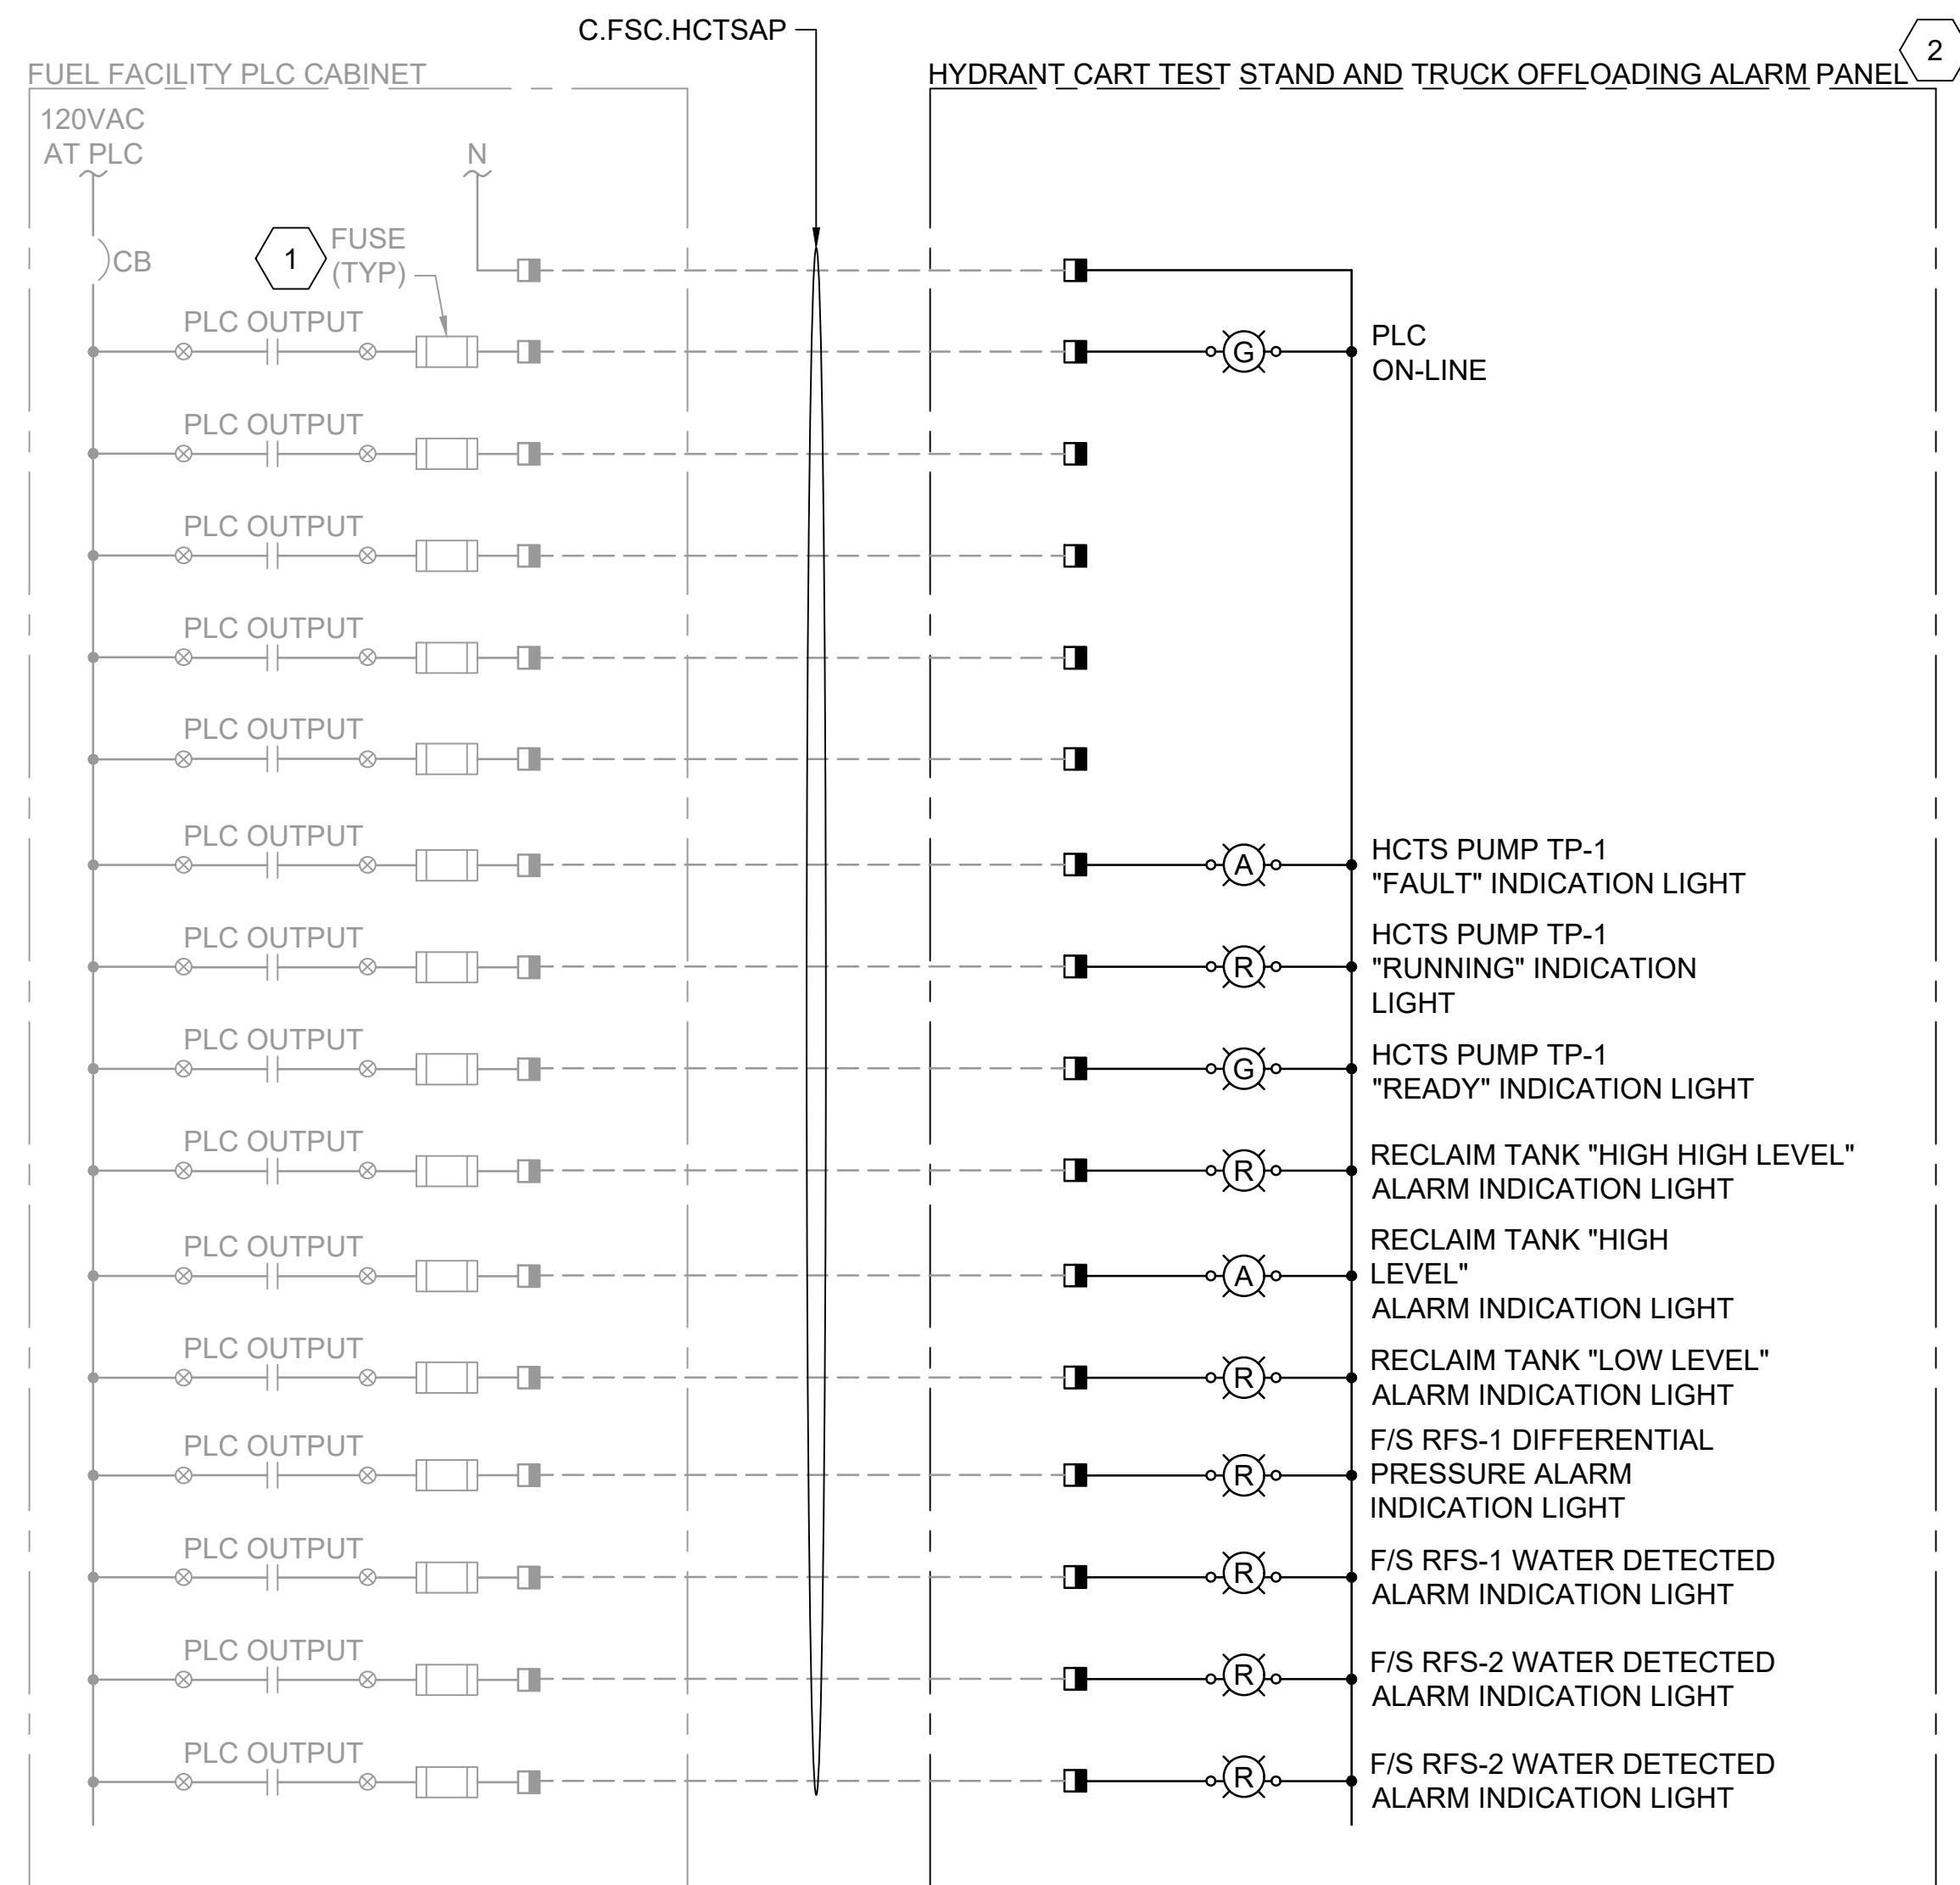

DETAIL

WIRING DIAGRAM - HCTS ALARM PANEL

NOT TO SCALE

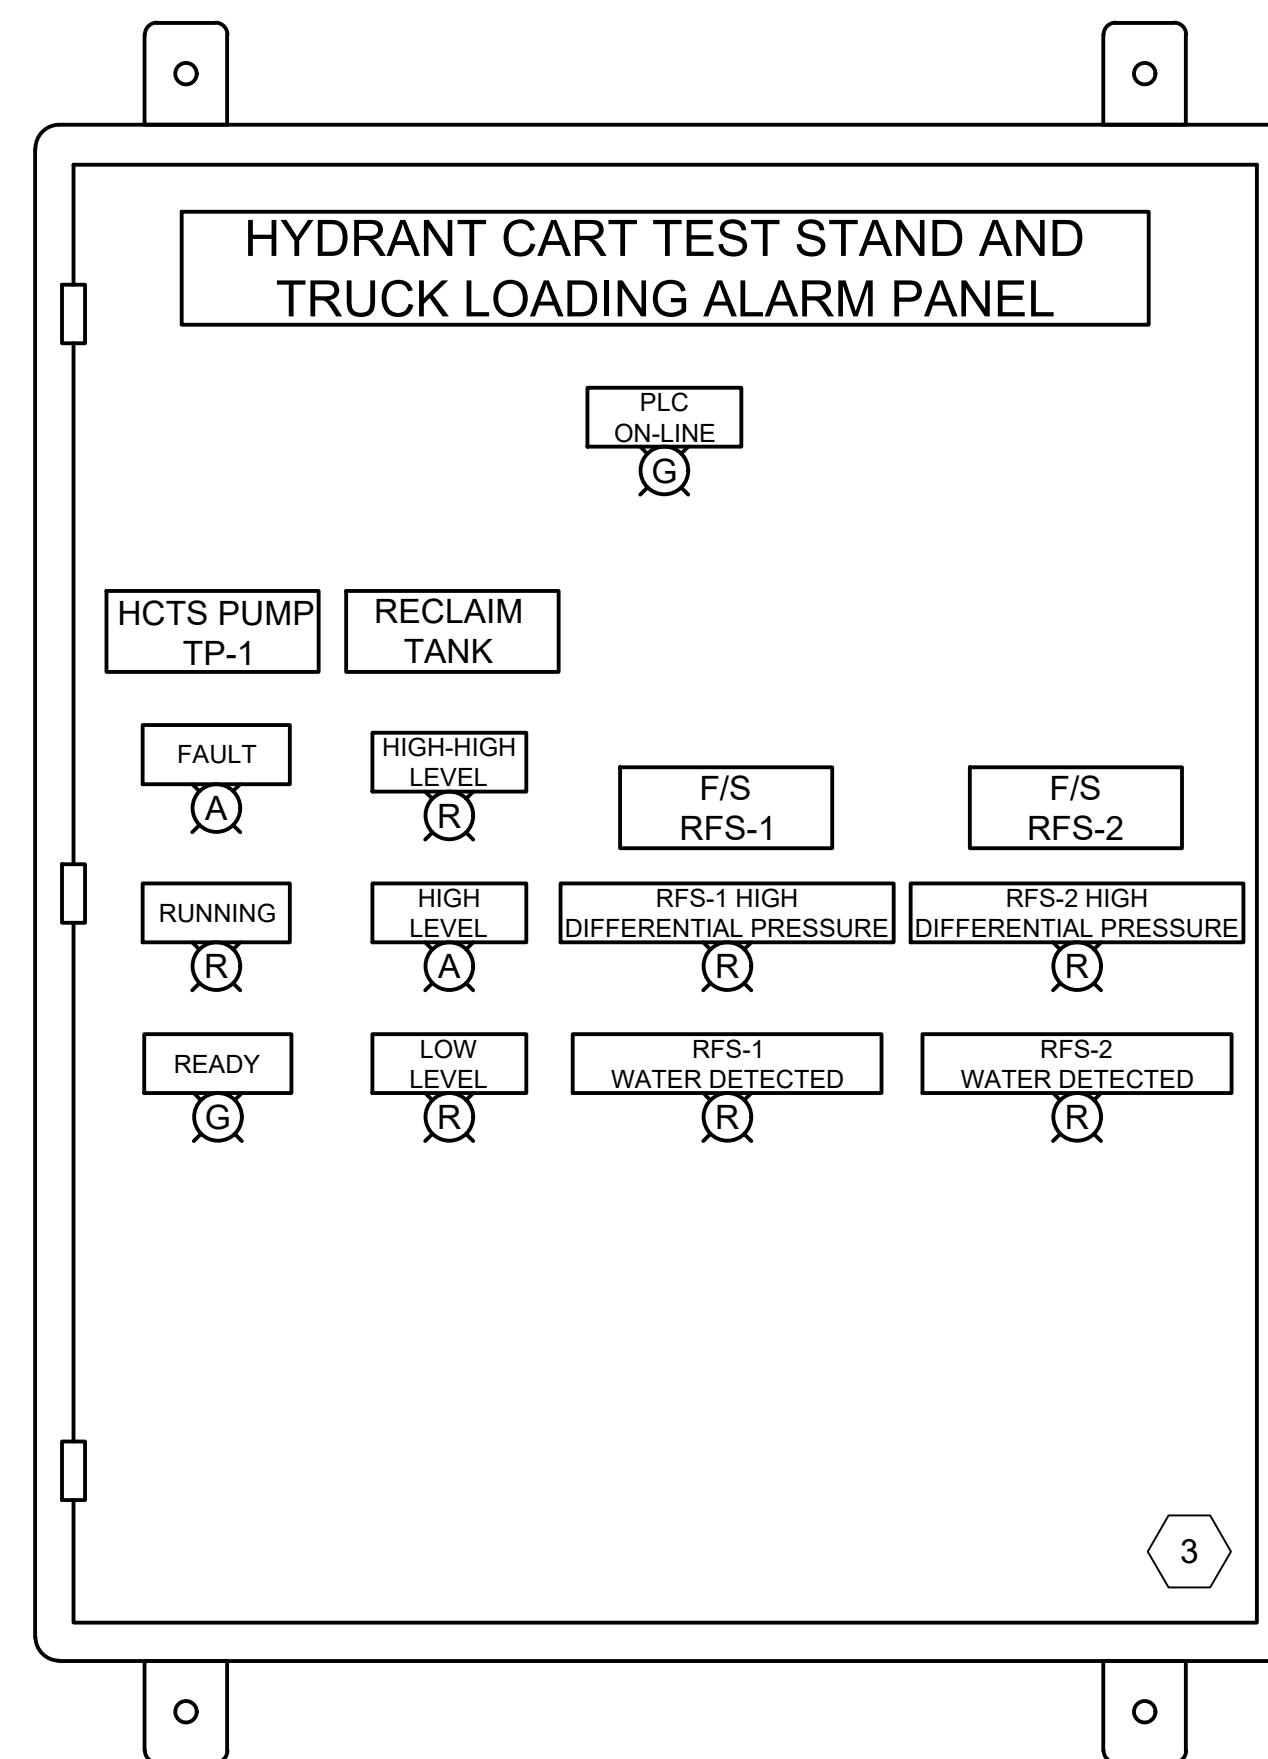

DETAIL

HCTS ALARM PANEL - EXTERIOR

NOT TO SCALE

no.	date	by	ckd	description
A	12/21/23	TSR	BAW	ISSUED FOR PERMIT

**ISSUED FOR PERMIT
ONLY**



9400 WARD PARKWAY
KANSAS CITY, MO 64114
816-333-9400

Burns & McDonnell Engineering Co, Inc.

date	detailed
04/24/2023	S. JESBERG
designed	checked
T. RENSHAW	B. WINTER

PDX FUEL COMPANY L.L.C

PORTLAND INTERNATIONAL AIRPORT
5000 NE MARINE DR.
PORTLAND, OREGON 97218


PDX FACILITY IMPROVEMENTS

HCTS CONTROL PANEL WIRING DIAGRAM

project	contract
153929	
drawing	rev.

file 153929E-620.dwg

Millimeters
Scale For Microfilming
Inches

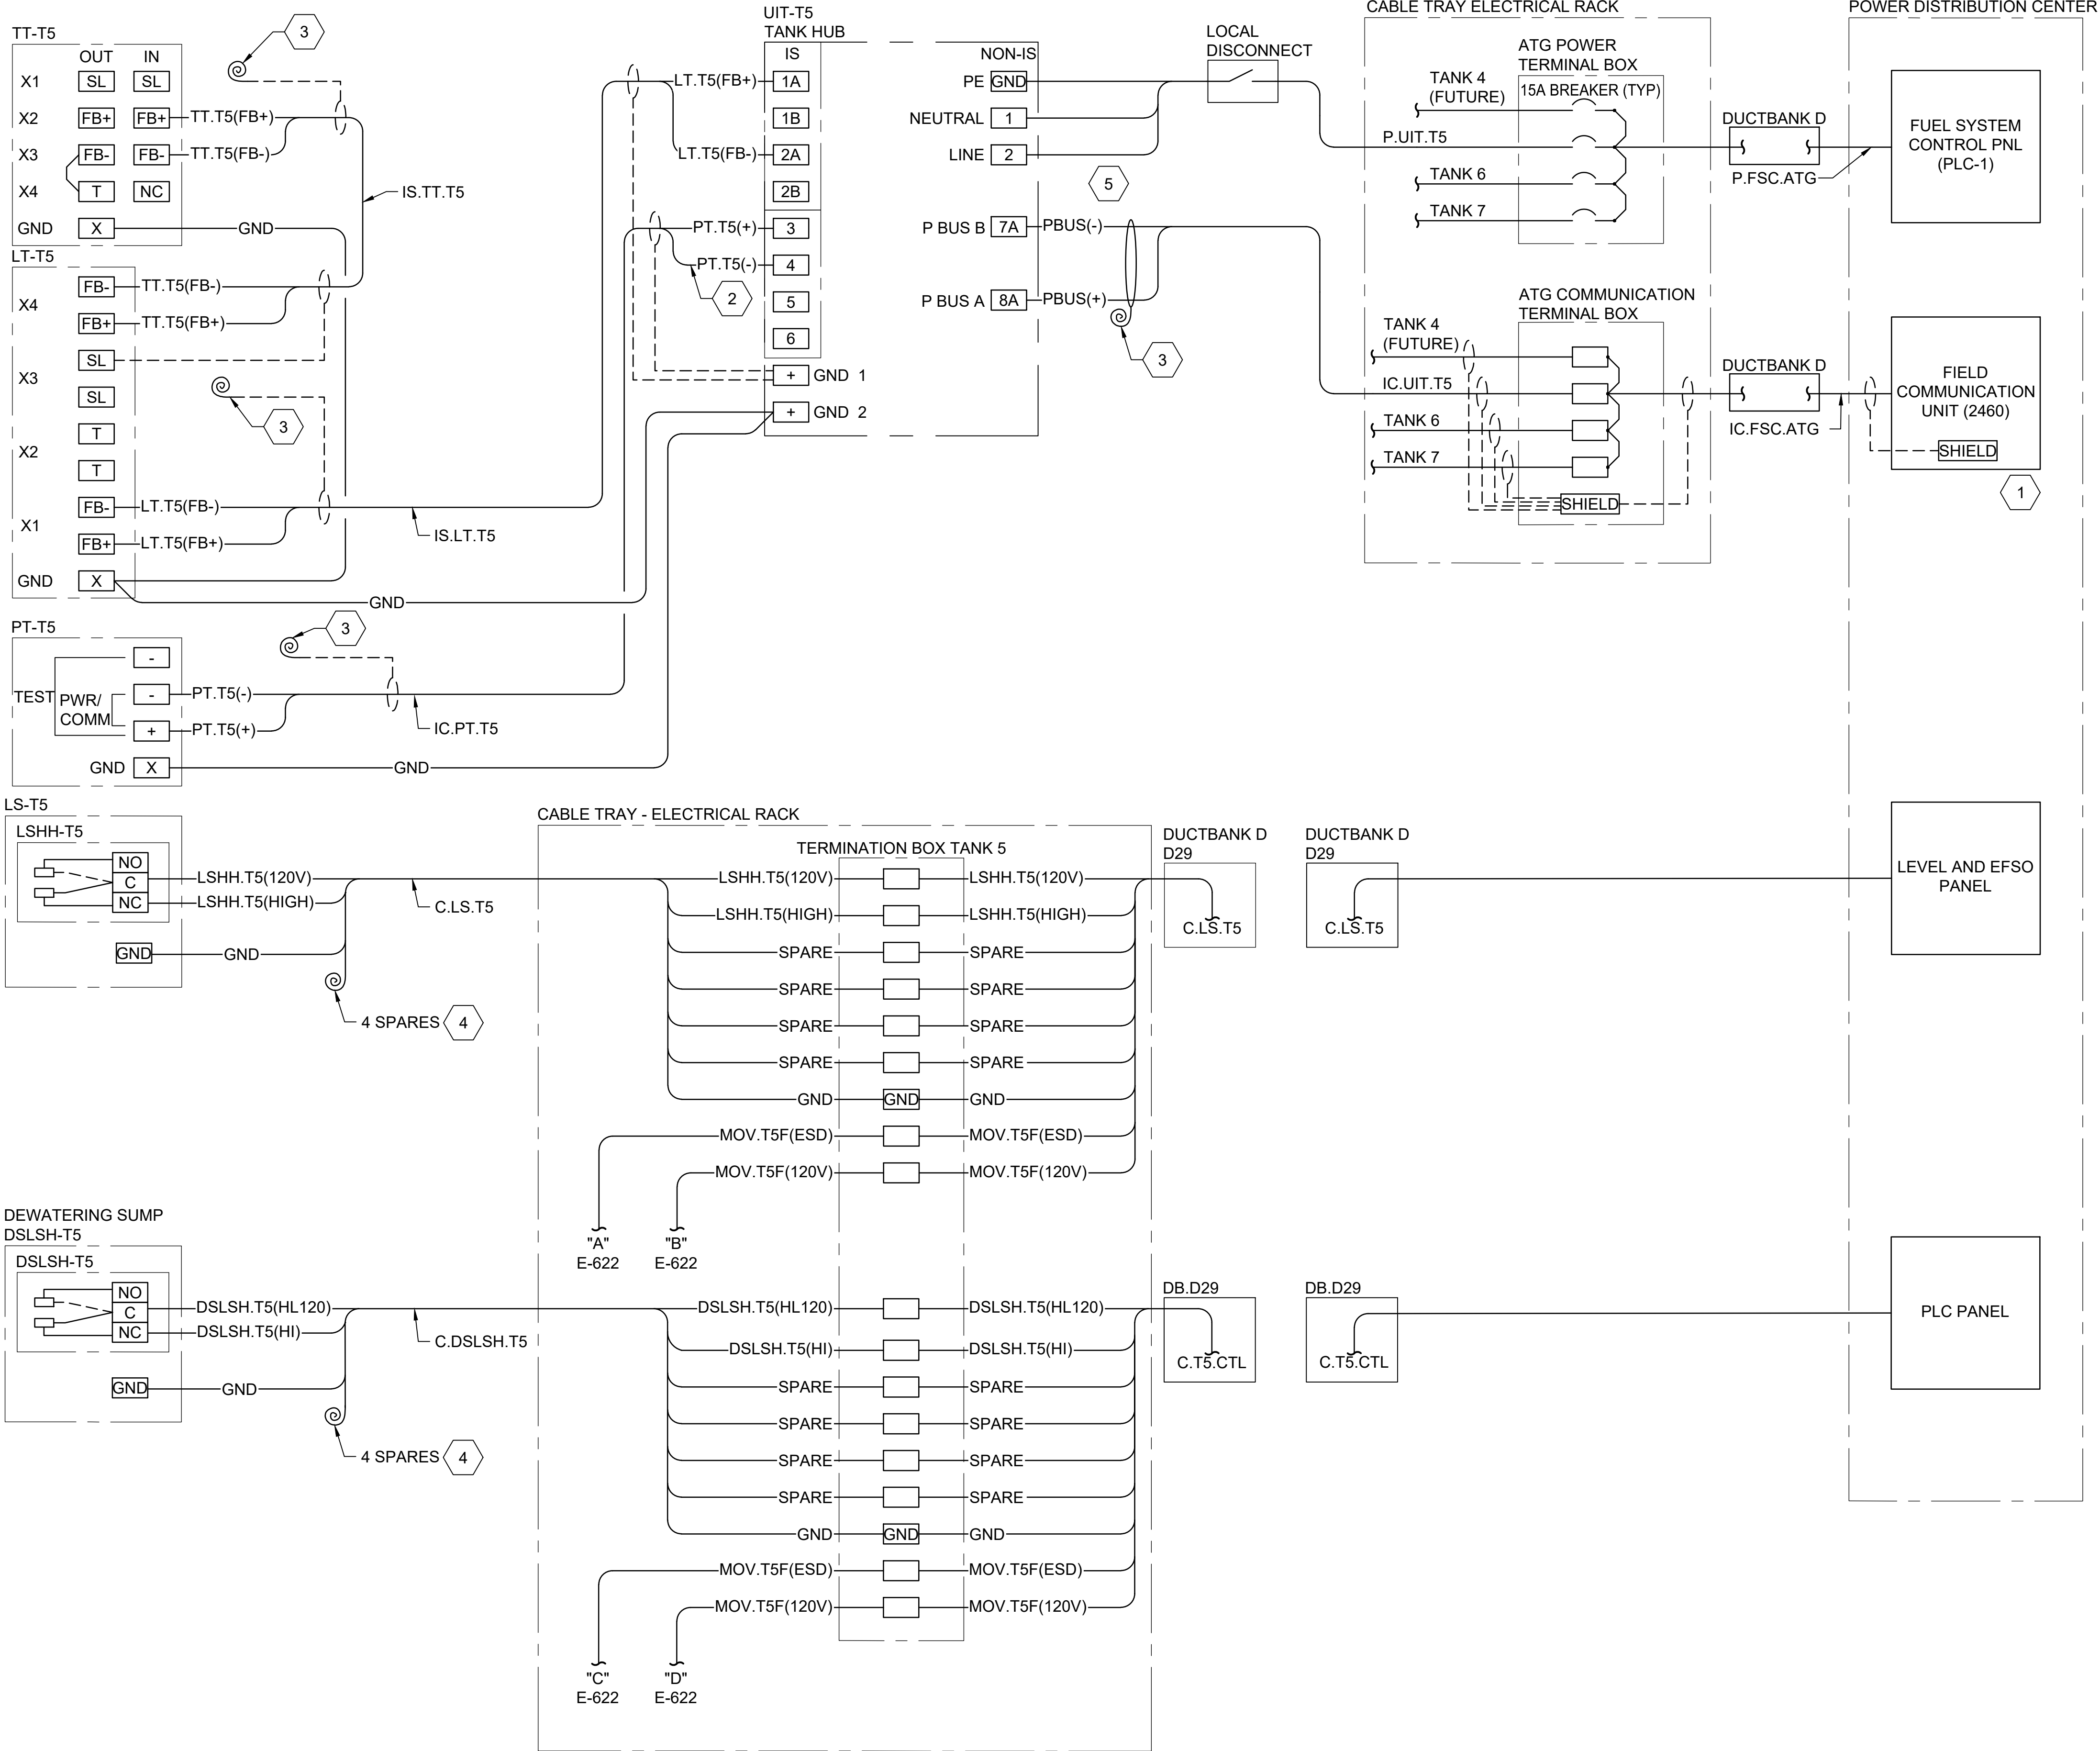

- NOTES:**
1. WIRING SHOWN IS THAT OF JET FUEL TANK 5 (T5). FOR CLARITY THE TAGS AND DESCRIPTORS SHOWN ARE SPECIFIC TO T5.
 2. THE WIRING DIAGRAM CONVEYS OVERALL QUANTITIES AND ORIGINATION OF SYSTEM SIGNALS. CONSULT THE EQUIPMENT MANUFACTURERS LITERATURE FOR EXACT TERMINATION POINTS.
- KEYED NOTES:**
- 1 SEE EI653 RISER DIAGRAM FOR COMMUNICATION INTERCONNECTIONS.
 - 2 HART 4-20MA SIGNAL USED FOR PT.
 - 3 TAPE SHIELD BACK
 - 4 TAPE CONDUCTORS AND LEAVE AS SPARES
 - 5 SPLICE CABLES SHIELDS TOGETHER. ENSURE SHIELDS ARE ISOLATED FROM TOUCHING ANY PART OF ENCLOSURE.

no.	date	by	ckd	description
A	12/21/23	TSR	BAW	ISSUED FOR PERMIT

ISSUED FOR PERMIT
ONLY



9400 WARD PARKWAY
KANSAS CITY, MO 64114
816-333-9400
Burns & McDonnell Engineering Co., Inc.

date	04/24/2023	detailed	S. JESBERG
designed	T. RENSHAW	checked	B. WINTER

PDX FUEL COMPANY L.L.C


PORTLAND INTERNATIONAL AIRPORT
5000 NE MARINE DR.
PORTLAND, OREGON 97218

PDX FACILITY IMPROVEMENTS
CONTROL DIAGRAM - TANK 5 - ATG

project	153929	contract	
drawing	E-621	rev.	A

file 153929E-621.dwg

Millimeters
Inches
Scale For Microfilming

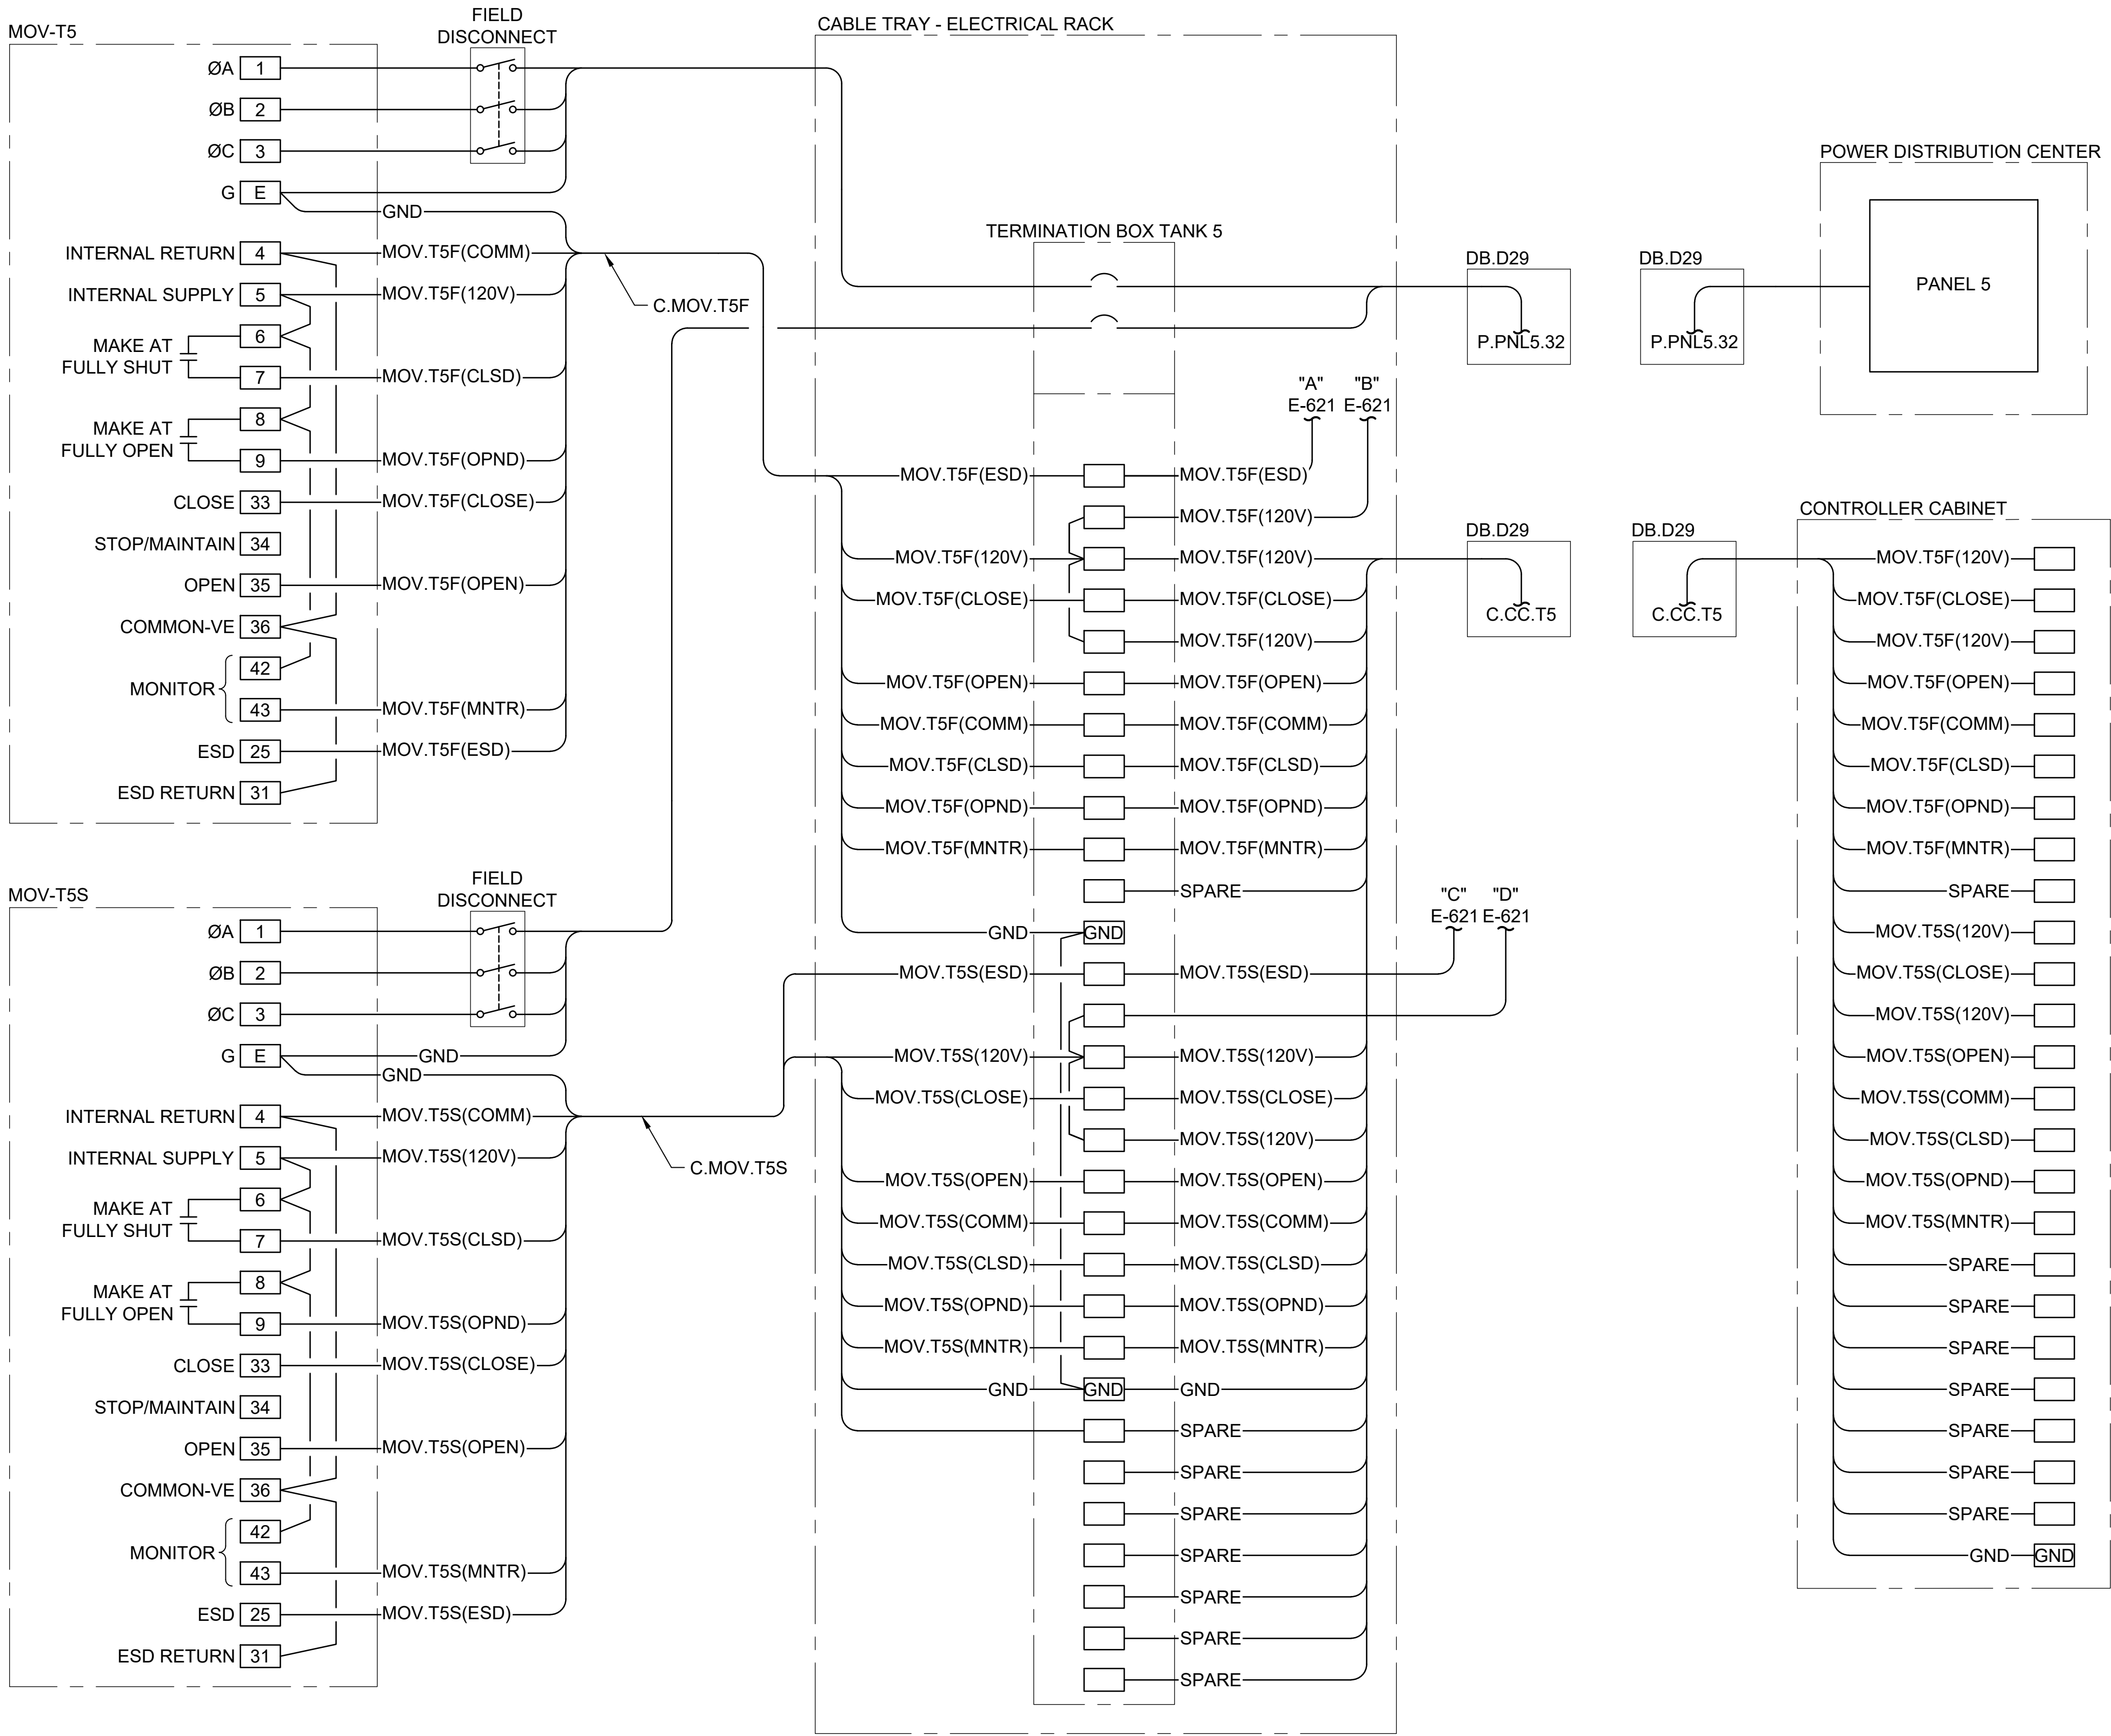

- NOTES:**
1. WIRING SHOWN IS THAT OF JET FUEL TANK 5 (T5). FOR CLARITY THE TAGS AND DESCRIPTORS SHOWN ARE SPECIFIC TO T5.
 2. THE WIRING DIAGRAM CONVEYS OVERALL QUANTITIES AND ORIGATION OF SYSTEM SIGNALS. CONSULT THE EQUIPMENT MANUFACTURERS LITERATURE FOR EXACT TERMINATION POINTS.

no.	date	by	ckd	description
A	12/21/23	TSR	BAW	ISSUED FOR PERMIT

**ISSUED FOR PERMIT
ONLY**



9400 WARD PARKWAY
KANSAS CITY, MO 64114
816-333-9400
Burns & McDonnell Engineering Co., Inc.

date	04/24/2023	detailed	S. JESBERG
designed	T. RENSHAW	checked	B. WINTER

PDX FUEL COMPANY L.L.C

PORTLAND INTERNATIONAL AIRPORT
5000 NE MARINE DR.
PORTLAND, OREGON 97218


PDX FACILITY IMPROVEMENTS
CONTROL DIAGRAM - TANK 5 - MOV

project	153929	contract	
drawing	E-622	rev.	A


file 153929E-622.dwg





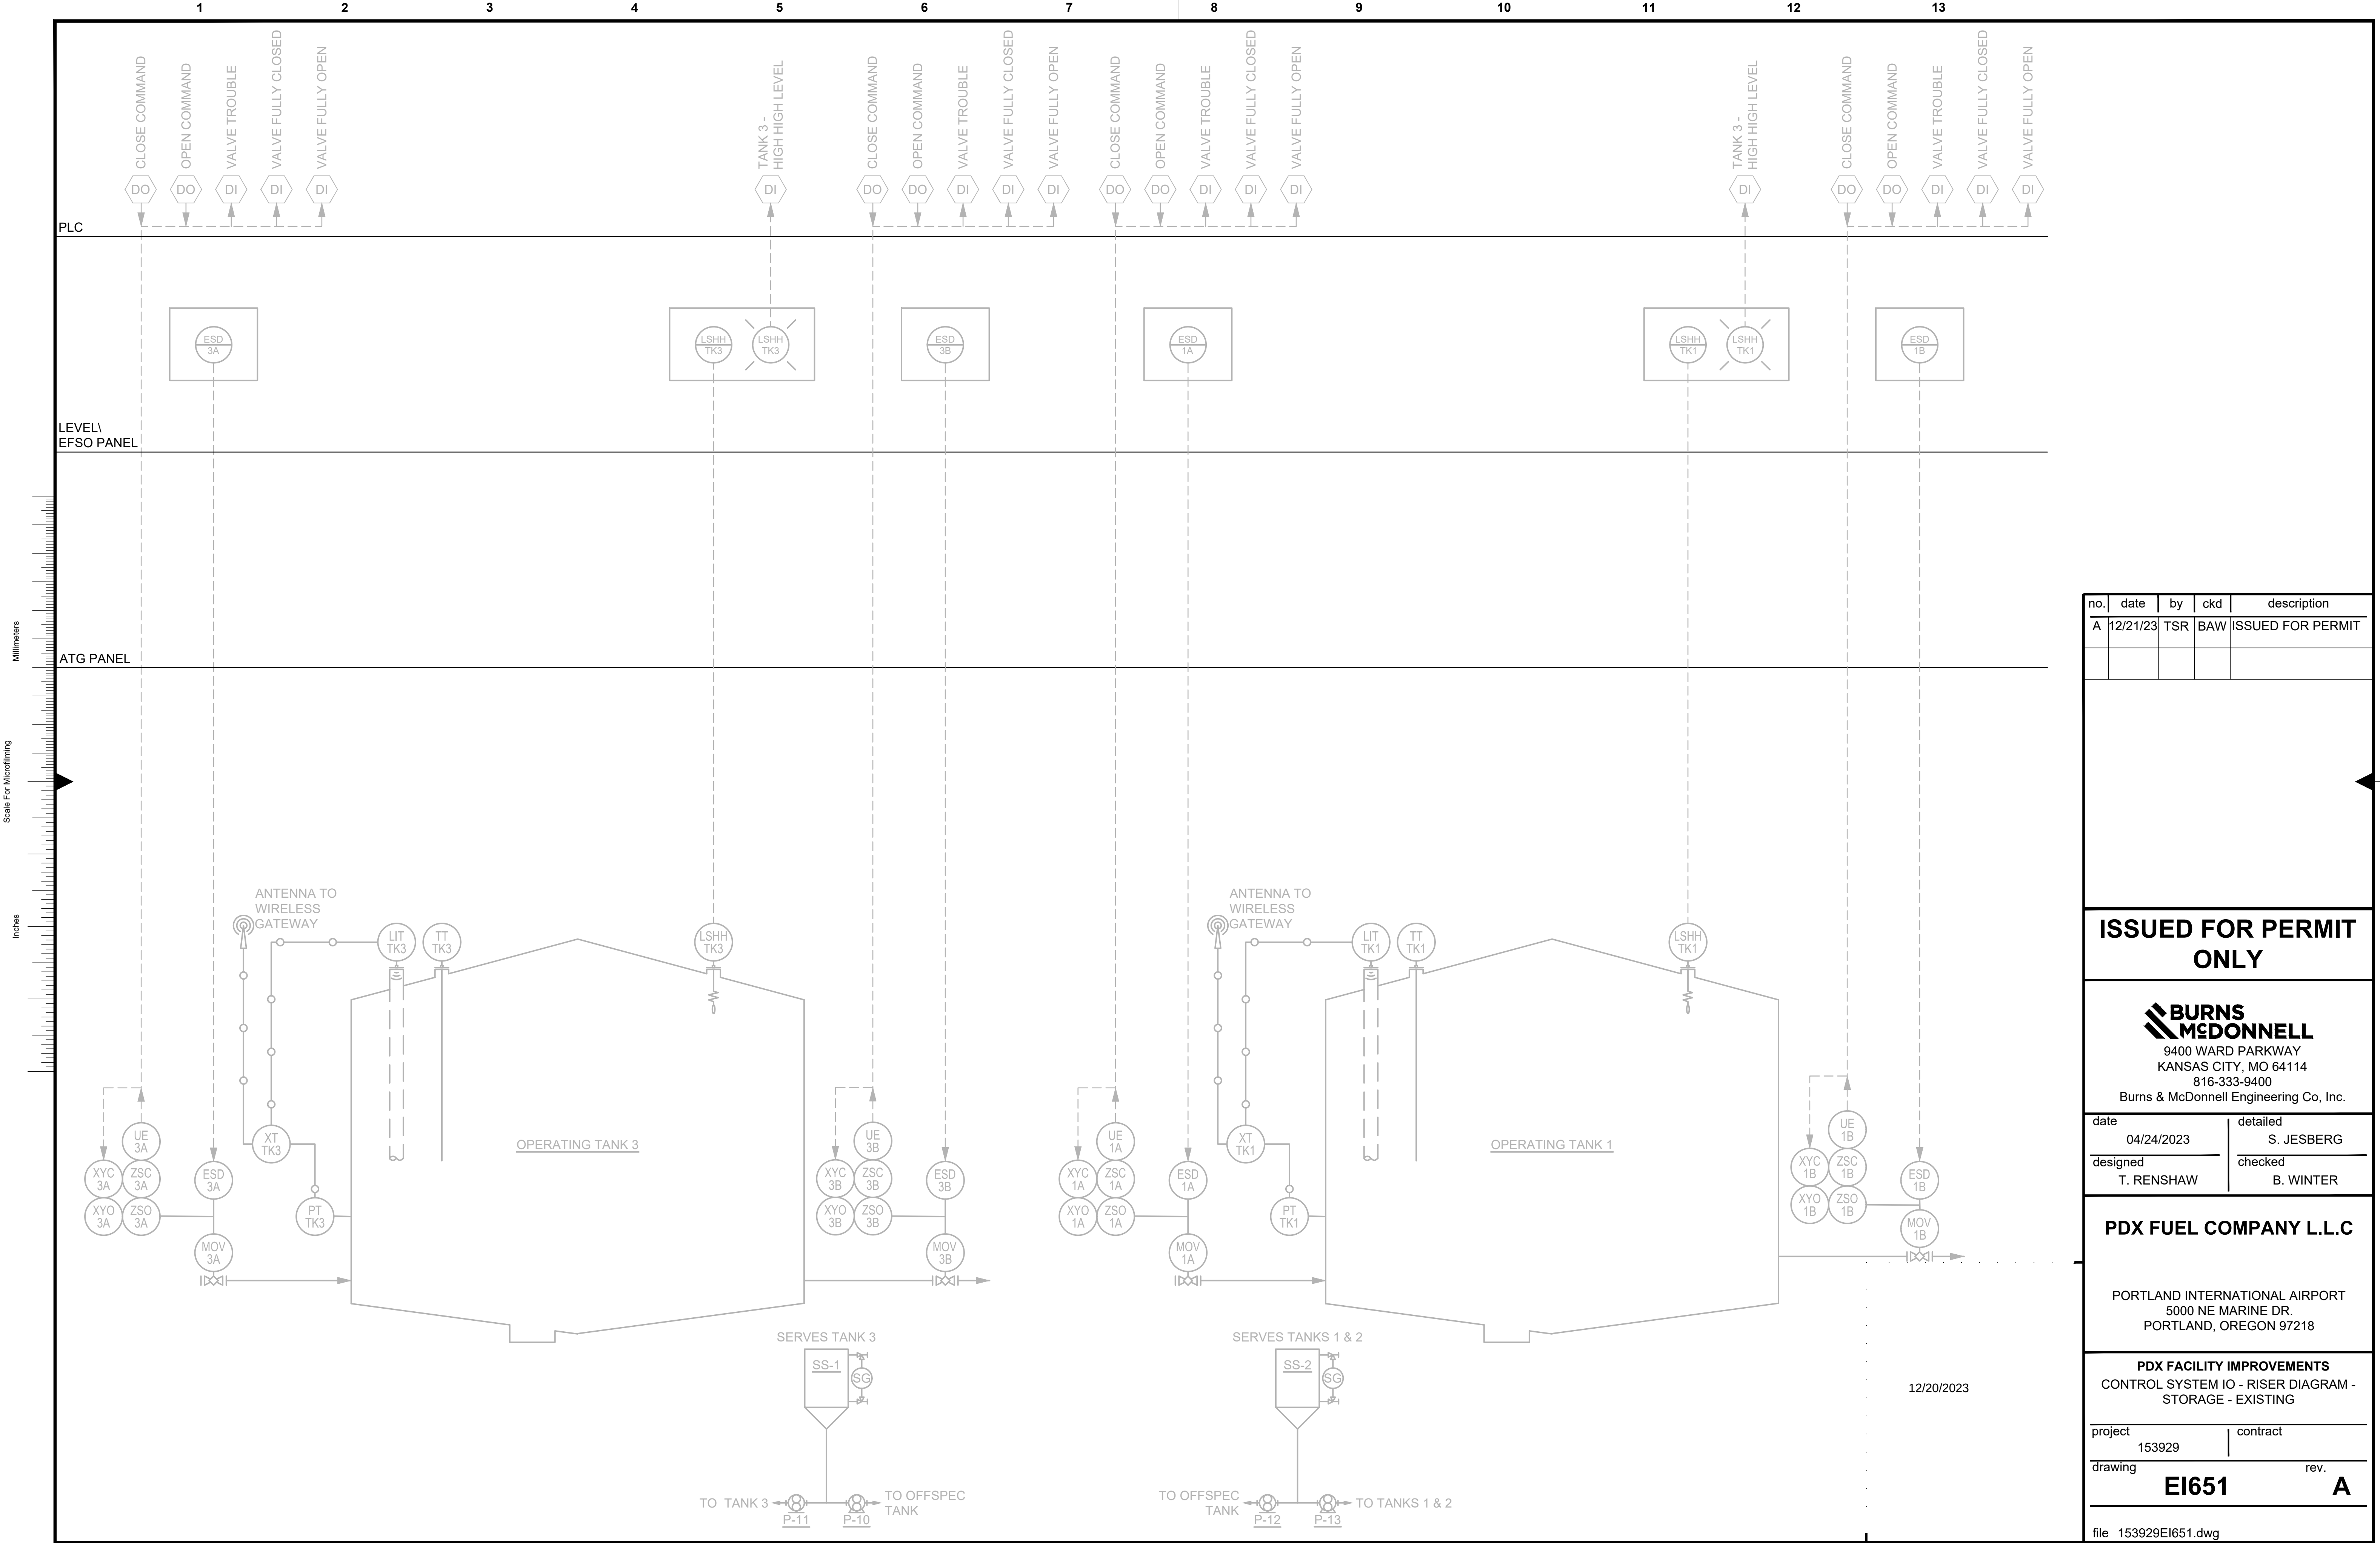



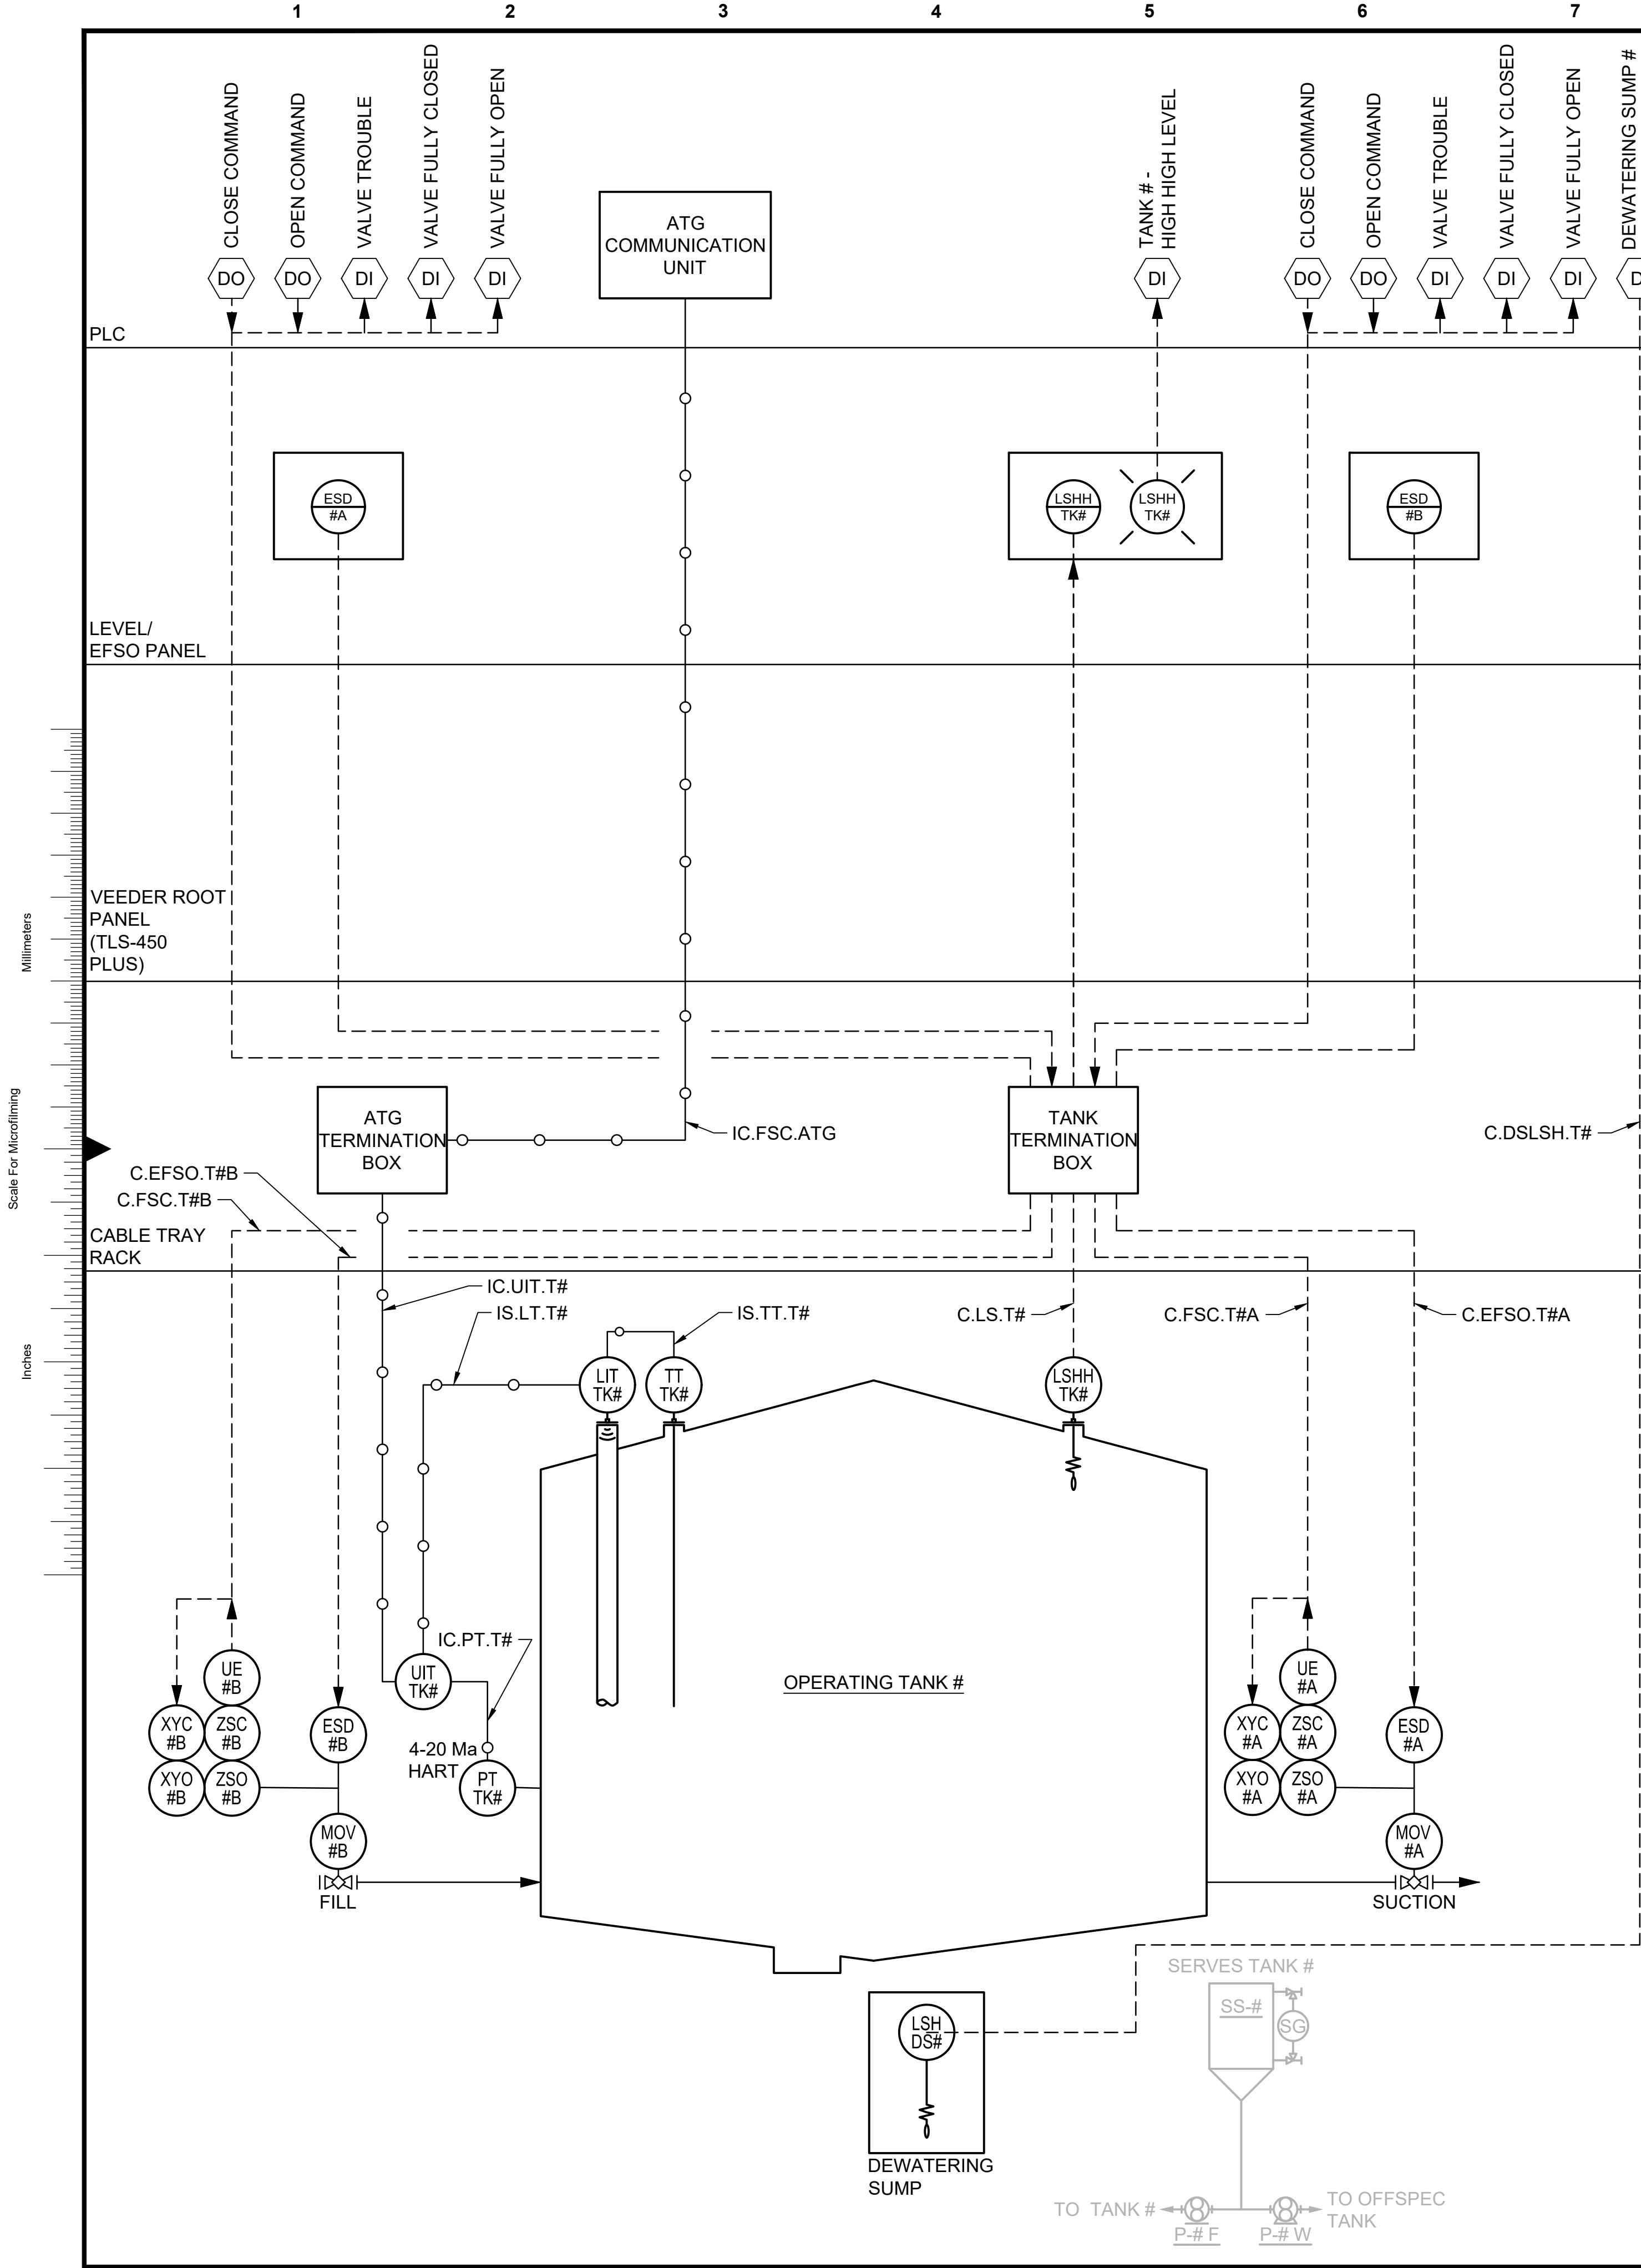

CORRESPONDING INSTRUMENT NUMBERS (#)			
TANK #	TANK 5	TANK 6	TANK 7
TANK # HIGH-HIGH LEVEL	TANK 5 HIGH-HIGH LEVEL	TANK 6 HIGH-HIGH LEVEL	TANK 7 HIGH-HIGH LEVEL
ESD #A	ESD 5A	ESD 6A	ESD 7A
ESD #B	ESD 5B	ESD 6B	ESD 7B
LSHH TK#	LSHH TK5	LSHH TK6	LSHH TK7
UE #A	UE 5A	UE 6A	UE 7A
UE #B	UE 5B	UE 6B	UE 7B
XYC #A	XYC 5A	XYC 6A	XYC 7A
XYC #B	XYC 5B	XYC 6B	XYC 7B
XYO #A	XYO 5A	XYO 6A	XYO 7A
XYO #B	XYO 5B	XYO 6B	XYO 7B
UE #A	UE 5A	UE 6A	UE 7A
UE #B	UE 5B	UE 6B	UE 7B
ZSC #A	ZSC 5A	ZSC 6A	ZSC 7A
ZSC #B	ZSC 5B	ZSC 6B	ZSC 7B
ZSO #A	ZSO 5A	ZSO 6A	ZSO 7A
ZSO #B	ZSO 5B	ZSO 6B	ZSO 7B
MOV #A	MOV 5A	MOV 6A	MOV 7A
MOV #B	MOV 5B	MOV 6B	MOV 7B
PT TK #	PT TK 5	PT TK 6	PT TK 7
LIT TK#	LIT TK5	LIT TK6	LIT TK7
TT TK#	TT TK5	TT TK6	TT TK7
LSH TK#	LSH TK5	LSH TK	LSH TK7
LSH DSTK#	LSH DSTK5	LSH DSTK6	LSH DSTK7

no.	date	by	ckd	description
A	12/21/23	TSR	BAW	ISSUED FOR PERMIT

ISSUED FOR PERMIT ONLY

BURNS MEDONNELL
9400 WARD PARKWAY
KANSAS CITY, MO 64114
816-333-9400
Burns & McDonnell Engineering Co., Inc.

date	04/24/2023	detailed	S. JESBERG
designed	T. RENSHAW	checked	B. WINTER


PDX FUEL COMPANY L.L.C

PORTLAND INTERNATIONAL AIRPORT
5000 NE MARINE DR.
PORTLAND, OREGON 97218

PDX FACILITY IMPROVEMENTS
CONTROL SYSTEM IO - RISER DIAGRAM - STORAGE - FINAL

project	153929	contract	
drawing	EI653	rev.	A

file 153929EI653.dwg

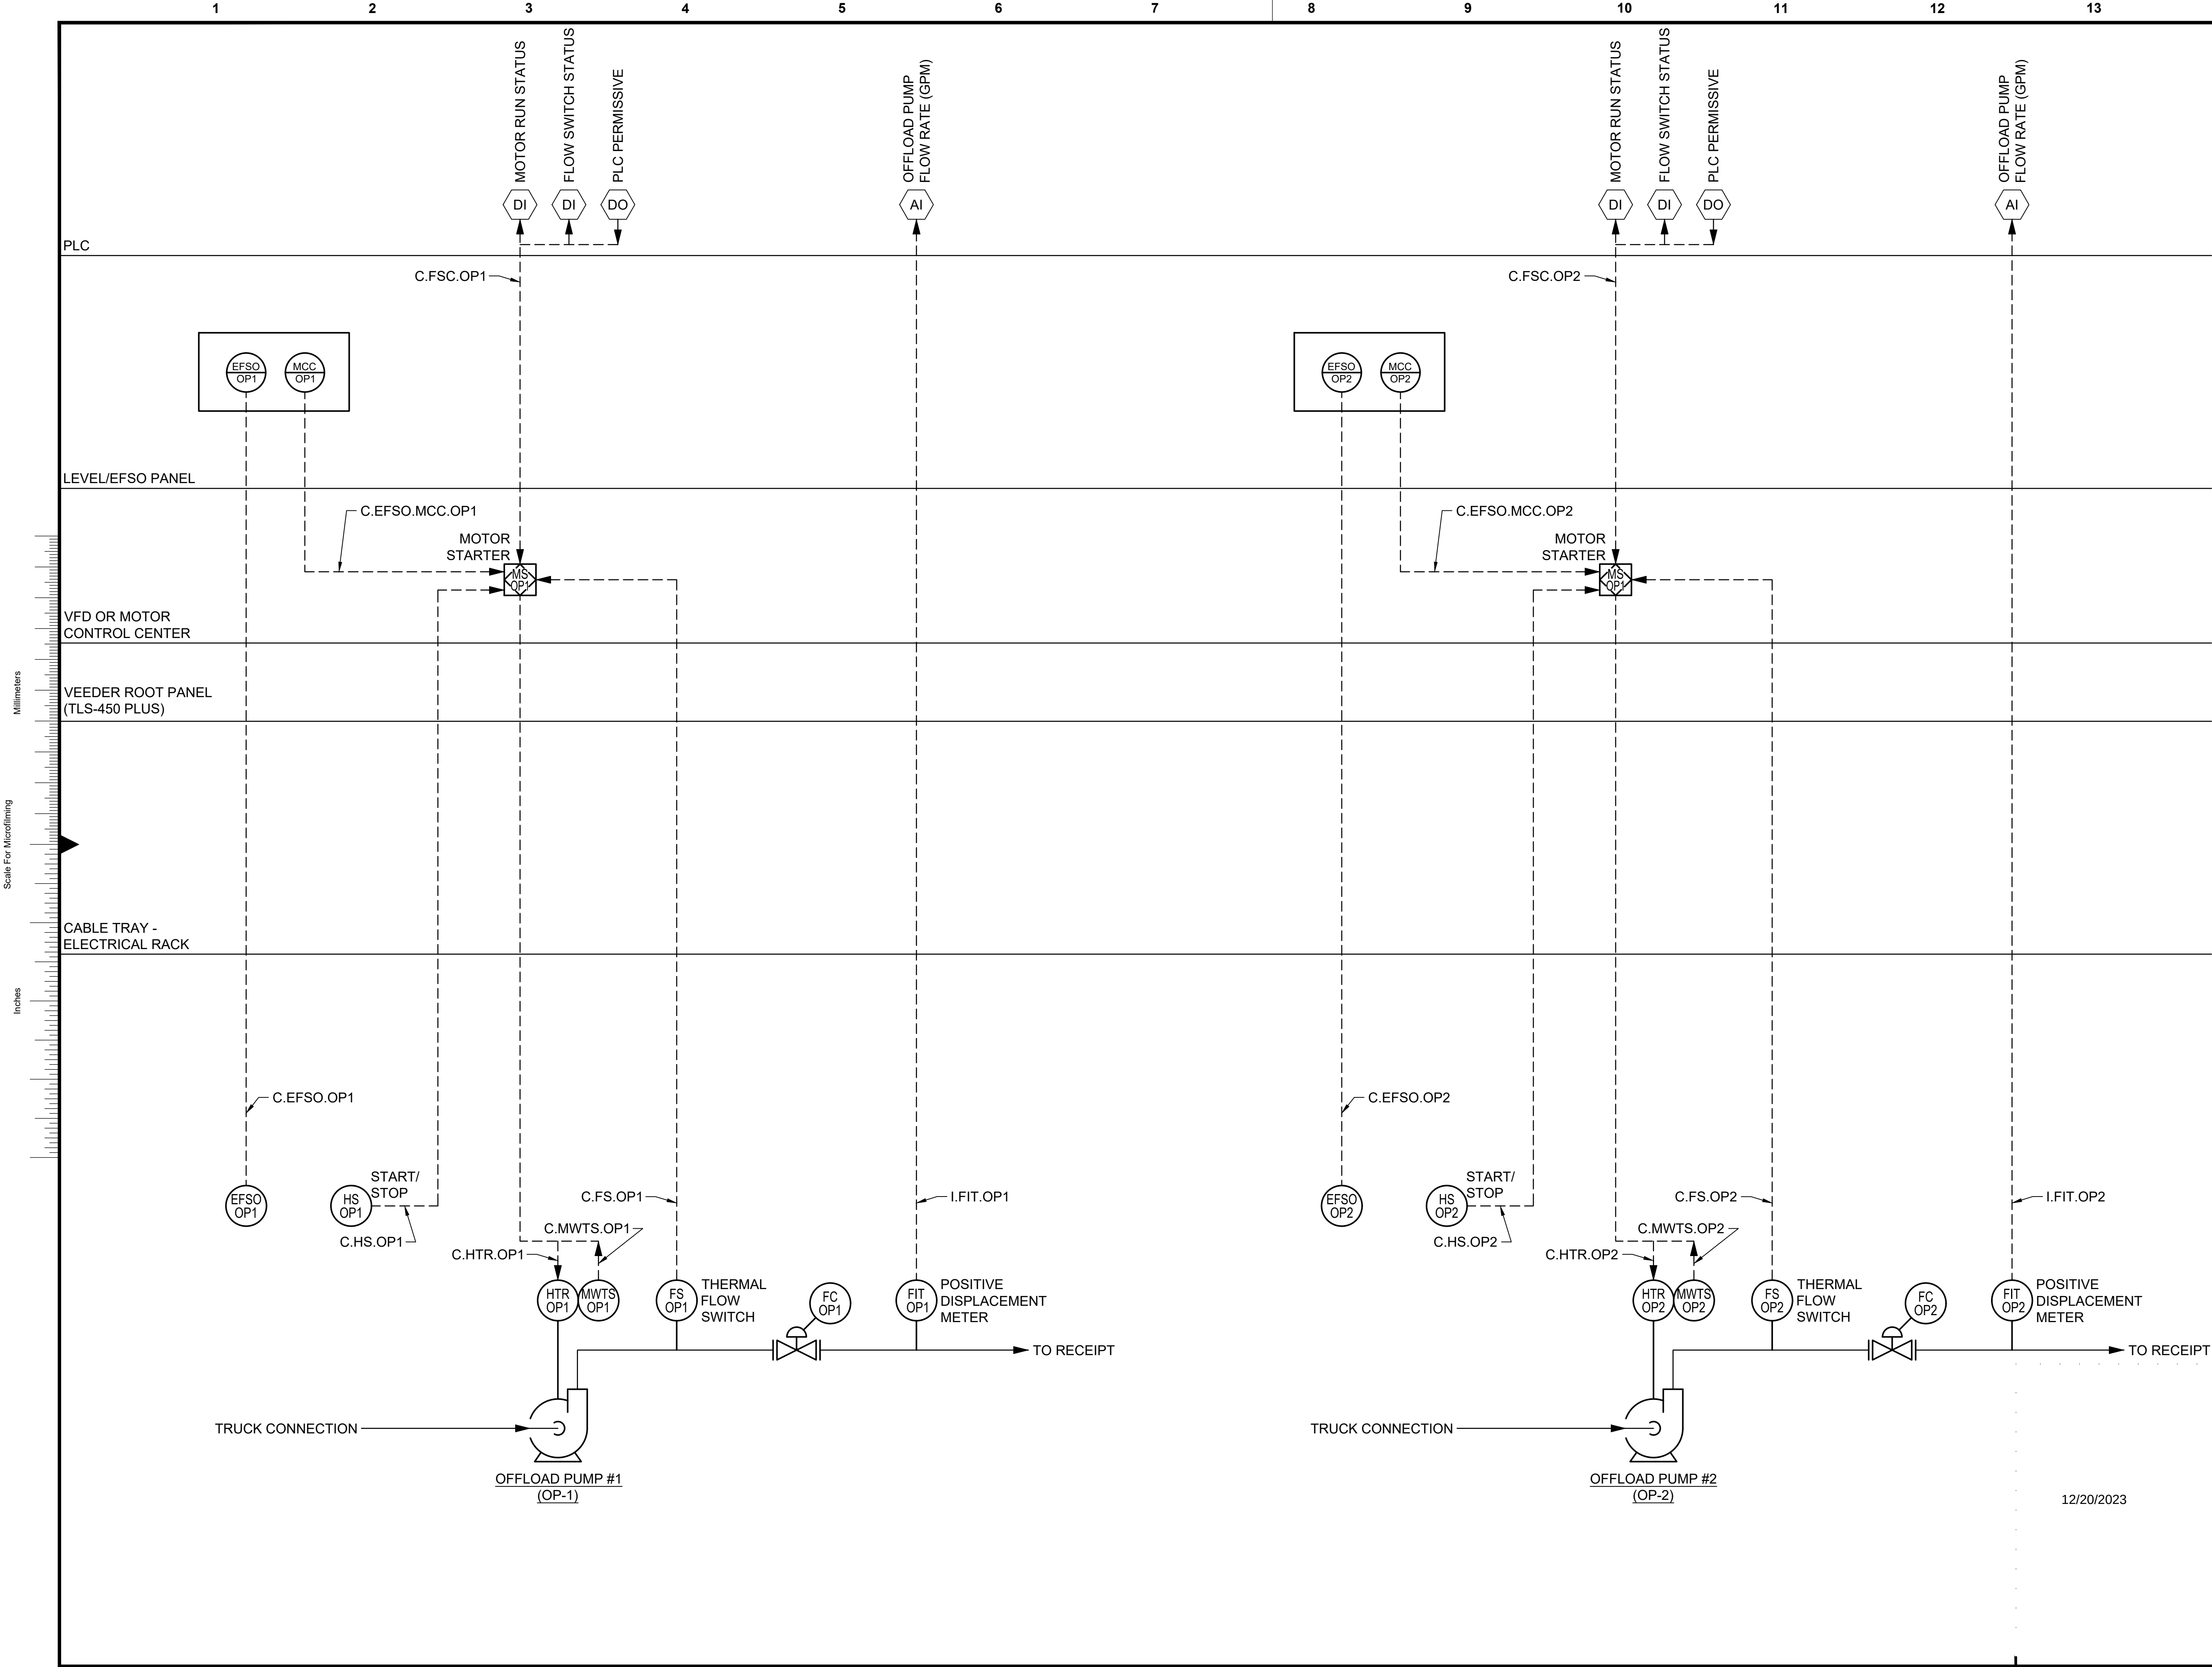

no.	date	by	ckd	description
A	12/21/23	TSR	BAW	ISSUED FOR PERMIT

ISSUED FOR PERMIT
ONLY



9400 WARD PARKWAY
KANSAS CITY, MO 64114
816-333-9400
Burns & McDonnell Engineering Co., Inc.

date	04/24/2023	detailed	S. JESBERG
designed	T. RENSHAW	checked	B. WINTER


PDX FUEL COMPANY L.L.C

PORTLAND INTERNATIONAL AIRPORT
5000 NE MARINE DR.
PORTLAND, OREGON 97218

PDX FACILITY IMPROVEMENTS
CONTROL SYSTEM IO - RISER DIAGRAM -
OFFLOAD

project	153929	contract	
drawing	EI654	rev.	A

file 153929EI654.dwg

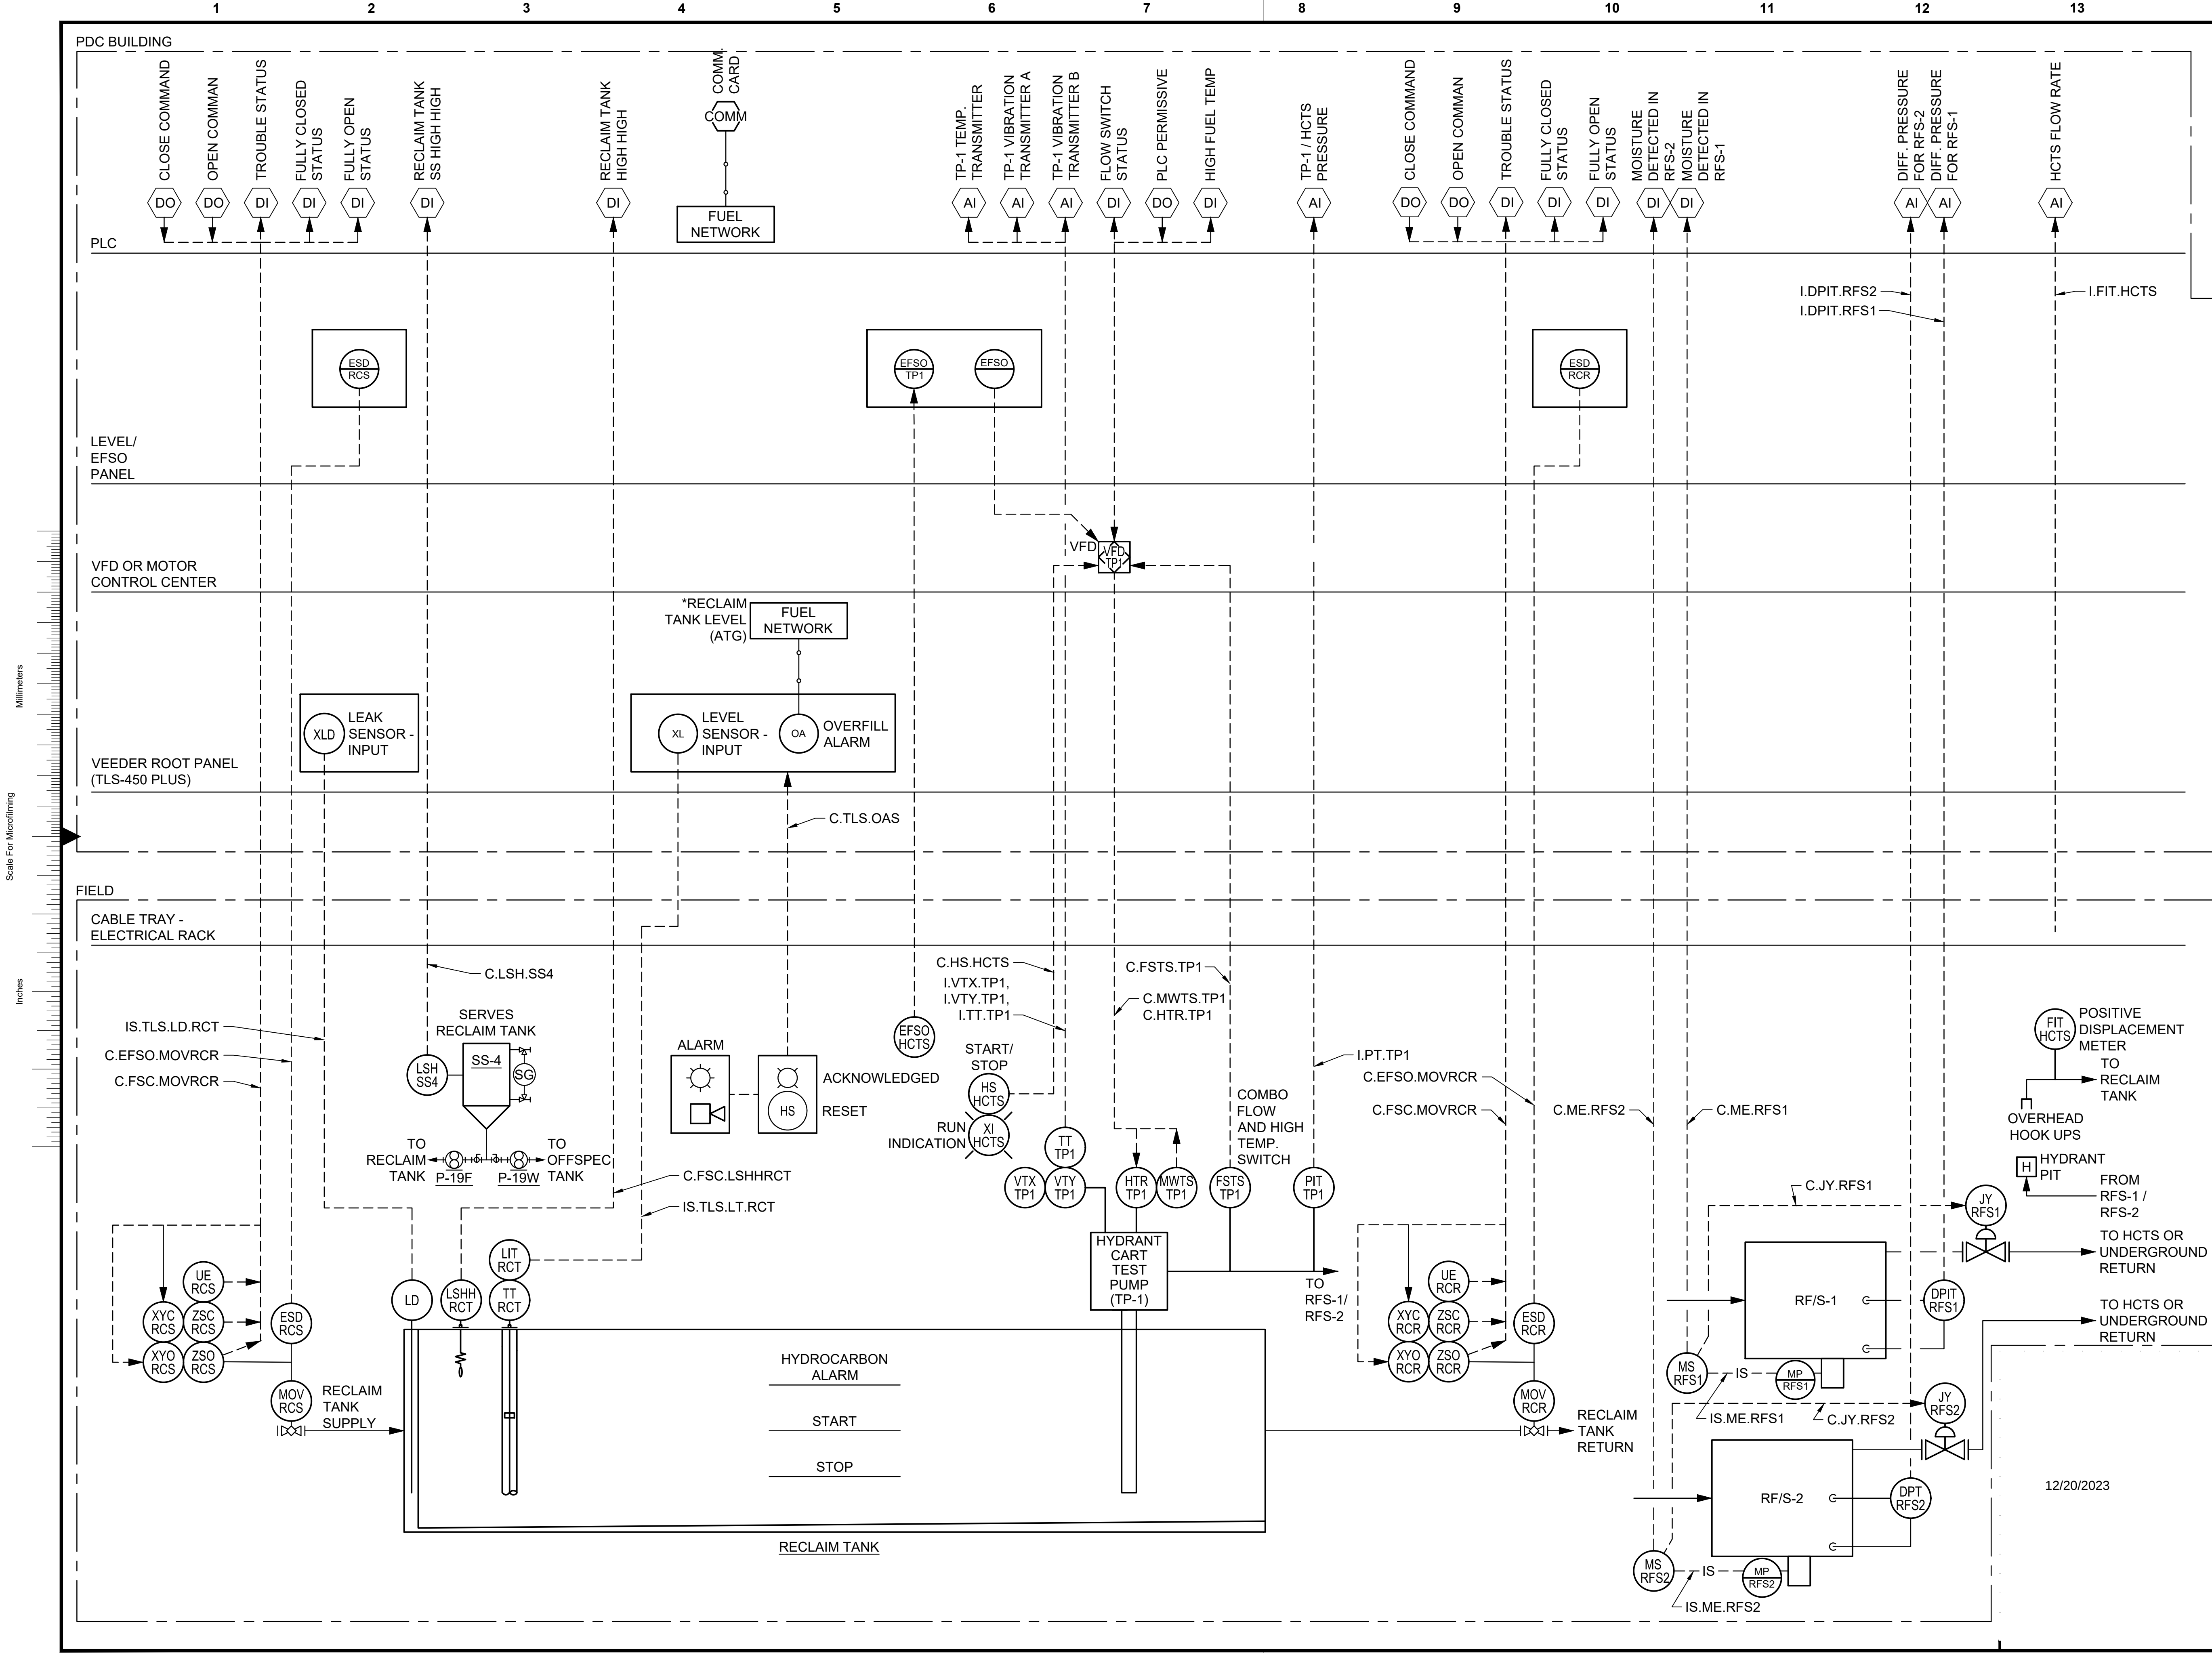

no.	date	by	ckd	description
A	12/21/23	TSR	BAW	ISSUED FOR PERMIT

ISSUED FOR PERMIT ONLY



9400 WARD PARKWAY
KANSAS CITY, MO 64114
816-333-9400
Burns & McDonnell Engineering Co., Inc.

date	detailed
04/24/2023	S. JESBERG
designed	checked
T. RENSHAW	B. WINTER


PDX FUEL COMPANY L.L.C


PORTLAND INTERNATIONAL AIRPORT
5000 NE MARINE DR.
PORTLAND, OREGON 97218

PDX FACILITY IMPROVEMENTS
CONTROL SYSTEM IO - RISER DIAGRAM - HCTS

project	contract
153929	
drawing	rev.
EI655	A

file 153929EI655.dwg

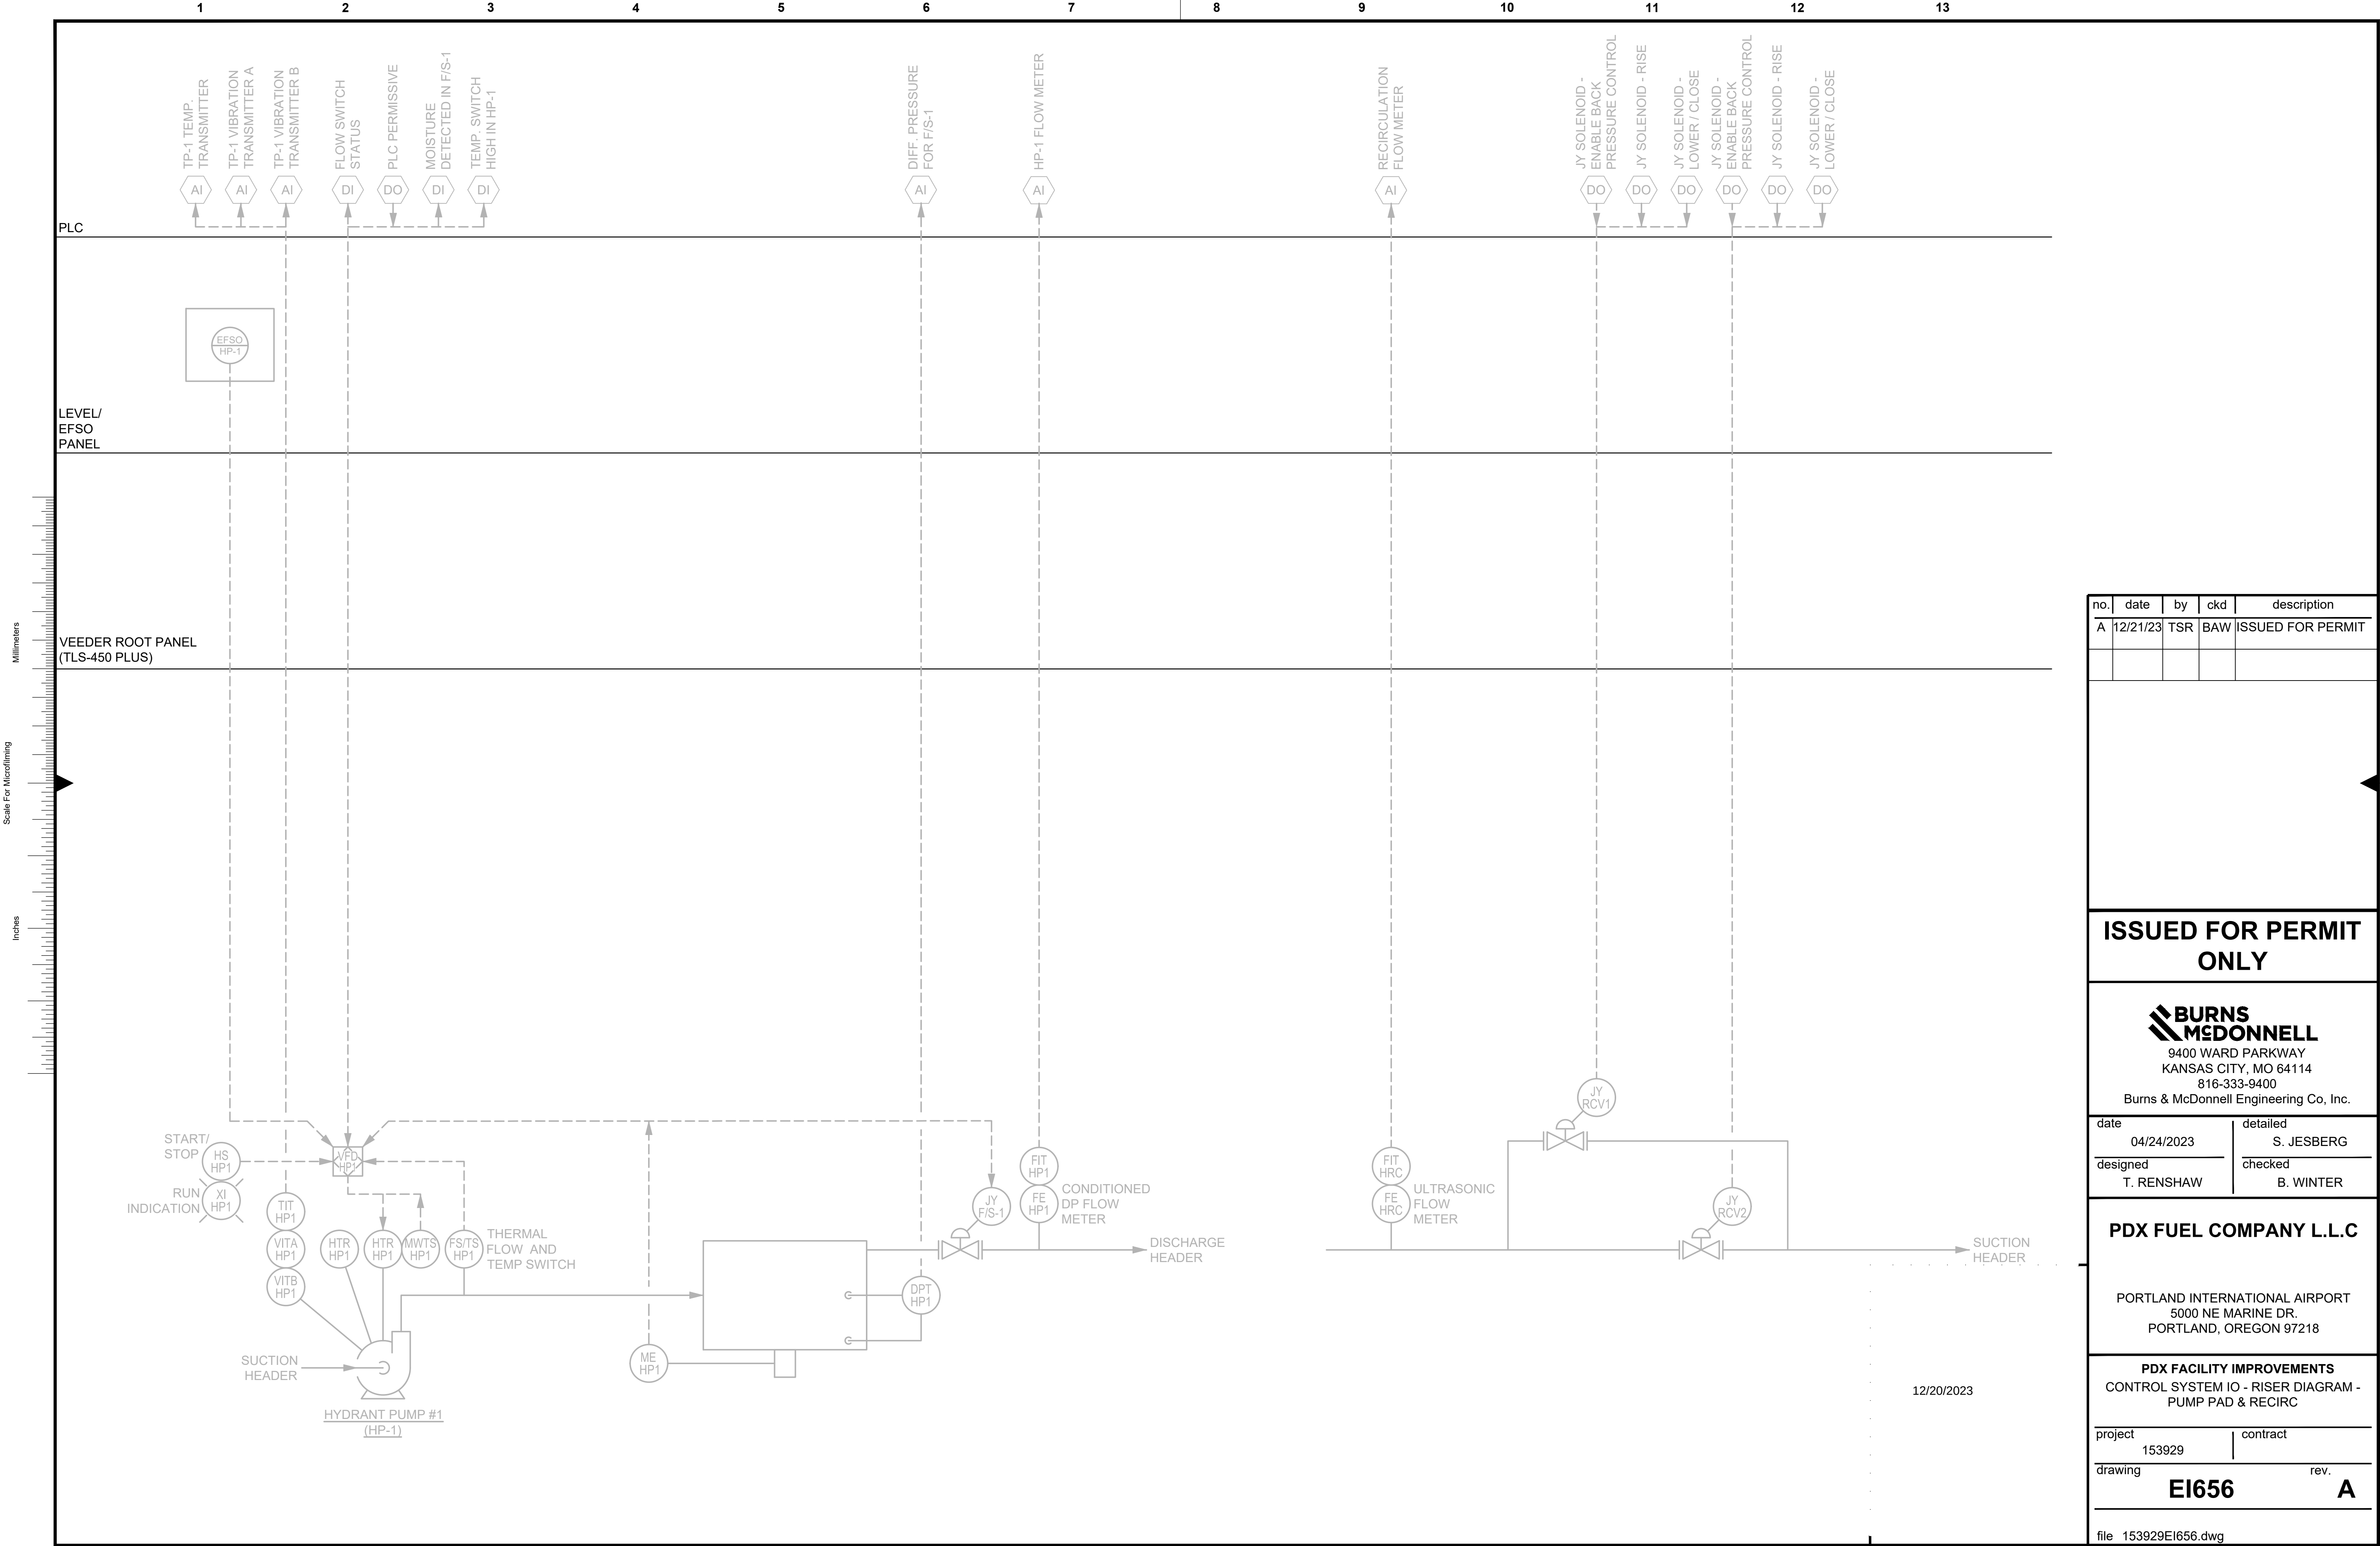

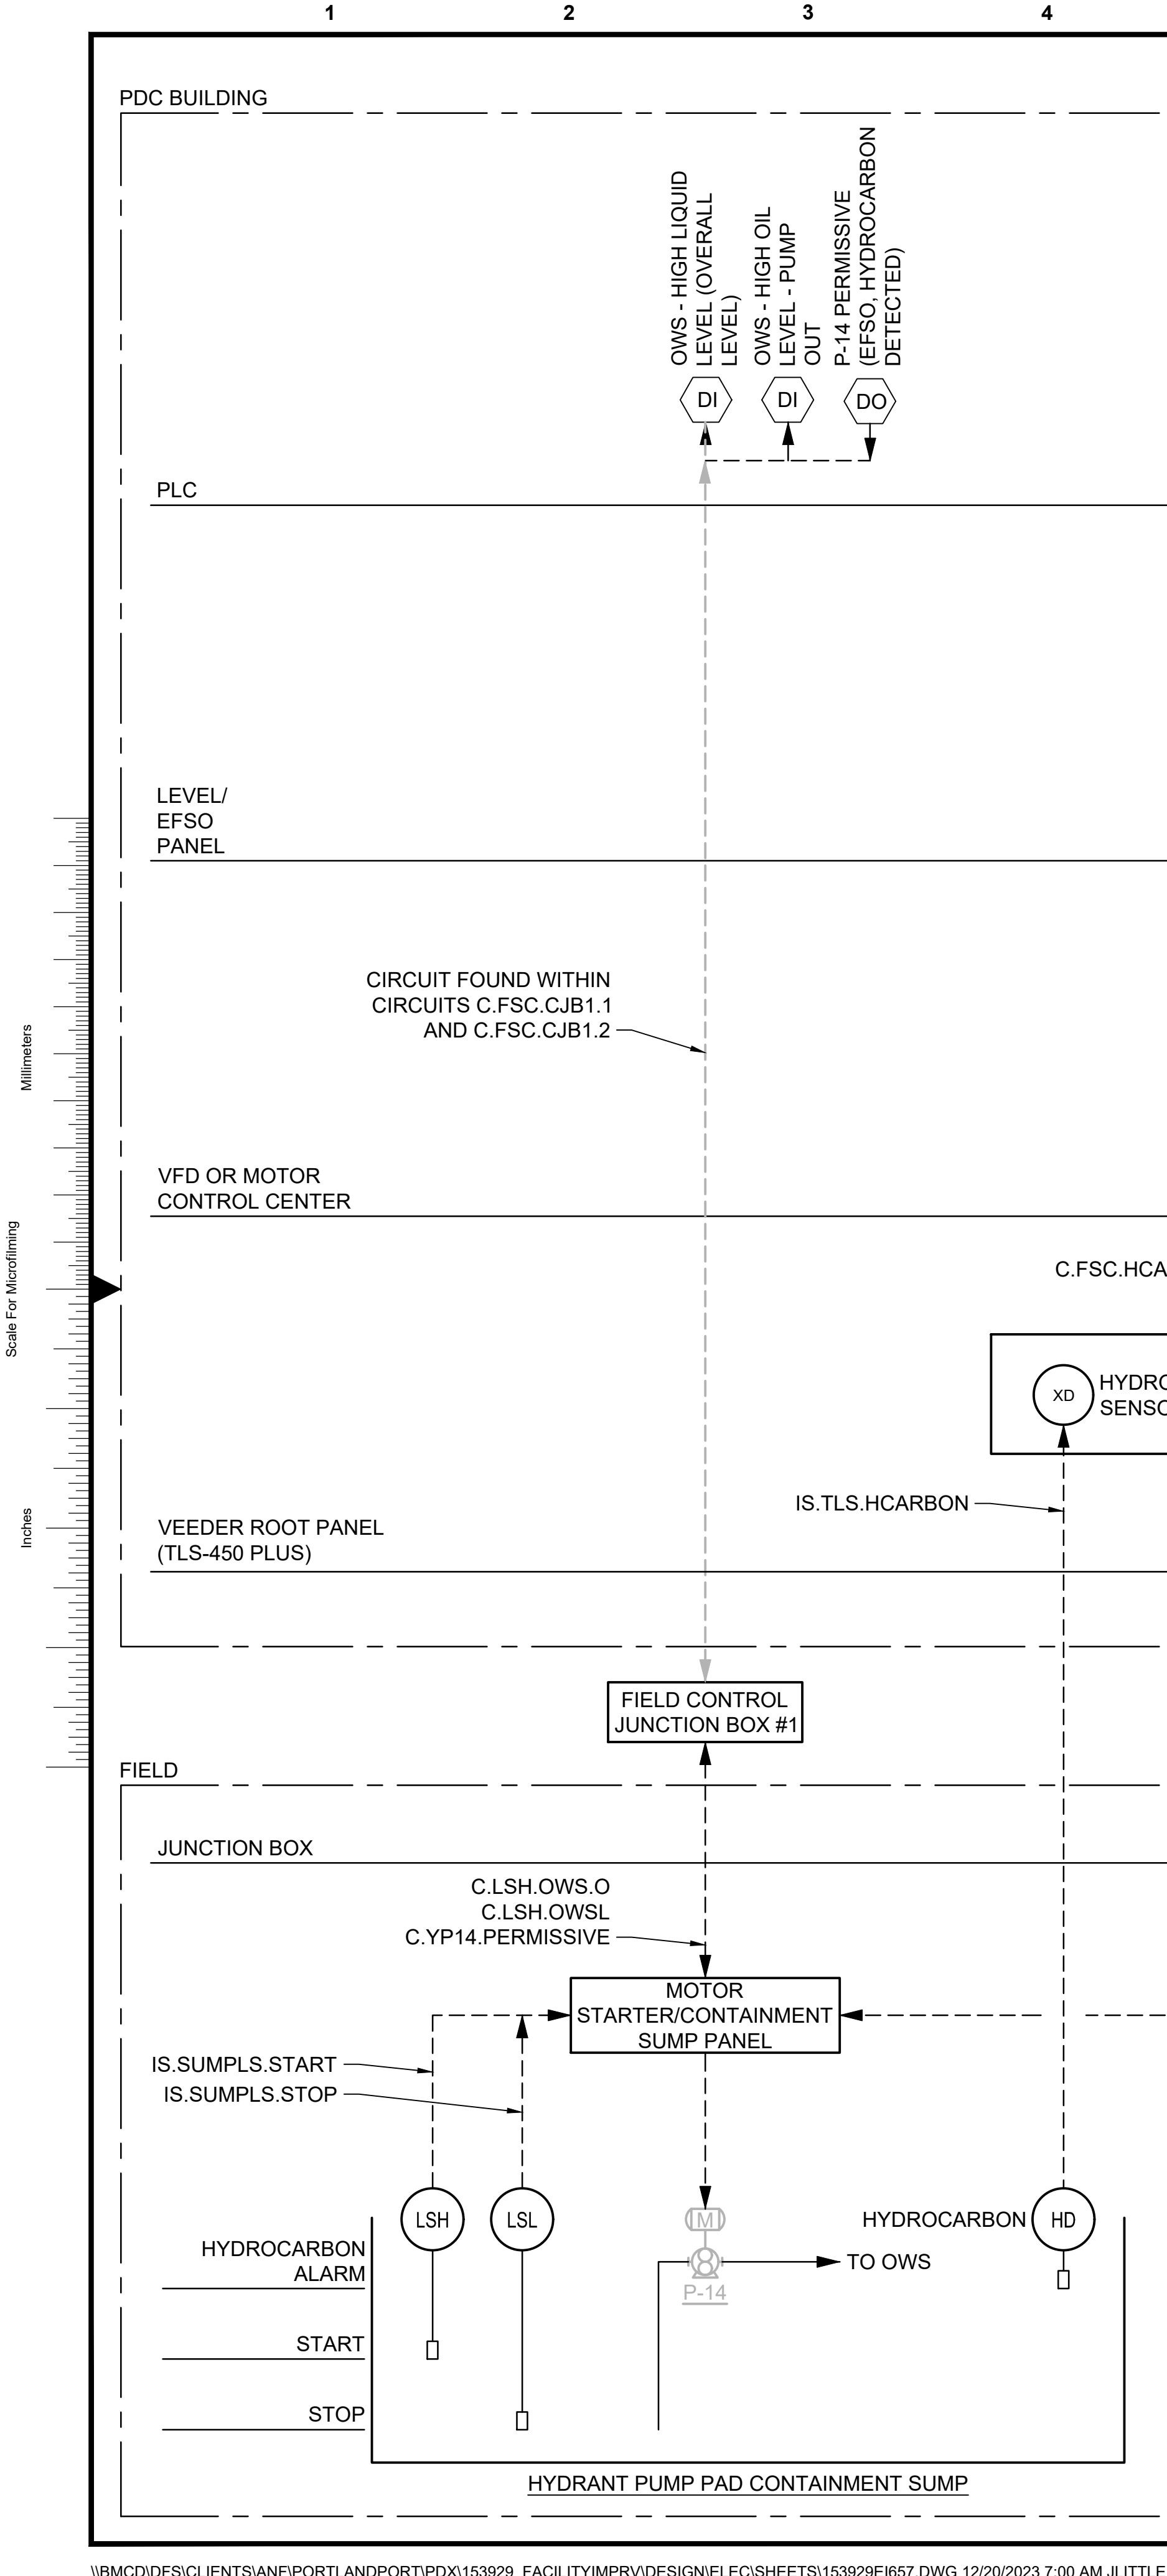

no.	date	by	ckd	description
A	12/21/23	TSR	BAW	ISSUED FOR PERMIT

ISSUED FOR PERMIT
ONLY



9400 WARD PARKWAY
KANSAS CITY, MO 64114
816-333-9400
Burns & McDonnell Engineering Co., Inc.

date	04/24/2023	detailed	S. JESBERG
designed	T. RENSHAW	checked	B. WINTER

PDX FUEL COMPANY L.L.C

PORTLAND INTERNATIONAL AIRPORT
5000 NE MARINE DR.
PORTLAND, OREGON 97218

PDX FACILITY IMPROVEMENTS
CONTROL SYSTEM IO - RISER DIAGRAM -
PUMP PAD & CONTAINMENT SUMP

project	153929	contract	
drawing	EI657	rev.	A

file 153929EI657.dwg

Millimeters
Scale For Microfinning
Inches

PANELBOARD NAME:	LP-1	65,000 RMS SYMMETRICAL A.I.C.	110 AMP TRIP MAIN BREAKER
PANELBOARD TYPE:	MAIN CIRCUIT BREAKER	SURFACE MOUNTED, NEMA 1 ENCLOSURE	200 AMP MAINS
PANEL LOCATION:	PDC	208Y/120 VOLTS, 3 PHASE, 4 WIRE, 60 Hz	
SUPPLIED FROM:	MCC-1		

CKT NO.	TRIP AMPS	NO. POLES	WIRE / GND / COND	LOAD SERVED	LOAD VA	Ø	LOAD VA	LOAD SERVED	WIRE / GND / COND	NO. POLES	TRIP AMPS	CKT NO.
1	20	1	2#12 , #12 GND, 3/4" C	PDC INTERIOR LIGHTING	240	A	240	PDC INTERIOR/EXTERIOR RECEPT.	2#12 , #12 GND, 3/4" C	1	20	2
3	20	1	2#12 , #12 GND, 3/4" C	PDC EXTERIOR LIGHTING (VIA CONTACTOR)	240	B	240	PDC INTERIOR/EXTERIOR RECEPT.	2#12 , #12 GND, 3/4" C	1	20	4
5	20	1	2#12 , #12 GND, 3/4" C	LIGHTING CONTACTOR	50	C		SPARE		2	20	6
7	20	2	2#10 , #10 GND, 3/4" C	CANOPY LIGHTING (208V) (VIA CONTACTOR)	510	A		SPARE		2	20	10
11	20	1	2#12 , #12 GND, 3/4" C	VEEDER ROOT - OVERFILL ALARM SWITCH	510	B						
13	20	1		SPARE	120	C						
15	20	1		SPARE		A	10000	KINDER MORGAN TRANSFORMER (208V-120/240)	2#1 , #6 GND, 3/4" C	2	125	14
17	20	1		SPARE		B	10000					
19	20	1	2#10 , #10 GND, 3/4" C	TANK 4 STAIR LIGHTING (FUTURE)	335	C						
21	20	1	2#10 , #10 GND, 3/4" C	TANK 5 STAIR LIGHTING (VIA CONTACTOR)	335	A	879	TANK 5 & 7 AREA LIGHTS (208V) (VIA CONTACTOR)	2#10 , #10 GND, 3/4" C	2	20	20
23	20	1	2#10 , #10 GND, 3/4" C	TANK 6 STAIR LIGHTING (VIA CONTACTOR)	335	B	879					
25	20	1	2#10 , #10 GND, 3/4" C	TANK 7 STAIR LIGHTING (VIA CONTACTOR)	335	C	879	TANK 4 & 6 AREA LIGHTS (208V) (VIA CONTACTOR)	2#10 , #10 GND, 3/4" C	2	20	24
27	20	1		SPARE		A		SPARE		1	20	28
29	20	1		SPARE		B		TANK 4 OBSTRUCTION LIGHT (FUTURE)	2#12 , #12 GND, 3/4" C	1	15	30
31		1		SPACE		C	100	TANK 5 OBSTRUCTION LIGHT	2#12 , #12 GND, 3/4" C	1	15	32
33		1		SPACE		A	100	TANK 6 OBSTRUCTION LIGHT	2#12 , #12 GND, 3/4" C	1	15	34
35		1		SPACE		B	100	TANK 7 OBSTRUCTION LIGHT	2#12 , #12 GND, 3/4" C	1	15	36
37		1		SPACE		C		SPACE				
39		1		SPACE		A		SPACE				
41		1		SPACE		B		SPACE				

TOTAL CONNECTED LOAD = 27.4 kVA X 64% DEMAND FACTOR = 17.4 kVA ESTIMATED DEMAND LOAD
PHASE BALANCE (KVA) - A: 13.5 , B: 12.3 , C: 1.6 DESIGN LOAD = 48 AMPERES, TOTAL LOAD WITH EXPANSION = 72 AMPERES
NOTES:
1. PROVIDE SURGE PROTECTION DEVICE (SPD).

PANELBOARD NAME:	PNL-5	65,000 RMS SYMMETRICAL A.I.C.	200 AMP TRIP MAIN BREAKER
PANELBOARD TYPE:	MAIN CIRCUIT BREAKER	SURFACE MOUNTED, NEMA 1 ENCLOSURE	200 AMP MAINS
PANEL LOCATION:	PDC	480 VOLTS, 3 PHASE, 3 WIRE, 60 Hz	
SUPPLIED FROM:	MCC-1		

CKT NO.	TRIP AMPS	NO. POLES	WIRE / GND / COND	LOAD SERVED	LOAD VA	Ø	LOAD VA	LOAD SERVED	WIRE / GND / COND	NO. POLES	TRIP AMPS	CKT NO.
1	20	3	3#12 , #12 GND, 3/4" C	MOV-1A 8" TANK 1 INLET	190	A	440	MOV-1B 12" TANK 1 OUTLET	3#12 , #12 GND, 3/4" C	3	20	2
					190	B	440					
					190	C	440					
7	20	3	3#12 , #12 GND, 3/4" C	MOV-2A 8" TANK 1 INLET	190	A	440	MOV-2B 12" TANK 1 OUTLET	3#12 , #12 GND, 3/4" C	3	20	8
					190	B	440					
					190	C	440					
13	20	3	3#12 , #12 GND, 3/4" C	MOV-3A 8" TANK 1 INLET	190	A	500	MOV-3B 16" TANK 1 OUTLET	3#12 , #12 GND, 3/4" C	3	20	14
					190	B	500					
					190	C	500					
19	20	3	3#12 , #12 GND, 3/4" C	RECLAIM SUPPLY AND RETURN (MOV-RCS & MOV-RCR)	1280	A		SPARE		3	20	20
					1280	B						
					1280	C						
25	20	3		SPARE		A	8500	CONSTRUCTION TRAILER POWER	3#4 , #4 GND, 1" C	3	40	26
						B	8500					
						C	8500					
31	15	3	3#12 , #12 GND, 3/4" C	TANK 4 MOV - INLET & OUTLET (FUTURE)	1280	A	1280	TANK 5 MOV - INLET & OUTLET	3#12 , #12 GND, 3/4" C	3	15	32
					1280	B	1280					
					1280	C	1280					
37	15	3	3#12 , #12 GND, 3/4" C	TANK 6 MOV - INLET & OUTLET	1280	A	1280	TANK 7 MOV - INLET & OUTLET	3#12 , #12 GND, 3/4" C	3	15	38
					1280	B	1280					
					1280	C	1280					

TOTAL CONNECTED LOAD = 49.9 kVA X 60% DEMAND FACTOR = 30 kVA ESTIMATED DEMAND LOAD
PHASE BALANCE (KVA) - A: 16.9 , B: 16.9 , C: 16.2 DESIGN LOAD = 36 AMPERES, TOTAL LOAD WITH EXPANSION = 54 AMPERES
NOTES:
1. PROVIDE SURGE PROTECTION DEVICE (SPD).

PANELBOARD NAME:	PNL-6	65,000 RMS SYMMETRICAL A.I.C.	110 AMP TRIP MAIN BREAKER
PANELBOARD TYPE:	MAIN CIRCUIT BREAKER	SURFACE MOUNTED, NEMA 1 ENCLOSURE	200 AMP MAINS
PANEL LOCATION:	PDC	208Y/120 VOLTS, 3 PHASE, 4 WIRE, 60 Hz	
SUPPLIED FROM:	MCC-1		

CKT NO.	TRIP AMPS	NO. POLES	WIRE / GND / COND	LOAD SERVED	LOAD VA	Ø	LOAD VA	LOAD SERVED	WIRE / GND / COND	NO. POLES	TRIP AMPS	CKT NO.
1	20	3		SPARE		A		SPARE		3	20	2
						B						
						C						
7	20	1	2#12 , #12 GND, 3/4" C	UPS-EFSO/PLC PANEL	1500	A	2000	AIR COMPRESSOR (RELOCATED)	3#10 , #10 GND, 3/4" C	3	35	8
9	20	1		SPARE		B	2000					
11	20	1	2#12 , #12 GND, 3/4" C	ALARM/HORN	1500	C	2000					
13	20	1		SPARE		A	8050	GEP-1 GENERATOR ELECTRICAL PANEL	3#2 , #8 GND, 3/4" C	2	100	14
15	20	1		SPARE		B	8050					
17	20	1		SPARE		C		SPARE		1	20	18
19	15	3	3#12 , #12 GND, 3/4" C	RESERVED	600	A	600	RESERVED	3#12 , #12 GND, 3/4" C	3	15	20
					600	B	600					
					600	C	600					
25	15	3	3#12 , #12 GND, 3/4" C	RESERVED	600	A	795	TANK 4 (FUTURE) SUMP SEPARATOR MOTORS	2#6 , #6 GND, 3/4" C	2	15	26
					600	B	795					
					600	C	795	TANK 5 SUMP SEPARATOR MOTORS	2#6 , #6 GND, 3/4" C	2	15	30
					795	A	795					
31	15	2	2#6 , #6 GND, 3/4" C	TANK 6 SUMP SEPARATOR MOTORS	795	B	795	SS-4 (PUMP #19F & #19W) LOCATED AT RECLAIM TANK, 3/4 HP	2#8 , #8 GND, 3/4" C	2	15	34
35	15	2	2#6 , #6 GND, 3/4" C	TANK 7 SUMP SEPARATOR MOTORS	795	C	795					
39	20	1		SPARE		A		SPARE		1	20	38
41	20	1		SPARE		B		SPARE		1	20	40
						C		SPARE		1	20	42

TOTAL CONNECTED LOAD = 38.5 kVA X 90% DEMAND FACTOR = 34.6 kVA ESTIMATED DEMAND LOAD
PHASE BALANCE (KVA) - A: 16.5 , B: 14.2 , C: 7.7 DESIGN LOAD = 96 AMPERES, TOTAL LOAD WITH EXPANSION = 144 AMPERES

PANELBOARD NAME:	LP-1	65,000 RMS SYMMETRICAL A.I.C.	110 AMP TRIP MAIN BREAKER
PANELBOARD TYPE:	MAIN CIRCUIT BREAKER	SURFACE MOUNTED, NEMA 1 ENCLOSURE	200 AMP MAINS
PANEL LOCATION:	EXISTING MCC-1 RM. (TO BE DEMOLISHED)	208Y/120 VOLTS, 3 PHASE, 4 WIRE, 60 Hz	
SUPPLIED FROM:	P-1		

CKT NO.	TRIP AMPS	NO. POLES	WIRE / GND / COND	LOAD SERVED	LOAD VA	Ø	LOAD VA	LOAD SERVED	WIRE / GND / COND	NO. POLES	TRIP AMPS	CKT NO.
1	20	1		CONTROL PANEL		A		POLE LIGHT SE TRIPLE HEAD		1	20	2
3	20	1		RECEPTACLES		B		EXTERIOR LIGHTING CONTACTOR		1	20	4
5	20	1		ROOM LIGHTS		C						
7	20	1		CATHODIC		A		SPARE		1	20	6
						B		CATHODIC T3A		1	20	8
						C		CATHODIC T2A		1	20	10
9	30	3		AIR COMPRESSOR		A		CATHODIC T1A		1	20	12
						B		SPARE		1	20	14
15	30	1		SPARE		C		SPARE		1	15	16
17	30	1		SPARE		A		SPACE				
19	20	1		TEST STAND RECEPTACLES & EXTERIOR LIGHTS		A						

TOTAL CONNECTED LOAD = 0 kVA X 0% DEMAND FACTOR = 0 kVA ESTIMATED DEMAND LOAD
PHASE BALANCE (KVA) - A: 0 , B: 0 , C: 0 DESIGN LOAD = 0 AMPERES, TOTAL LOAD WITH EXPANSION = 0 AMPERES
NOTES:
1. PROVIDE SURGE PROTECTION DEVICE (SPD).

PANELBOARD NAME:	GEP-1	65,000 RMS SYMMETRICAL A.I.C.	200 AMP MAINS
PANELBOARD TYPE:	MAIN LUGS ONLY	SURFACE MOUNTED, NEMA 1 ENCLOSURE	
PANEL LOCATION:	PDC	208 VOLTS, 1 PHASE, 3 WIRE, 60 Hz	
SUPPLIED FROM:	PNL-6		

CKT NO.	TRIP AMPS	NO. POLES	WIRE / GND / COND	LOAD SERVED	LOAD VA	Ø	LOAD VA	LOAD SERVED	WIRE / GND / COND	NO. POLES	TRIP AMPS	CKT NO.
1	20	2	2#12 , #12 GND, 3/4" C	BLOCK HEATER	4500	A	1690	GFCI RECEPTACLE	2#12 , #12 GND, 3/4" C	1	20	2
5	20	1	2#12 , #12 GND, 3/4" C	ENCLOSURE HEATER	4500	B	360	GENERATOR HEATER	2#12 , #12 GND, 3/4" C	1	20	4
					1850	A	240	MOTORIZED AIR INLET LOUVER	2#12 , #12 GND, 3/4" C	1	20	6
						B	60	LED LIGHTS	2#12 , #12 GND, 3/4" C	1	20	8
9	20	1	2#12 , #12 GND, 3/4" C	BATTERY CHARGER	600	A		SPARE		1	15	10
11	20	2	2#12 , #12 GND, 3/4" C	VENTILATION FAN	208	B		SPARE		1	15	12
					208	A		SPARE		1	15	14
15	15	1		SPARE		B		SPARE		1	15	16

TOTAL CONNECTED LOAD = 16.1 kVA X 95% DEMAND FACTOR = 15.2 kVA ESTIMATED DEMAND LOAD
PHASE BALANCE (KVA) - A: 9.1 , B: 7 DESIGN LOAD = 73 AMPERES, TOTAL LOAD WITH EXPANSION = 110 AMPERES
NOTES:
1. PROVIDE SURGE PROTECTION DEVICE (SPD).

NOTES:

- SEE SHEET E-001 FOR GENERAL NOTES, LEGEND AND ABBREVIATIONS.

KEYED NOTES:

- BREAKER WITHIN ENCLOSURE, LOCATED FOLLOWING TAP RULE. ENCLOSURE TO BE LOCKABLE AND KM TO BE PROVIDED KEY.
- DEMOLISH AND REMOVE ONCE NEW OPERATIONS BUILDING IS COMMISSIONED.
- DEMOLISH AND REMOVE ONCE TANKS 5, 6 AND 7 ARE COMMISSIONED.
- DEMOLISH AND REMOVE ONCE NEW FIRE PROTECTIONS IS COMMISSIONED AT SITE.
- CONFIRM THAT BREAKER IS 100A OR LESS

 
12/20/2023

NOTES:

1. SEE SHEET E-001 FOR GENERAL NOTES, LEGEND AND ABBREVIATIONS.

KEYED NOTES:

1 > GROUND IS RAN WITH EACH SET

DUCT/BANK SECTION(S)	PDC STUB UP	CIRCUIT NUMBER	FROM	TO	PURPOSE	VOLTS	FUEL STORAGE POWER CIRCUIT SCHEDULE			NOTES	
							CONDUCTORS		GROUND 		
							POWER				
							NUMBER AND SIZE	NUMBER AND SIZE	TYPE		
B	B2, B3, B4, B6, B7	P.XFMR.SWGR1	UTILITY TRANSFORMER	SWITCHGEAR SWGR-1	SERVICE ENTRANCE CONDUCTORS	480V	5 SETS OF (4) 600KCMIL		1		
-	-	P.SWGR1.ATS1	SWITCHGEAR SWGR-1	AUTOMATIC TRANSFER SWITCH ATS-1	ATS FEEDER	480V	4 SETS OF (3) 600 KCMIL	1 - #4/0 AWG	1	1600A OVERCURRENT PROTECTION	
-	-	P.SWGR1.ATS2	SWITCHGEAR SWGR-1	AUTOMATIC TRANSFER SWITCH ATS-2	ATS FEEDER	480V	4 SETS OF (3) 600 KCMIL	1 - #4/0 AWG	1	1600A OVERCURRENT PROTECTION	
C	C2, C3, C4, C5	P.GEN.ATS1	GENERATOR	AUTOMATIC TRANSFER SWITCH ATS-1	ATS FEEDER	480V	4 SETS OF (3) 600 KCMIL	1 - #4/0 AWG	1	1600A OVERCURRENT PROTECTION	
C	C8, C9, C10, C11	P.GEN.ATS2	GENERATOR	AUTOMATIC TRANSFER SWITCH ATS-2	ATS FEEDER	480V	4 SETS OF (3) 600 KCMIL	1 - #4/0 AWG	1	1600A OVERCURRENT PROTECTION	
-	-	P.ATS1.SWBD1	AUTOMATIC TRANSFER SWITCH ATS-1	SWITCHBOARD SWBD-1	SWITCHBOARD FEEDER	480V	4 SETS OF (3) 600 KCMIL	1 - #4/0 AWG	1	1600A OVERCURRENT PROTECTION	
-	-	P.ATS2.SWBD2	AUTOMATIC TRANSFER SWITCH ATS-2	SWITCHBOARD SWBD-2	SWITCHBOARD FEEDER	480V	4 SETS OF (3) 600 KCMIL	1 - #4/0 AWG	1	1600A OVERCURRENT PROTECTION	
-	-	P.SWBD1.MCC1	SWITCHBOARD SWBD-1	MOTOR CONTROL CENTER MCC-1	MOTOR CONTROL CENTER FEEDER	480V	2 SETS OF (3) 350KCMIL	1 - #1 AWG	1	600A OVERCURRENT PROTECTION	
-	-	P.SWBD1.VFDHP1	SWITCHBOARD SWBD-1	VARIABLE FREQUENCY DRIVE VFD-HP1	VARIABLE FREQUENCY DRIVE BRANCH CIRCUIT	480V	2 SETS OF (3) #4/0 AWG	1 - #3 AWG	3	200HP VFD, NOTE 1	
-	-	P.SWBD1.VFDHP3	SWITCHBOARD SWBD-1	VARIABLE FREQUENCY DRIVE VFD-HP3	VARIABLE FREQUENCY DRIVE BRANCH CIRCUIT	480V	2 SETS OF (3) #4/0 AWG	1 - #3 AWG	3	200HP VFD, NOTE 1	
-	-	P.SWBD1.VFDHP5	SWITCHBOARD SWBD-1	VARIABLE FREQUENCY DRIVE VFD-HP5	VARIABLE FREQUENCY DRIVE BRANCH CIRCUIT	480V	2 SETS OF (3) #4/0 AWG	1 - #3 AWG	3	200HP VFD, NOTE 1	
-	-	P.SWBD2.MCC1	SWITCHBOARD SWBD-2	MOTOR CONTROL CENTER MCC-1	MOTOR CONTROL CENTER FEEDER	480V	2 SETS OF (3) 350KCMIL	1 - #1 AWG	1	600A OVERCURRENT PROTECTION	
-	-	P.SWBD2.VFDHP2	SWITCHBOARD SWBD-2	VARIABLE FREQUENCY DRIVE VFD-HP2	VARIABLE FREQUENCY DRIVE BRANCH CIRCUIT	480V	2 SETS OF (3) #4/0 AWG	1 - #3 AWG	3	200HP VFD, NOTE 1	
-	-	P.SWBD2.VFDHP4	SWITCHBOARD SWBD-2	VARIABLE FREQUENCY DRIVE VFD-HP4	VARIABLE FREQUENCY DRIVE BRANCH CIRCUIT	480V	2 SETS OF (3) #4/0 AWG	1 - #3 AWG	3	200HP VFD, NOTE 1	
-	-	P.SWBD2.VFDHP6	SWITCHBOARD SWBD-2	VARIABLE FREQUENCY DRIVE VFD-HP6	VARIABLE FREQUENCY DRIVE BRANCH CIRCUIT	480V	2 SETS OF (3) #4/0 AWG	1 - #3 AWG	3	200HP VFD, NOTE 1	
K5	K5	P.SWBD2.OPS	SWITCHBOARD SWBD-2	OPERATIONS BUILDING (MAIN FEED)	MAIN POWER FEED TO OPERATIONS BUILDING	480V	1 SETS OF (3) #1 AWG	1 - #8 AWG	1		
F11, G3, I3	F11	P.VFD1.HP1	VARIABLE FREQUENCY DRIVE VFD-HP1	HYDRANT PUMP HP-1	PUMP BRANCH CIRCUIT	480V	3/C - 350KCMIL	(3) #2	2	200HP	
F12, G4, I4	F12	P.VFD2.HP2	VARIABLE FREQUENCY DRIVE VFD-HP2	HYDRANT PUMP HP-2	PUMP BRANCH CIRCUIT	480V	3/C - 350KCMIL	(3) #2	2	200HP	
F13, G5, I5	F13	P.VFD3.HP3	VARIABLE FREQUENCY DRIVE VFD-HP3	HYDRANT PUMP HP-3	PUMP BRANCH CIRCUIT	480V	3/C - 350KCMIL	(3) #2	2	200HP	
F14, G6, I6	F14	P.VFD4.HP4	VARIABLE FREQUENCY DRIVE VFD-HP4	HYDRANT PUMP HP-4	PUMP BRANCH CIRCUIT	480V	3/C - 350KCMIL	(3) #2	2	200HP	
F23, G15, I10	F23	P.VFD5.HP5	VARIABLE FREQUENCY DRIVE VFD-HP5	HYDRANT PUMP HP-5	PUMP BRANCH CIRCUIT	480V	3/C - 350KCMIL	(3) #2	2	200HP	
-	-	P.MCC1.VFDTP1	MOTOR CONTROL CENTER MCC-1	VARIABLE FREQUENCY DRIVE VFD-TP1	VARIABLE FREQUENCY DRIVE BRANCH CIRCUIT	480V	3/C - 350KCMIL	1 - #3 AWG	1	100HP VFD, NOTE 1	
Z37, T30, Q23, R23	Z37	P.VFDTP1.TP1	VARIABLE FREQUENCY DRIVE VFD-TP1	HYDRANT CART TEST STAND PUMP, TP-1	HCTS PUMP BRANCH CIRCUIT	480V	3/C - #2/0 AWG	1 - #6 AWG	2	100HP	
Z15, T7, L4	Z15	P.MCC1.OP1	MOTOR CONTROL CENTER MCC-1	OFFLOAD PUMP #1, OP-1	OFFLOAD PUMP, OP-1 BRANCH CIRCUIT	480V	3/C - #4 AWG	1 - #8 AWG	3	40HP	
Z26, T19, Q5, R5	Z26	P.MCC1.OP2	MOTOR CONTROL CENTER MCC-1	OFFLOAD PUMP #2, OP-2	OFFLOAD PUMP, OP-2 BRANCH CIRCUIT	480V	3/C - #4 AWG	1 - #8 AWG	3	40HP	
F22, G14, I9	F22	P.MCC1.TP2	MOTOR CONTROL CENTER MCC-1	TRANSFER PUMP, TP-2	TRANSFER PUMP BRANCH CIRCUIT	480V	3/C - #6 AWG	1 - #8 AWG	3	30HP	
-	-	P.MCC1.HVAC1	MOTOR CONTROL CENTER MCC-1	EXTERIOR HVAC UNIT 1, HVAC-1	EXTERIOR HVAC UNIT 1, HVAC-1 BRANCH CIRCUIT	480V	3/C - #1 AWG	1 - #6 AWG	3	110A BREAKER, QUANTITY AND SIZE BY VENDOR	
-	-	P.MCC1.HVAC2	MOTOR CONTROL CENTER MCC-1	EXTERIOR HVAC UNIT 2, HVAC-2	EXTERIOR HVAC UNIT 2, HVAC-2 BRANCH CIRCUIT	480V	3/C - #1 AWG	1 - #6 AWG	3	110A BREAKER, QUANTITY AND SIZE BY VENDOR	
-	-	P.MCC1.PNL5	MOTOR CONTROL CENTER MCC-1	480V PANELBOARD, PNL-5	480V PANELBOARD, PNL-5 BRANCH CIRCUIT	480V	3/C - #1 AWG	1 - #8 AWG	3	100A	
F3, E1	F3	P.MCC1.PP1	MOTOR CONTROL CENTER MCC-1	480V PANELBOARD, PP1	480V PANELBOARD, PP1 BRANCH CIRCUIT	480V	3/C - #1 AWG	1 - #8 AWG	3	100A	
-	-	P.MCC1.TR6	MOTOR CONTROL CENTER MCC-1	TRANSFORMER TR-6	TRANSFORMER TR-6 BRANCH CIRCUIT	480V	3/C - #6 AWG	1 - #10 AWG	3	30KVA	
-	-	P.TR6.PNL6	TRANSFORMER TR-6	120/208V PANELBOARD, PNL-6	120/208V PANELBOARD, PNL-6 BRANCH CIRCUIT	208V	4/C - #1 AWG	1 - #6 AWG	3	30KVA	
-	-	P.MCC1.TR7	MOTOR CONTROL CENTER MCC-1	TRANSFORMER TR-7	TRANSFORMER TR-7 BRANCH CIRCUIT	480V	3/C - #6 AWG	1 - #10 AWG	3	30KVA	
-	-	P.TR7.LP1	TRANSFORMER TR-7	120/208V LIGHTING PANELBOARD, LP-1	120/208V PANELBOARD, LP-1 BRANCH CIRCUIT	208V	4/C - #1 AWG	1 - #6 AWG	3	30KVA	

NOTES:

1. APPROVED EQUAL DLO CABLE (RHH/RHW) IS ACCEPTABLE FOR POWER CIRCUITS INTERIOR TO ELECTRICAL ENCLOSURE. CABLE SHALL MEET MINIMUM REQUIREMENTS AS INDICATED IN CABLE TYPE 1 AND 3.
2. SIZING BASED ON ANTICIPATED INPUT RATING OF THE VFD. CONDUCTOR SIZES MAY BE REDUCED BASED ON NAMEPLATE DATA AFTER SUPPLIED BY SUBCONTRACTOR.

CABLE TYPE	DESCRIPTION	TYPE
1	SINGLE CONDUCTOR, COPPER STRANDED WITH 600V RATING, UL LISTED, OIL RESISTANT, TYPE XHHW-2	480V POWER CABLE
2	MULTI CONDUCTOR, COPPER STRANDED WITH 1000V RATING, UL LISTED, XHHW-2, PVC OVERALL JACKET, COPPER TAPE SHIELD (100% COVERAGE), THREE SYMMETRICAL GROUND WIRES, OIL RESISTANT, UL LISTED	480V VFD CABLE
3	MULTI CONDUCTOR, COPPER STRANDED WITH 600V RATING, UL LISTED, TRAY CABLE, TC-ER, XHHW-2, PVC OVERALL JACKET, SUNLIGHT RESISTANT PER UL 1277, LISTED FOR USE IN CLASS I DIVISION 2 AREAS	480V POWER CABLE - MULTICONDUCTOR

no.	date	by	ckd	description
A	12/21/23	TSR	BAW	ISSUED FOR PERMIT

**ISSUED FOR PERMIT
ONLY**



9400 WARD PARKWAY
KANSAS CITY, MO 64114
816-333-9400
Burns & McDonnell Engineering Co., Inc.

date 04/24/2023	detailed S. JESBERG
designed T. RENSHAW	checked B. WINTER

PDX FUEL COMPANY L.L.C

PORTLAND INTERNATIONAL AIRPORT
5000 NE MARINE DR.
PORTLAND, OREGON 97218

PDX FACILITY IMPROVEMENTS

project	contract
153929	
drawing	rev.

file 153929E-703.dwg

12/20/2023

12/20/2023

Millimeters

Inches

Scale For Microfitting

		CONTROL CIRCUIT SCHEDULE													
DUCTBANK SECTION(S)	PDC STUB UP	CONTROL CIRCUIT SCHEDULE	FROM	TO	PURPOSE	SIGNAL	PLC I/O						CONDUCTORS		NOTES
							I	Q	A	AO	PULSE	COMM	QUANTITY AND SIZE	TYPE	
VEEDER ROOT PANEL															
-	-	C.FSC.HCARBON	TLS PANEL	FUEL SYSTEM CONTROL PNL (PLC-1)	HYDROCARBON ALARM TO PLC-1	120VAC	1	-	-	-	-	-	3/C #14	B	
Z29, T22, Q24, R24	Z29	IS.TLS.LT.RCT	TLS PANEL	RECLAIM TANK AUTOMATIC TANK GAUGE	ATG SYSTEM FOR RECLAIM TANK	I.S.	-	-	-	-	-	-	(1) TSP #18	G	SEE VENDOR CATALOG; BELDEN 88760
Z29, T22, Q24, R24	Z29	IS.TLS.LD.RCT	TLS PANEL	RECLAIM TANK LEAK SENSOR	LEAK SENSOR FOR RECLAIM TANK	I.S.	-	-	-	-	-	-	(1) TSP #18	G	SEE VENDOR CATALOG; BELDEN 88760
Z20, T20, Q21, R21	Z20	C.TLS.OAS	TLS PANEL	OVERFILL ALARM SWITCH	OVERFILL ALARM SWITCH TO TLS RELAY CARD	120VAC	-	-	-	-	-	-	3/C #14	B	
F27, G19, J6	F27	IS.TLS.HCARBON	TLS PANEL	HYDROCARBON SENSOR	SENSE HYDROCARBON WITHIN CONTAINMENT SUMP	I.S.	-	-	-	-	-	-	(1) TSP #18	G	SEE VENDOR CATALOG; BELDEN 88760
CONTAINMENT SUMP PANEL															
F16, G8, J2	NOTE 2	C.LSH.OWS.O	CONTAINMENT SUMP PANEL	FUEL SYSTEM CONTROL PNL (PLC-1)	OWS LEVEL SWITCH HIGH - OIL	120VAC	1	-	-	-	-	-	(3) #14	A	
F16, G8, J2	NOTE 2	C.LSH.OWS.L	CONTAINMENT SUMP PANEL	FUEL SYSTEM CONTROL PNL (PLC-1)	OWS LEVEL SWITCH HIGH - LIQUID	120VAC	1	-	-	-	-	-	(3) #14	A	
F16, G8, J2	NOTE 2	C.YP14.PERMISSIVE	CONTAINMENT SUMP PANEL	FUEL SYSTEM CONTROL PNL (PLC-1)	YARD PUMP - PLC RUN PERMISSIVE	120VAC	-	1	-	-	-	-	(3) #14	A	
-	-	C.CSP.OWS	CONTAINMENT SUMP PANEL	OWS LEVEL SWITCHES	OWS HIGH OIL AND LIQUID - LEVEL SWITCHES	120VAC	-	-	-	-	-	-	(5) #14	A	
-	-	IS.SUMPLS.START	CONTAINMENT SUMP PANEL	SUMP LEVEL SWITCH	SUMP HIGH LEVEL SWITCH - START	I.S.	-	-	-	-	-	-	VENDOR FURNISHED	VENDOR	CABLE SUPPLIED WITH FLOAT
-	-	IS.SUMPLS.STOP	CONTAINMENT SUMP PANEL	SUMP LEVEL SWITCH	SUMP LOW LEVEL SWITCH - STOP	I.S.	-	-	-	-	-	-	VENDOR FURNISHED	VENDOR	CABLE SUPPLIED WITH FLOAT
SUMP SEPARATOR SS-3															
F16, G8, J2	NOTE 2	C.LSH.SS3	SUMP SEPARATOR SS-3	FUEL SYSTEM CONTROL PNL (PLC-1)	LEVEL SWITCH HIGH - SS3 (LSH-SS3)	120VAC	1	-	-	-	-	-	3/C #14	B	
SUMP SEPARATOR SS-4															
Z9, T4, Q14, R14	Z9	C.LSH.SS4	SUMP SEPARATOR SS-4	FUEL SYSTEM CONTROL PNL (PLC-1)	LEVEL SWITCH HIGH - SS3 (LSH-SS4)	120VAC	1	-	-	-	-	-	3/C #14	B	
OFFLOAD PUMPS															
OFFLOAD PUMP #1															
-	-	C.EFSO.MCC.OP1	MOTOR CONTROL CENTER (MCC-1)	EFSSO PANEL	EFSSO INTERLOCK, OP-1	120VAC	-	-	-	-	-	-	2/C #14	B	
Z2, T5, L2	Z2	P.FIT.OP1	FUEL SYSTEM CONTROL PNL (PLC-1)	FLOW METER (FE-OP1)	METER POWER	24VDC	-	-	-	-	-	-	3/C #14	B	PD METER - POWER
Z2, T5, L2	Z2	I.FIT.OP1	FUEL SYSTEM CONTROL PNL (PLC-1)	FLOW METER (FE-OP1)	4-20MA SIGNAL	4-20mA	-	-	1	-	-	-	(1) TSP #16	E	PD METER - SIGNAL
Z15, T7, L4	Z15	C.FS.OP1	MOTOR CONTROL CENTER (MCC-1)	FLOW SWITCH (FS-OP1)	CONTROL SWITCH FS-OP1 POWER/STATUS	120VAC	-	-	-	-	-	-	5/C #14	B	
Z15, T7, L4	Z15	C.HS.OP1	MOTOR CONTROL CENTER (MCC-1)	HAND STATION (HS-OP1)	START STOP CONTROL (IN HAND)	120VAC	-	-	-	-	-	-	5/C #14	B	
Z15, T7, L4	Z15	C.MWTS.OP1	MOTOR CONTROL CENTER (MCC-1)	MOTOR WINDING TEMPERATURE SWITCH, OP-1	MOTOR WINDING TEMPERATURE SWITCH, OP-1	120VAC	-	-	-	-	-	-	3/C #14	B	
Z15, T7, L4	Z15	C.HTR.OP1	MOTOR CONTROL CENTER (MCC-1)	MOTOR HEATER, OP-1	MOTOR HEATER, OP-1	120VAC	-	-	-	-	-	-	3/C #14	B	
-	-	C.FSC.OP1	MOTOR CONTROL CENTER (MCC-1)	FUEL SYSTEM CONTROL PNL (PLC-1)	OP-1 PLC CONTROL/ RUN FEEDBACK / FLOW STATUS	120VAC	2	1	-	-	-	-	9/C #14	B	
OFFLOAD PUMP #2															
-	-	C.EFSO.MCC.OP2	MOTOR CONTROL CENTER (MCC-1)	EFSSO PANEL	EFSSO INTERLOCK, OP-2	120VAC	-	-	-	-	-	-	2/C #14	B	
Z8, T3, Q13, R13	Z8	P.FIT.OP2	FUEL SYSTEM CONTROL PNL (PLC-1)	FLOW METER (FE-OP2)	METER POWER	24VDC	-	-	-	-	-	-	3/C #14	B	PD METER - POWER
Z8, T3, Q13, R13	Z8	I.FIT.OP2	FUEL SYSTEM CONTROL PNL (PLC-1)	FLOW METER (FE-OP2)	4-20MA SIGNAL	4-20mA	-	-	1	-	-	-	(1) TSP #16	E	PD METER - SIGNAL
Z26, T19, Q5, R5	Z26	C.FS.OP2	MOTOR CONTROL CENTER (MCC-1)	FLOW SWITCH (FS-OP2)	CONTROL SWITCH FS-OP2 POWER/STATUS	120VAC	-	-	-	-	-	-	5/C #14	B	
Z26, T19, Q5, R5	Z26	C.HS.OP2	MOTOR CONTROL CENTER (MCC-1)	HAND STATION (HS-OP2)	START STOP CONTROL (IN HAND)	120VAC	-	-	-	-	-	-	5/C #14	B	
Z26, T19, Q5, R5	Z26	C.MWTS.OP2	MOTOR CONTROL CENTER (MCC-1)	MOTOR WINDING TEMPERATURE SWITCH, OP-2	MOTOR WINDING TEMPERATURE SWITCH, OP-2	120VAC	-	-	-	-	-	-	3/C #14	B	
Z26, T19, Q5, R5	Z26	C.HTR.OP2	MOTOR CONTROL CENTER (MCC-1)	MOTOR HEATER, OP-2	MOTOR HEATER, OP-2	120VAC	-	-	-	-	-	-	3/C #14	B	
-	-	C.FSC.OP2	MOTOR CONTROL CENTER (MCC-1)	FUEL SYSTEM CONTROL PNL (PLC-1)	OP-2 PLC CONTROL/ RUN FEEDBACK / FLOW STATUS	120VAC	2	1	-	-	-	-	9/C #14	B	
HYDRANT CART TEST STAND AND RECLAIM TANK															
TEST PUMP, TP-1															
Z8, T3, Q13, R13	Z8	P.FIT.HCTS	FUEL SYSTEM CONTROL PNL (PLC-1)	FLOW METER (FE-HCTS)	LOCAL DISPLAY/METER PULSE POWER	24VDC							3/C #14	B	LOCAL DISPLAY/METER PULSE - POWER
Z8, T3, Q13, R13	Z8	I.FIT.HCTS	FUEL SYSTEM CONTROL PNL (PLC-1)	FLOW METER (FE-HCTS)	4-20MA SIGNAL	4-20mA			1				(1) TSP #16	E	METER - SIGNAL
Z8, T3, Q13, R13	Z8	I.TT.TP1	FUEL SYSTEM CONTROL PNL (PLC-1)	MOTOR BEARING TEMPERATURE TRANSMITTER (TT-TP1)	MOTOR TEMPERATURE TRANSMITTER (TT-TP1)	4-20mA			1				(1) TSP #16	E	LOOP POWERED
Z8, T3, Q13, R13	Z8	I.VTX.TP1	FUEL SYSTEM CONTROL PNL (PLC-1)	MOTOR VIBRATION TRANSMITTERS (VT-TP1)	MOTOR VIBRATION TRANSMITTERS (VT-TP1)	4-20mA			1				(1) TSP #16	E	LOOP POWERED
Z8, T3, Q13, R13	Z8	I.VTY.TP1	FUEL SYSTEM CONTROL PNL (PLC-1)	MOTOR VIBRATION TRANSMITTERS (VT-TP1)	MOTOR VIBRATION TRANSMITTERS (VT-TP1)	4-20mA			1				(1) TSP #16	E	LOOP POWERED
Z37, T30, Q23, R23	Z37	C.HS.HCTS	VARIABLE FREQUENCY DRIVE, VFD TP1	HAND STATION (HS-HCTS)	RUN/STOP AND INDICATION LIGHTS	120VAC	-	-	-	-	-	-	6/C #14	B	
Z37, T30, Q23, R23	Z37	C.FSTS.TP1	VARIABLE FREQUENCY DRIVE, VFD-TP1	FLOW & TEMPERATURE SWITCHES TP1	FLOW & TEMPERATURE SWITCHES TP1	120VAC	-	-	-	-	-	-	7/C #14	B	
Z37, T30, Q23, R23	Z37	C.MWTS.TP1	VARIABLE FREQUENCY DRIVE, VFD-TP1	MOTOR WINDING TEMPERATURE SWITCH, TP-1	MOTOR WINDING TEMPERATURE SWITCH, TP-1	120VAC							3/C #14	B	
Z37, T30, Q23, R23	Z37	C.HTR.TP1	VARIABLE FREQUENCY DRIVE, VFD-TP1	MOTOR HEATER, TP-1	MOTOR HEATER, TP-1	120VAC							3/C #14	B	
Z8, T3, Q13, R13	Z8	I.PT.TP1	FUEL SYSTEM CONTROL PNL (PLC-1)	PRESSURE TRANSMITTER (PT-TP1)	4-20MA SIGNAL (DEVICE LOOP POWERED)	4-20mA			1				(1) TSP #16	E	LOOP POWERED
-	-	I.C.FSC.TP1	VARIABLE FREQUENCY DRIVE, VFD-TP1	FUEL SYSTEM CONTROL PNL (PLC-1)	VFD COMMUNICATIONS, TP-1	EOC						1	(1) CAT 6	C	
-	-	C.FSC.TP1	VARIABLE FREQUENCY DRIVE, VFD-TP1	FUEL SYSTEM CONTROL PNL (PLC-1)	FLOW/FUEL TEMP SWITCH, PLC RUN/STOP	120VAC	2	1					9/C #14	B	
-	-	C.EFSO.VFD.TP1	VARIABLE FREQUENCY DRIVE, VFD-TP1	EFSSO PANEL	EFSSO INTERLOCK, TP-1	24VDC							2/C #14	B	
RECLAIM TANK															
Z9, T4, Q14, R14	Z9	C.LSHH.RCT	FUEL SYSTEM CONTROL PNL (PLC-1)	RECLAIM TANK HIGH LEVEL ALARM	HIGH HIGH LEVEL SWITCH ALARM	120VAC	1	-	-	-	-	-	4/C #14	B	
RECLAIM TANK MOV5															
Z7, T2, Q11, R11	Z7	C.FSC.MOVRCS	FUEL SYSTEM CONTROL PNL (PLC-1)	RECLAIM SUPPLY	MOV CONTROL CABLE	120VAC	3	2	-	-	-	-	9/C #14	B	
Z7, T2, Q11, R11	Z7	C.FSC.MOVRCR	FUEL SYSTEM CONTROL PNL (PLC-1)	RECLAIM RETURN	MOV CONTROL CABLE	120VAC	3	2	-	-	-	-	9/C #14	B	
RECLAIM FILTER SEPARATORS															
Z8, T3, Q13, R13	Z8	I.DPIT.RFS1	FUEL SYSTEM CONTROL PNL (PLC-1)	DIFFERENTIAL PRESSURE XMTR (DPT-RFS1)	DIFFERENTIAL PRESSURE XMTR (DPT-RFS1)	4-20mA	-	-	1	-	-	-	(1) TSP #16	E	LOOP POWERED
Z8, T3, Q13, R13	Z8	I.DPIT.RFS2	FUEL SYSTEM CONTROL PNL (PLC-1)	DIFFERENTIAL PRESSURE XMTR (DPT-RFS2)	DIFFERENTIAL PRESSURE XMTR (DPT-RFS2)	4-20mA	-	-	1	-	-	-	(1) TSP #16	E	LOOP POWERED
Z9, T4, Q14, R14	Z9	C.MS.RFS1	FUEL SYSTEM CONTROL PNL (PLC-1)	MOISTURE SWITCH (MS-RFS1)	PWR / CNTRL TO MOISTURE SWITCH	120VAC	1	-	-	-	-	-	4/C #14	B	
-	-	IS.ME.RFS1	MOISTURE SWITCH	MOISTURE SENSOR	MOISTURE SENSOR TO MOISTURE CONTROLLER	I.S.	-	-	-	-	-	-	VENDOR FURNISHED	-	
-	-	C.JY.RFS1	MOISTURE SENSOR	WATER SLUG VALVE (SOLENOID)	FLOW CONTROL VALVE	120VAC	-	-	-	-	-	-	3/C #14	B	
Z9, T4, Q14, R14	Z9	C.MS.RFS2	FUEL SYSTEM CONTROL PNL (PLC-1)	MOISTURE SWITCH (MS-RFS2)	PWR / CNTRL TO MOISTURE SWITCH	120VAC	1	-	-	-	-	-	4/C #14	B	
-	-	IS.ME.RFS2	MOISTURE SWITCH	MOISTURE SENSOR	MOISTURE SENSOR TO MOISTURE CONTROLLER	I.S.	-	-	-	-	-	-	VENDOR FURNISHED	-	
-	-	C.JY.RFS2	MOISTURE SENSOR	WATER SLUG VALVE (SOLENOID)	FLOW CONTROL VALVE	120VAC	-	-	-	-	-	-	3/C #14	B	
HYDRANT CART TEST STAND ALARM PANEL															
Z22, T15, Q2, R2	Z22	C.FSC.HCTSAP	FUEL SYSTEM CONTROL PNL (PLC-1)	HYDRANT CART TEST STAND ALARM PANEL	ALARM INDICATION LIGHTS	120VAC	-	10	-	-	-	-	19/C	B	

- NOTES:
- CIRCUIT FOUND WITHIN CIRCUITS I.FSC.CJB1.3 AND I.FSC.CJB1.4.
 - CIRCUIT FOUND WITHIN CIRCUITS C.FSC.CJB1.1 AND C.FSC.CJB1.2.
 - DIRECT BURIED TO GENERATOR.
 - DIRECT BURIED TO EXTERIOR LIGHT POLE.

no.	date	by	ckd	description
A	12/21/23	TSR	BAW	ISSUED FOR PERMIT

ISSUED FOR PERMIT ONLY



9400 WARD PARKWAY
KANSAS CITY, MO 64114
816-333-9400
Burns & McDonnell Engineering Co, Inc.

date	04/24/2023	detailed	S. JESBERG
designed	T. RENSHAW	checked	B. WINTER

PDX FUEL COMPANY L.L.C

PORTLAND INTERNATIONAL AIRPORT
5000 NE MARINE DR.
PORTLAND, OREGON 97218

PDX FACILITY IMPROVEMENTS
CABLE SCHEDULE - 2

project	153929	contract	
drawing	E-704	rev.	A

file 153929E-704.dwg

1	2	3	4	5	6	7	8	9	10	11	12	13			
CONTROL CIRCUIT SCHEDULE															
DUCTBANK SECTION(S)	PDC STUB UP	CONTROL CIRCUIT SCHEDULE	FROM	TO	PURPOSE	SIGNAL	PLC I/O						CONDUCTORS		NOTES
							DI	DO	AI	AO	PULSE	COMM	QUANTITY AND SIZE	TYPE	
TANK FARM															
TANK CONTROL															
D2	D2	C.FSC.T5A	FUEL SYSTEM CONTROL PNL (PLC-1)	TANK 5 - MOV 5A	TANK 5 - MOV 5A CONTROL	120VAC	-	-	-	-	-	-	9/C #14	A / B	USE TYPE B IN CABLE TRAY
D2	D2	C.FSC.T5B	FUEL SYSTEM CONTROL PNL (PLC-1)	TANK 5 - MOV 5B	TANK 5 - MOV 5B CONTROL	120VAC	-	-	-	-	-	-	9/C #14	A / B	USE TYPE B IN CABLE TRAY
D2	D2	C.FSC.T6A	FUEL SYSTEM CONTROL PNL (PLC-1)	TANK 6 - MOV 6A	TANK 6 - MOV 6A CONTROL	120VAC	-	-	-	-	-	-	9/C #14	A / B	USE TYPE B IN CABLE TRAY
D2	D2	C.FSC.T6B	FUEL SYSTEM CONTROL PNL (PLC-1)	TANK 6 - MOV 6B	TANK 6 - MOV 6B CONTROL	120VAC	-	-	-	-	-	-	9/C #14	A / B	USE TYPE B IN CABLE TRAY
D2	D2	C.FSC.T7A	FUEL SYSTEM CONTROL PNL (PLC-1)	TANK 7 - MOV 7A	TANK 7 - MOV 7A CONTROL	120VAC	-	-	-	-	-	-	9/C #14	A / B	USE TYPE B IN CABLE TRAY
D2	D2	C.FSC.T7B	FUEL SYSTEM CONTROL PNL (PLC-1)	TANK 7 - MOV 7B	TANK 7 - MOV 7B CONTROL	120VAC	-	-	-	-	-	-	9/C #14	A / B	USE TYPE B IN CABLE TRAY
D2	D2	C.DSLSH.T5	FUEL SYSTEM CONTROL PNL (PLC-1)	FIELD DEWATERING SUMP LEVEL SWITCH	DEWATERING SUMP LEVEL SWITCH HIGH - (DSLSH)	120VAC	-	-	-	-	-	-	3/C #14	A / B	USE TYPE B IN CABLE TRAY
D2	D2	C.DSLSH.T6	FUEL SYSTEM CONTROL PNL (PLC-1)	FIELD DEWATERING SUMP LEVEL SWITCH	DEWATERING SUMP LEVEL SWITCH HIGH - (DSLSH)	120VAC	-	-	-	-	-	-	3/C #14	A / B	USE TYPE B IN CABLE TRAY
D2	D2	C.DSLSH.T7	FUEL SYSTEM CONTROL PNL (PLC-1)	FIELD DEWATERING SUMP LEVEL SWITCH	DEWATERING SUMP LEVEL SWITCH HIGH - (DSLSH)	120VAC	-	-	-	-	-	-	3/C #14	A / B	USE TYPE B IN CABLE TRAY
D2	D2	P.FSC.ATG	FUEL SYSTEM CONTROL PNL (PLC-1)	ATG POWER TERMINAL BOX	POWER TO TANK ATG	120VAC	-	-	-	-	-	-	2-#12 + #12 GND	A	
F19, G21, J6	F19	C.TANK1.CTLP	FUEL SYSTEM CONTROL PNL (PLC-1)	ROSEMOUNT TANK HUB 2410 - TANK 1	CONTROL POWER FOR TANK INSTRUMENTS	120VAC							3/C #14	B	
F19, G21, J6	F19	C.TANK2.CTLP	FUEL SYSTEM CONTROL PNL (PLC-1)	ROSEMOUNT TANK HUB 2410 - TANK 2	CONTROL POWER FOR TANK INSTRUMENTS	120VAC							3/C #14	B	
F19, G21, J6	F19	C.TANK3.CTLP	FUEL SYSTEM CONTROL PNL (PLC-1)	ROSEMOUNT TANK HUB 2410 - TANK 3	CONTROL POWER FOR TANK INSTRUMENTS	120VAC							3/C #14	B	
F15, G7, J1	F15	C.MOV1A.CTL	FUEL SYSTEM CONTROL PNL (PLC-1)	TANK 1 - MOV 1A	TANK 1 - MOV 1A CONTROL	120VAC	3	2					9/C #14	B	
F15, G7, J1	F15	C.MOV1B.CTL	FUEL SYSTEM CONTROL PNL (PLC-1)	TANK 1 - MOV 1B	TANK 1 - MOV 1B CONTROL	120VAC	3	2					9/C #14	B	
F15, G7, J1	F15	C.MOV2A.CTL	FUEL SYSTEM CONTROL PNL (PLC-1)	TANK 2 - MOV 2A	TANK 2 - MOV 2A CONTROL	120VAC	3	2					9/C #14	B	
F15, G7, J1	F15	C.MOV2B.CTL	FUEL SYSTEM CONTROL PNL (PLC-1)	TANK 2 - MOV 2B	TANK 2 - MOV 2B CONTROL	120VAC	3	2					9/C #14	B	
F15, G7, J1	F15	C.MOV3A.CTL	FUEL SYSTEM CONTROL PNL (PLC-1)	TANK 3 - MOV 3A	TANK 3 - MOV 3A CONTROL	120VAC	3	2					9/C #14	B	
F15, G7, J1	F15	C.MOV3B.CTL	FUEL SYSTEM CONTROL PNL (PLC-1)	TANK 3 - MOV 3B	TANK 3 - MOV 3B CONTROL	120VAC	3	2					9/C #14	B	
POWER DISTRIBUTION CENTER (PDC)															
EFSO PANEL															
D5	D5	C.LS.T5	EFSO PANEL - FUEL FACILITY	FIELD LEVEL SWITCH	TANK LEVEL SWITCH	120VAC	-	-	-	-	-	-	9/C #14	A / B	USE TYPE B IN CABLE TRAY
D5	D5	C.LS.T6	EFSO PANEL - FUEL FACILITY	FIELD LEVEL SWITCH	TANK LEVEL SWITCH	120VAC	-	-	-	-	-	-	9/C #14	A / B	USE TYPE B IN CABLE TRAY
D5	D5	C.LS.T7	EFSO PANEL - FUEL FACILITY	FIELD LEVEL SWITCH	TANK LEVEL SWITCH	120VAC	-	-	-	-	-	-	9/C #14	A / B	USE TYPE B IN CABLE TRAY
D5	D5	C.EFSO.T5A	EFSO PANEL - FUEL FACILITY	TANK 5 - SUCTION MOV	TANK 5 - MOV, EFSO INTERLOCK	120VAC	-	-	-	-	-	-	3/C #14	A / B	USE TYPE B IN CABLE TRAY
D5	D5	C.EFSO.T5B	EFSO PANEL - FUEL FACILITY	TANK 5 - FILL MOV	TANK 5 - MOV, EFSO INTERLOCK	120VAC	-	-	-	-	-	-	3/C #14	A / B	USE TYPE B IN CABLE TRAY
D5	D5	C.EFSO.T6A	EFSO PANEL - FUEL FACILITY	TANK 6 - SUCTION MOV	TANK 6 - MOV, EFSO INTERLOCK	120VAC	-	-	-	-	-	-	3/C #14	A / B	USE TYPE B IN CABLE TRAY
D5	D5	C.EFSO.T6B	EFSO PANEL - FUEL FACILITY	TANK 6 - FILL MOV	TANK 6 - MOV, EFSO INTERLOCK	120VAC	-	-	-	-	-	-	3/C #14	A / B	USE TYPE B IN CABLE TRAY
D5	D5	C.EFSO.T7A	EFSO PANEL - FUEL FACILITY	TANK 7 - SUCTION MOV	TANK 7 - MOV, EFSO INTERLOCK	120VAC	-	-	-	-	-	-	3/C #14	A / B	USE TYPE B IN CABLE TRAY
D5	D5	C.EFSO.T7B	EFSO PANEL - FUEL FACILITY	TANK 7 - FILL MOV	TANK 7 - MOV, EFSO INTERLOCK	120VAC	-	-	-	-	-	-	3/C #14	A / B	USE TYPE B IN CABLE TRAY
D5	D5	C.EFSO.T5W	EFSO PANEL - FUEL FACILITY	HAND STATION - EFSO	EFSO PUSHBUTTON AT TANK	120VAC	-	-	-	-	-	-	3/C #14	A / B	USE TYPE B IN CABLE TRAY
D5	D5	C.EFSO.T5E	EFSO PANEL - FUEL FACILITY	HAND STATION - EFSO	EFSO PUSHBUTTON AT TANK	120VAC	-	-	-	-	-	-	3/C #14	A / B	USE TYPE B IN CABLE TRAY
D5	D5	C.EFSO.T5I	EFSO PANEL - FUEL FACILITY	HAND STATION - EFSO	EFSO PUSHBUTTON AT TANK	120VAC	-	-	-	-	-	-	3/C #14	A / B	USE TYPE B IN CABLE TRAY
D5	D5	C.EFSO.T6W	EFSO PANEL - FUEL FACILITY	HAND STATION - EFSO	EFSO PUSHBUTTON AT TANK	120VAC	-	-	-	-	-	-	3/C #14	A / B	USE TYPE B IN CABLE TRAY
D5	D5	C.EFSO.T6E	EFSO PANEL - FUEL FACILITY	HAND STATION - EFSO	EFSO PUSHBUTTON AT TANK	120VAC	-	-	-	-	-	-	3/C #14	A / B	USE TYPE B IN CABLE TRAY
D5	D5	C.EFSO.T6I	EFSO PANEL - FUEL FACILITY	HAND STATION - EFSO	EFSO PUSHBUTTON AT TANK	120VAC	-	-	-	-	-	-	3/C #14	A / B	USE TYPE B IN CABLE TRAY
D5	D5	C.EFSO.T7W	EFSO PANEL - FUEL FACILITY	HAND STATION - EFSO	EFSO PUSHBUTTON AT TANK	120VAC	-	-	-	-	-	-	3/C #14	A / B	USE TYPE B IN CABLE TRAY
D5	D5	C.EFSO.T7E	EFSO PANEL - FUEL FACILITY	HAND STATION - EFSO	EFSO PUSHBUTTON AT TANK	120VAC	-	-	-	-	-	-	3/C #14	A / B	USE TYPE B IN CABLE TRAY
D5	D5	C.EFSO.T7I	EFSO PANEL - FUEL FACILITY	HAND STATION - EFSO	EFSO PUSHBUTTON AT TANK	120VAC	-	-	-	-	-	-	3/C #14	A / B	USE TYPE B IN CABLE TRAY
K3	K3	C.EFSO.OPSRM	EFSO PANEL - FUEL FACILITY	HAND STATION - EFSO OPERATIONS ROOM	EFSO PUSHBUTTON IN OPERATIONS ROOM	120VAC							2/C #14	B	
Z1, T14, Q1, R1	Z1	C.EFSO.HCTS	EFSO PANEL - FUEL FACILITY	HAND STATION - EFSO HCTS	EFSO PUSHBUTON BY HYDRANT CART TEST STAND	120VAC							2/C #14	B	
Z1, T9, L1	Z1	C.EFSO.OP1	EFSO PANEL - FUEL FACILITY	HAND STATION - EFSO OP1	EFSO PUSHBUTTON BY OFFLOAD PUMP 1	120VAC	-	-	-	-	-	-	2/C #14	B	
Z1, T14, Q1, R1	Z1	C.EFSO.OP2	EFSO PANEL - FUEL FACILITY	HAND STATION - EFSO OP2	EFSO PUSHBUTTON BY OFFLOAD PUMP 2	120VAC							2/C #14	B	
F16, G8, J2	NOTE 2	C.EFSO.T3EX	EFSO PANEL - FUEL FACILITY	HAND STATION - EFSO T3EX	EFSO PUSHBUTTON AT TANK 3 AREA EXIT	120VAC	-	-	-	-	-	-	2/C #14	B	
F16, G8, J2	NOTE 2	C.EFSO.T12EX	EFSO PANEL - FUEL FACILITY	HAND STATION - EFSO T12EX	EFSO PUSHBUTTON AT TANK 1&2 AREA EXIT	120VAC	-	-	-	-	-	-	2/C #14	B	
F16, G8, J2	NOTE 2	C.EFSO.PPA	EFSO PANEL - FUEL FACILITY	HAND STATION - EFSO PPA	EFSO PUSHBUTTON IN PUMP PAD AREA	120VAC	-	-	-	-	-	-	2/C #14	B	
F20, E4	F20	C.EFSO.AIRSIDE	EFSO PANEL - FUEL FACILITY	ROOM 1660 RELAY PANEL	EFSO ALARM RELAY PANEL IN ROOM 1660	120VAC							2/C #14	B	
F15, G7, J1	F15	C.EFSO.MOV1A	EFSO PANEL - FUEL FACILITY	TANK 1 - MOV 1A	TANK 1 - MOV 1A, EFSO INTERLOCK	120VAC							2/C #14	B	
F15, G7, J1	F15	C.EFSO.MOV1B	EFSO PANEL - FUEL FACILITY	TANK 1 - MOV 1B	TANK 1 - MOV 1B, EFSO INTERLOCK	120VAC							2/C #14	B	
F15, G7, J1	F15	C.EFSO.MOV2A	EFSO PANEL - FUEL FACILITY	TANK 2 - MOV 2A	TANK 2 - MOV 2A, EFSO INTERLOCK	120VAC							2/C #14	B	
F15, G7, J1	F15	C.EFSO.MOV2B	EFSO PANEL - FUEL FACILITY	TANK 2 - MOV 2B	TANK 2 - MOV 2B, EFSO INTERLOCK	120VAC							2/C #14	B	
F15, G7, J1	F15	C.EFSO.MOV3A	EFSO PANEL - FUEL FACILITY	TANK 3 - MOV 3A	TANK 3 - MOV 3A, EFSO INTERLOCK	120VAC							2/C #14	B	
F15, G7, J1	F15	C.EFSO.MOV3B	EFSO PANEL - FUEL FACILITY	TANK 3 - MOV 3B	TANK 3 - MOV 3B, EFSO INTERLOCK	120VAC							2/C #14	B	
Z7, T2, Q11, R11	Z7	C.EFSO.MOVRCS	EFSO PANEL - FUEL FACILITY	CANOPY - MOV RCS	MOV RCS, EFSO INTERLOCK	120VAC	-	-	-	-	-	-	2/C #14	B	
Z7, T2, Q11, R11	Z7	C.EFSO.MOVRCR	EFSO PANEL - FUEL FACILITY	CANOPY - MOV RCR	MOV RCR, EFSO INTERLOCK	120VAC	-	-	-	-	-	-	2/C #14	B	
F19, G21, J6	F19	C.LSHH.T1	EFSO PANEL - FUEL FACILITY	FIELD LEVEL SWITCH	LEVEL SWITCH HIGH - TANK 1 (LSHH-T1)	120VAC	-						3/C #14	B	
F19, G21, J6	F19	C.LSHH.T2	EFSO PANEL - FUEL FACILITY	FIELD LEVEL SWITCH	LEVEL SWITCH HIGH - TANK 2 (LSHH-T2)	120VAC	-						3/C #14	B	
F19, G21, J6	F19	C.LSHH.T3	EFSO PANEL - FUEL FACILITY	FIELD LEVEL SWITCH	LEVEL SWITCH HIGH - TANK 3 (LSHH-T3)	120VAC	-						3/C #14	B	
-	-	C.EFSO.BYPASS	EFSO PANEL - FUEL FACILITY	FUEL SYSTEM CONTROL PNL (PLC-1)	PLC INDICATION THAT EFSO IS IN BYPASS	120VAC	1						2/C #14	B	
-	-	C.LSHH.T1.2	EFSO PANEL - FUEL FACILITY	FUEL SYSTEM CONTROL PNL (PLC-1)	LEVEL SWITCH HIGH - TANK 1 (LSHH-T1)	120VAC	1						2/C #14	B	
-	-	C.LSHH.T2.2	EFSO PANEL - FUEL FACILITY	FUEL SYSTEM CONTROL PNL (PLC-1)	LEVEL SWITCH HIGH - TANK 2 (LSHH-T2)	120VAC	1						2/C #14	B	
-	-	C.LSHH.T3.2	EFSO PANEL - FUEL FACILITY	FUEL SYSTEM CONTROL PNL (PLC-1)	LEVEL SWITCH HIGH - TANK 3 (LSHH-T3)	120VAC	1						2/C #14	B	
-	-	C.EFSO.R1.2	EFSO PANEL - FUEL FACILITY	FUEL SYSTEM CONTROL PNL (PLC-1)	CONTROL ROOM (IN PDC) - EFSO STATUS	120VAC	1						2/C #14	B	
-	-	C.EFSO.R2.2	EFSO PANEL - FUEL FACILITY	FUEL SYSTEM CONTROL PNL (PLC-1)	HCTS/EAST EXIT EFSO STATUS	120VAC	1						2/C #14	B	
-	-	C.EFSO.R3.2	EFSO PANEL - FUEL FACILITY	FUEL SYSTEM CONTROL PNL (PLC-1)	OFFLOAD EFSO STATUS	120VAC	1						2/C #14	B	
-	-	C.EFSO.R4.2	EFSO PANEL - FUEL FACILITY	FUEL SYSTEM CONTROL PNL (PLC-1)	TANK/PUMP PAD EFSO STATUS	120VAC	1						2/C #14	B	
-	-	C.EFSO.R5.2	EFSO PANEL - FUEL FACILITY	FUEL SYSTEM CONTROL PNL (PLC-1)	AIRSIDE ACTIVATION	120VAC	1						2/C #14	B	
-	-	C.EFSO.R6.2	EFSO PANEL - FUEL FACILITY	FUEL SYSTEM CONTROL PNL (PLC-1)	OPERATIONS ROOM EFSO STATUS	120VAC	1						2/C #14	B	
-	-	C.EFSO.R1.3	EFSO PANEL - FUEL FACILITY	FIRE ALARM CONTROL UNIT (FACU)	CONTROL ROOM (IN PDC) - EFSO STATUS	120VAC	-	-	-	-	-	-	2/C #14	B	
-	-	C.EFSO.R2.3	EFSO PANEL - FUEL FACILITY	FIRE ALARM CONTROL UNIT (FACU)	HCTS/EAST EXIT EFSO STATUS	120VAC	-	-	-	-	-	-	2/C #14	B	
-	-	C.EFSO.R3.3	EFSO PANEL - FUEL FACILITY	FIRE ALARM CONTROL UNIT (FACU)	OFFLOAD EFSO STATUS	120VAC	-	-	-	-	-	-	2/C #14	B	
-	-	C.EFSO.R4.3	EFSO PANEL - FUEL FACILITY	FIRE ALARM CONTROL UNIT (FACU)	TANK/PUMP PAD EFSO STATUS	120VAC	-	-	-	-	-	-	2/C #14	B	
-	-	C.EFSO.R5.3	EFSO PANEL - FUEL FACILITY	FIRE ALARM CONTROL UNIT (FACU)	AIRSIDE ACTIVATION	120VAC	-	-	-	-	-				

no.	date	by	ckd	description
A	12/21/23	TSR	BAW	ISSUED FOR PERMIT

ISSUED FOR PERMIT ONLY



BURNS

MCDONNELL

9400 WARD PARKWAY
KANSAS CITY, MO 64114
816-333-9400
Burns & McDonnell Engineering Co, Inc.

date	04/24/2023	detailed	S. JESBERG
designed	T. RENSCHAW	checked	B. WINTER

PDX FUEL COMPANY L.L.C

PORTLAND INTERNATIONAL AIRPORT
5000 NE MARINE DR.
PORTLAND, OREGON 97218

PDX FACILITY IMPROVEMENTS
CABLE SCHEDULE - 3

project	153929	contract	
drawing	E-705	rev.	A

file 153929E-705.dwg

Millimeters
Inches
Scale For Microfitting

CONTROL CIRCUIT SCHEDULE															
DUCTBANK SECTION(S)	PDC STUB UP	CONTROL CIRCUIT SCHEDULE	FROM	TO	PURPOSE	SIGNAL	PLC I/O						CONDUCTORS		NOTES
							I	DO	A	AO	PULSE	COMM	QUANTITY AND SIZE	TYPE	
PANELBOARDS															
F1, G1, I1	F1	P.PNL5.1	PANELBOARD 5	SEE PANEL SCHDL.	SEE PANEL SCHDL.	480VAC	-	-	-	-	-	-	SEE PANEL SCHDL.	A	
F1, G1, I1	F1	P.PNL5.2	PANELBOARD 5	SEE PANEL SCHDL.	SEE PANEL SCHDL.	480VAC	-	-	-	-	-	-	SEE PANEL SCHDL.	A	
F1, G1, I1	F1	P.PNL5.7	PANELBOARD 5	SEE PANEL SCHDL.	SEE PANEL SCHDL.	480VAC	-	-	-	-	-	-	SEE PANEL SCHDL.	A	
F10, G2, I7	F10	P.PNL5.8	PANELBOARD 5	SEE PANEL SCHDL.	SEE PANEL SCHDL.	480VAC	-	-	-	-	-	-	SEE PANEL SCHDL.	A	
F10, G2, I7	F10	P.PNL5.13	PANELBOARD 5	SEE PANEL SCHDL.	SEE PANEL SCHDL.	480VAC	-	-	-	-	-	-	SEE PANEL SCHDL.	A	
F10, G2, I7	F10	P.PNL5.14	PANELBOARD 5	SEE PANEL SCHDL.	SEE PANEL SCHDL.	480VAC	-	-	-	-	-	-	SEE PANEL SCHDL.	A	
Z25, T18, Q12, R12	Z25	P.PNL5.19	PANELBOARD 5	SEE PANEL SCHDL.	SEE PANEL SCHDL.	480VAC	-	-	-	-	-	-	SEE PANEL SCHDL.	A	
Z3, T32, Q6,S3	Z3	P.PNL5.26	PANELBOARD 5	SEE PANEL SCHDL.	SEE PANEL SCHDL.	480VAC	-	-	-	-	-	-	SEE PANEL SCHDL.	A	
D29	D29	P.PNL5.32	PANELBOARD 5	SEE PANEL SCHDL.	SEE PANEL SCHDL.	480VAC	-	-	-	-	-	-	SEE PANEL SCHDL.	A / B	USE TYPE B IN CABLE TRAY
D29	D29	P.PNL5.37	PANELBOARD 5	SEE PANEL SCHDL.	SEE PANEL SCHDL.	480VAC	-	-	-	-	-	-	SEE PANEL SCHDL.	A / B	USE TYPE B IN CABLE TRAY
D29	D29	P.PNL5.38	PANELBOARD 5	SEE PANEL SCHDL.	SEE PANEL SCHDL.	480VAC	-	-	-	-	-	-	SEE PANEL SCHDL.	A / B	USE TYPE B IN CABLE TRAY
-	-	P.PNL6.7	PANELBOARD 6	SEE PANEL SCHDL.	SEE PANEL SCHDL.	480VAC	-	-	-	-	-	-	SEE PANEL SCHDL.	A	
F1, G1, I1	F1	P.PNL6.8	PANELBOARD 6	SEE PANEL SCHDL.	SEE PANEL SCHDL.	480VAC	-	-	-	-	-	-	SEE PANEL SCHDL.	A	
-	-	P.PNL6.11	PANELBOARD 6	SEE PANEL SCHDL.	SEE PANEL SCHDL.	480VAC	-	-	-	-	-	-	SEE PANEL SCHDL.	A	
D38	D38	P.PNL6.30	PANELBOARD 6	SEE PANEL SCHDL.	SEE PANEL SCHDL.	208VAC	-	-	-	-	-	-	SEE PANEL SCHDL.	A / B	USE TYPE B IN CABLE TRAY
D38	D38	P.PNL6.31	PANELBOARD 6	SEE PANEL SCHDL.	SEE PANEL SCHDL.	208VAC	-	-	-	-	-	-	SEE PANEL SCHDL.	A / B	USE TYPE B IN CABLE TRAY
Z35, T28, Q20, R20	Z35	P.PNL6.34	PANELBOARD 6	SEE PANEL SCHDL.	SEE PANEL SCHDL.	208VAC	-	-	-	-	-	-	SEE PANEL SCHDL.	A	-
D38	D38	P.PNL6.35	PANELBOARD 6	SEE PANEL SCHDL.	SEE PANEL SCHDL.	208VAC	-	-	-	-	-	-	SEE PANEL SCHDL.	A / B	USE TYPE B IN CABLE TRAY
-	NOTE 3	P.PNL6.14	PANELBOARD 6	SEE PANEL SCHDL.	SEE PANEL SCHDL.	480VAC	-	-	-	-	-	-	SEE PANEL SCHDL.	A	
-	-	P.LP1.1	PANELBOARD LP1	SEE PANEL SCHDL.	SEE PANEL SCHDL.	480VAC	-	-	-	-	-	-	SEE PANEL SCHDL.	A	
-	-	P.LP1.2	PANELBOARD LP1	SEE PANEL SCHDL.	SEE PANEL SCHDL.	480VAC	-	-	-	-	-	-	SEE PANEL SCHDL.	A	
-	NOTE 4	P.LP1.3	PANELBOARD LP1	SEE PANEL SCHDL.	SEE PANEL SCHDL.	480VAC	-	-	-	-	-	-	SEE PANEL SCHDL.	A	
-	-	P.LP1.4	PANELBOARD LP1	SEE PANEL SCHDL.	SEE PANEL SCHDL.	480VAC	-	-	-	-	-	-	SEE PANEL SCHDL.	A	
-	-	P.LP1.5	PANELBOARD LP1	SEE PANEL SCHDL.	SEE PANEL SCHDL.	480VAC	-	-	-	-	-	-	SEE PANEL SCHDL.	A	
-	-	P.LP1.7	PANELBOARD LP1	LIGHTING CONTACTOR	SEE PANEL SCHDL.	208VAC	-	-	-	-	-	-	SEE PANEL SCHDL.	A	
Z14, T31, L3	Z14	P.LP1.7.1	PANELBOARD LP1	SEE PANEL SCHDL.	SEE PANEL SCHDL.	208VAC	-	-	-	-	-	-	SEE PANEL SCHDL.	A	.1, DOWNSTREAM OF CONTACTOR
Z14, T28, Q20, R20	Z14	P.LP1.11	PANELBOARD LP1	SEE PANEL SCHDL.	SEE PANEL SCHDL.	120VAC	-	-	-	-	-	-	SEE PANEL SCHDL.	A	
-	-	P.LP1.20	PANELBOARD LP1	LIGHTING CONTACTOR	SEE PANEL SCHDL.	208VAC	-	-	-	-	-	-	SEE PANEL SCHDL.	A	
D18	D18	P.LP1.20.1	LIGHTING CONTACTOR	SEE PANEL SCHDL.	SEE PANEL SCHDL.	208VAC	-	-	-	-	-	-	SEE PANEL SCHDL.	A / B	USE TYPE B IN CABLE TRAY
-	-	P.LP1.21	PANELBOARD LP1	LIGHTING CONTACTOR	SEE PANEL SCHDL.	120VAC	-	-	-	-	-	-	SEE PANEL SCHDL.	A	
D18	D18	P.LP1.21.1	LIGHTING CONTACTOR	SEE PANEL SCHDL.	SEE PANEL SCHDL.	120VAC	-	-	-	-	-	-	SEE PANEL SCHDL.	A / B	USE TYPE B IN CABLE TRAY
-	-	P.LP1.23	PANELBOARD LP1	LIGHTING CONTACTOR	SEE PANEL SCHDL.	120VAC	-	-	-	-	-	-	SEE PANEL SCHDL.	A	
D18	D18	P.LP1.23.1	LIGHTING CONTACTOR	SEE PANEL SCHDL.	SEE PANEL SCHDL.	120VAC	-	-	-	-	-	-	SEE PANEL SCHDL.	A / B	USE TYPE B IN CABLE TRAY
-	-	P.LP1.24	PANELBOARD LP1	LIGHTING CONTACTOR	SEE PANEL SCHDL.	208VAC	-	-	-	-	-	-	SEE PANEL SCHDL.	A	
D18	D18	P.LP1.24.1	LIGHTING CONTACTOR	SEE PANEL SCHDL.	SEE PANEL SCHDL.	208VAC	-	-	-	-	-	-	SEE PANEL SCHDL.	A / B	USE TYPE B IN CABLE TRAY
-	-	P.LP1.25	PANELBOARD LP1	LIGHTING CONTACTOR	SEE PANEL SCHDL.	120VAC	-	-	-	-	-	-	SEE PANEL SCHDL.	A	
D18	D18	P.LP1.25.1	LIGHTING CONTACTOR	SEE PANEL SCHDL.	SEE PANEL SCHDL.	120VAC	-	-	-	-	-	-	SEE PANEL SCHDL.	A / B	USE TYPE B IN CABLE TRAY
D42	D42	P.LP1.32	PANELBOARD LP1	SEE PANEL SCHDL.	SEE PANEL SCHDL.	120VAC	-	-	-	-	-	-	SEE PANEL SCHDL.	A / B	USE TYPE B IN CABLE TRAY
D42	D42	P.LP1.34	PANELBOARD LP1	SEE PANEL SCHDL.	SEE PANEL SCHDL.	120VAC	-	-	-	-	-	-	SEE PANEL SCHDL.	A / B	USE TYPE B IN CABLE TRAY
D42	D42	P.LP1.36	PANELBOARD LP1	SEE PANEL SCHDL.	SEE PANEL SCHDL.	120VAC	-	-	-	-	-	-	SEE PANEL SCHDL.	A / B	USE TYPE B IN CABLE TRAY
-	-	P.UIT.T5	ATG POWER TERMINAL BOX	TANK 5 - ATG	TANK 5 - ATG	120VAC	-	-	-	-	-	-	3/C #12	B	IN CABLE TRAY
-	-	P.UIT.T6	ATG POWER TERMINAL BOX	TANK 6 - ATG	TANK 6 - ATG	120VAC	-	-	-	-	-	-	3/C #12	B	IN CABLE TRAY
-	-	P.UIT.T7	ATG POWER TERMINAL BOX	TANK 7 - ATG	TANK 7 - ATG	120VAC	-	-	-	-	-	-	3/C #12	B	IN CABLE TRAY
NETWORK ARCHITECTURE															
Z4	Z4	IC.FSC.AFS	HH-5	PDC - AIRSIDE EFSO CONNECTION	COMMUNICATION TO AIRSIDE - EFSO CABINETS	EOF						1	6-STRAND	H	
K2	K2	IC.FSC.FSHMI	FUEL SYSTEM CONTROL PNL (PLC-1)	CONTROL ROOM - OPS BUILDING	CONTROL ROOM DATA CONNECTION	EOC						1	(1) CAT 6	C	
K2	K2	IC.FSC.FSHMI	FUEL SYSTEM CONTROL PNL (PLC-1)	CONTROL ROOM - NEW OPS BUILDING	CONTROL ROOM DATA CONNECTION	EOC						1	(1) CAT 6	C	
K2	K2	IC.FSC.EFSOHMI	FUEL SYSTEM CONTROL PNL (PLC-1)	CONTROL ROOM - OPS BUILDING	CONTROL ROOM DATA CONNECTION	EOC						1	(1) CAT 6	C	
K2	K2	IC.FSC.EFSOHMI	FUEL SYSTEM CONTROL PNL (PLC-1)	CONTROL ROOM - NEW OPS BUILDING	CONTROL ROOM DATA CONNECTION	EOC						1	(1) CAT 6	C	
K2	K2	IC.FSC.PR	FUEL SYSTEM CONTROL PNL (PLC-1)	CONTROL ROOM - OPS BUILDING	CONTROL ROOM DATA CONNECTION	EOC						1	(1) CAT 6	C	
K2	K2	IC.FSC.PR	FUEL SYSTEM CONTROL PNL (PLC-1)	CONTROL ROOM - NEW OPS BUILDING	CONTROL ROOM DATA CONNECTION	EOC						1	(1) CAT 6	C	
-	-	IC.INTERNET.OPS	INTERNET PROVIDER	IT ROOM - NEW OPS BUILDING	SITE INTERNET CONNECTION	EOF						1	12-STRAND	-	PROVIDED BY INERNET PROVIDER
K4	K4	IC.INTERNET.PDC	IT ROOM - NEW OPS BUILDING	PDC - INTERNET DROP	PDC INTERNET CONNECTION	EOF						1	12-STRAND	H	
F8, E2	F8	IC.FSC.TEMP	FUEL SYSTEM CONTROL PNL (PLC-1)	EXISTING MOTOR CONTROL ROOM	DATA CONNECTION DURING TRANSITION	EOC						1	(1) CAT 6	C	
F28, G20, J7	F28	IC.FSC.WTG	FUEL SYSTEM CONTROL PNL (PLC-1)	WIRELESS GATEWAY EXISTING	TANK INSTRUMENTS	EOC						1	(1) CAT 6	C	
-	-	IC.FSC.PM	FUEL SYSTEM CONTROL PNL (PLC-1)	SWITCHGEAR, SWGR-1	METER DATA CONNECTION	EOC						1	(1) CAT 6	C	
F9, E3	F9	IC.FSC.AFS	FUEL SYSTEM CONTROL PNL (PLC-1)	AIRPORT FIRE STATION	ALARM COMMUNICATION TO FIRE STATION	EOF						1	6-STRAND	H	
D6	D6	IC.FSC.ATG	FUEL SYSTEM CONTROL PNL (PLC-1)	ATG COMMUNICATION TERMINAL BOX	COMMUNICATION TO TANK ATG	FIELDBUS						1	(1) TSP #18	D	
-	-	IC.UIT.T5	ATG COMMUNICATION TERMINAL BOX	TANK UIT	COMMUNICATION TO TANK UIT	FIELDBUS						1	(1) TSP #18	D	
-	-	IC.UIT.T6	ATG COMMUNICATION TERMINAL BOX	TANK UIT	COMMUNICATION TO TANK UIT	FIELDBUS						1	(1) TSP #18	D	
-	-	IC.UIT.T7	ATG COMMUNICATION TERMINAL BOX	TANK UIT	COMMUNICATION TO TANK UIT	FIELDBUS						1	(1) TSP #18	D	
ATG															
-	-	IS.TT.T5	TT-T5	LT-T5	ATG DATA - TEMP XMTR	FIELDBUS	-	-	-	-	-	1	(1) TSP #16	E	
-	-	IS.LT.T5	LT-T5	UIT-T5	ATG DATA - LEVEL XMTR	FIELDBUS	-	-	-	-	-	1	(1) TSP #16	E	
-	-	IC.PT.T5	PT-T5	UIT-T5	ATG DATA - PRESSURE XMTR	4-20 mA	-	-	-	-	-	1	(1) TSP #16	E	
-	-	IS.TT.T6	TT-T6	LT-T6	ATG DATA - TEMP XMTR	FIELDBUS	-	-	-	-	-	1	(1) TSP #16	E	
-	-	IS.LT.T6	LT-T6	near sp	ATG DATA - LEVEL XMTR	FIELDBUS	-	-	-	-	-	1	(1) TSP #16	E	
-	-	IC.PT.T6	PT-T6	UIT-T6	ATG DATA - PRESSURE XMTR	4-20 mA	-	-	-	-	-	1	(1) TSP #16	E	
-	-	IS.TT.T7	TT-T7	LT-T7	ATG DATA - TEMP XMTR	FIELDBUS	-	-	-	-	-	1	(1) TSP #16	E	
-	-	IS.LT.T7	LT-T7	UIT-T7	ATG DATA - LEVEL XMTR	FIELDBUS	-	-	-	-	-	1	(1) TSP #16	E	
-	-	IC.PT.T7	PT-T7	UIT-T6	ATG DATA - PRESSURE XMTR	4-20 mA	-	-	-	-	-	1	(1) TSP #16	E	

NOTES:

1. CIRCUIT FOUND WITHIN CIRCUITS I.FSC.CJB1.3 AND I.FSC.CJB1.4.
2. CIRCUIT FOUND WITHIN CIRCUITS C.FSC.CJB1.1 AND C.FSC.CJB1.2.
3. DIRECT BURIED TO GENERATOR.
4. DIRECT BURIED TO EXTERIOR LIGHT POLE.

12/20/2023

no.	date	by	ckd	description
A	12/21/23	TSR	BAW	ISSUED FOR PERMIT

ISSUED FOR PERMIT ONLY



9400 WARD PARKWAY
KANSAS CITY, MO 64114
816-333-9400
Burns & McDonnell Engineering Co, Inc.

date	04/24/2023	detailed	S. JESBERG
designed	T. RENSHAW	checked	B. WINTER

PDX FUEL COMPANY L.L.C

PORTLAND INTERNATIONAL AIRPORT
5000 NE MARINE DR.
PORTLAND, OREGON 97218

PDX FACILITY IMPROVEMENTS
CABLE SCHEDULE - 4

project	153929	contract	
drawing	E-706	rev.	A

			CONTROL CIRCUIT SCHEDULE													
DUCT/BANK SECTION(S)	PDC STUB UP	CONTROL CIRCUIT SCHEDULE	FROM	TO	PURPOSE	SIGNAL	PLC I/O					CONDUCTORS		NOTES		
							DI	DO	AI	AO	PULSE	COMM	QUANTITY AND SIZE		TYPE	
MISCELLANEOUS																
AOA CABINET																
Z36	Z36	IC.AOA.FIBER	HH-6	AOA CABINET	AOA SECURITY FIBER	EOF						1	12-STRAND	-		
SECURITY																
-	-	IC.EC01.ICCR	ENCLOSURE CABINET 01	INTERCOM AND CARD READER	INTERCOM AND CARD READER								VENDOR FURNISHED			FURNISHED WITH CARD READER EQUIPMENT
-	-	IC.EC01.CT01	ENCLOSURE CABINET 01	CAMERA 01	CAMERA 01	EOC							(1) CAT 6A			COPPER WIRE
-	-	IC.EC01.CR	ENCLOSURE CABINET 01	CARD READER (MAIN GATE)	CARD READER (MAIN GATE)								VENDOR FURNISHED			FURNISHED WITH CARD READER EQUIPMENT
-	-	IC.EC01.CR	ENCLOSURE CABINET 01	CARD READER (AOA GATE)	CARD READER (AOA GATE)								VENDOR FURNISHED			FURNISHED WITH CARD READER EQUIPMENT
-	-	IC.EC01.GC	ENCLOSURE CABINET 01	GATE CONTROLLER	GATE CONTROLLER								VENDOR FURNISHED			FURNISHED WITH GATE CONTROLLER EQUIPMENT
-	-	IC.EC01.LDGC	ENCLOSURE CABINET 01	LANE DETECTOR AND GATE CONTROLLER	LANE DETECTOR AND GATE CONTROLLER								VENDOR FURNISHED			FURNISHED WITH GATE CONTROLLER EQUIPMENT
-	-	IC.EC02.CT02	ENCLOSURE CABINET 02	CAMERA 02	CAMERA 02	EOC							(1) CAT 6A			COPPER WIRE
-	-	IC.EC02.CT03	ENCLOSURE CABINET 02	CAMERA 03	CAMERA 03	EOC							(1) CAT 6A			COPPER WIRE
-	-	IC.EC02.CT04	ENCLOSURE CABINET 02	CAMERA 04	CAMERA 04	EOC							(1) CAT 6A			COPPER WIRE
R7, S4	-	IC.EC02.CT22	ENCLOSURE CABINET 02	CAMERA 22	CAMERA 22	EOC							(1) CAT 6A			COPPER WIRE
R7, S4	-	IC.EC02.CT23	ENCLOSURE CABINET 02	CAMERA 23	CAMERA 23	EOC							(1) CAT 6A			COPPER WIRE
-	-	IC.EC03.CT05	ENCLOSURE CABINET 03	CAMERA 05	CAMERA 05	EOC							(1) CAT 6A			COPPER WIRE
-	-	IC.EC03.CT06	ENCLOSURE CABINET 03	CAMERA 06	CAMERA 06	EOC							(1) CAT 6A			COPPER WIRE
-	-	IC.EC03.CT07	ENCLOSURE CABINET 03	CAMERA 07	CAMERA 07	EOC							(1) CAT 6A			COPPER WIRE
-	-	IC.EC03.CT08	ENCLOSURE CABINET 03	CAMERA 08	CAMERA 08	EOC							(1) CAT 6A			COPPER WIRE
-	-	IC.EC03.CT09	ENCLOSURE CABINET 03	CAMERA 09	CAMERA 09	EOC							(1) CAT 6A			COPPER WIRE
-	-	IC.EC03.CT10	ENCLOSURE CABINET 03	CAMERA 10	CAMERA 10	EOC							(1) CAT 6A			COPPER WIRE
-	-	IC.EC04.CT11	ENCLOSURE CABINET 04	CAMERA 11	CAMERA 11	EOC							(1) CAT 6A			COPPER WIRE
-	-	IC.EC04.CT12	ENCLOSURE CABINET 04	CAMERA 12	CAMERA 12	EOC							(1) CAT 6A			COPPER WIRE
-	-	IC.EC04.CT13	ENCLOSURE CABINET 04	CAMERA 13	CAMERA 13	EOC							(1) CAT 6A			COPPER WIRE
-	-	IC.EC04.CT14	ENCLOSURE CABINET 04	CAMERA 14	CAMERA 14	EOC							(1) CAT 6A			COPPER WIRE
-	-	IC.EC05.CT15	ENCLOSURE CABINET 05	CAMERA 15	CAMERA 15	EOC							(1) CAT 6A			COPPER WIRE
-	-	IC.EC05.CT16	ENCLOSURE CABINET 05	CAMERA 16	CAMERA 16	EOC							(1) CAT 6A			COPPER WIRE
-	-	IC.EC05.CT17	ENCLOSURE CABINET 05	CAMERA 17	CAMERA 17	EOC							(1) CAT 6A			COPPER WIRE
-	-	IC.EC05.CT18	ENCLOSURE CABINET 05	CAMERA 18	CAMERA 18	EOC							(1) CAT 6A			COPPER WIRE
-	-	IC.EC06.CT19	ENCLOSURE CABINET 06	CAMERA 19	CAMERA 19	EOC							(1) CAT 6A			COPPER WIRE
-	-	IC.EC06.CT20	ENCLOSURE CABINET 06	CAMERA 20	CAMERA 20	EOC							(1) CAT 6A			COPPER WIRE
-	-	IC.OPS.CT21	OPERATIONS BUILDING	CAMERA 21	CAMERA 21	EOC							(1) CAT 6A			COPPER WIRE
OPERATIONS BUILDING																
IT. ROOM 106																
M2, N2	-	IC.OPS.EC01	OPERATIONS BUILDING	ENCLOSURE CABINET 01	SECURITY FIBER	EOF							24-STRAND	H		
Y1, T36, Q8, S1	-	IC.OPS.EC02	OPERATIONS BUILDING	ENCLOSURE CABINET 02	SECURITY FIBER	EOF							24-STRAND	H		
Y1, T36, Q8, S1, X1	-	IC.OPS.EC03	OPERATIONS BUILDING	ENCLOSURE CABINET 03	SECURITY FIBER	EOF							24-STRAND	H		
Y1, T36, Q8, S1, X1	-	IC.OPS.EC04	OPERATIONS BUILDING	ENCLOSURE CABINET 04	SECURITY FIBER	EOF							24-STRAND	H		
Y1, T36, Q8, S1, X1	-	IC.OPS.EC05	OPERATIONS BUILDING	ENCLOSURE CABINET 05	SECURITY FIBER	EOF							24-STRAND	H		
Y1, T36, Q8, S1, X1	-	IC.OPS.EC06	OPERATIONS BUILDING	ENCLOSURE CABINET 06	SECURITY FIBER	EOF							24-STRAND	H		
MECH. ROOM 102																
N3, M3	-	P.PNLA2.57	PANELBOARD A2	WEST GATE MOTOR OPERATOR (1 HP)	POWER TO GATE OPERATOR	208VAC	-	-	-	-	-	-	3-#10 + #10 GND	A		
N3, M3	-	P.PNLA2.69	PANELBOARD A2	AOA GATE MOTOR OPERATOR (1 HP)	POWER TO GATE OPERATOR	208VAC	-	-	-	-	-	-	3-#10 + #10 GND	A		
Y2,Q26, S2, X2	-	P.PNLA2.75	PANELBOARD A2	SECURITY CABINET (EC02, EC03, EC06)	POWER TO SECURITY CABINET	120VAC	-	-	-	-	-	-	3-#12 + #12 GND	A		
Y2,Q26, S2, X2	-	P.PNLA2.77	PANELBOARD A2	SECURITY CABINET (EC04, EC05)	POWER TO SECURITY CABINET	120VAC	-	-	-	-	-	-	3-#12 + #12 GND	A		
N5, M5	-	P.PNLA2.79	PANELBOARD A2	SECURITY CABINET (EC01)	POWER TO SECURITY CABINET	120VAC	-	-	-	-	-	-	3-#12 + #12 GND	A		
M1, P1/N1	-	P.PNLH1.XX	PANELBOARD H1	AREA LIGHTS / PARKING LIGHTS	POWER TO LIGHTS	480VAC	-	-	-	-	-	-	2-#10 + #10 GND	A		
HYDRANT MAIN AND BYPASS, INCOMING FILTRATION																
HYDRANT MAIN LINE																
F17, G9, J3	NOTE 1	I.PT.MAIN1	FUEL SYSTEM CONTROL PNL (PLC-1)	PRESSURE TRANSMITTER MAIN #1 (PT-MAIN1)	4-20MA SIGNAL (DEVICE LOOP POWERED)	4-20mA			1				(1) TSP #16	E		LOOP POWERED
F17, G9, J3	NOTE 1	I.PT.MAIN2	FUEL SYSTEM CONTROL PNL (PLC-1)	PRESSURE TRANSMITTER MAIN #2 (PT-MAIN2)	4-20MA SIGNAL (DEVICE LOOP POWERED)	4-20mA			1				(1) TSP #16	E		LOOP POWERED
F17, G9, J3	NOTE 1	I.PT.MAIN3	FUEL SYSTEM CONTROL PNL (PLC-1)	PRESSURE TRANSMITTER MAIN #3 (PT-MAIN3)	4-20MA SIGNAL (DEVICE LOOP POWERED)	4-20mA			1				(1) TSP #16	E		LOOP POWERED
RECIRC LINE																
F16, G8, J2	NOTE 2	C.JY.RCL1.1	FUEL SYSTEM CONTROL PNL (PLC-1)	RECIRC FLOW CONTROL VALVE 1	FLOW CONTROL VALVE	120VAC		1					3/C #14	B		
F16, G8, J2	NOTE 2	C.JY.RCL1.2	FUEL SYSTEM CONTROL PNL (PLC-1)	RECIRC FLOW CONTROL VALVE 1	FLOW CONTROL VALVE	120VAC		1					3/C #14	B		
F16, G8, J2	NOTE 2	C.JY.RCL1.3	FUEL SYSTEM CONTROL PNL (PLC-1)	RECIRC FLOW CONTROL VALVE 1	FLOW CONTROL VALVE	120VAC		1					3/C #14	B		SPARE FOR FUTURE AUTOMATIC BYPASS
F17, G9, J3	F17	P.FE.RCL1	FUEL SYSTEM CONTROL PNL (PLC-1)	RECIRC FLOW METER 1 (FE-RCL1)	METER POWER	24VDC							3/C #14	B		ULTRASONIC METER - POWER
F17, G9, J3	NOTE 1	I.FE.RCL1	FUEL SYSTEM CONTROL PNL (PLC-1)	RECIRC FLOW METER 1 (FE-RCL1)	4-20MA SIGNAL	4-20mA			1				(1) TSP #16	E		ULTRASONIC METER - SIGNAL
F16, G8, J2	NOTE 2	C.JY.RCL2.1	FUEL SYSTEM CONTROL PNL (PLC-1)	RECIRC FLOW CONTROL VALVE 2	FLOW CONTROL VALVE	120VAC		1					3/C #14	B		
F16, G8, J2	NOTE 2	C.JY.RCL2.2	FUEL SYSTEM CONTROL PNL (PLC-1)	RECIRC FLOW CONTROL VALVE 1	FLOW CONTROL VALVE	120VAC		1					3/C #14	B		
F16, G8, J2	NOTE 2	C.JY.RCL2.3	FUEL SYSTEM CONTROL PNL (PLC-1)	RECIRC FLOW CONTROL VALVE 1	FLOW CONTROL VALVE	120VAC		1					3/C #14	B		SPARE FOR FUTURE AUTOMATIC BYPASS
INCOMING FILTRATION																
F16, G8, J2	NOTE 2	C.AE.FS6	FUEL SYSTEM CONTROL PNL (PLC-1)	MOISTURE SENSOR (ME-FS6)	MOISTURE SENSOR (ME-FS6)	120VAC	1						2/C #14	B		
F17, G9, J3	NOTE 1	I.DPT.FS6	FUEL SYSTEM CONTROL PNL (PLC-1)	DIFFERENTIAL PRESSURE TRANSMITTER (DPT-FS6)	DIFFERENTIAL PRESSURE TRANSMITTER (DPT-FS6)	4-20mA			1				(1) TSP #16	E		LOOP POWERED
F17, G9, J3	NOTE 1	I.DPT.CF1	FUEL SYSTEM CONTROL PNL (PLC-1)	DIFFERENTIAL PRESSURE TRANSMITTER (DPT-CF6)	DIFFERENTIAL PRESSURE TRANSMITTER (DPT-CF6)	4-20mA			1				(1) TSP #16	E		LOOP POWERED
F17, G9, J3	NOTE 1	I.DPT.PF1	FUEL SYSTEM CONTROL PNL (PLC-1)	DIFFERENTIAL PRESSURE TRANSMITTER (DPT-PF6)	DIFFERENTIAL PRESSURE TRANSMITTER (DPT-PF6)	4-20mA			1				(1) TSP #16	E		LOOP POWERED
TRANSFER PUMP 2																
-	-	C.FSC.TP2	MOTOR CONTROL CENTER (MCC-1)	FUEL SYSTEM CONTROL PNL (PLC-1)	FLOW STATUS, RUN STATUS, PLC RUN/STOP	120VAC	2	1					6/C #14	B		
F22, G14, I9	F22	C.HS.TP2.1	MOTOR CONTROL CENTER (MCC-1)	HAND STATION (HS1-TP2)	RUN STOP CONTROL (IN HAND)	120VAC							3/C #14	B		
F3, E1	F3	C.HS.TP2.2	MOTOR CONTROL CENTER (MCC-1)	HAND STATION (HS2-TP2)	RUN STOP CONTROL (IN HAND)	120VAC	-	-	-	-	-	-	3/C #14	B		
F22, G14, I9	F22	C.FS.TP2	MOTOR CONTROL CENTER (MCC-1)	FLOW SWITCH (FS-TP2)	CONTROL SWITCH FS-TP2 POWER/STATUS	120VAC							3/C #14	B		
F22, G14, I9	F22	C.JY.TP2	MOTOR CONTROL CENTER (MCC-1)	FLOW CONTROL VALVE (FC-TP2)	FLOW CONTROL VALVE	120VAC		0					3/C #14	B		
F22, G14, I9	F22	C.MWTS.TP2	MOTOR CONTROL CENTER (MCC-1)	MOTOR WINDING TEMPERATURE SWITCH, TP-2	MOTOR WINDING TEMPERATURE SWITCH, TP-2	120VAC							2/C #14	B		
F22, G14, I9	F22	C.HTR.TP2	MOTOR CONTROL CENTER (MCC-1)	MOTOR HEATER, TP-2	MOTOR HEATER, TP-2	120VAC							3/C #14	B		
F20, E4	F20	C.FSC.SG	FUEL SYSTEM CONTROL PNL (PLC-1)	SCULLY GROUND	SCULLY GROUND AT SLOP TANK	120VAC	1						2/C #14	B		
-	-	C.EFSO.TP2	MOTOR CONTROL CENTER (MCC-1)	EF50 PANEL	EF50 SHUTDOWN	120VAC							2/C #14	B		

NOTES:

1. CIRCUIT FOUND WITHIN CIRCUITS I.FSC.CJB1.3 AND I.FSC.CJB1.4.
2. CIRCUIT FOUND WITHIN CIRCUITS C.FSC.CJB1.1 AND C.FSC.CJB1.2.
3. DIRECT BURIED TO GENERATOR.
4. DIRECT BURIED TO EXTERIOR LIGHT POLE.

12/20/2023

no.	date	by	ckd	description
A	12/21/23	TSR	BAW	ISSUED FOR PERMIT

**ISSUED FOR PERMIT
ONLY**



9400 WARD PARKWAY
KANSAS CITY, MO 64114
816-333-9400
Burns & McDonnell Engineering Co., Inc.

date 04/24/2023	detailed S. JESBERG
designed T. RENSHAW	checked B. WINTER

PDX FUEL COMPANY L.L.C

PORTLAND INTERNATIONAL AIRPORT
5000 NE MARINE DR.
PORTLAND, OREGON 97218

PDX FACILITY IMPROVEMENTS

project	contract
153929	
drawing	rev.

E-707

A

file 153929E-707.dwg

Millimeters
Inches
Scale For Microfinning

CONTROL CIRCUIT SCHEDULE															
DUCTBANK SECTION(S)	PDC STUB UP	CONTROL CIRCUIT SCHEDULE	FROM	TO	PURPOSE	SIGNAL	PLC I/O						CONDUCTORS		NOTES
							I	DO	A	AO	PULSE	COMM	QUANTITY AND SIZE	TYPE	
HYDRANT PUMP PAD															
HYDRANT PUMP TRAIN 1															
F18, G10, J4	F18	C.ME.HFS1	CONTROL JUNCTION BOX #1	MOISTURE SWITCH (ME-HFS1)	PWR / CNTRL TO MOISTURE SWITCH (ME-HFS1)	120VAC							4/C #14	B	
-	-	IS.ME.HFS1	MOISTURE SWITCH	MOISTURE SENSOR	MOISTURE SENSOR TO MOISTURE CONTROLLER	I.S.							VENDOR FURNISHED	-	
F18, G10, J4	F18	C.JY.HP1	CONTROL JUNCTION BOX #1	WATER SLUG VALVE SOLENOID (JY-HP1)	WATER SLUG VALVE SOLENOID (JY-HP1)	120VAC							3/C #14	B	
F18, G10, J4	F18	C.FSTS.HP1	CONTROL JUNCTION BOX #1	FLOW & TEMPERATURE SWITCHES (FSTS-HP1)	FLOW & TEMPERATURE SWITCHES (FSTS-HP1)	120VAC							7/C #14	B	
F11, G3, I3	F11	C.MWTS. HP1	CONTROL JUNCTION BOX #1	MOTOR WINDING TEMPERATURE SWITCH, HP-1	MOTOR WINDING TEMPERATURE SWITCH, HP-1	120VAC							2/C #14	B	
F30, G11, H1	F30	C.HS.HP1.1	CONTROL JUNCTION BOX #1	HAND STATION (HS-HP1)	RUN STOP CONTROL (IN HAND)	120VAC							3/C #14	B	
F30, G11, H1	F30	C.HS.HP1.2	CONTROL JUNCTION BOX #1	HAND STATION (HS-HP1)	FIELD RUN INDICATION LIGHT	24VDC							2/C #14	B	
F11, G3, I3	F11	C.HTR.HP1	CONTROL JUNCTION BOX #1	MOTOR HEATER, HP-1	MOTOR HEATER, HP-1	120VAC							3/C #14	B	
-	-	C.EFSO.HP1	VARIABLE FREQUENCY DRIVE, VFD-HP1	EFSSO PANEL	EFSSO INTERLOCK, HP-1	120VAC							2/C #14	B	
-	-	IC.FSC.VFD1	VARIABLE FREQUENCY DRIVE, VFD-HP1	FUEL SYSTEM CONTROL PNL (PLC-1)	VFD COMMUNICATIONS, HP-1	EOC					1		(1) CAT 6	C	
F17, G9, J3	NOTE 1	I.FE.HP1	CONTROL JUNCTION BOX #1	FLOW METER, HP-1	4-20MA SIGNAL (DEVICE LOOP POWERED)	4-20mA			1				(1) TSP #16	E	CONDITIONED DP METER - LOOP POWERED
F17, G9, J3	NOTE 1	I.DPT.HFS1	CONTROL JUNCTION BOX #1	DIFFERENTIAL PRESSURE XMTR (DPT-HFS1)	DIFFERENTIAL PRESSURE XMTR (DPT-HFS1)	4-20mA			1				(1) TSP #16	E	LOOP POWERED
-	-	C.FSC.HP1	VARIABLE FREQUENCY DRIVE, VFD-HP1	FUEL SYSTEM CONTROL PNL (PLC-1)	MOIST/FLOW/FUEL TEMP SWITCH, PLC RUN/STOP	120VAC	3	1					9/C #14	B	WITH 2 SPARE CONDUCTORS
F17, G9, J3	NOTE 1	I.TT.HP1	CONTROL JUNCTION BOX #1	MOTOR BEARING TEMPERATURE TRANSMITTER (TT-HP1)	MOTOR TEMPERATURE TRANSMITTER (TT-HP1)	4-20mA			1				(1) TSP #16	E	LOOP POWERED
F17, G9, J3	NOTE 1	I.VT.HP1.1	CONTROL JUNCTION BOX #1	MOTOR VIBRATION TRANSMITTERS (VT-HP1), SET 1	MOTOR VIBRATION TRANSMITTERS (VT-HP1)	4-20mA			1				(1) TSP #16	E	LOOP POWERED
F17, G9, J3	NOTE 1	I.VT.HP1.2	CONTROL JUNCTION BOX #1	MOTOR VIBRATION TRANSMITTERS (VT-HP1), SET 2	MOTOR VIBRATION TRANSMITTERS (VT-HP1)	4-20mA			1				(1) TSP #16	E	LOOP POWERED
HYDRANT PUMP TRAIN 2															
F18, G10, J4	F18	C.ME.HFS2	CONTROL JUNCTION BOX #1	MOISTURE SWITCH (ME-HFS2)	PWR / CNTRL TO MOISTURE SWITCH (ME-HFS2)	120VAC							4/C #14	B	
-	-	IS.ME.HFS2	MOISTURE SWITCH	MOISTURE SENSOR	MOISTURE SENSOR TO MOISTURE CONTROLLER	I.S.							VENDOR FURNISHED	-	
F18, G10, J4	F18	C.JY.HP2	CONTROL JUNCTION BOX #1	WATER SLUG VALVE SOLENOID (JY-HP2)	WATER SLUG VALVE SOLENOID (JY-HP2)	120VAC							3/C #14	B	
F18, G10, J4	F18	C.FSTS.HP2	CONTROL JUNCTION BOX #1	FLOW & TEMPERATURE SWITCHES (FSTS-HP2)	FLOW & TEMPERATURE SWITCHES (FSTS-HP2)	120VAC							7/C #14	B	
F12, G4, I4	F12	C.MWTS. HP2	CONTROL JUNCTION BOX #1	MOTOR WINDING TEMPERATURE SWITCH, HP-2	MOTOR WINDING TEMPERATURE SWITCH, HP-2	120VAC							2/C #14	B	
F30, G11, H1	F30	C.HS.HP2.1	CONTROL JUNCTION BOX #1	HAND STATION (HS-HP2)	RUN STOP CONTROL (IN HAND)	120VAC							3/C #14	B	
F30, G11, H1	F30	C.HS.HP2.2	CONTROL JUNCTION BOX #1	HAND STATION (HS-HP2)	FIELD RUN INDICATION LIGHT	24VDC							2/C #14	B	
F12, G4, I4	F12	C.HTR.HP2	CONTROL JUNCTION BOX #1	MOTOR HEATER, HP-2	MOTOR HEATER, HP-2	120VAC							3/C #14	B	
-	-	C.EFSO.HP2	VARIABLE FREQUENCY DRIVE, VFD-HP2	EFSSO PANEL	EFSSO INTERLOCK, HP-2	120VAC							2/C #14	B	
-	-	IC.FSC.VFD2	VARIABLE FREQUENCY DRIVE, VFD-HP2	FUEL SYSTEM CONTROL PNL (PLC-1)	VFD COMMUNICATIONS, HP-2	EOC					1		(1) CAT 6	C	
F17, G9, J3	NOTE 1	I.FE.HP2	CONTROL JUNCTION BOX #1	FLOW METER, HP-2	4-20MA SIGNAL (DEVICE LOOP POWERED)	4-20mA			1				(1) TSP #16	E	CONDITIONED DP METER - LOOP POWERED
F17, G9, J3	NOTE 1	I.DPT.HFS2	CONTROL JUNCTION BOX #1	DIFFERENTIAL PRESSURE XMTR (DPT-HFS2)	DIFFERENTIAL PRESSURE XMTR (DPT-HFS2)	4-20mA			1				(1) TSP #16	E	LOOP POWERED
-	-	C.FSC.HP2	VARIABLE FREQUENCY DRIVE, VFD-HP2	FUEL SYSTEM CONTROL PNL (PLC-1)	MOIST/FLOW/FUEL TEMP SWITCH, PLC RUN/STOP	120VAC	3	1					9/C #14	B	WITH 2 SPARE CONDUCTORS
F17, G9, J3	NOTE 1	I.TT.HP2	CONTROL JUNCTION BOX #1	MOTOR BEARING TEMPERATURE TRANSMITTER (TT-HP2)	MOTOR TEMPERATURE TRANSMITTER (TT-HP2)	4-20mA			1				(1) TSP #16	E	LOOP POWERED
F17, G9, J3	NOTE 1	I.VT.HP2.1	CONTROL JUNCTION BOX #1	MOTOR VIBRATION TRANSMITTERS (VT-HP2), SET 1	MOTOR VIBRATION TRANSMITTERS (VT-HP2)	4-20mA			1				(1) TSP #16	E	LOOP POWERED
F17, G9, J3	NOTE 1	I.VT.HP2.2	CONTROL JUNCTION BOX #1	MOTOR VIBRATION TRANSMITTERS (VT-HP2), SET 2	MOTOR VIBRATION TRANSMITTERS (VT-HP2)	4-20mA			1				(1) TSP #16	E	LOOP POWERED
HYDRANT PUMP TRAIN 3															
F18, G10, J4	F18	C.ME.HFS3	CONTROL JUNCTION BOX #1	MOISTURE SWITCH (ME-HFS3)	PWR / CNTRL TO MOISTURE SWITCH (ME-HFS3)	120VAC							4/C #14	B	
-	-	IS.ME.HFS3	MOISTURE SWITCH	MOISTURE SENSOR	MOISTURE SENSOR TO MOISTURE CONTROLLER	I.S.							VENDOR FURNISHED	-	
F18, G10, J4	F18	C.JY.HP3	CONTROL JUNCTION BOX #1	WATER SLUG VALVE SOLENOID (JY-HP3)	WATER SLUG VALVE SOLENOID (JY-HP3)	120VAC							3/C #14	B	
F18, G10, J4	F18	C.FSTS.HP3	CONTROL JUNCTION BOX #1	FLOW & TEMPERATURE SWITCHES (FSTS-HP3)	FLOW & TEMPERATURE SWITCHES (FSTS-HP3)	120VAC							7/C #14	B	
F13, G5, I5	F13	C.MWTS. HP3	CONTROL JUNCTION BOX #1	MOTOR WINDING TEMPERATURE SWITCH, HP-3	MOTOR WINDING TEMPERATURE SWITCH, HP-3	120VAC							2/C #14	B	
F30, G11, H1	F30	C.HS.HP3.1	CONTROL JUNCTION BOX #1	HAND STATION (HS-HP3)	RUN STOP CONTROL (IN HAND)	120VAC							3/C #14	B	
F30, G11, H1	F30	C.HS.HP3.2	CONTROL JUNCTION BOX #1	HAND STATION (HS-HP3)	FIELD RUN INDICATION LIGHT	24VDC							2/C #14	B	
F13, G5, I5	F13	C.HTR.HP3	CONTROL JUNCTION BOX #1	MOTOR HEATER, HP-3	MOTOR HEATER, HP-3	120VAC							3/C #14	B	
-	-	C.EFSO.HP3	VARIABLE FREQUENCY DRIVE, VFD-HP3	EFSSO PANEL	EFSSO INTERLOCK, HP-3	120VAC							2/C #14	B	
-	-	IC.FSC.VFD3	VARIABLE FREQUENCY DRIVE, VFD-HP3	FUEL SYSTEM CONTROL PNL (PLC-1)	VFD COMMUNICATIONS, HP-3	EOC					1		(1) CAT 6	C	
F17, G9, J3	NOTE 1	I.FE.HP3	CONTROL JUNCTION BOX #1	FLOW METER, HP-3	4-20MA SIGNAL (DEVICE LOOP POWERED)	4-20mA			1				(1) TSP #16	E	CONDITIONED DP METER - LOOP POWERED
F17, G9, J3	NOTE 1	I.DPT.HFS3	CONTROL JUNCTION BOX #1	DIFFERENTIAL PRESSURE XMTR (DPT-HFS3)	DIFFERENTIAL PRESSURE XMTR (DPT-HFS3)	4-20mA			1				(1) TSP #16	E	LOOP POWERED
-	-	C.FSC.HP3	VARIABLE FREQUENCY DRIVE, VFD-HP3	FUEL SYSTEM CONTROL PNL (PLC-1)	MOIST/FLOW/FUEL TEMP SWITCH, PLC RUN/STOP	120VAC	3	1					9/C #14	B	WITH 2 SPARE CONDUCTORS
F17, G9, J3	NOTE 1	I.TT.HP3	CONTROL JUNCTION BOX #1	MOTOR BEARING TEMPERATURE TRANSMITTER (TT-HP3)	MOTOR TEMPERATURE TRANSMITTER (TT-HP3)	4-20mA			1				(1) TSP #16	E	LOOP POWERED
F17, G9, J3	NOTE 1	I.VT.HP3.1	CONTROL JUNCTION BOX #1	MOTOR VIBRATION TRANSMITTERS (VT-HP3), SET 1	MOTOR VIBRATION TRANSMITTERS (VT-HP3)	4-20mA			1				(1) TSP #16	E	LOOP POWERED
F17, G9, J3	NOTE 1	I.VT.HP3.2	CONTROL JUNCTION BOX #1	MOTOR VIBRATION TRANSMITTERS (VT-HP3), SET 2	MOTOR VIBRATION TRANSMITTERS (VT-HP3)	4-20mA			1				(1) TSP #16	E	LOOP POWERED
HYDRANT PUMP TRAIN 4															
F18, G10, J4	F18	C.ME.HFS4	CONTROL JUNCTION BOX #1	MOISTURE SWITCH (ME-HFS4)	PWR / CNTRL TO MOISTURE SWITCH (ME-HFS4)	120VAC							4/C #14	B	
-	-	IS.ME.HFS4	MOISTURE SWITCH	MOISTURE SENSOR	MOISTURE SENSOR TO MOISTURE CONTROLLER	I.S.							VENDOR FURNISHED	-	
F18, G10, J4	F18	C.JY.HP4	CONTROL JUNCTION BOX #1	WATER SLUG VALVE SOLENOID (JY-HP4)	WATER SLUG VALVE SOLENOID (JY-HP4)	120VAC							3/C #14	B	
F18, G10, J4	F18	C.FSTS.HP4	CONTROL JUNCTION BOX #1	FLOW & TEMPERATURE SWITCHES (FSTS-HP4)	FLOW & TEMPERATURE SWITCHES (FSTS-HP4)	120VAC							7/C #14	B	
F14, G6, I6	F14	C.MWTS. HP4	CONTROL JUNCTION BOX #1	MOTOR WINDING TEMPERATURE SWITCH, HP-4	MOTOR WINDING TEMPERATURE SWITCH, HP-4	120VAC							2/C #14	B	
F30, G11, H1	F30	C.HS.HP4.1	CONTROL JUNCTION BOX #1	HAND STATION (HS-HP4)	RUN STOP CONTROL (IN HAND)	120VAC							3/C #14	B	
F30, G11, H1	F30	C.HS.HP4.2	CONTROL JUNCTION BOX #1	HAND STATION (HS-HP4)	FIELD RUN INDICATION LIGHT	24VDC							2/C #14	B	
F14, G6, I6	F14	C.HTR.HP4	CONTROL JUNCTION BOX #1	MOTOR HEATER, HP-4	MOTOR HEATER, HP-4	120VAC							3/C #14	B	
-	-	C.EFSO.HP4	VARIABLE FREQUENCY DRIVE, VFD-HP4	EFSSO PANEL	EFSSO INTERLOCK, HP-4	120VAC							2/C #14	B	
-	-	IC.FSC.VFD4	VARIABLE FREQUENCY DRIVE, VFD-HP4	FUEL SYSTEM CONTROL PNL (PLC-1)	VFD COMMUNICATIONS, HP-4	EOC					1		(1) CAT 6	C	
F17, G9, J3	NOTE 1	I.FE.HP4	CONTROL JUNCTION BOX #1	FLOW METER, HP-4	4-20MA SIGNAL (DEVICE LOOP POWERED)	4-20mA			1				(1) TSP #16	E	CONDITIONED DP METER - LOOP POWERED
F17, G9, J3	NOTE 1	I.DPT.HFS4	CONTROL JUNCTION BOX #1	DIFFERENTIAL PRESSURE XMTR (DPT-HFS4)	DIFFERENTIAL PRESSURE XMTR (DPT-HFS4)	4-20mA			1				(1) TSP #16	E	LOOP POWERED
-	-	C.FSC.HP4	VARIABLE FREQUENCY DRIVE, VFD-HP4	FUEL SYSTEM CONTROL PNL (PLC-1)	MOIST/FLOW/FUEL TEMP SWITCH, PLC RUN/STOP	120VAC	3	1					9/C #14	B	WITH 2 SPARE CONDUCTORS
F17, G9, J3	NOTE 1	I.TT.HP4	CONTROL JUNCTION BOX #1	MOTOR BEARING TEMPERATURE TRANSMITTER (TT-HP4)	MOTOR TEMPERATURE TRANSMITTER (TT-HP4)	4-20mA			1				(1) TSP #16	E	LOOP POWERED
F17, G9, J3	NOTE 1	I.VT.HP4.1	CONTROL JUNCTION BOX #1	MOTOR VIBRATION TRANSMITTERS (VT-HP4), SET 1	MOTOR VIBRATION TRANSMITTERS (VT-HP4)	4-20mA			1				(1) TSP #16	E	LOOP POWERED
F17, G9, J3	NOTE 1	I.VT.HP4.2	CONTROL JUNCTION BOX #1	MOTOR VIBRATION TRANSMITTERS (VT-HP4), SET 2	MOTOR VIBRATION TRANSMITTERS (VT-HP4)	4-20mA			1				(1) TSP #16	E	LOOP POWERED
HYDRANT PUMP TRAIN 5															
F18, G10, J4	F18	C.ME.HFS5	CONTROL JUNCTION BOX #1	MOISTURE SWITCH (ME-HFS5)	PWR / CNTRL TO MOISTURE SWITCH (ME-HFS5)	120VAC							4/C #14	B	
-	-	IS.ME.HFS5	MOISTURE SWITCH	MOISTURE SENSOR	MOISTURE SENSOR TO MOISTURE CONTROLLER	I.S.							VENDOR FURNISHED	-	
F18, G10, J4	F18	C.JY.HP5	CONTROL JUNCTION BOX #1	WATER SLUG VALVE SOLENOID (JY-HP5)	WATER SLUG VALVE SOLENOID (JY-HP5)	120VAC							3/C #14	B	
F18, G10, J4	F18	C.FSTS.HP5	CONTROL JUNCTION BOX #1	FLOW & TEMPERATURE SWITCHES (FSTS-HP5)	FLOW & TEMPERATURE SWITCHES (FSTS-HP5)	120VAC							7/C #14	B	
F23, G15, I10	F23	C.MWTS. HP5	CONTROL JUNCTION BOX #1	MOTOR WINDING TEMPERATURE SWITCH, HP-5	MOTOR WINDING TEMPERATURE SWITCH, HP-5	120VAC							2/C #14	B	
F30, G11, H1	F30	C.HS.HP5.1	CONTROL JUNCTION BOX #1	HAND STATION (HS-HP5)	RUN STOP CONTROL (IN HAND)	120VAC							3/C #14	B	
F30, G11, H1	F30	C.HS.HP5.2	CONTROL JUNCTION BOX #1	HAND STATION (HS-HP5)	FIELD RUN INDICATION LIGHT	24VDC							2/C #14	B	
F23, G15, I10	F23	C.HTR.HP5	CONTROL JUNCTION BOX #1	MOTOR HEATER, HP-5	MOTOR HEATER, HP-5	120VAC									

NOTES:

1. CIRCUIT FOUND WITHIN CIRCUITS I.FSC.CJB1.3 AND I.FSC.CJB1.4.

2. CIRCUIT FOUND WITHIN CIRCUITS C.FSC.CJB1.1 AND C.FSC.CJB1.2.

3. DIRECT BURIED TO GENERATOR.

4. DIRECT BURIED TO EXTERIOR LIGHT POLE.

12/20/2023

no.	date	by	ckd	description
A	12/21/23	TSR	BAW	ISSUED FOR PERMIT

Millimeters
Scale For Microfilming
Inches

			CONTROL CIRCUIT SCHEDULE													
DUCTBANK SECTION(S)	PDC STUB UP	CONTROL CIRCUIT SCHEDULE	FROM	TO	PURPOSE	SIGNAL	PLC I/O						CONDUCTORS		NOTES	
							DI	DO	AI	AO	PULSE	COMM	QUANTITY AND SIZE	TYPE		
GENERATOR/ATS 1&2																
C6	C6	C.ATS1.GEN	STANDBY GENERATOR	AUTOMATIC TRANSFER SWITCH, ATS-1	ATS-1 GENERATOR RUN COMMAND	24VDC							2/C #14	B		
C6	C6	C.ATS2.GEN	STANDBY GENERATOR	AUTOMATIC TRANSFER SWITCH, ATS-2	ATS-2 GENERATOR RUN COMMAND	24VDC							2/C #14	B		
-	-	C.FSC.ATS1	AUTOMATIC TRANSFER SWITCH, ATS-1	FUEL SYSTEM CONTROL PNL (PLC-1)	AUTOMATIC TRANSFER SWITCH, ATS-1	120VAC	1						2/C #14	B		
-	-	C.FSC.ATS2	AUTOMATIC TRANSFER SWITCH, ATS-2	FUEL SYSTEM CONTROL PNL (PLC-1)	AUTOMATIC TRANSFER SWITCH, ATS-2	120VAC	1						2/C #14	B		
-	-	I.C.FSC.ATS1	AUTOMATIC TRANSFER SWITCH, ATS-1	FUEL SYSTEM CONTROL PNL (PLC-1)	AUTOMATIC TRANSFER SWITCH, ATS-1	EOC					1		(1) CAT 6	C		
-	-	I.C.FSC.ATS2	AUTOMATIC TRANSFER SWITCH, ATS-2	FUEL SYSTEM CONTROL PNL (PLC-1)	AUTOMATIC TRANSFER SWITCH, ATS-2	EOC					1		(1) CAT 6	C		
C12, K2	C12	I.C.GEN.RGAP	STANDBY GENERATOR	REMOTE GENERATOR ALARM PANEL	REMOTE ALARM PANEL	EOC					1		2/C #18	F		
K2	K2	I.C.GEN.RGAP	STANDBY GENERATOR	REMOTE GENERATOR ALARM PANEL	REMOTE ALARM PANEL	EOC					1		2/C #18	F		
C6	C6	C.FSC.GEN	STANDBY GENERATOR	FUEL SYSTEM CONTROL PNL (PLC-1)	GENERATOR HARDWIRED CONTROL POINTS	120VAC	6						13/C #14	B		
		I.C.FSC.GEN	STANDBY GENERATOR	FUEL SYSTEM CONTROL PNL (PLC-1)	GENERATOR HARDWIRED CONTROL POINTS	EOC					1		(1) CAT 6	C		
C6, K3	C6	C.EPO.GEN	STANDBY GENERATOR	EMERGENCY POWER OFF (EPO)	GENERATOR EPO BUTTON IN OPS BLDG.	24VDC	-	-	-	-	-	-	2/C #14	B		
K3	K3	C.EPO.GEN	STANDBY GENERATOR	EMERGENCY POWER OFF (EPO)	GENERATOR EPO BUTTON IN OPS BLDG.	24VDC	-	-	-	-	-	-	2/C #14	B		
CONTROL JUNCTION BOX #1																
F16, G8, J2	F16	C.FSC.CJB1.1	CONTROL JUNCTION BOX #1	FUEL SYSTEM CONTROL PNL (PLC-1)	PLC DI/DO HOME RUN CABLE	120VAC							18PR, #14	B		
F16, G8, J2	F16	C.FSC.CJB1.2	CONTROL JUNCTION BOX #1	FUEL SYSTEM CONTROL PNL (PLC-1)	PLC DI/DO HOME RUN CABLE	120VAC							18PR, #14	B		
F17, G9, J3	F17	I.FSC.CJB1.3	CONTROL JUNCTION BOX #1	FUEL SYSTEM CONTROL PNL (PLC-1)	PLC AI/AO HOME RUN CABLE	4-20mA							(18) TSP #16	B		
MISCELLANEOUS EXISTING INSTRUMENTS AND SIGNALS																
F20, E4	F20	C.FSC.KM	FUEL SYSTEM CONTROL PNL (PLC-1)	KINDER MORGAN BUILDING	KINDER MORGAN READY TO RECEIVE	120VAC	0	1					2/C #14	B		
F20, E4	F20	C.FSC.SLTLSHH	FUEL SYSTEM CONTROL PNL (PLC-1)	SEWER LIFT STATION (PNL-16)	LIFT STATION LEVEL ALARM - LSHH	120VAC	1						2/C #14	B		
F20, E4	F20	C.FSC.SLTLA	FUEL SYSTEM CONTROL PNL (PLC-1)	SEWER LIFT STATION (PNL-16)	PUMP 16A/16B SEAL LEAK ALARM	120VAC	1 or 2						2/C #14	B		
F20, E4	F20	C.FSC.LABLSH	FUEL SYSTEM CONTROL PNL (PLC-1)	LAB SUMP (PNL-17)	LAB SUMP LSH/ALARM LIGHT	120VAC	1						2/C #14	B		
-	-	C.LC.PC	LIGHTING CONTACTOR	PHOTOCELL	PHOTOCELL	120VAC	-	-	-	-	-	-	2/C #14	B		
-	-	C.FSC.HORN	FUEL SYSTEM CONTROL PNL (PLC-1)	ALARM HORN	HORN SIGNAL FROM PLC	120VAC	-	1					2/C #14	B		
K1	K1	C.FACU.OPS	FIRE ALARM CONTROL UNIT (FACU)	OPERATIONS BUILDING (OPS)	FIRE ALARM SIGNALS	24VDC	-	-	-	-	-	-	N/A	N/A		
K1	K1	C.FACU.OPS	FIRE ALARM CONTROL UNIT (FACU)	NEW OPERATIONS BUILDING (OPS)	FIRE ALARM SIGNALS	24VDC	-	-	-	-	-	-	N/A	N/A	PROVIDED BY FIRE SUBCONTRACTOR (SPEC. 28 31 00)	
WASTE TANK / OFFSPEC TANK																
F20, E4	F20	C.LSH.500	WASTE TANK LEVEL SWITCH	FUEL SYSTEM CONTROL PNL (PLC-1)	WASTE TANK LEVEL SWITCH	120VAC	1						2/C #14	B		
F8, E2	F8	I.LT.WT	WASTE TANK LEVEL TRANSMITTER	FUEL SYSTEM CONTROL PNL (PLC-1)	WASTE TANK LEVEL READINGS	4-20mA			1				(1) TSP #16	E	LOOP POWERED	

	DI	DO	AI	AO	PULSE	COMM
PDC - PLC I/O TOTALS	78	46	42	0	0	38

CIRCUIT NUMBER KEY:	
P - POWER	
C - 120VAC CONTROL	
I - 24VDC/4-20mA/PULSE/INSTRUMENTATION	
IC - COMMUNICATION	
IS - INTRINSICALLY SAFE	
CABLE TYPE	DESCRIPTION
A	120V/208V/240V/480V SYSTEMS & BELOW: SINGLE CONDUCTOR POWER AND CONTROL - COPPER STRANDED WITH 600V RATING, UL LISTED, TYPE XHHW-2.
B	120V/208V/240V/480V SYSTEMS & BELOW: MULTI CONDUCTOR POWER AND CONTROL - COPPER STRANDED WITH 600V RATING, UL LISTED, TRAY CABLE (TC-ER), TYPE XHHW-2, PVC OVERALL JACKET, SUNLIGHT RESISTANT PER UL 1277.
C	ETHERNET OVER COPPER - 600V, 4 TWISTED PAIR, SHIELDED, CAT6 OR CAT 6A (AS IDENTIFIED) COMMUNICATION CABLE - COPPER, STRANDED, UNDERGROUND/BURIAL, WITH WATERBLOCK, SUNLIGHT RESISTANT, OIL RESISTANT, UL LISTED.
D	BELDEN 1337A OR EQUIVALENT, TC-ER
E	600V, TWISTED SHIELDED PAIR INSTRUMENTATION CABLE, TINNED COPPER CONDUCTORS, PVC JACKET, SUNLIGHT AND OIL RESISTANT, UL LISTED. BELDEN 9342 OR APPROVED EQUAL.
F	RS-485 - #18 TWISTED SHIELDED PAIR, TINNED COPPER CONDUCTORS, PVC JACKET, OVERALL SHIELD, SUNLIGHT AND OIL RESISTANT, UL LISTED
G	300V, TWISTED SHIELDED PAIR INSTRUMENTATION CABLE, TINNED COPPER CONDUCTORS, OVERALL SHIELD, SUNLIGHT AND OIL RESISTANT, DIRECT BURIAL, UL LISTED. BELDEN 88760
H	SINGLE MODE FIBER OPTIC CABLE - 09/125um, LOOSE TUBE, INDOOR/OUTDOOR, UNDERGROUND/BURIAL, BEND INSENSITIVE, WATER BLOCK, OIL RESISTANT, RODENT RESISTANT, POLYETHYLENE JACKET, SUITABLE FOR USE IN CABLE TRAY, UL LISTED.
NOT USED	

- NOTES:
- CIRCUIT FOUND WITHIN CIRCUITS I.FSC.CJB1.3 AND I.FSC.CJB1.4.
 - CIRCUIT FOUND WITHIN CIRCUITS C.FSC.CJB1.1 AND C.FSC.CJB1.2.
 - DIRECT BURIED TO GENERATOR.
 - DIRECT BURIED TO EXTERIOR LIGHT POLE.

12/20/2023

no.	date	by	ckd	description
A	12/21/23	TSR	BAW	ISSUED FOR PERMIT

ISSUED FOR PERMIT ONLY



9400 WARD PARKWAY
KANSAS CITY, MO 64114
816-333-9400
Burns & McDonnell Engineering Co, Inc.

date	04/24/2023	detailed	S. JESBERG
designed	T. RENSHAW	checked	B. WINTER


PDX FUEL COMPANY L.L.C

PORTLAND INTERNATIONAL AIRPORT
5000 NE MARINE DR.
PORTLAND, OREGON 97218

PDX FACILITY IMPROVEMENTS
CABLE SCHEDULE - 7

project	153929	contract	
drawing	E-709	rev.	A

file 153929E-709.dwg

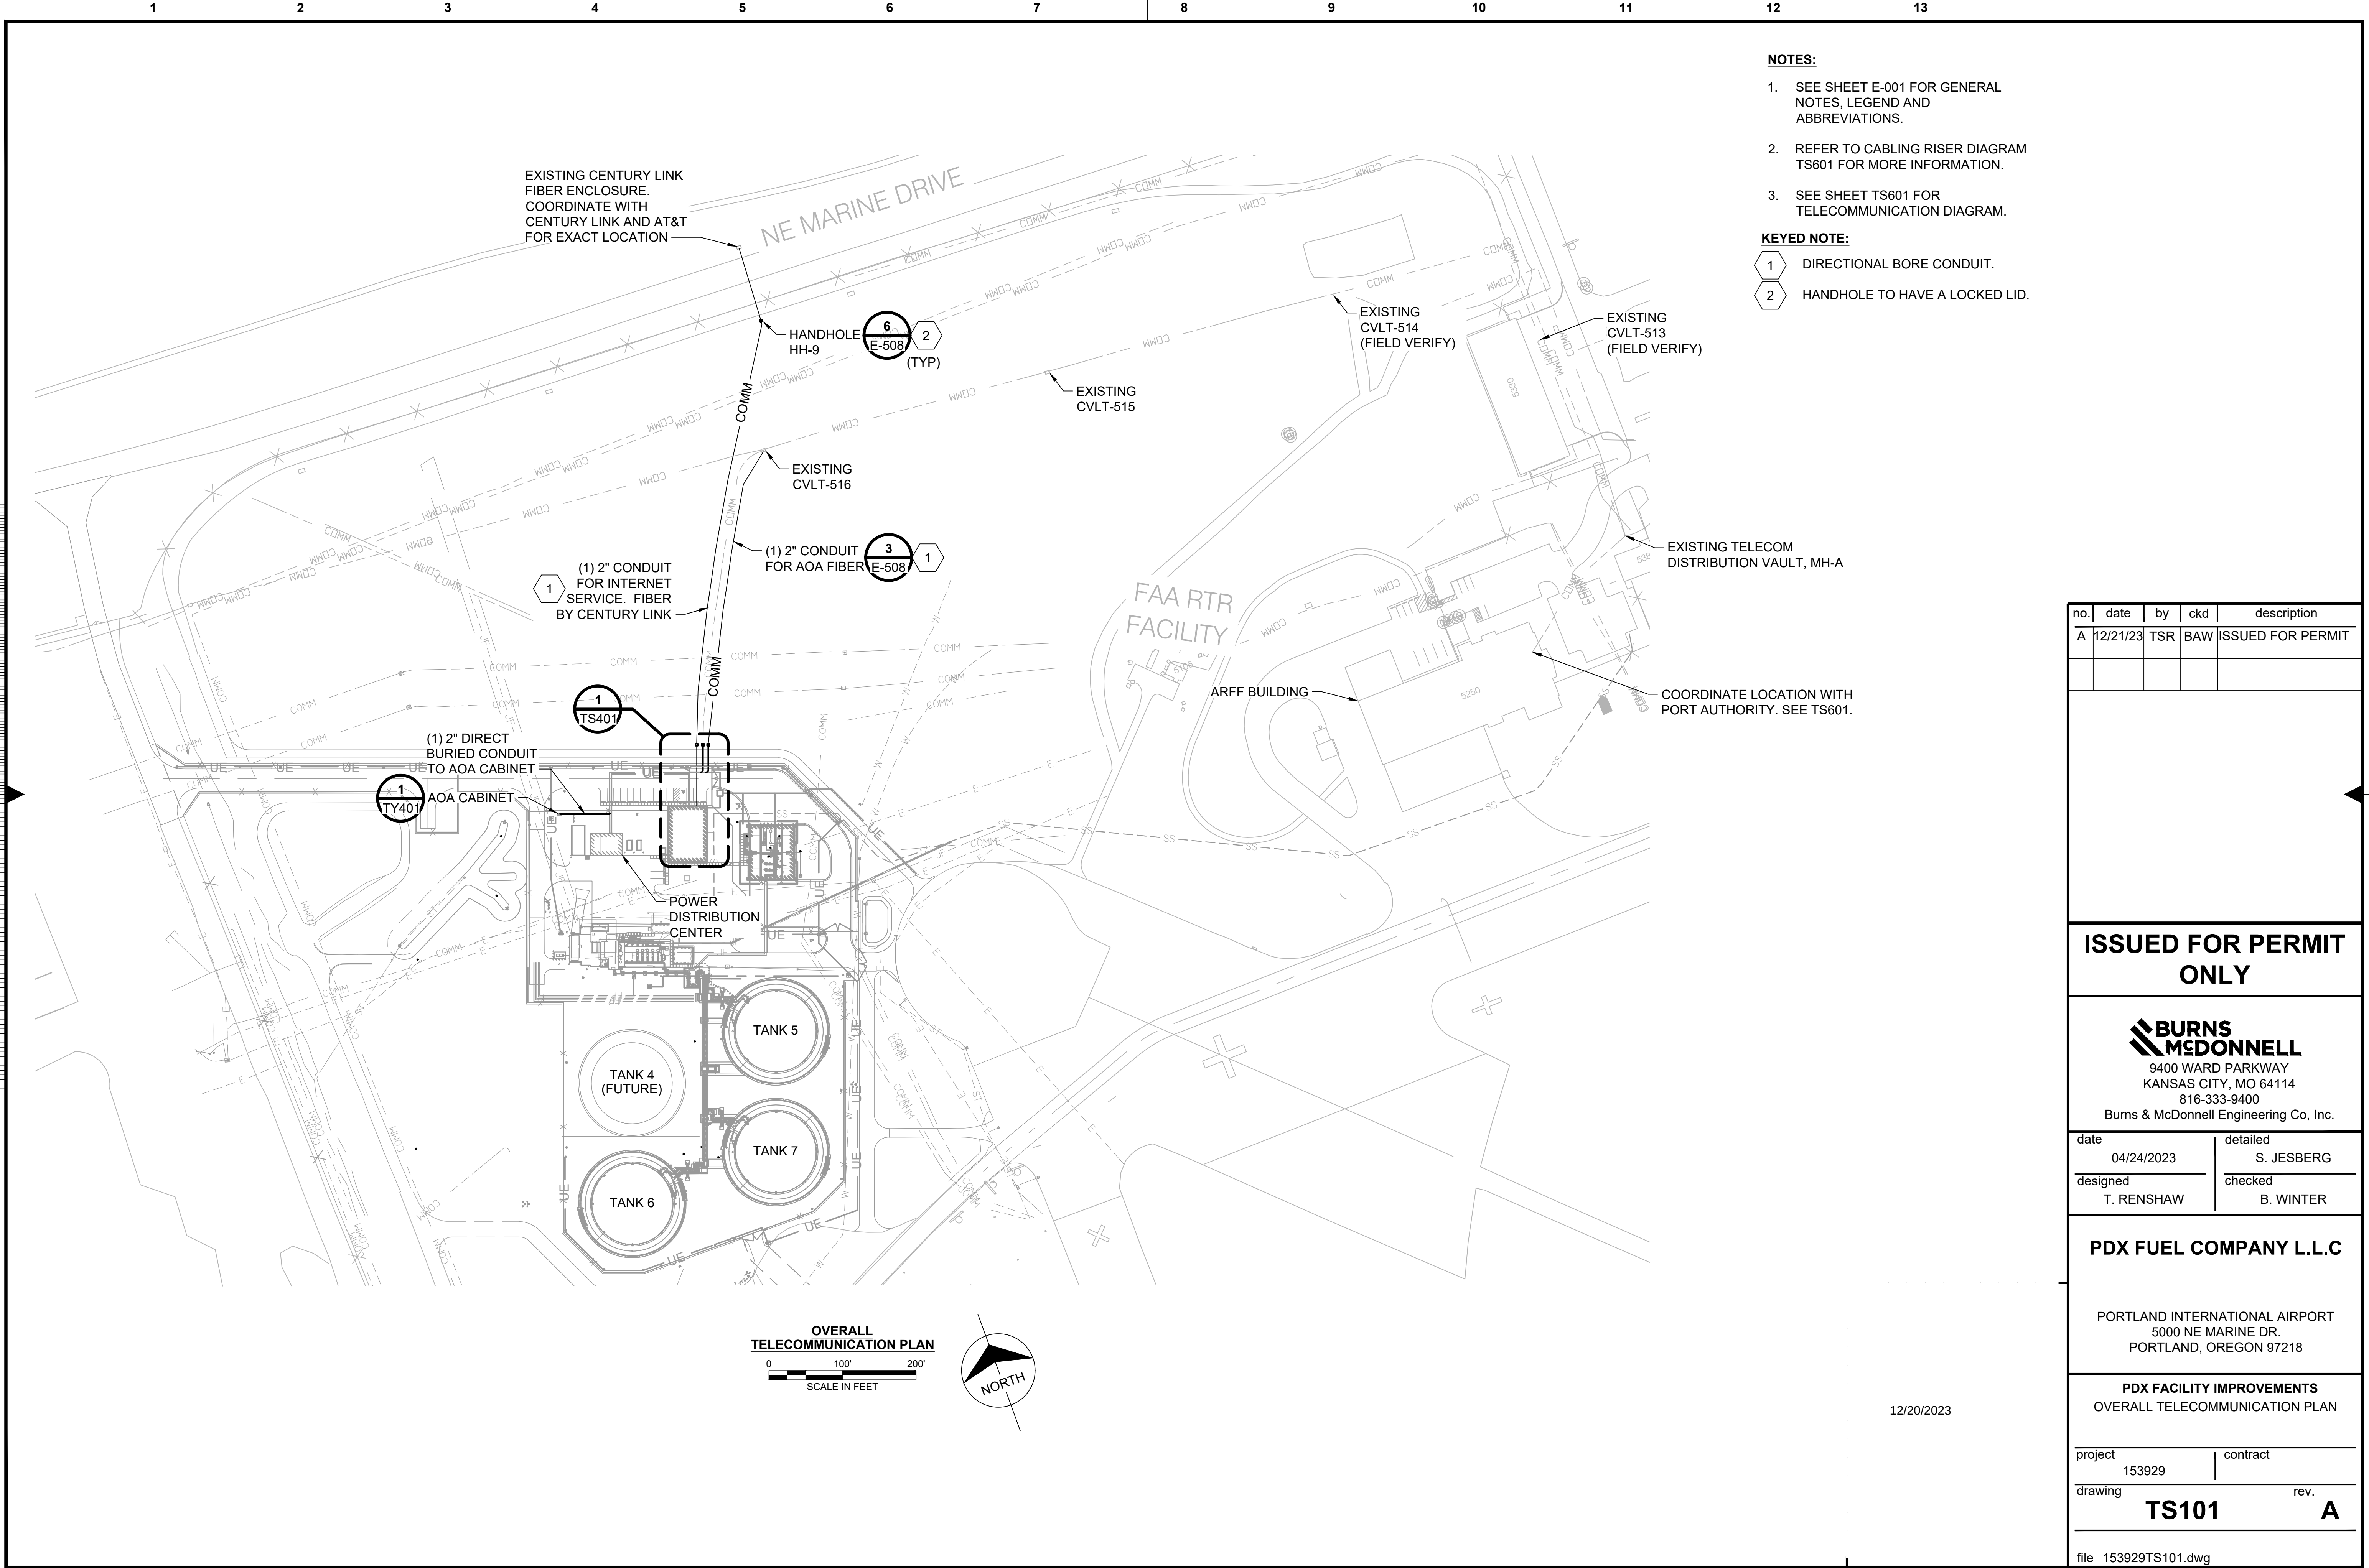

- NOTES:**
- 1. SEE SHEET E-001 FOR GENERAL NOTES, LEGEND AND ABBREVIATIONS.
 - 2. REFER TO CABLING RISER DIAGRAM TS601 FOR MORE INFORMATION.
 - 3. SEE SHEET TS601 FOR TELECOMMUNICATION DIAGRAM.
- KEYED NOTE:**
- 1 DIRECTIONAL BORE CONDUIT.
 - 2 HANDHOLE TO HAVE A LOCKED LID.

no.	date	by	ckd	description
A	12/21/23	TSR	BAW	ISSUED FOR PERMIT

ISSUED FOR PERMIT ONLY



9400 WARD PARKWAY
KANSAS CITY, MO 64114
816-333-9400
Burns & McDonnell Engineering Co., Inc.

date	04/24/2023	detailed	S. JESBERG
designed	T. RENSHAW	checked	B. WINTER


PDX FUEL COMPANY L.L.C

PORTLAND INTERNATIONAL AIRPORT
5000 NE MARINE DR.
PORTLAND, OREGON 97218


PDX FACILITY IMPROVEMENTS
OVERALL TELECOMMUNICATION PLAN

project	153929	contract	
drawing	TS101	rev.	A

file 153929TS101.dwg

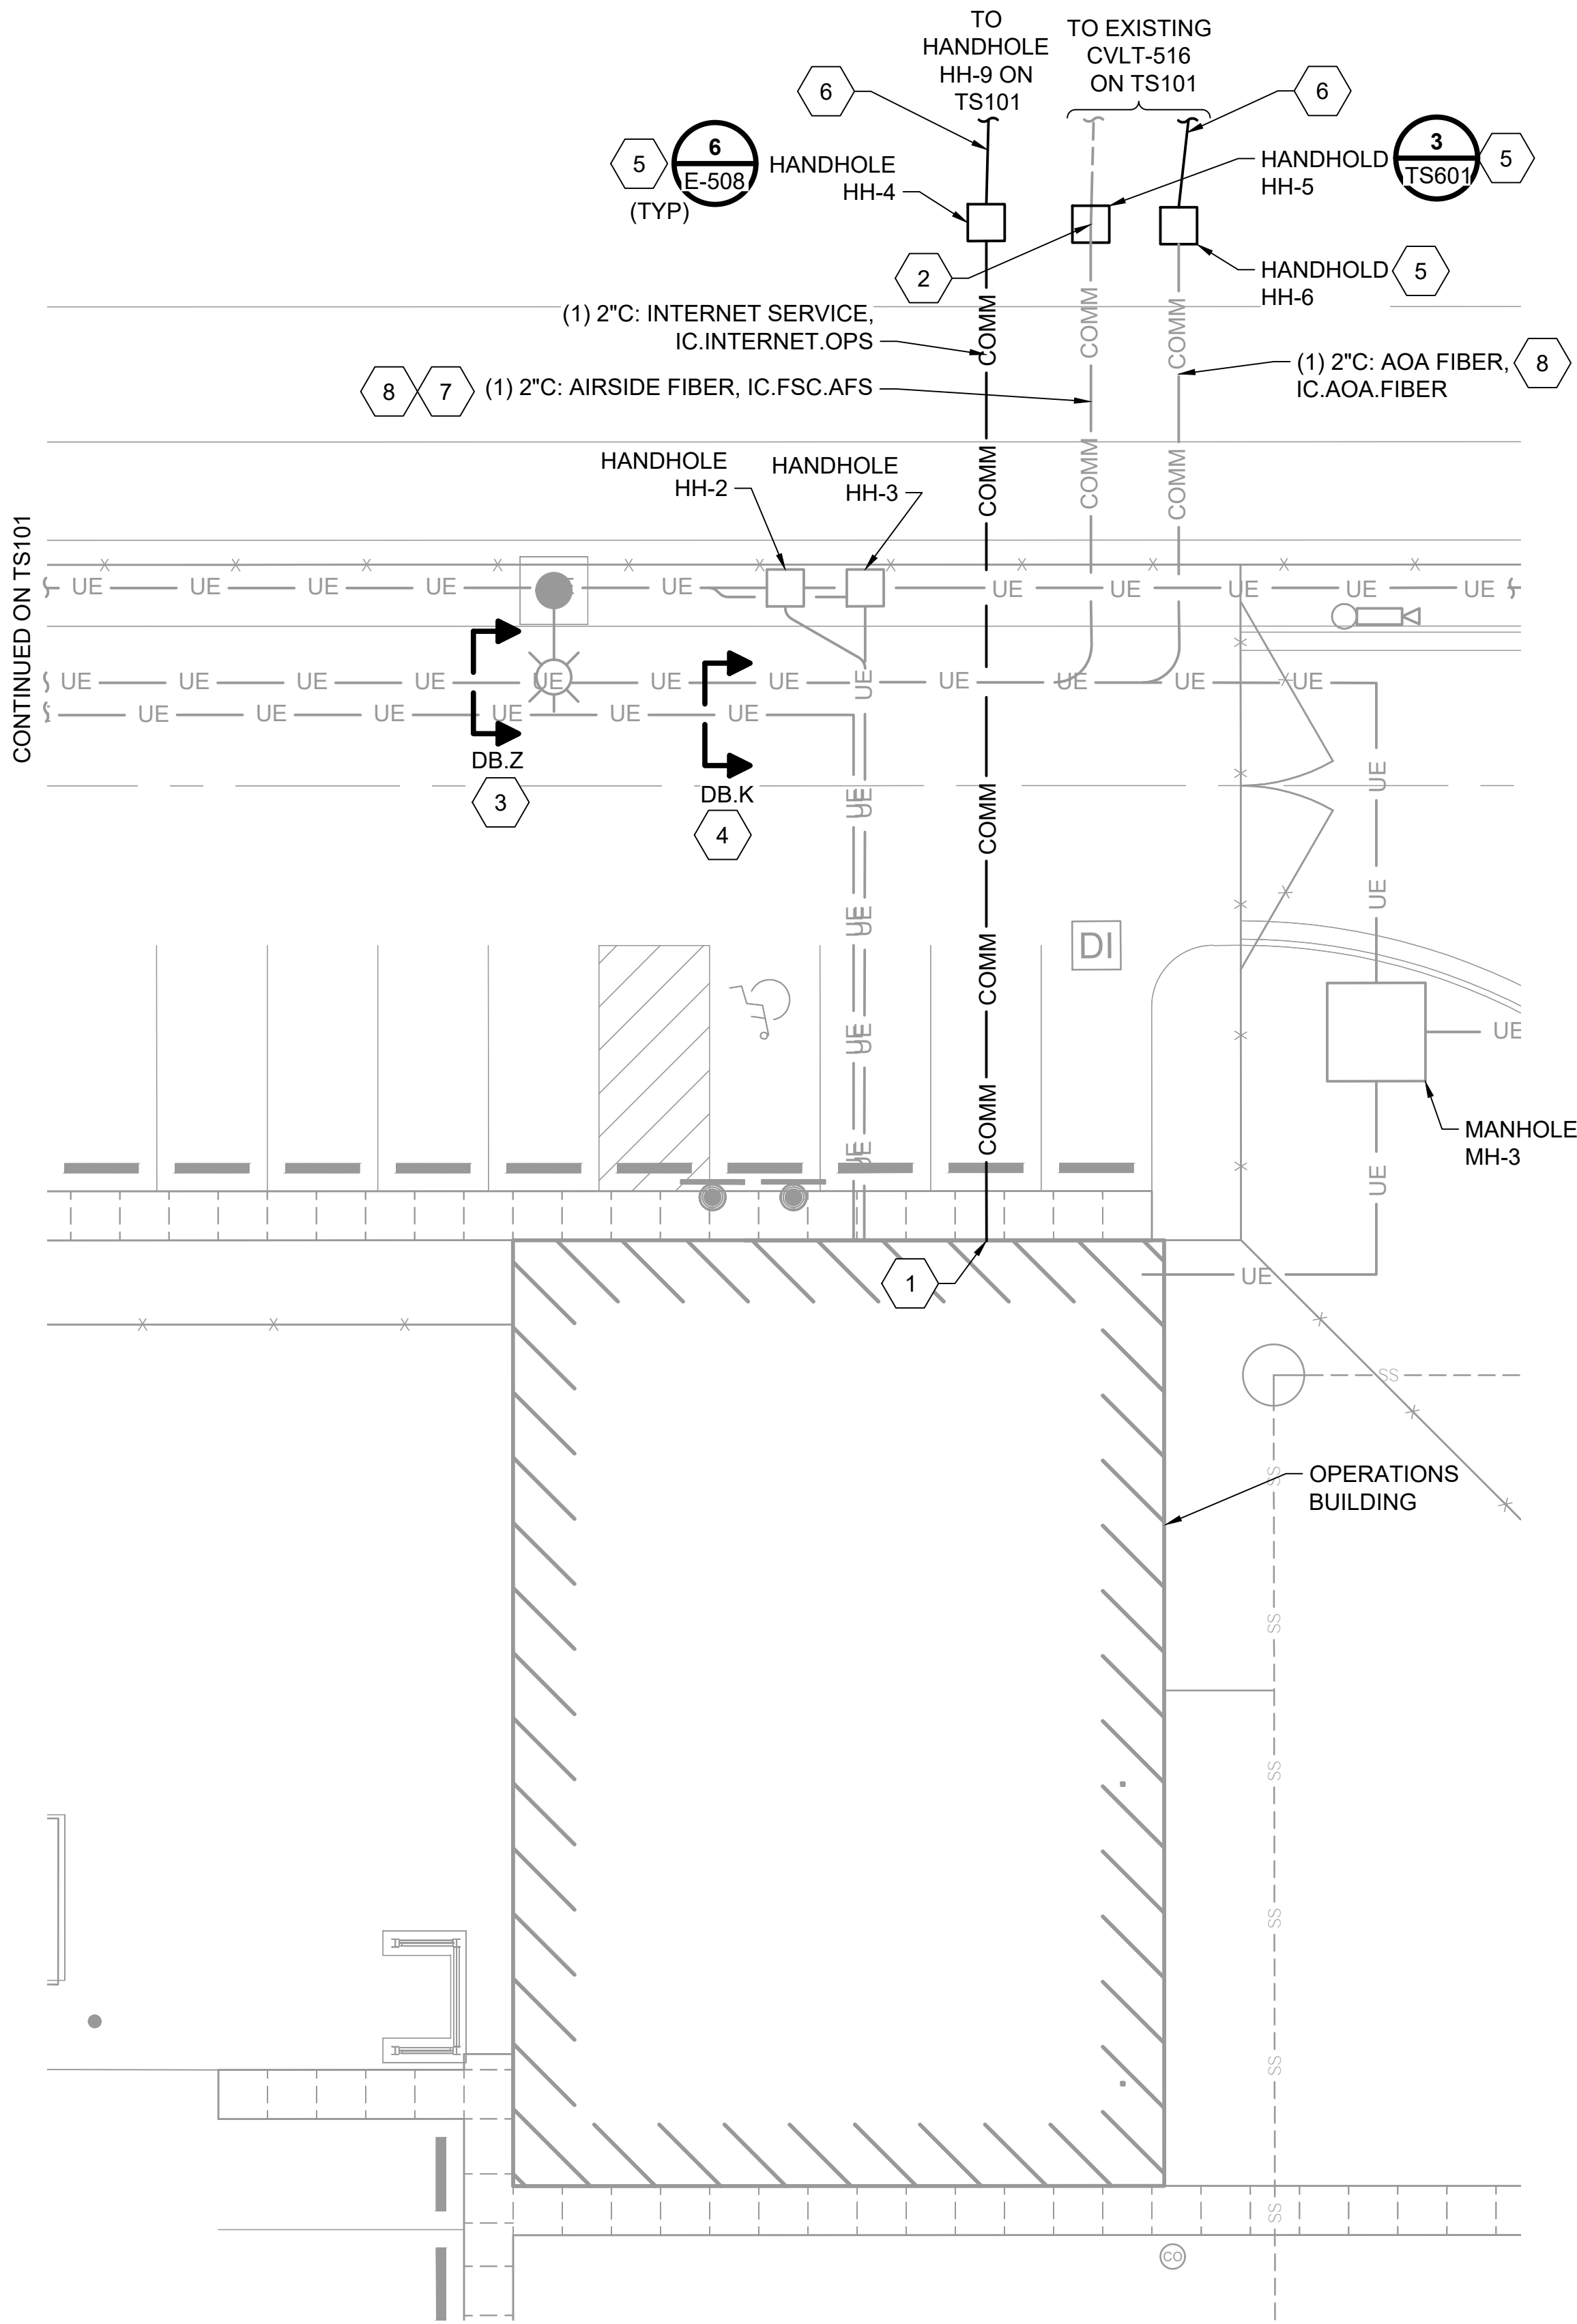

ENLARGED PLAN
ENLARGED TELECOMMUNICATION
PLAN - OPERATIONS BUILDING
0 8' 16' 24'
SCALE IN FEET

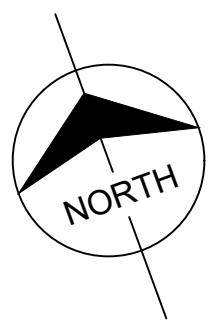

NOTES:

- SEE SHEET E-001 FOR GENERAL NOTES, LEGEND AND ABBREVIATIONS.
- SEE 'E' DRAWINGS FOR NEW DUCTBANK PATHS. NEW DUCTBANK PATHS ARE SCREENED BACK ON 'TS' DRAWINGS FOR CLARITY.
- THE FOLLOWING EQUIPMENT IS TO BE LOCATED WITHIN THE CORRESPONDING ROOMS:

- ROOM 111: CONTROL ROOM
- INTERCOM MASTER / SECURITY CAMERA MONITORS
 - REPORT/ALARM PRINTER
 - EFSO SYSTEM HMI WORKSTATION
 - FUEL SYSTEM HMI WORKSTATION
 - GENERATOR REMOTE ALARM PANEL
 - UPS SYSTEM
 - EFSO PUSHBUTTON
 - GENERATOR EPO BUTTON

- ROOM 106: IT ROOM
- ACCES CONTROL CENTER
 - INTERNET GATEWAY

KEYED NOTE:

- FIBER OPTIC CABLING SHALL BE ROUTED TO OPERATIONS BUILDING IT ROOM. COORDINATE WITH JH KELLY FOR FINAL LOCATION AND ROUTING.
- INTERCEPT EXISTING AIRSIDE FIBER WITH STAINLESS STEEL SPLICE CASE FOR BURIAL AND SUBMERGED APPLICATIONS. OUTDOOR RATED.
- DUCTBANK SERVES THE FOLLOWING:
 - A. AOA FIBER TO AOA CABINET
 - B. IC.AOA.FIBER AIRSIDE EFSO FIBER TO PDC, IC.FSC.AFS
- DUCTBANK SERVES THE FOLLOWING:
 - A. CONTAINS: INTERNET DROP TO PDX, IC.INTERNET.PDC
- HANDHOLE TO HAVE A LOCKED LID.
- DIRECTIONAL BORE CONDUIT.
- DEMOLISH AND REMOVE "COMM" CONDUIT BACK TO HH-5.
- DUCTBANK BY OTHERS

no.	date	by	ckd	description
A	12/21/23	TSR	BAW	ISSUED FOR PERMIT

ISSUED FOR PERMIT
ONLY



9400 WARD PARKWAY
KANSAS CITY, MO 64114
816-333-9400
Burns & McDonnell Engineering Co, Inc.

date	04/24/2023	detailed	S. JESBERG
designed	T. RENSHAW	checked	B. WINTER




PDX FUEL COMPANY L.L.C

PORTLAND INTERNATIONAL AIRPORT
5000 NE MARINE DR.
PORTLAND, OREGON 97218

PDX FACILITY IMPROVEMENTS
ENLARGED TELECOMMUNICATION PLAN -
OPERATIONS BUILDING

project	153929	contract	
drawing	TS401	rev.	A

file 153929TS401.dwg

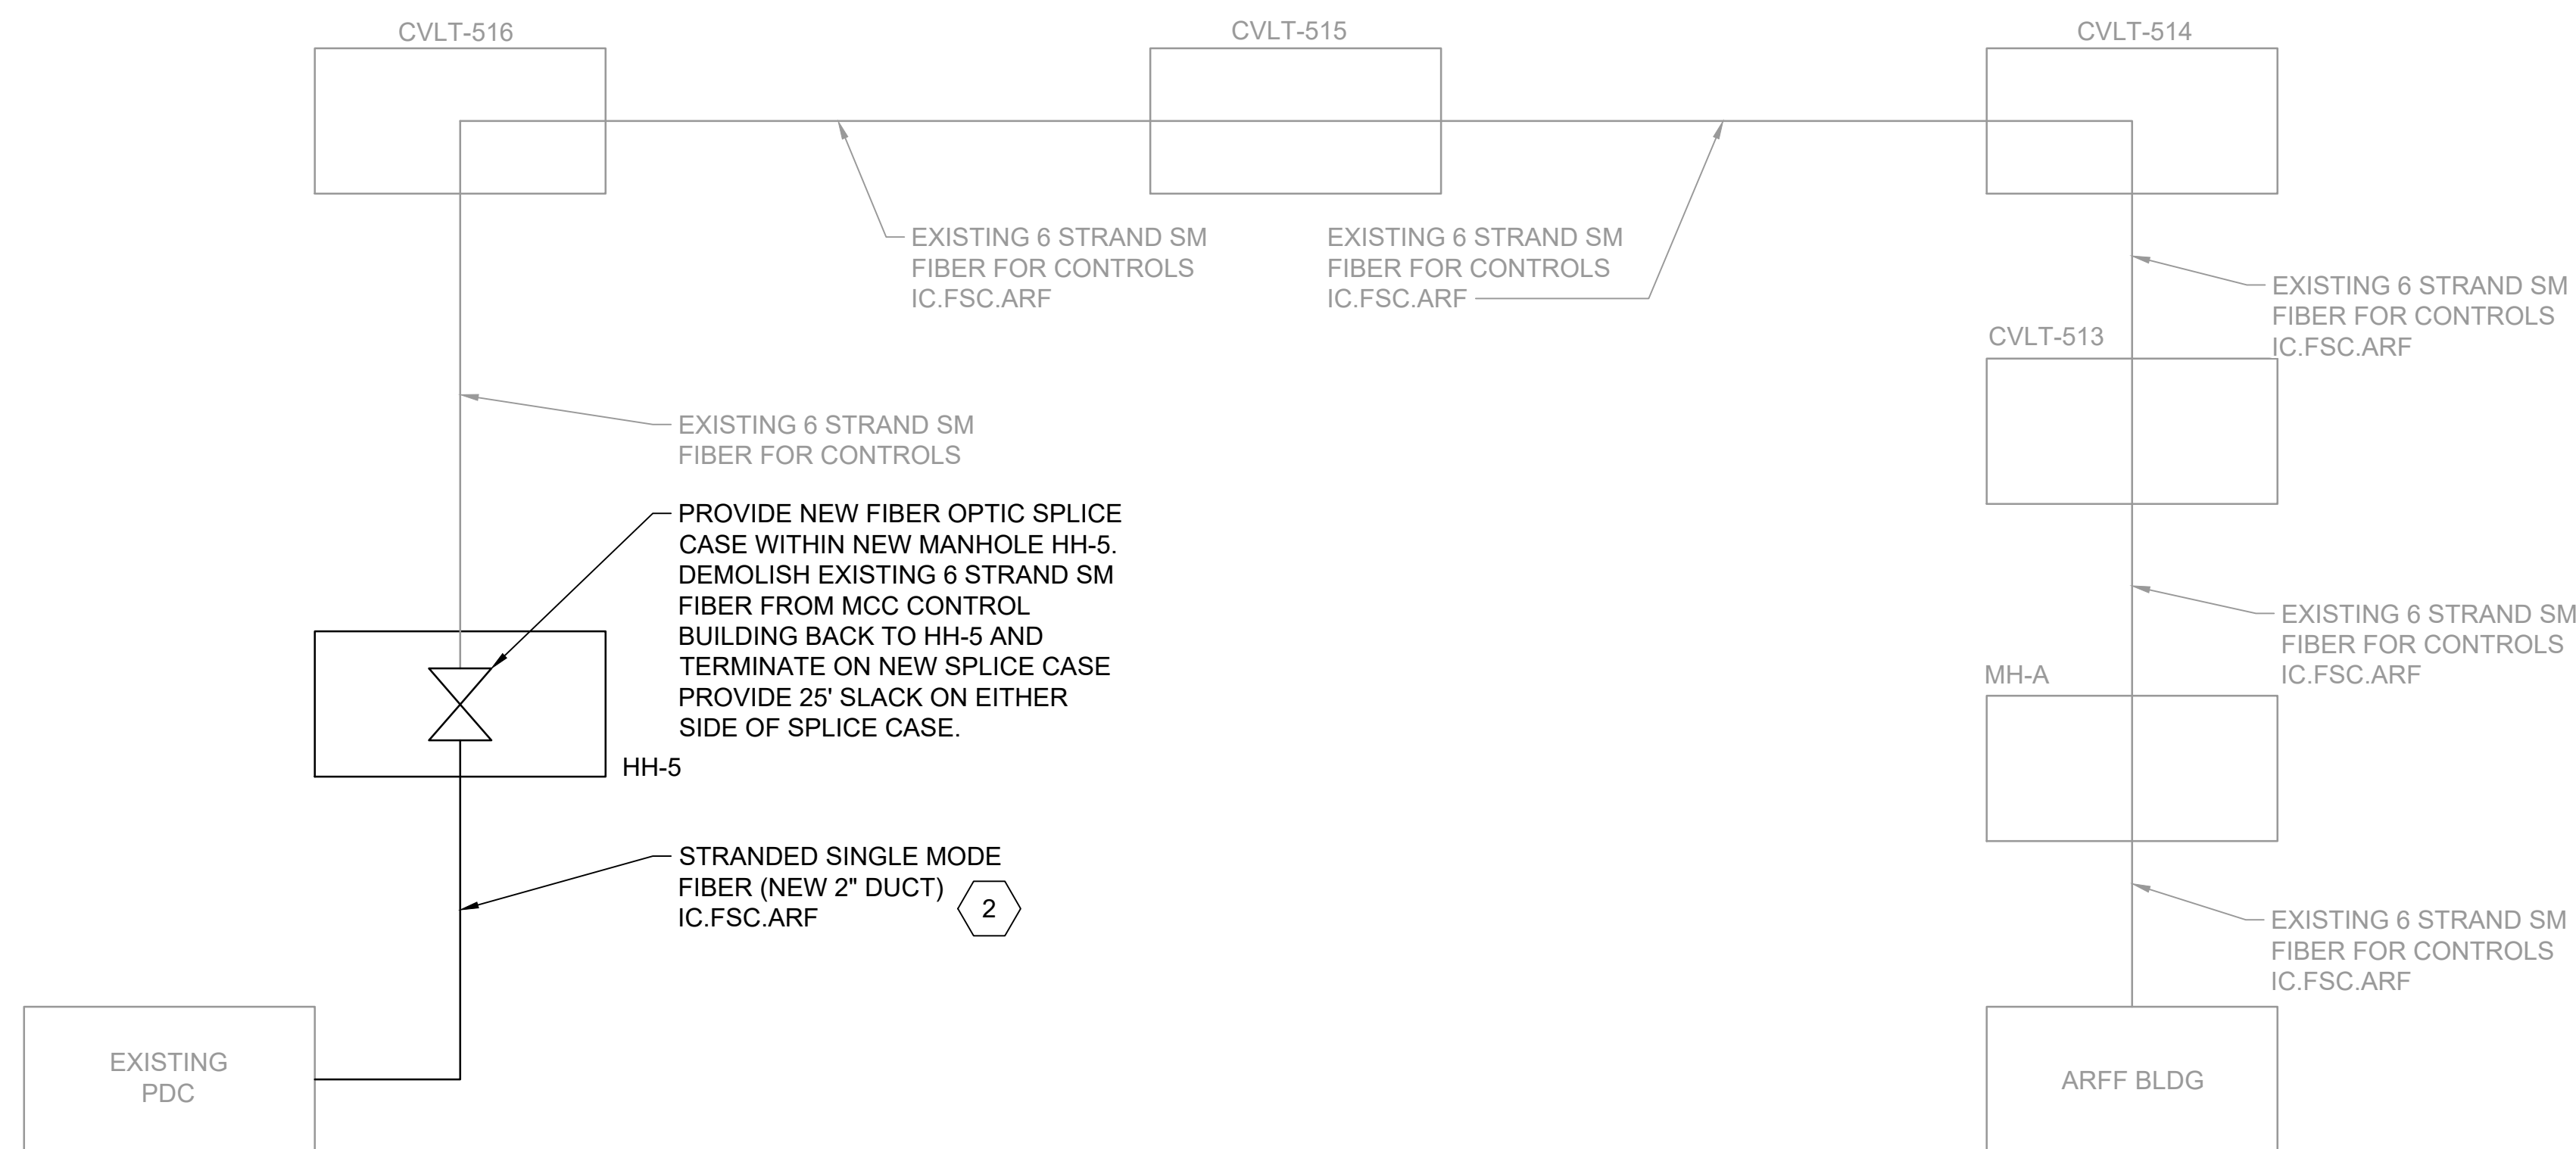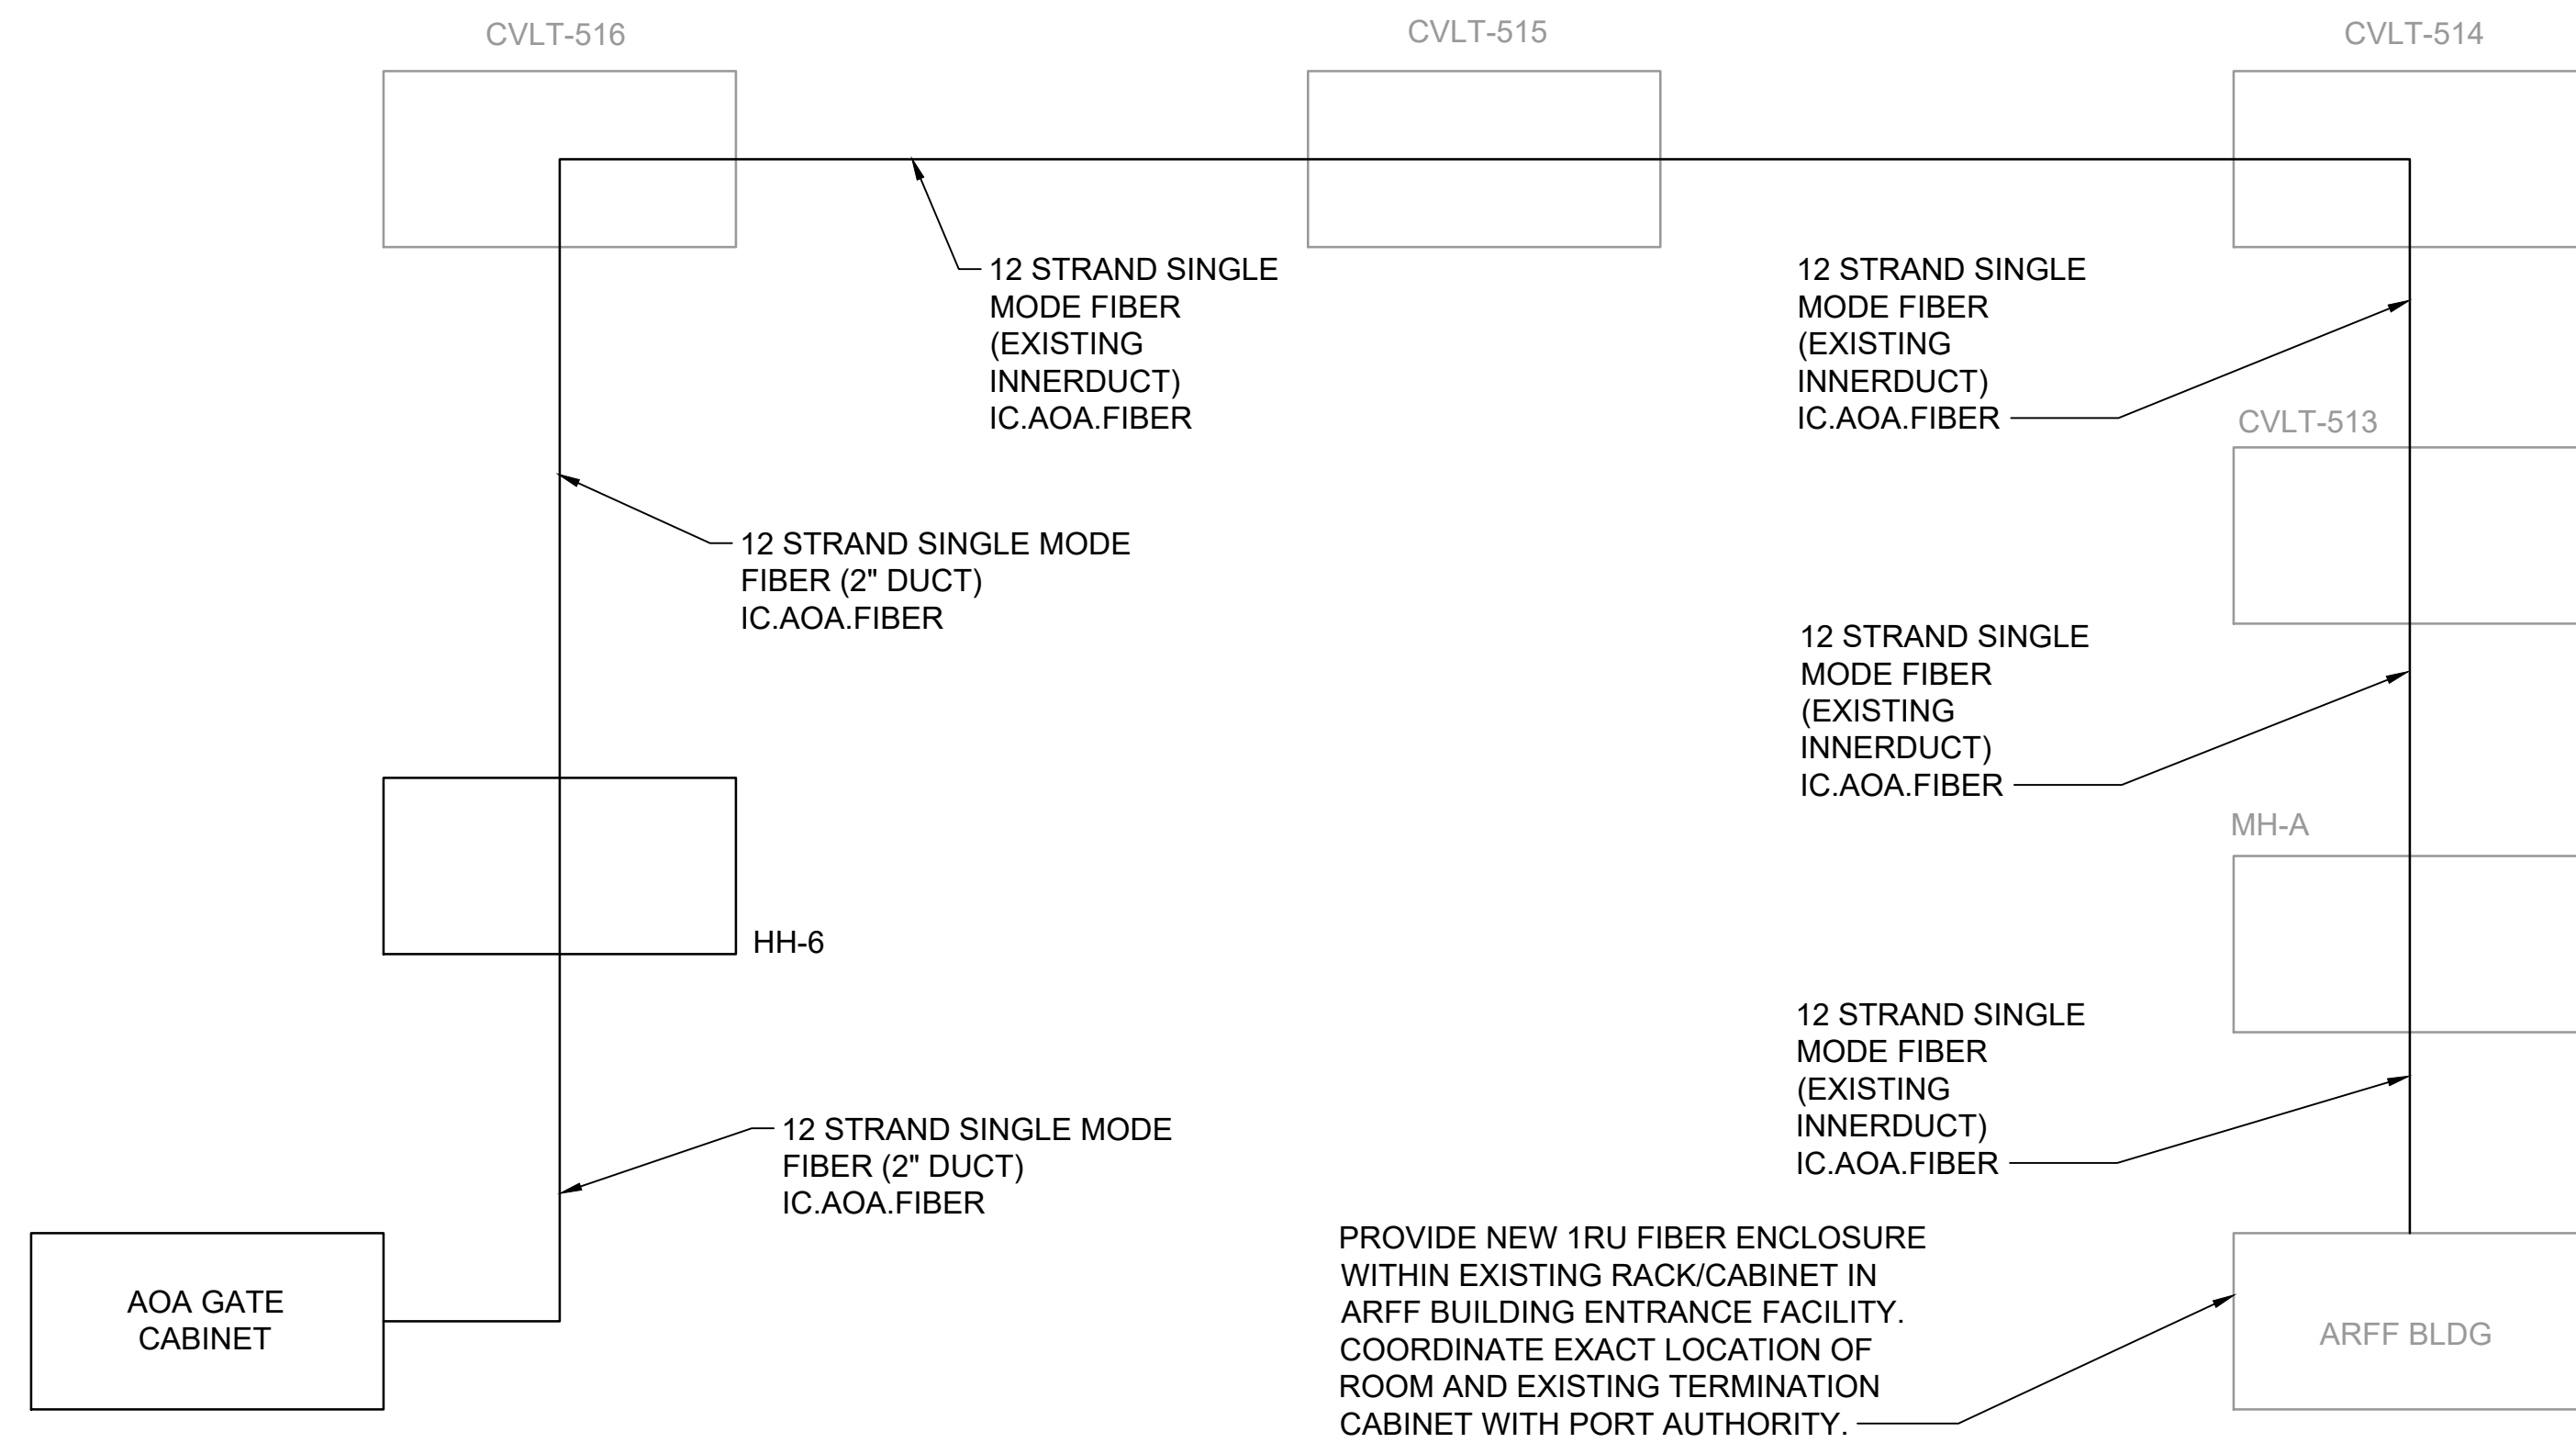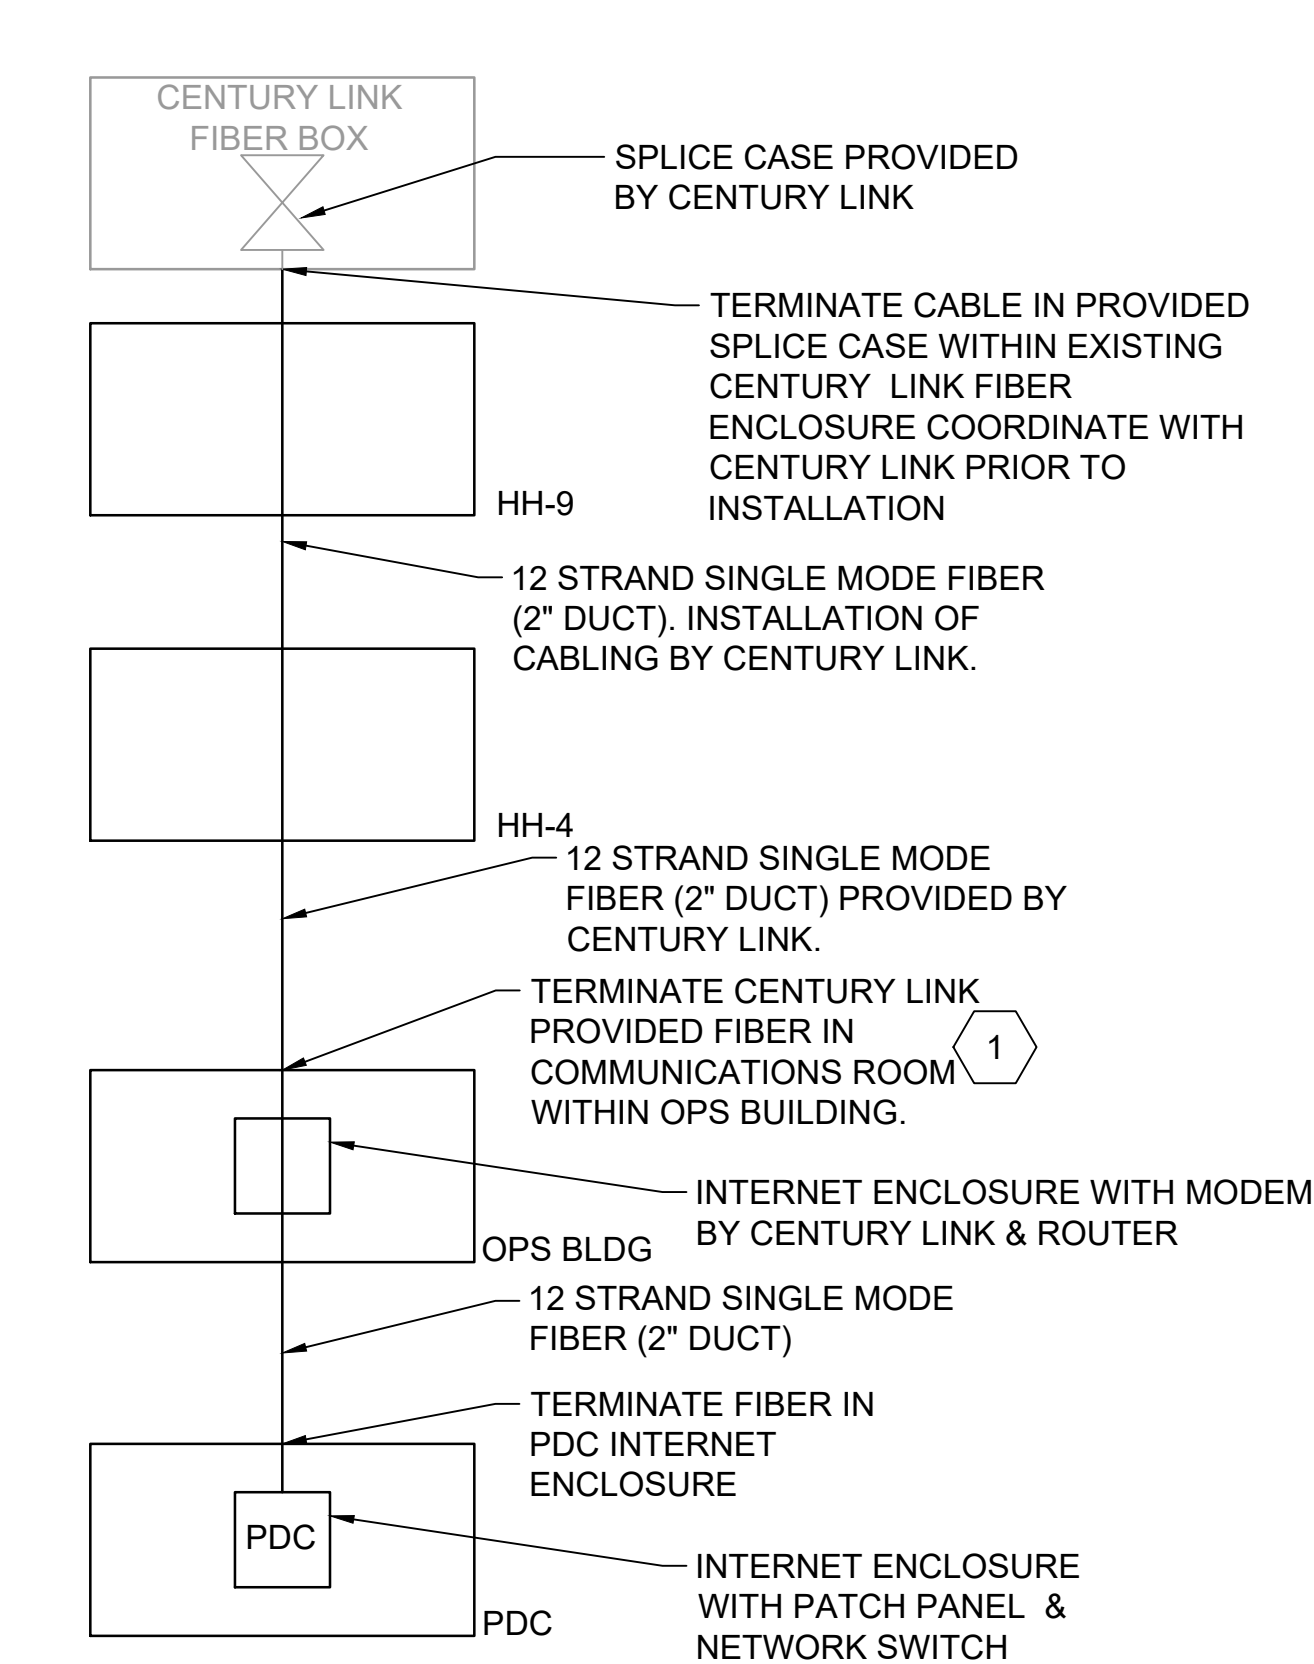

- NOTES:**

1. SEE SHEET E-001 FOR GENERAL NOTES, LEGEND AND ABBREVIATIONS.
2. ADD FABRIC (1) 2" 3-CELL MESH INNERDUCT TO NEW PATHWAYS.
3. PROVIDE 25' OF SLACK (TYP) FOR EACH MANHOLE OR HANDHOLE.
4. TERMINATE FIBER ON DUPLEX LC MODULES

KEYED NOTE:

- 1 FIBER OPTIC CABLING SHALL BE ROUTED TO OPERATIONS BUILDING IT ROOM. COORDINATE WITH JH KELLY FOR FINAL TERMINATION AND ROUTING.
- 2 MATCH STRAND COUNT OF EXISTING FIBER

no.	date	by	ckd	description
A	12/21/23	TSR	BAW	ISSUED FOR PERMIT

**ISSUED FOR PERMIT
ONLY**



9400 WARD PARKWAY
KANSAS CITY, MO 64114
816-333-9400
Burns & McDonnell Engineering Co., Inc.

date 04/24/2023	detailed S. JESBERG
designed T. RENSHAW	checked B. WINTER

PDX FUEL COMPANY L.L.C


PORTLAND INTERNATIONAL AIRPORT
5000 NE MARINE DR.
PORTLAND, OREGON 97218


PDX FACILITY IMPROVEMENTS

TELECOMMUNICATION DIAGRAM

project	contract
153929	
drawing	rev.

file 153929TS601.dwg

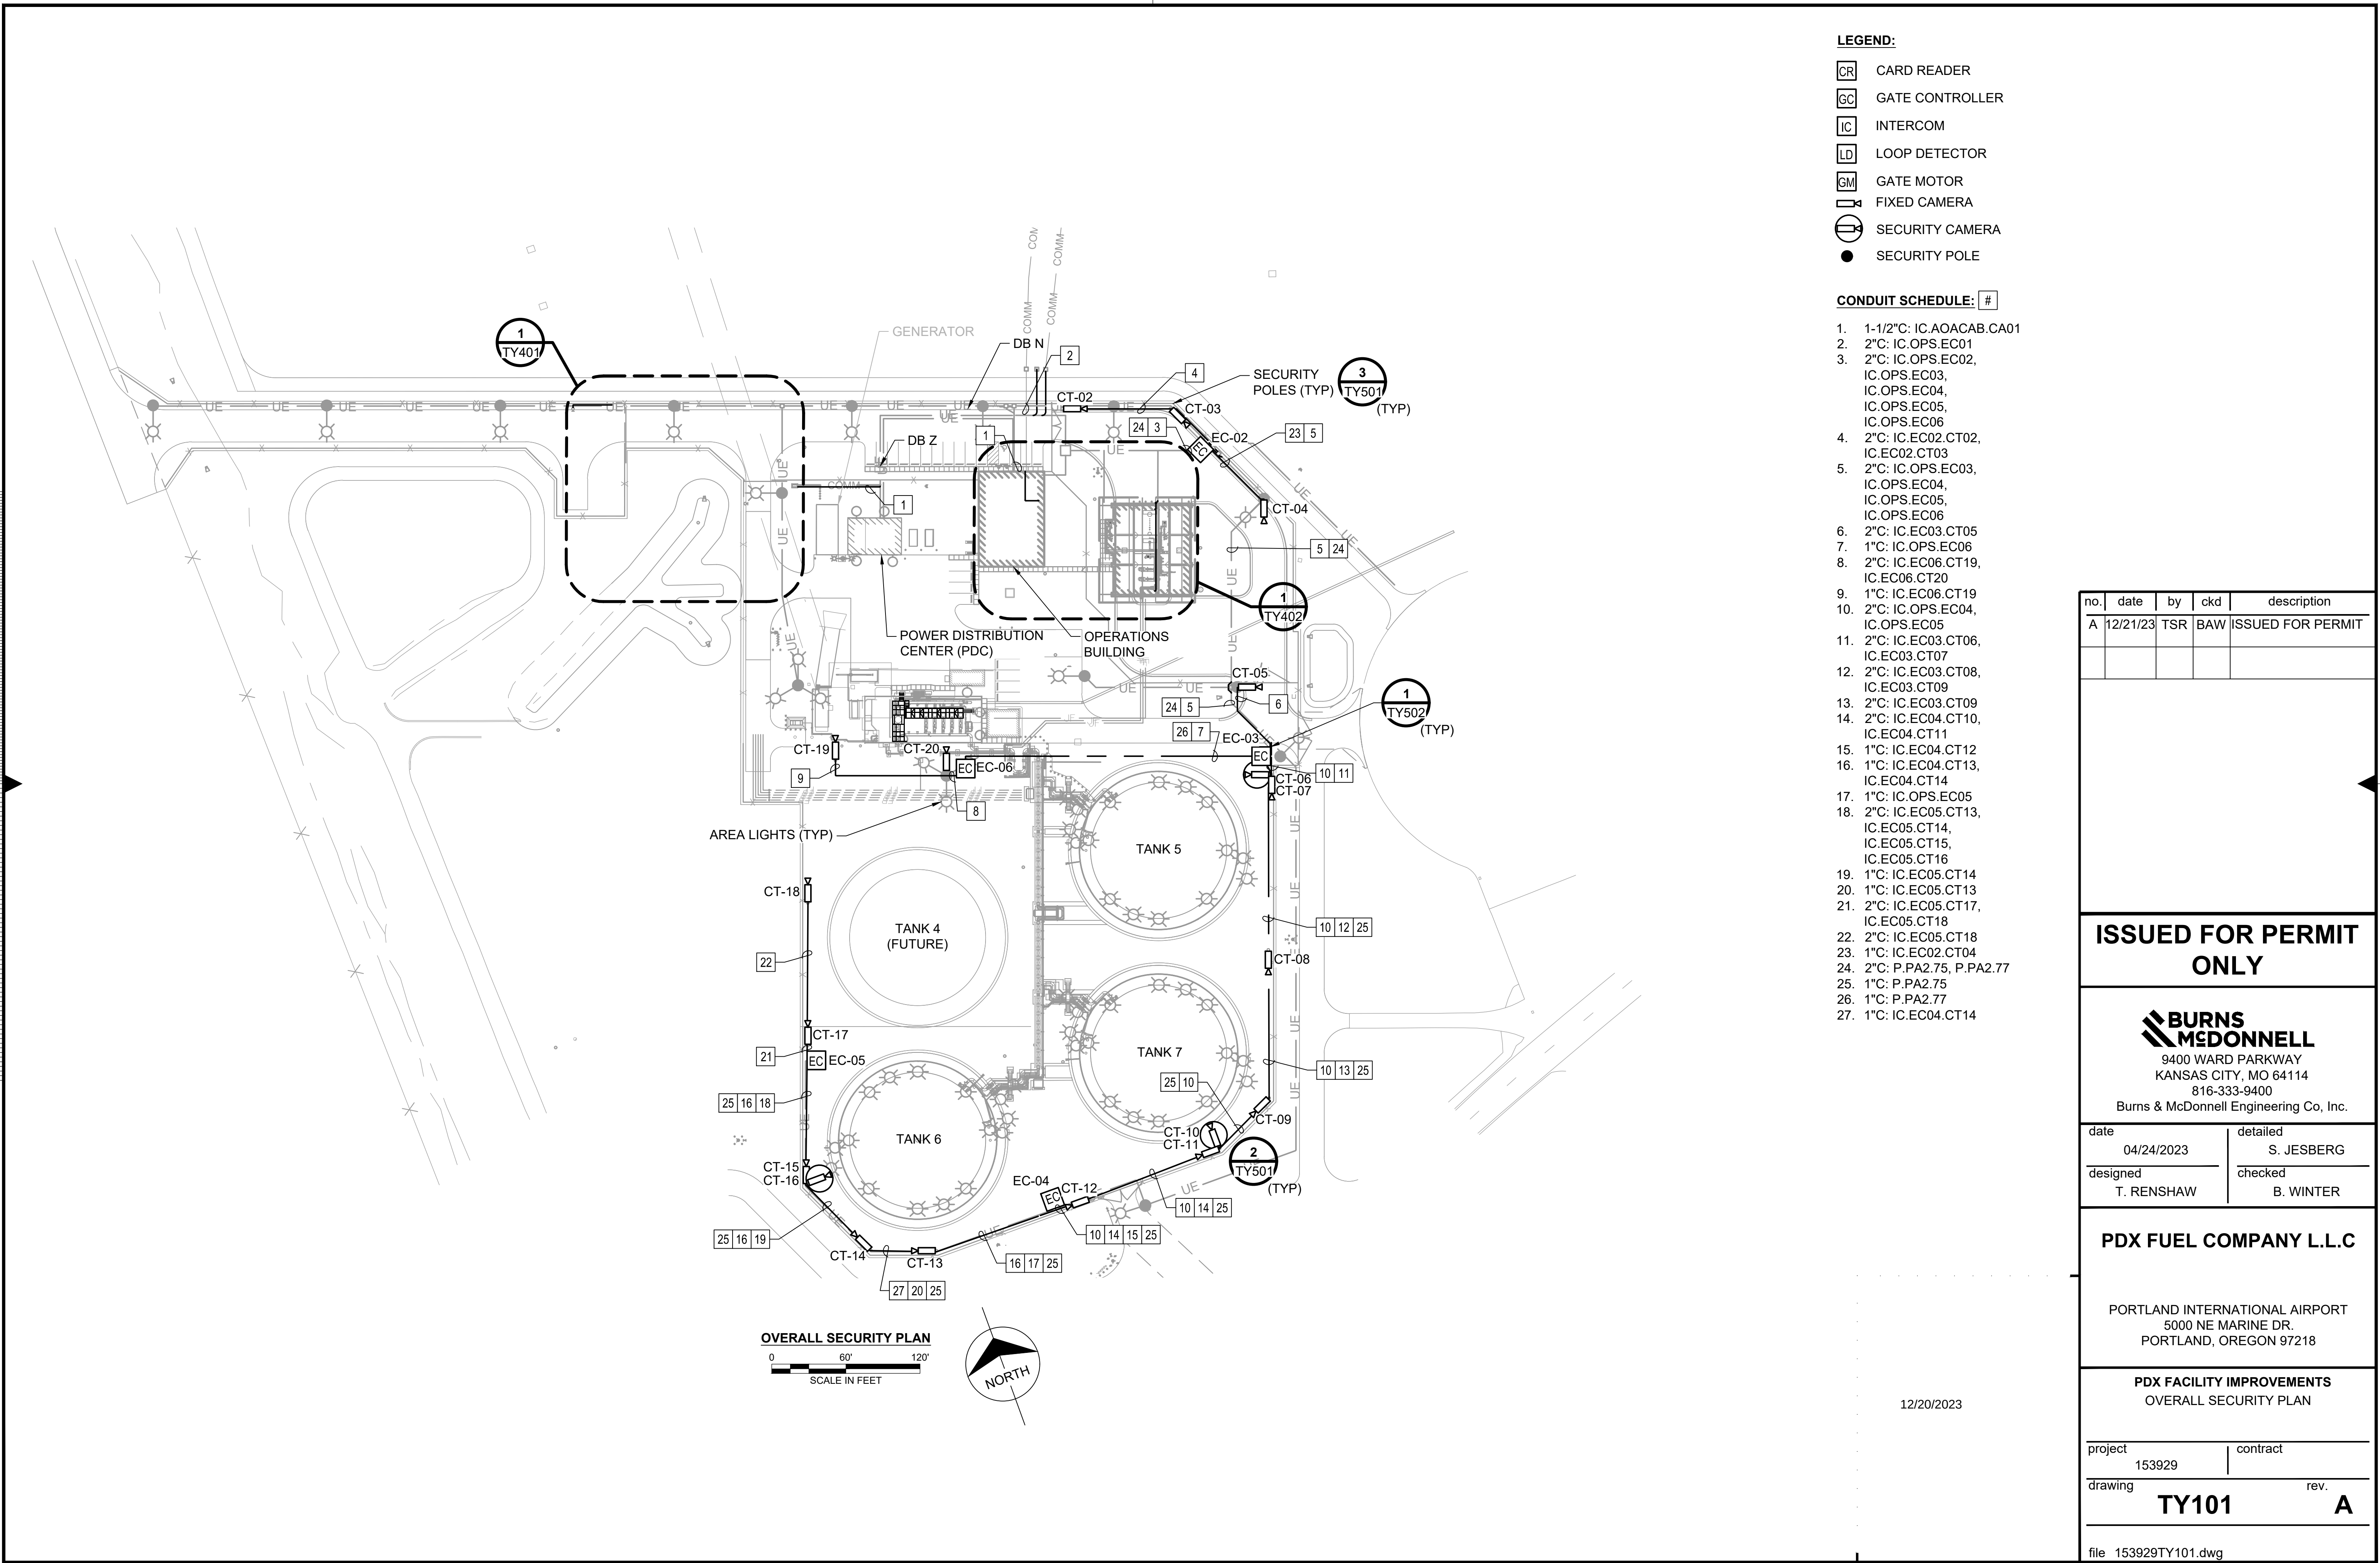

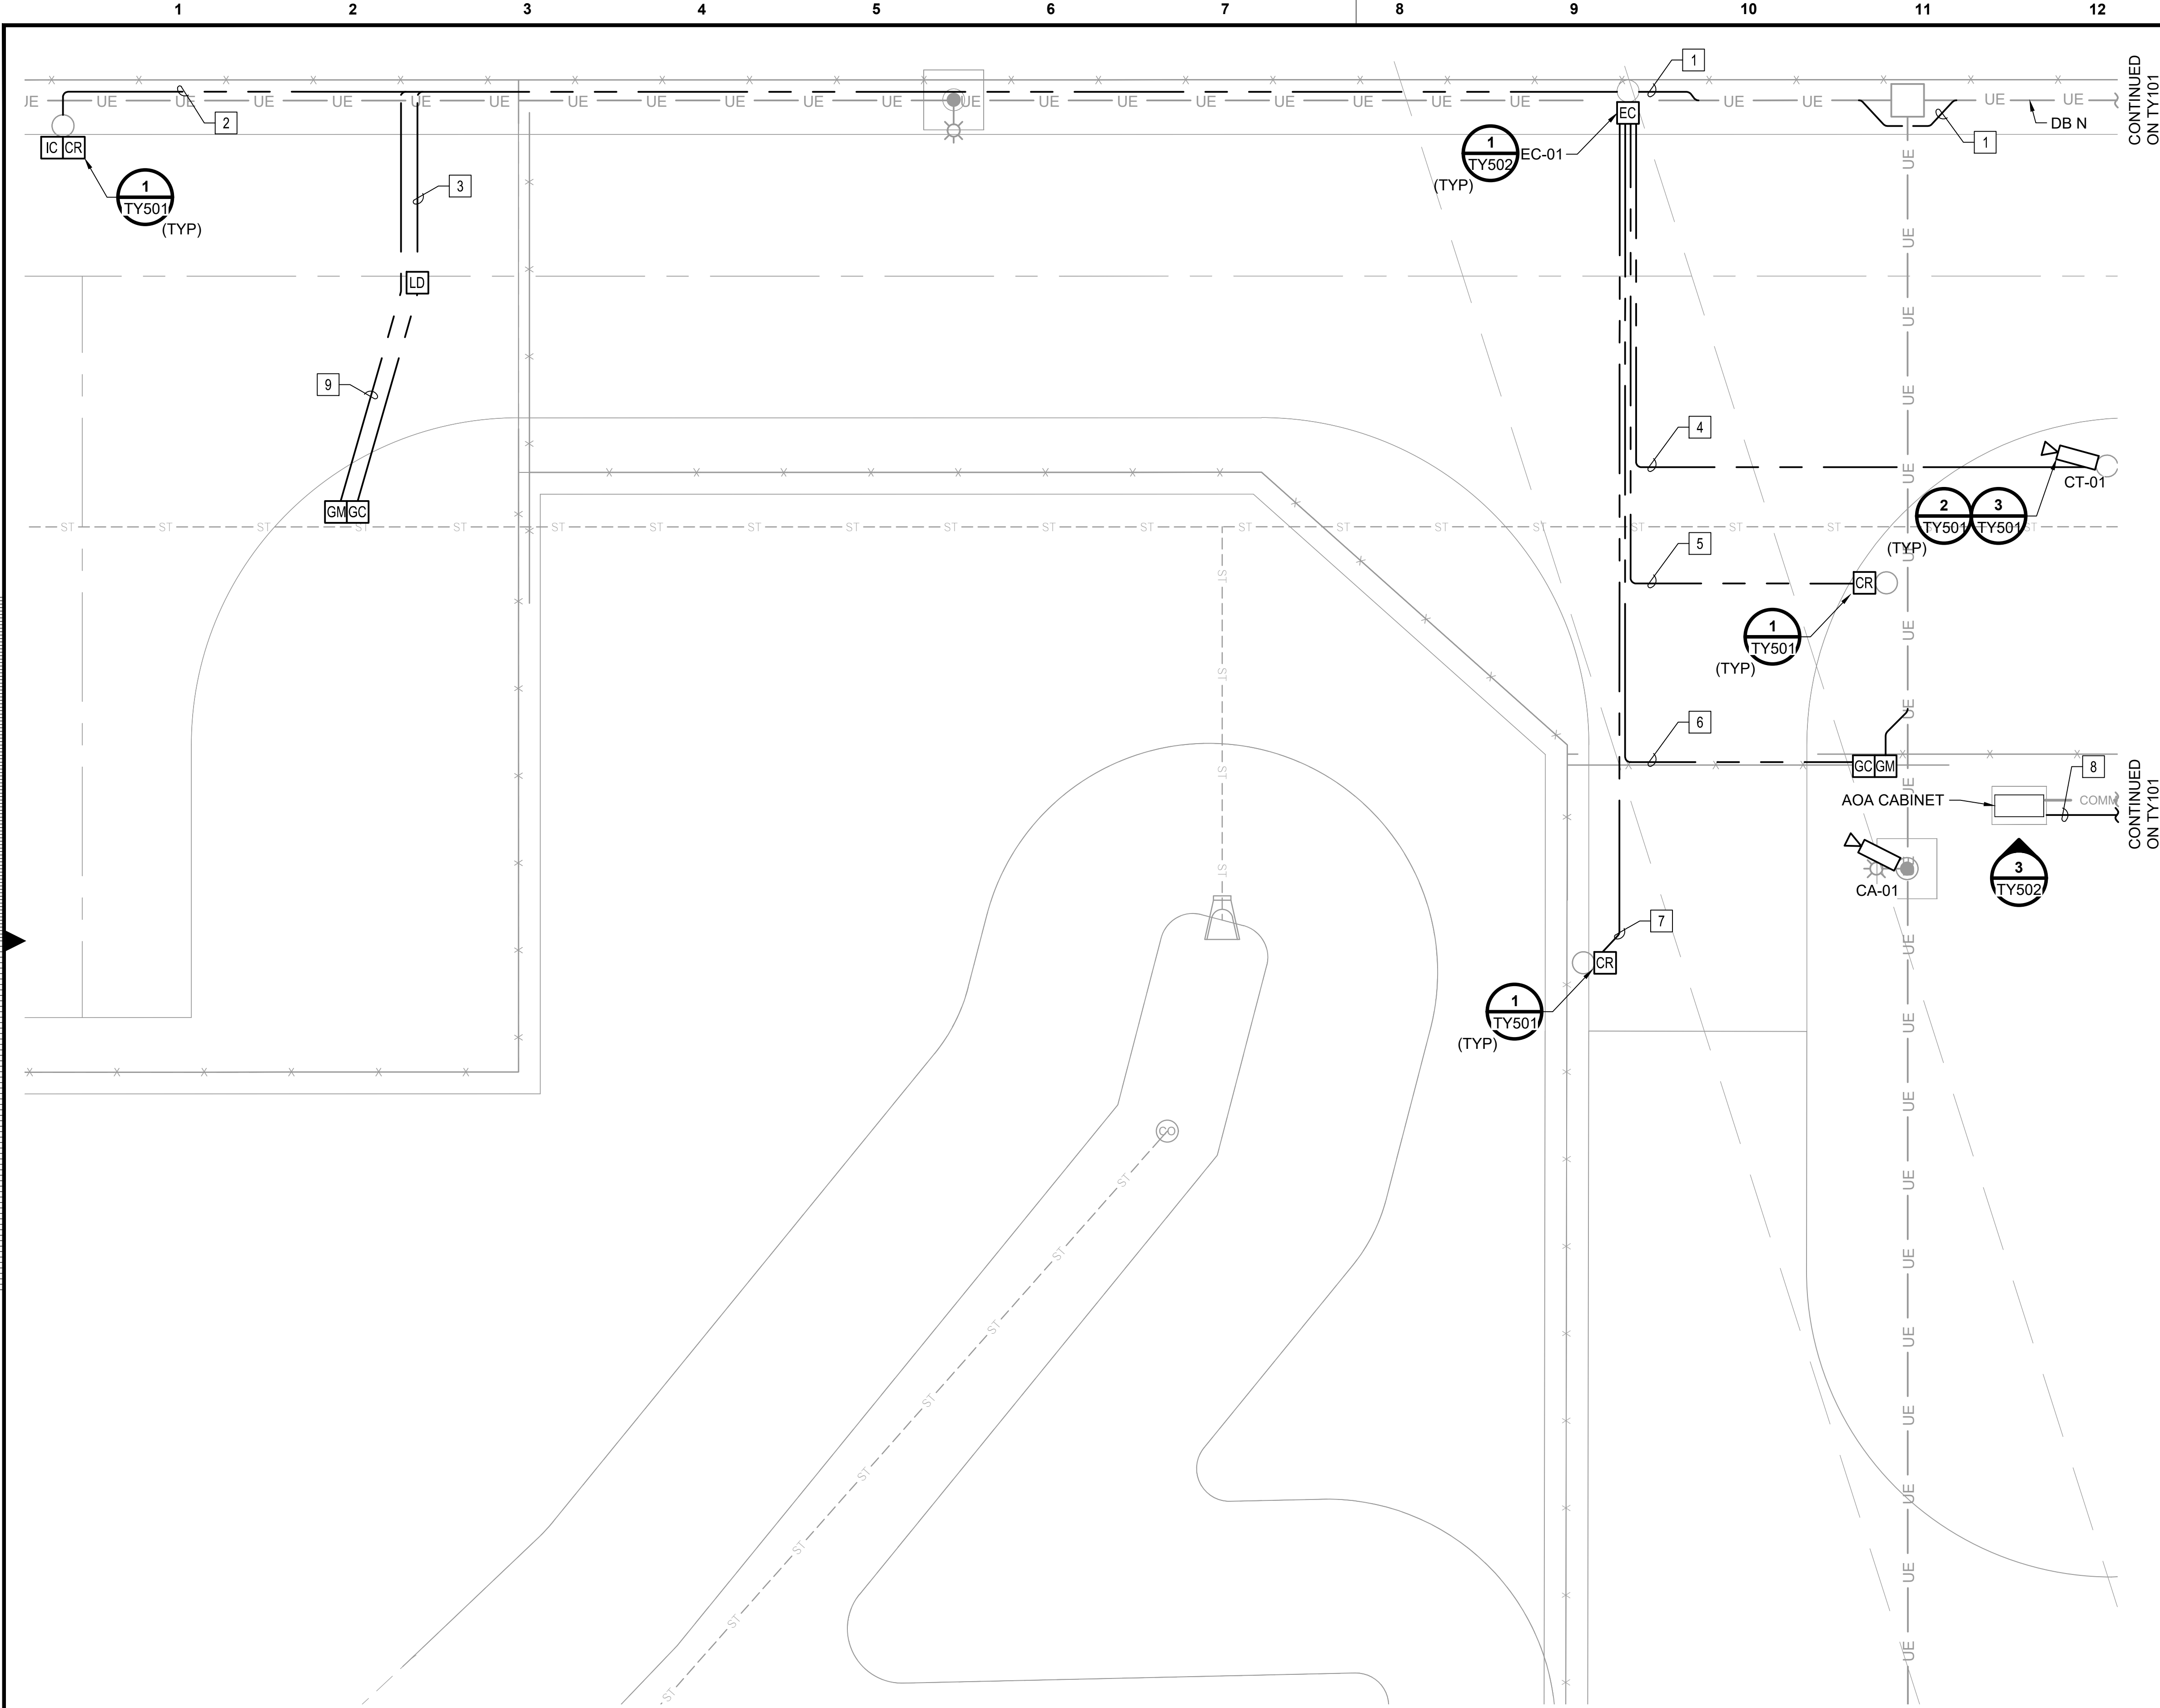

NOTES:

1. FINAL CONDUIT ROUTING AND EQUIPMENT PLACEMENT IN THE OPERATIONS BUILDING WILL BE PROVIDED BY JH KELLEY.

LEGEND:

- EC ENCLOSURE CABINET
- LD LOOP DETECTOR
- GC GATE CONTROLLER
- IC INTERCOM
- CR CARD READER
- GM GATE MOTOR
- CT FIXED CAMERA

CONDUIT SCHEDULE: #

1. 2"C: IC.OPS.EC01
2. 2"C: IC.EC01.ICCR
3. 2"C: IC.EC01.LDGC
4. 2"C: IC.EC01.CT01
5. 2"C: IC.EC01.CR
6. 2"C: IC.EC01.GC
7. 2"C: IC.EC01.CR
8. 1-1/2"C: IC.AOACAB.CA01
9. 2"C: P.PNLA2.57

no.	date	by	ckd	description
A	12/21/23	TSR	BAW	ISSUED FOR PERMIT

ISSUED FOR PERMIT ONLY



9400 WARD PARKWAY
KANSAS CITY, MO 64114
816-333-9400
Burns & McDonnell Engineering Co., Inc.

date	04/24/2023	detailed	S. JESBERG
designed	T. RENSHAW	checked	B. WINTER


PDX FUEL COMPANY L.L.C

PORTLAND INTERNATIONAL AIRPORT
5000 NE MARINE DR.
PORTLAND, OREGON 97218

PDX FACILITY IMPROVEMENTS
ENLARGED SECURITY PLAN - AOA GATE

project	153929	contract	
drawing	TY401	rev.	A

file 153929TY401.dwg

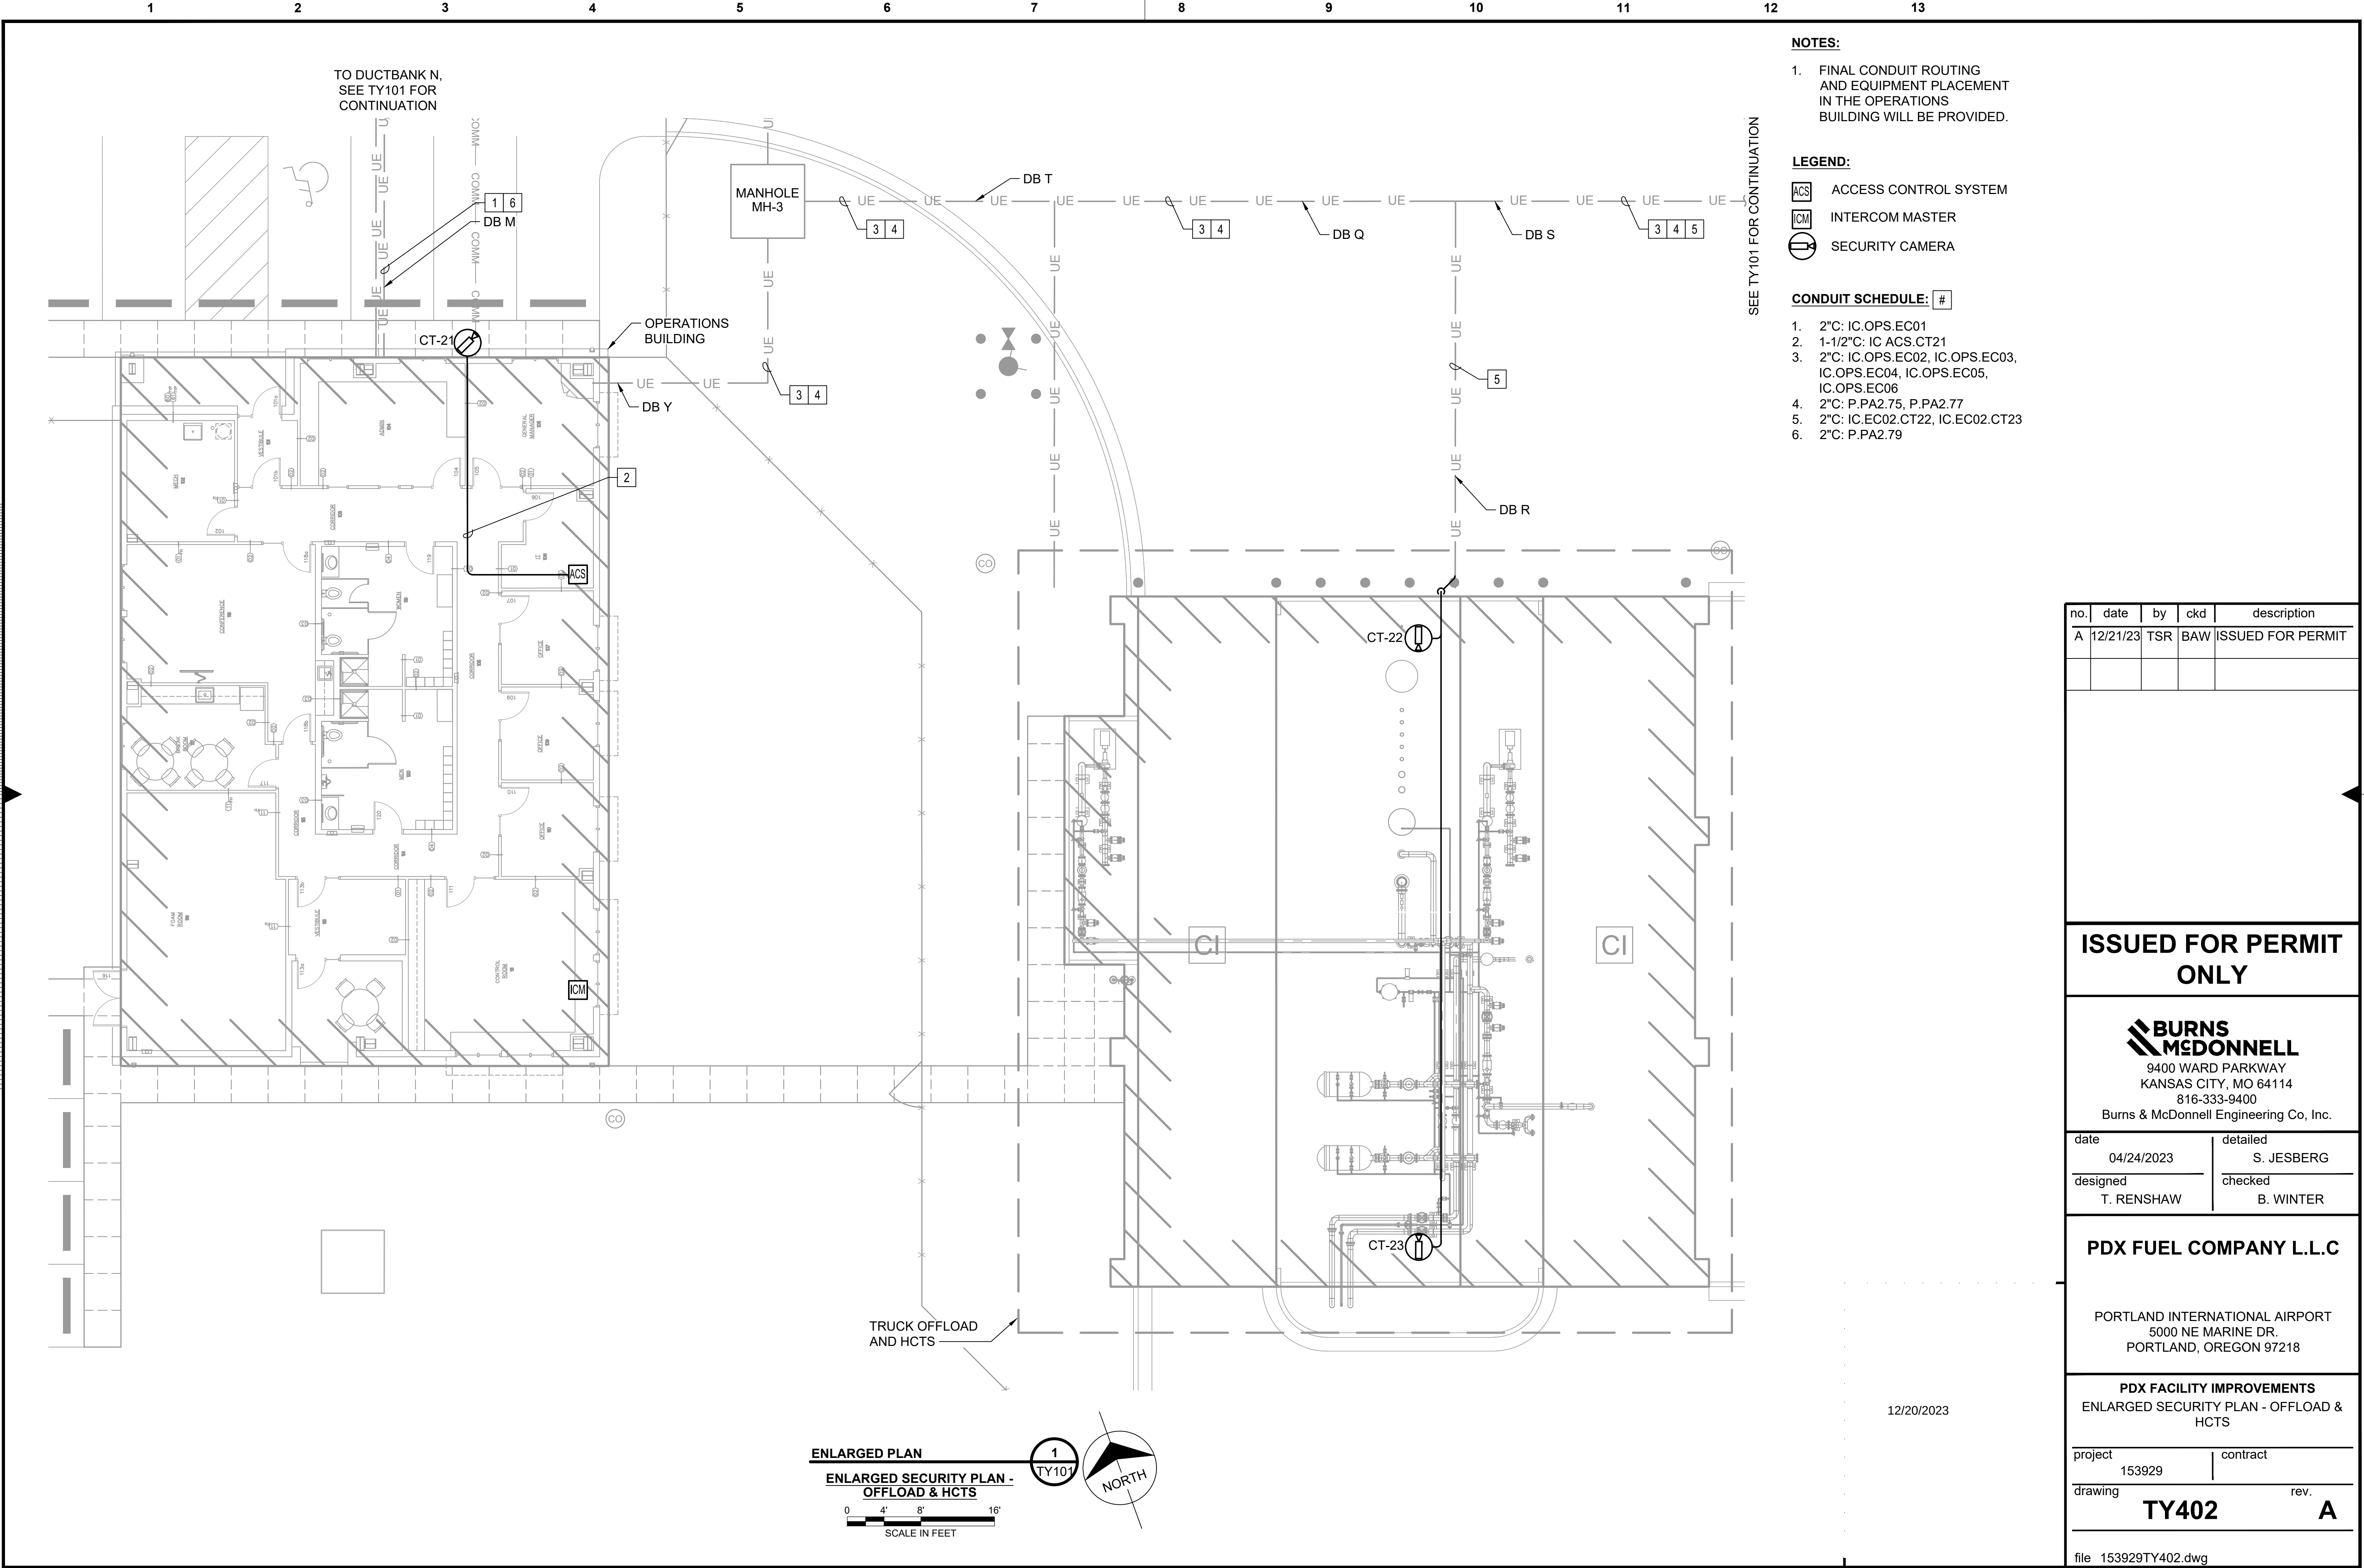


1 2 3 4 5 6 7 8 9 10 11 12 13

Scale For Microfilming

Millimeters


Inches

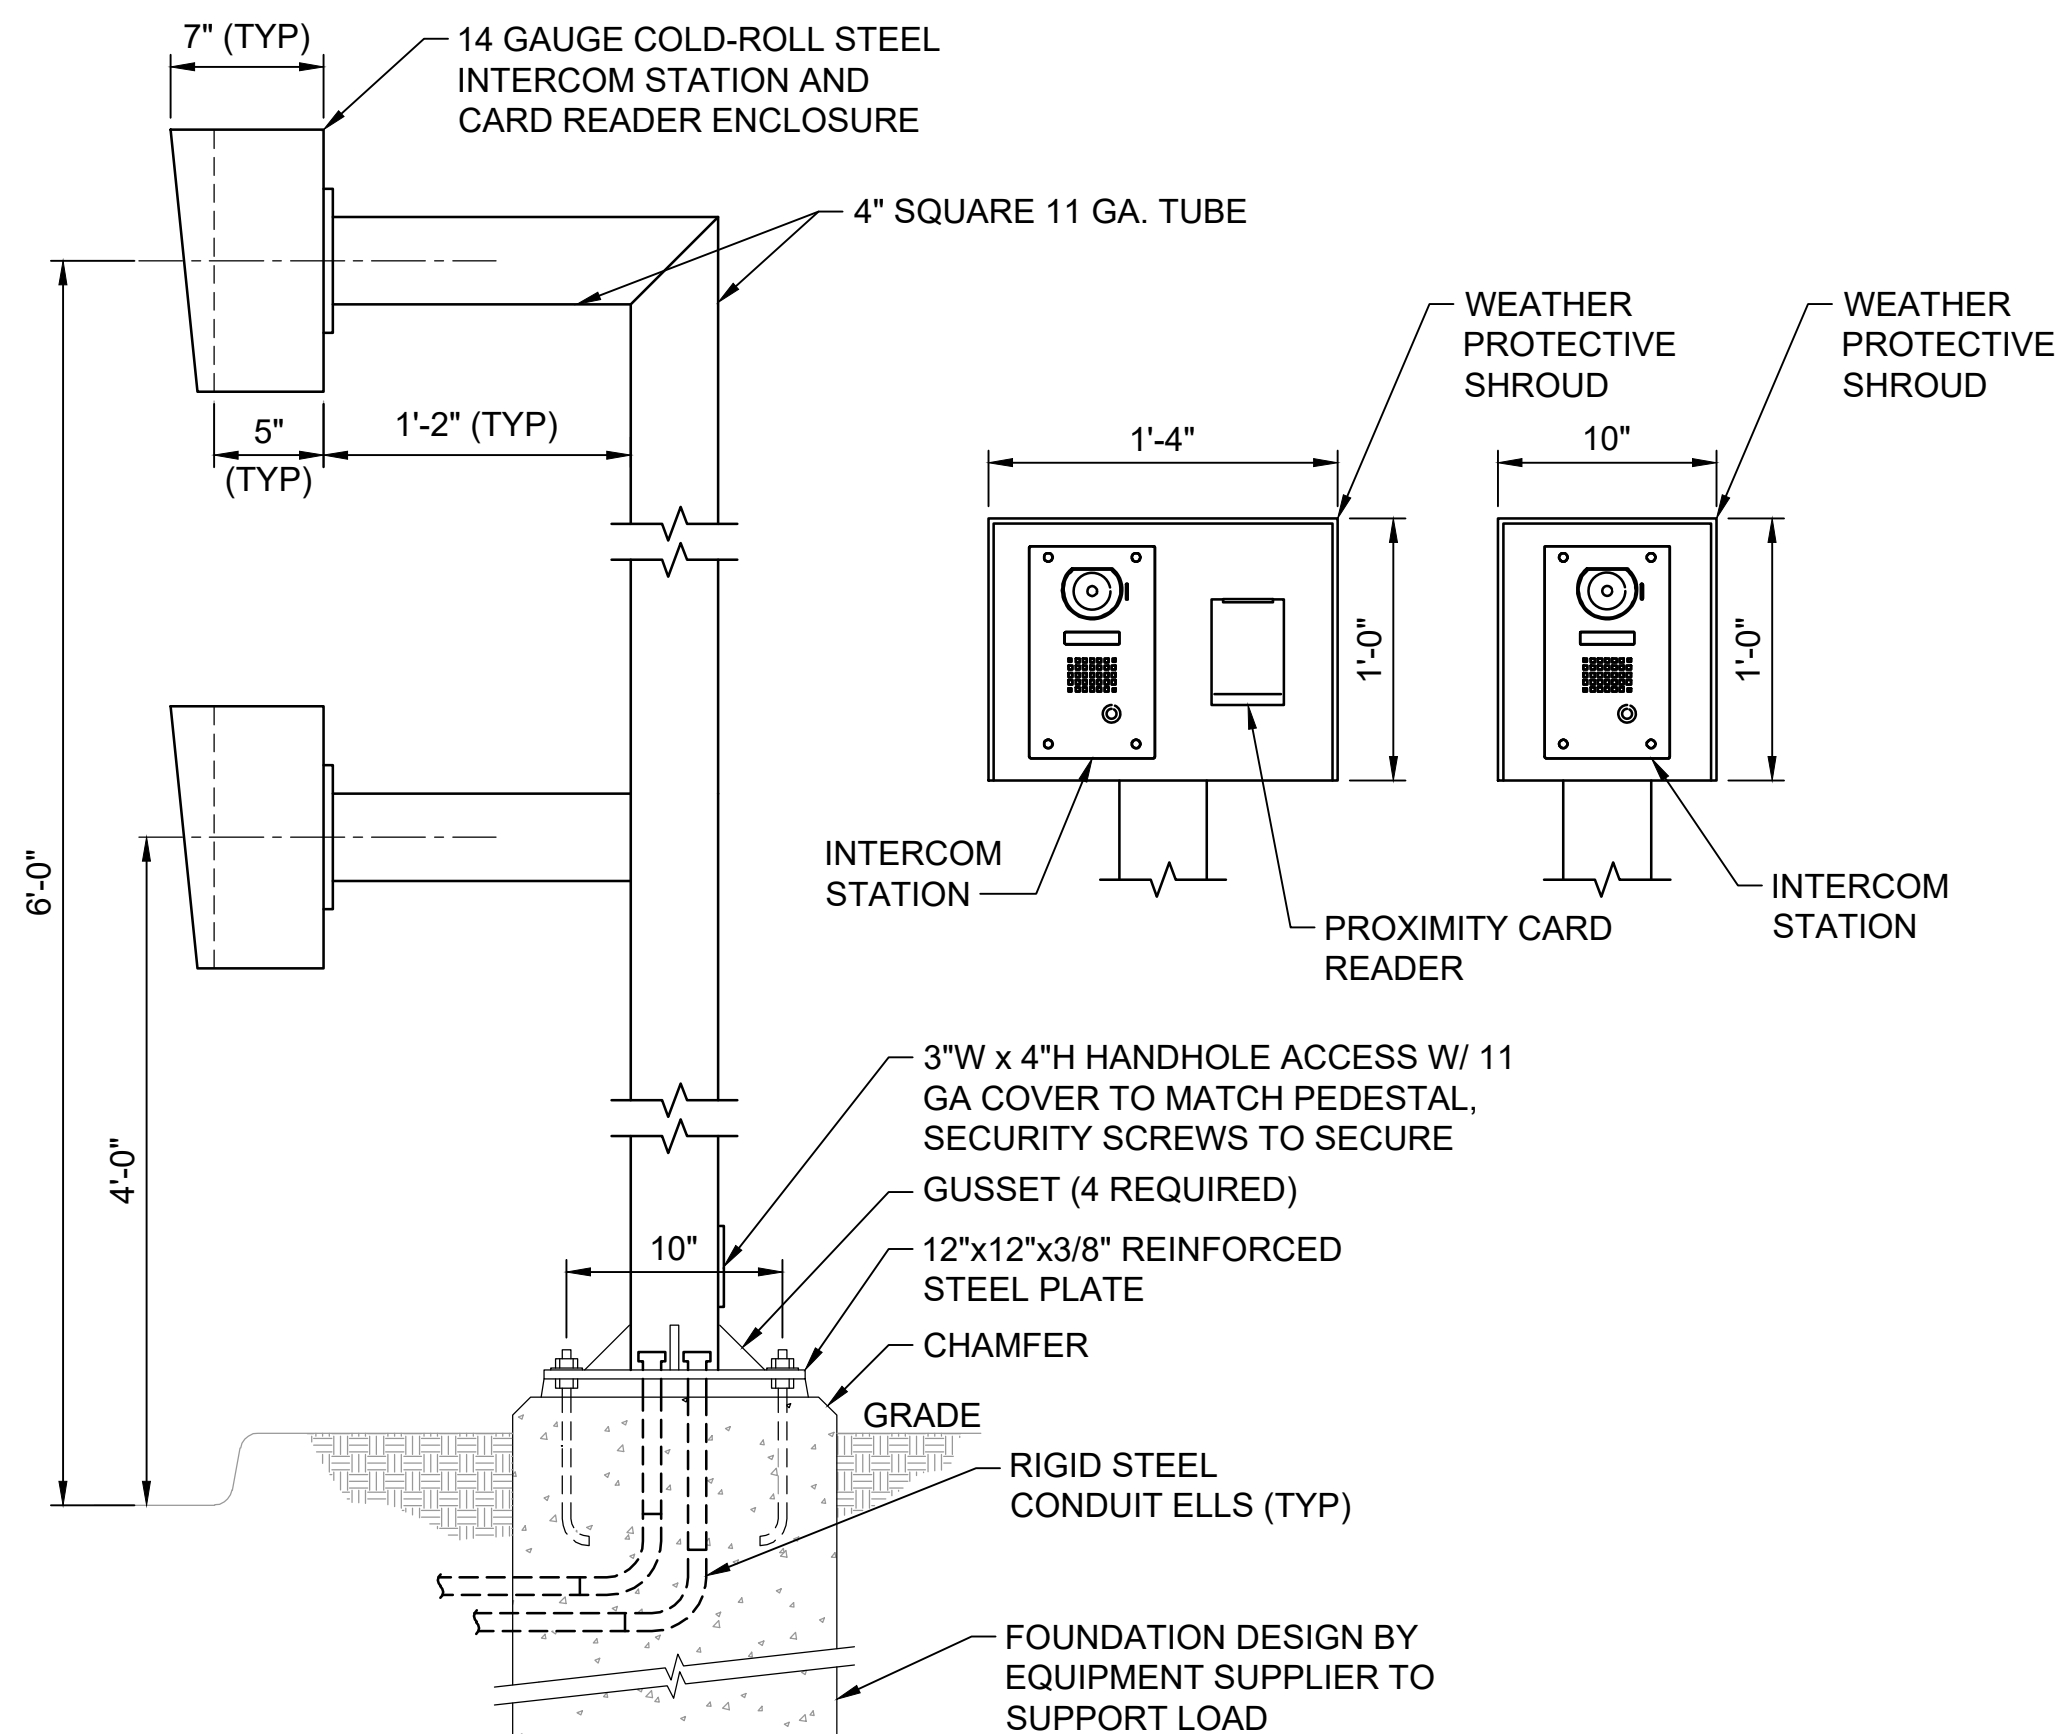


NOTES:

1. REFER TO S-531 FOR FOUNDATION REQUIREMENTS.

DETAIL 1
PEDESTAL MOUNTED CARD READER AND INTERCOM
NOT TO SCALE

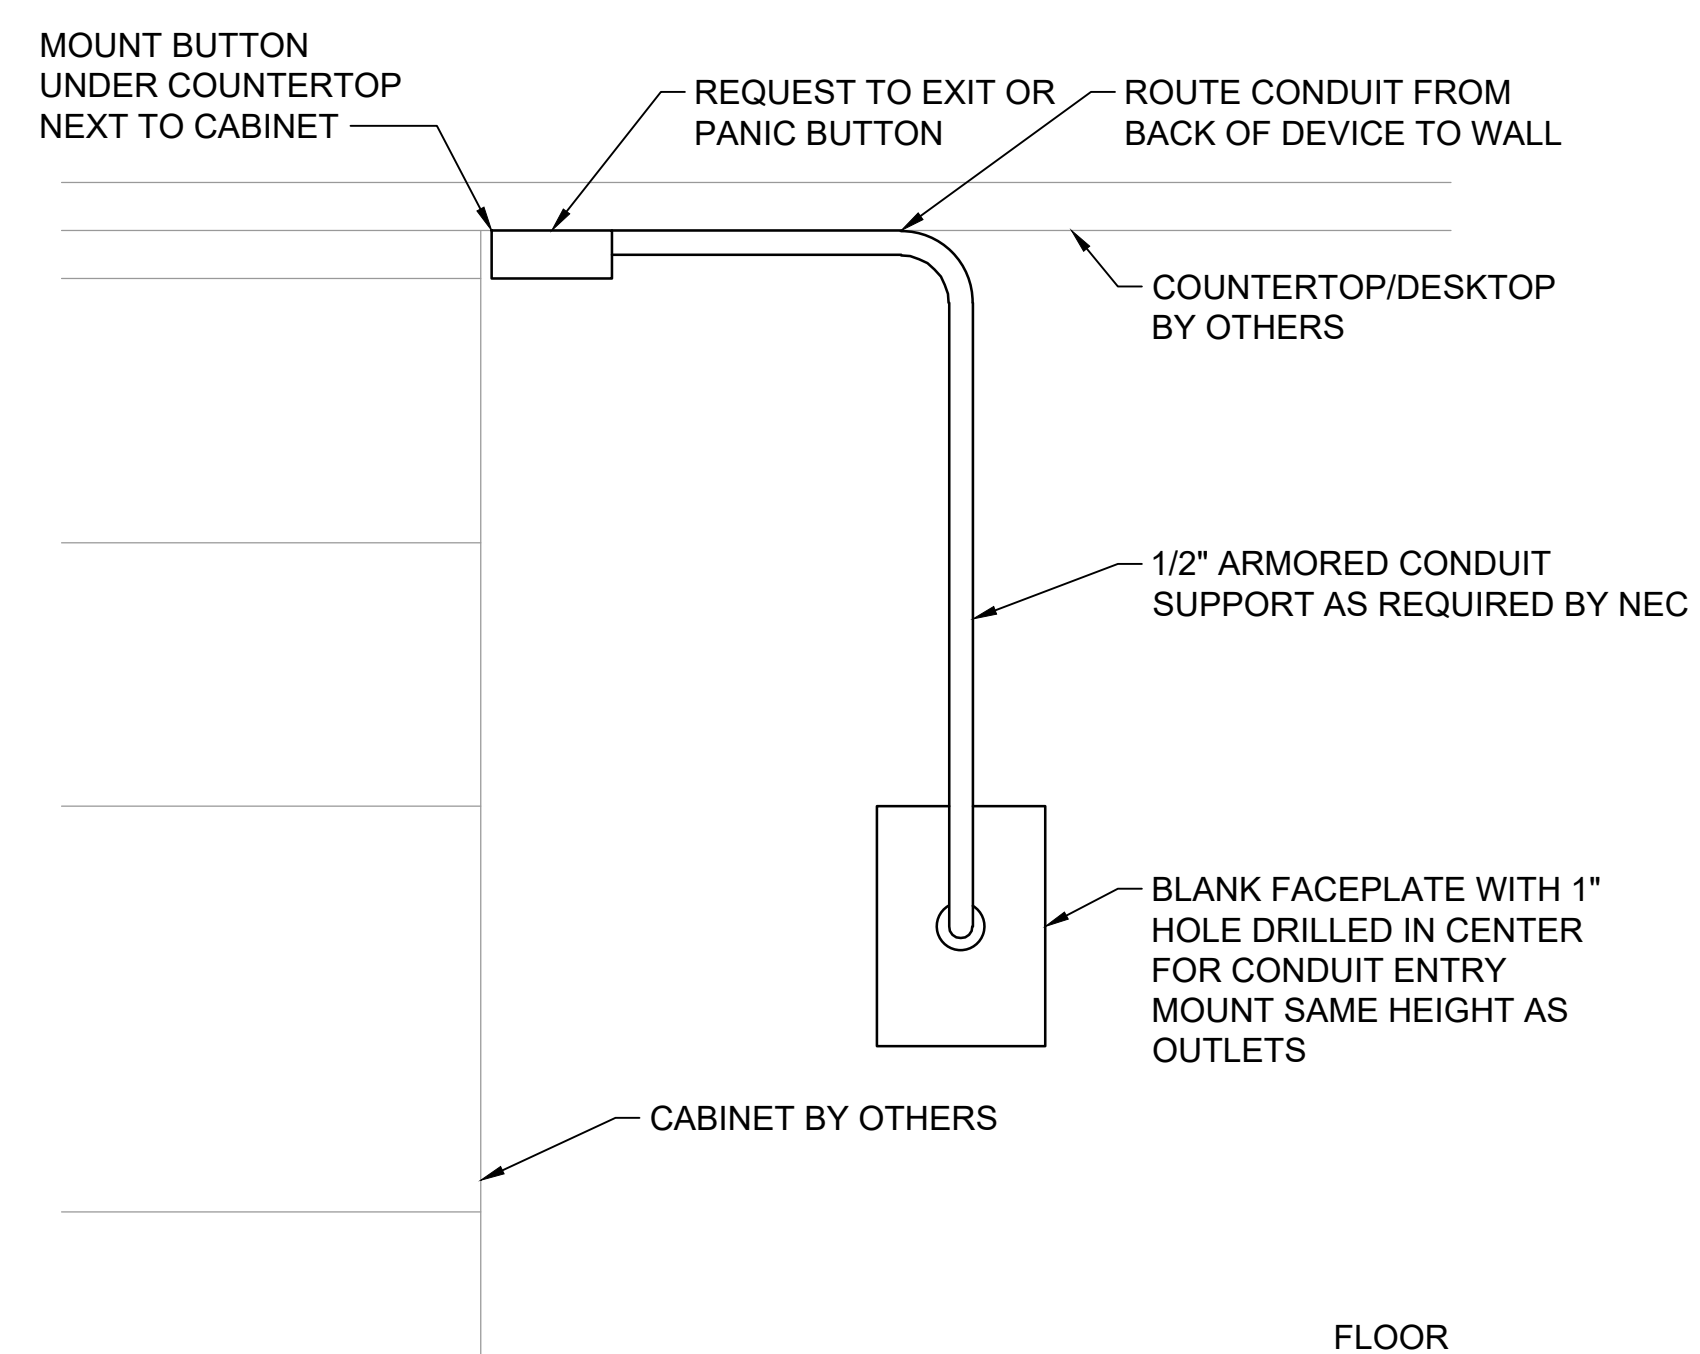


DETAIL 4
UNDER COUNTERTOP REQUEST TO EXIT AND PANIC BUTTON
NOT TO SCALE

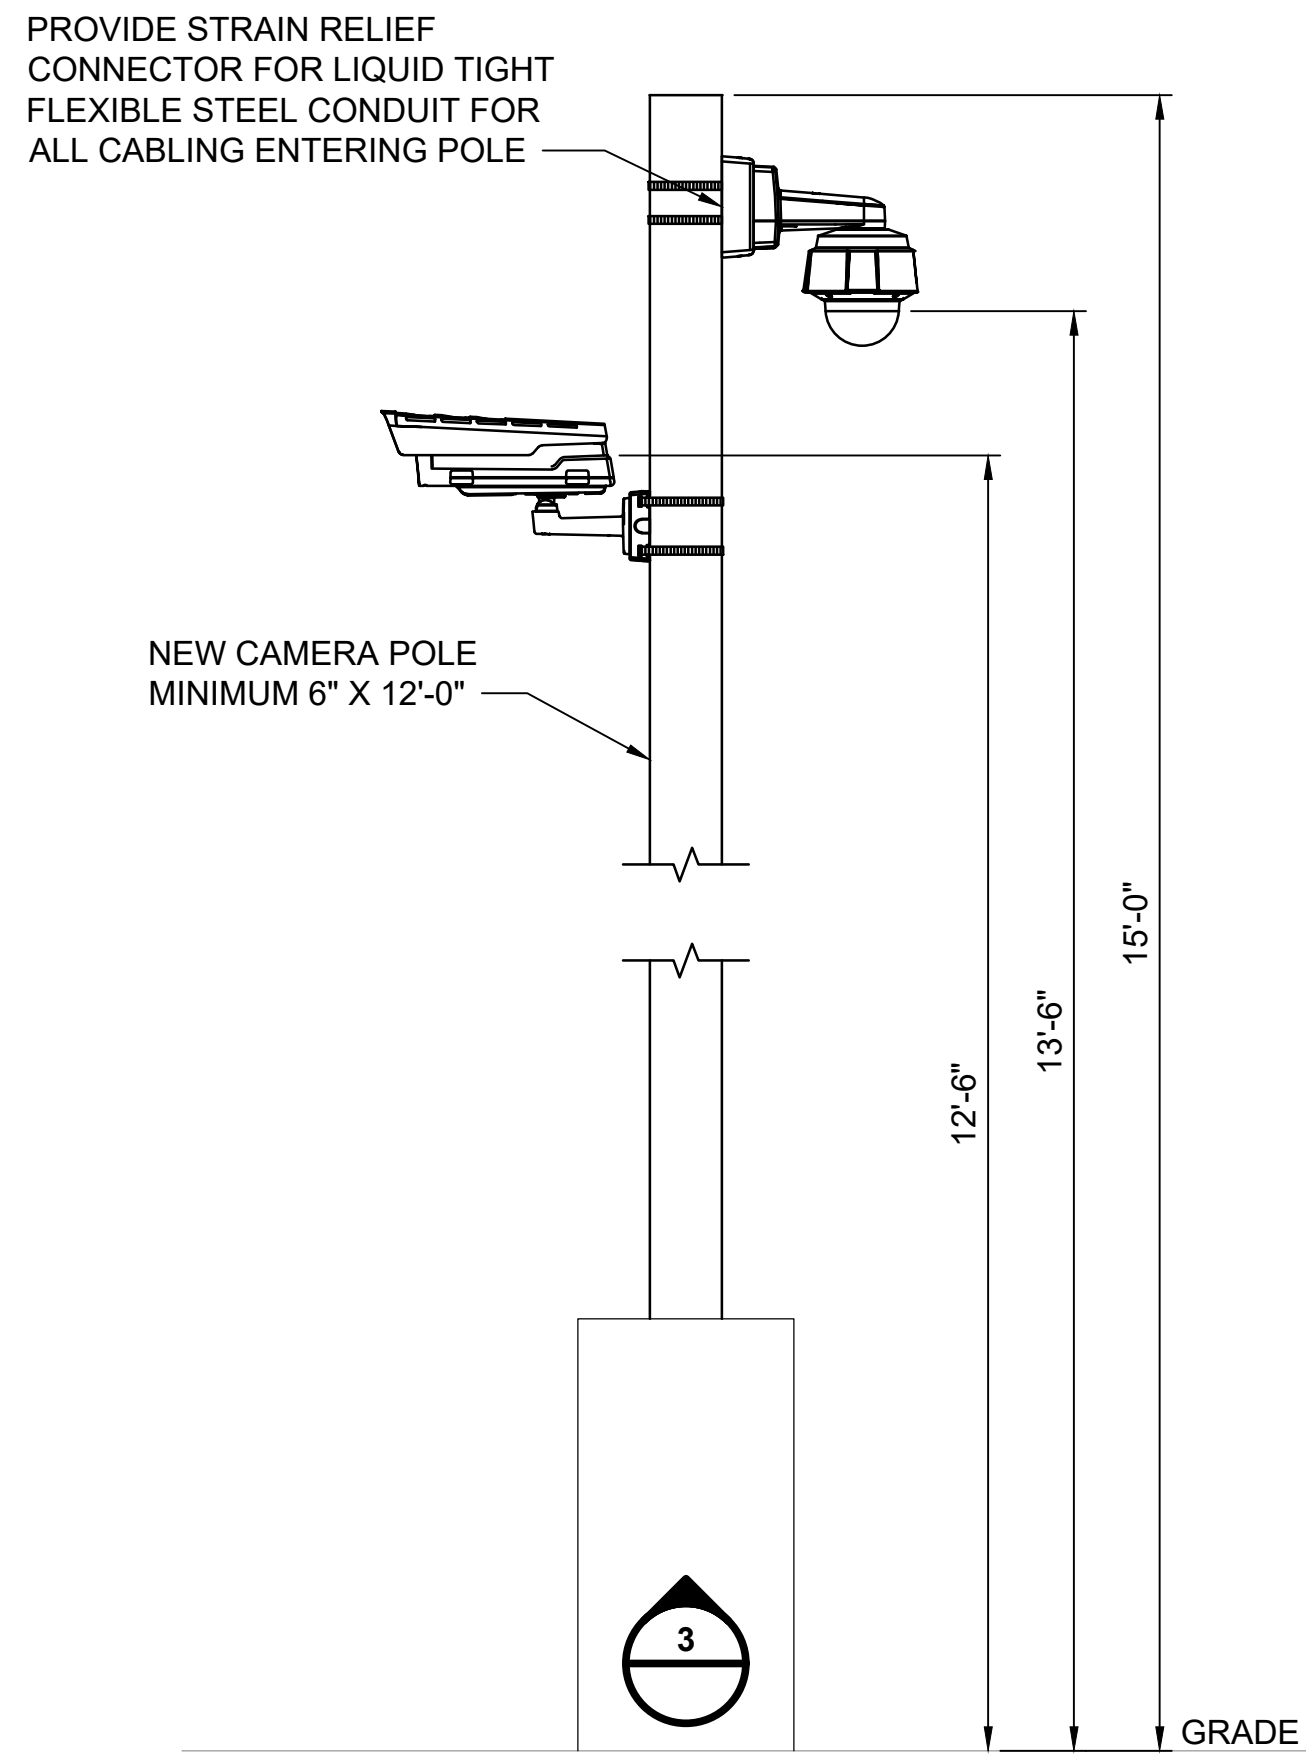

NOTES:

1. REFER TO S-531 FOR FOUNDATION REQUIREMENTS.

DETAIL 2
CAMERA ON POLE
NOT TO SCALE

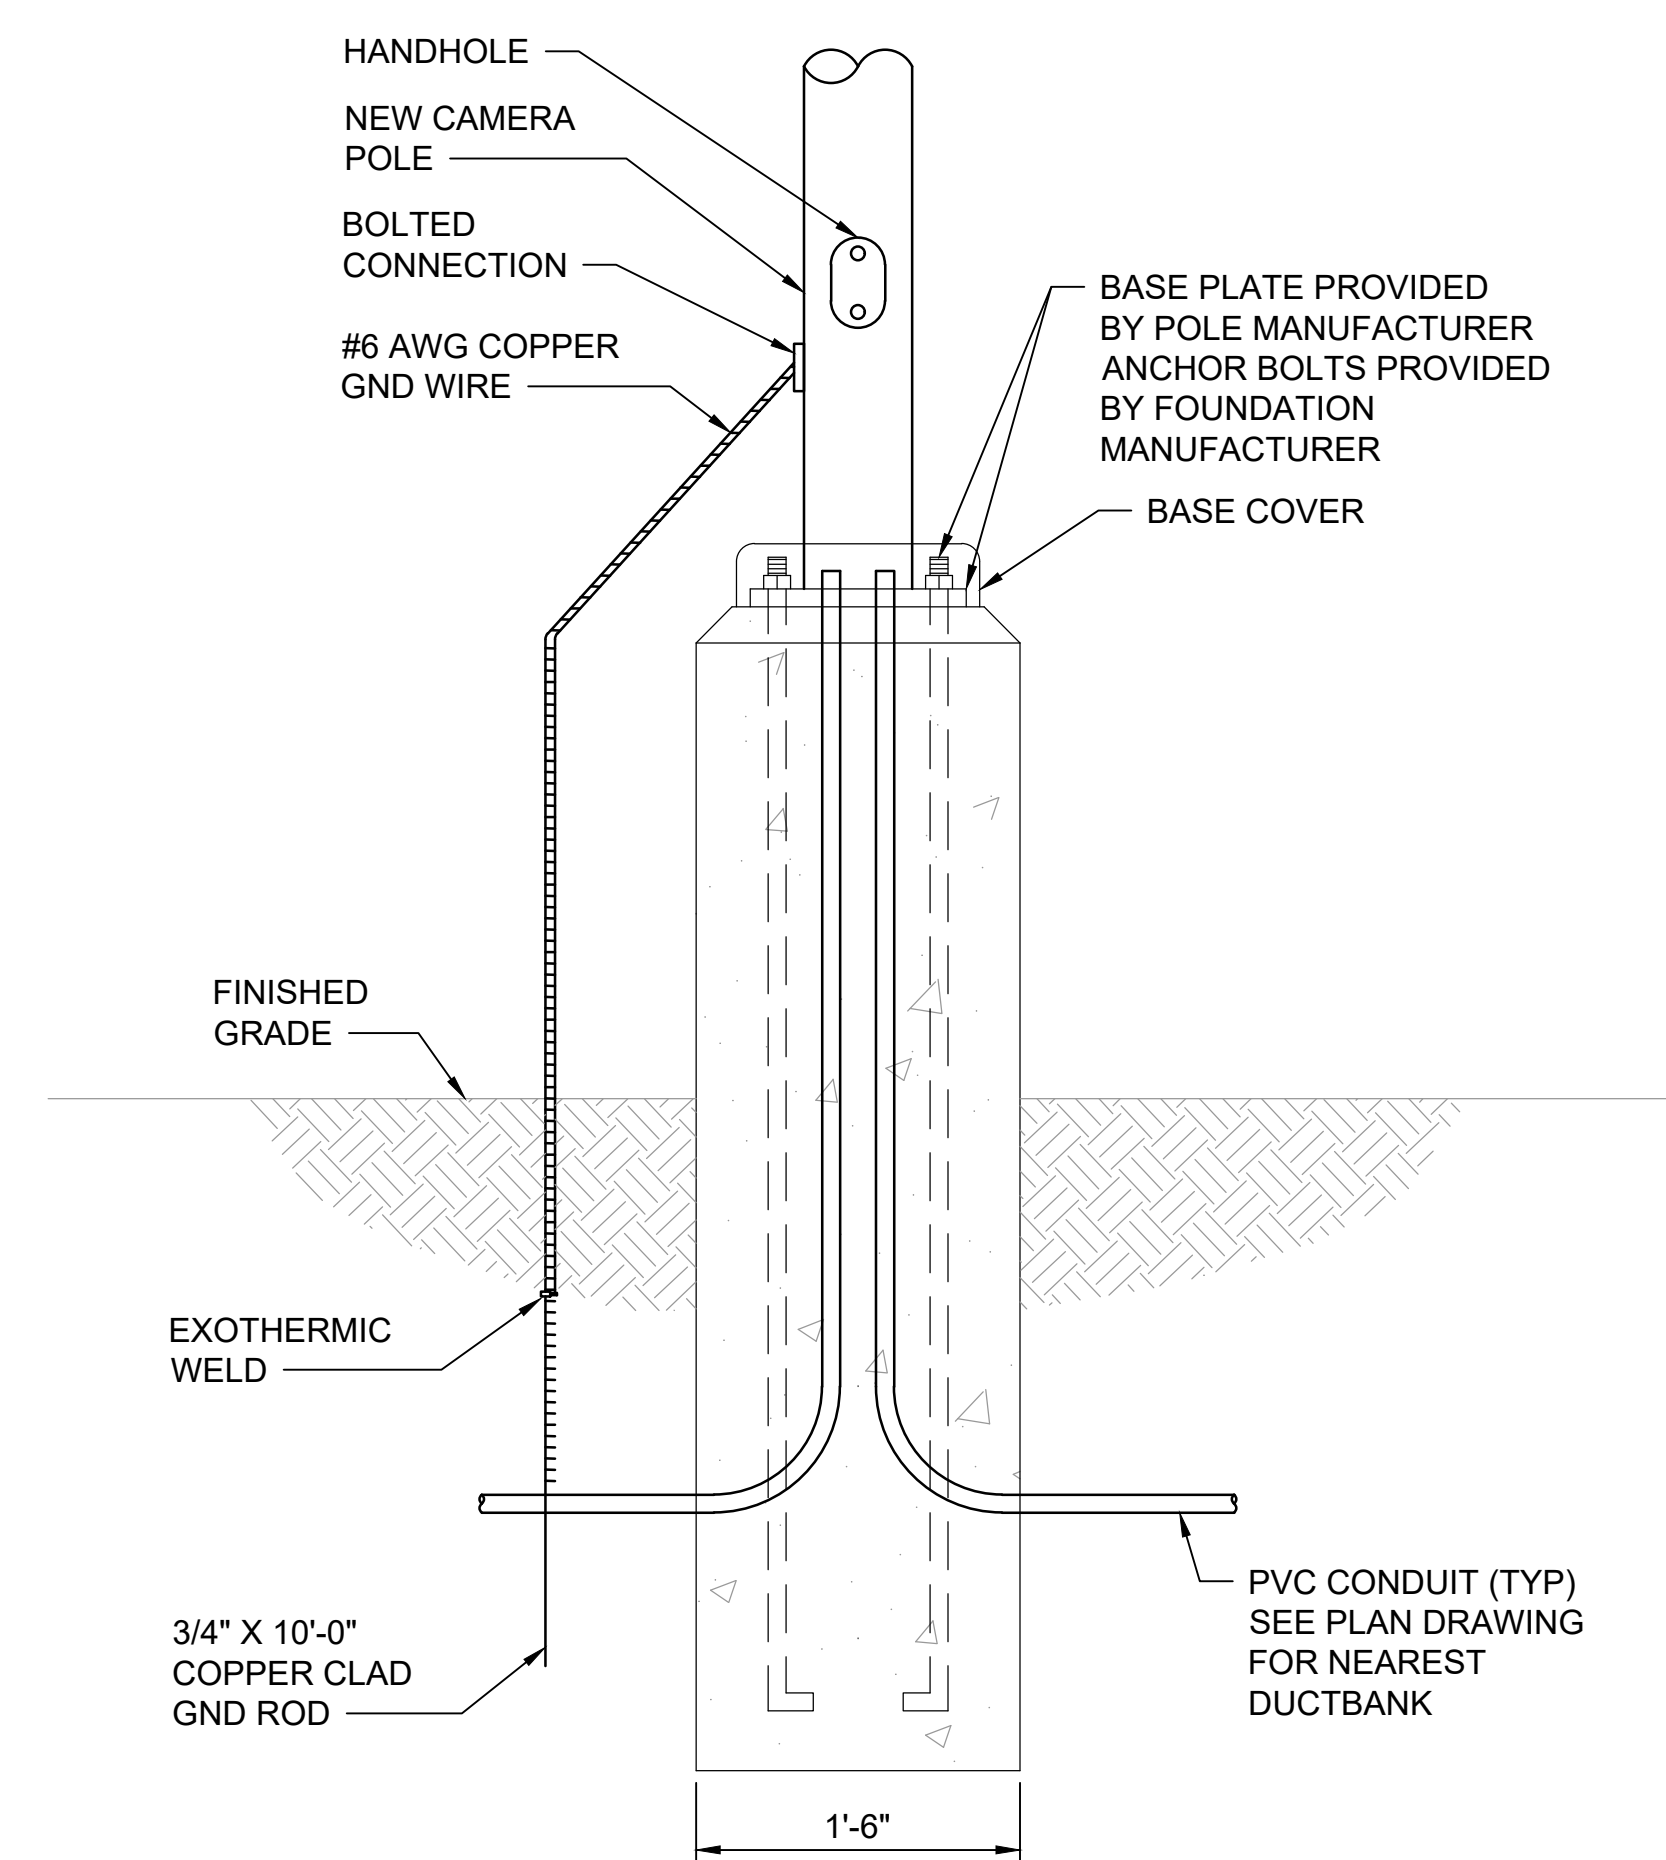

NOTES:

1. REFER TO S-531 FOR FOUNDATION REQUIREMENTS.

DETAIL 3
CAMERA POLE FOUNDATION - CONDUIT BELOW GRADE
NOT TO SCALE

12/20/2023

no.	date	by	ckd	description
A	12/21/23	TSR	BAW	ISSUED FOR PERMIT

ISSUED FOR PERMIT ONLY

BURNS MEDONNELL

9400 WARD PARKWAY
KANSAS CITY, MO 64114
816-333-9400
Burns & McDonnell Engineering Co., Inc.


date	04/24/2023	detailed	S. JESBERG
designed	T. RENSHAW	checked	B. WINTER

PDX FUEL COMPANY L.L.C


PORTLAND INTERNATIONAL AIRPORT
5000 NE MARINE DR.
PORTLAND, OREGON 97218

PDX FACILITY IMPROVEMENTS SECURITY DETAILS - 1	
project	contract
153929	
drawing	rev.
TY501	A
file 153929TY501.dwg	

Millimeters
Inches
Scale For Microfilming

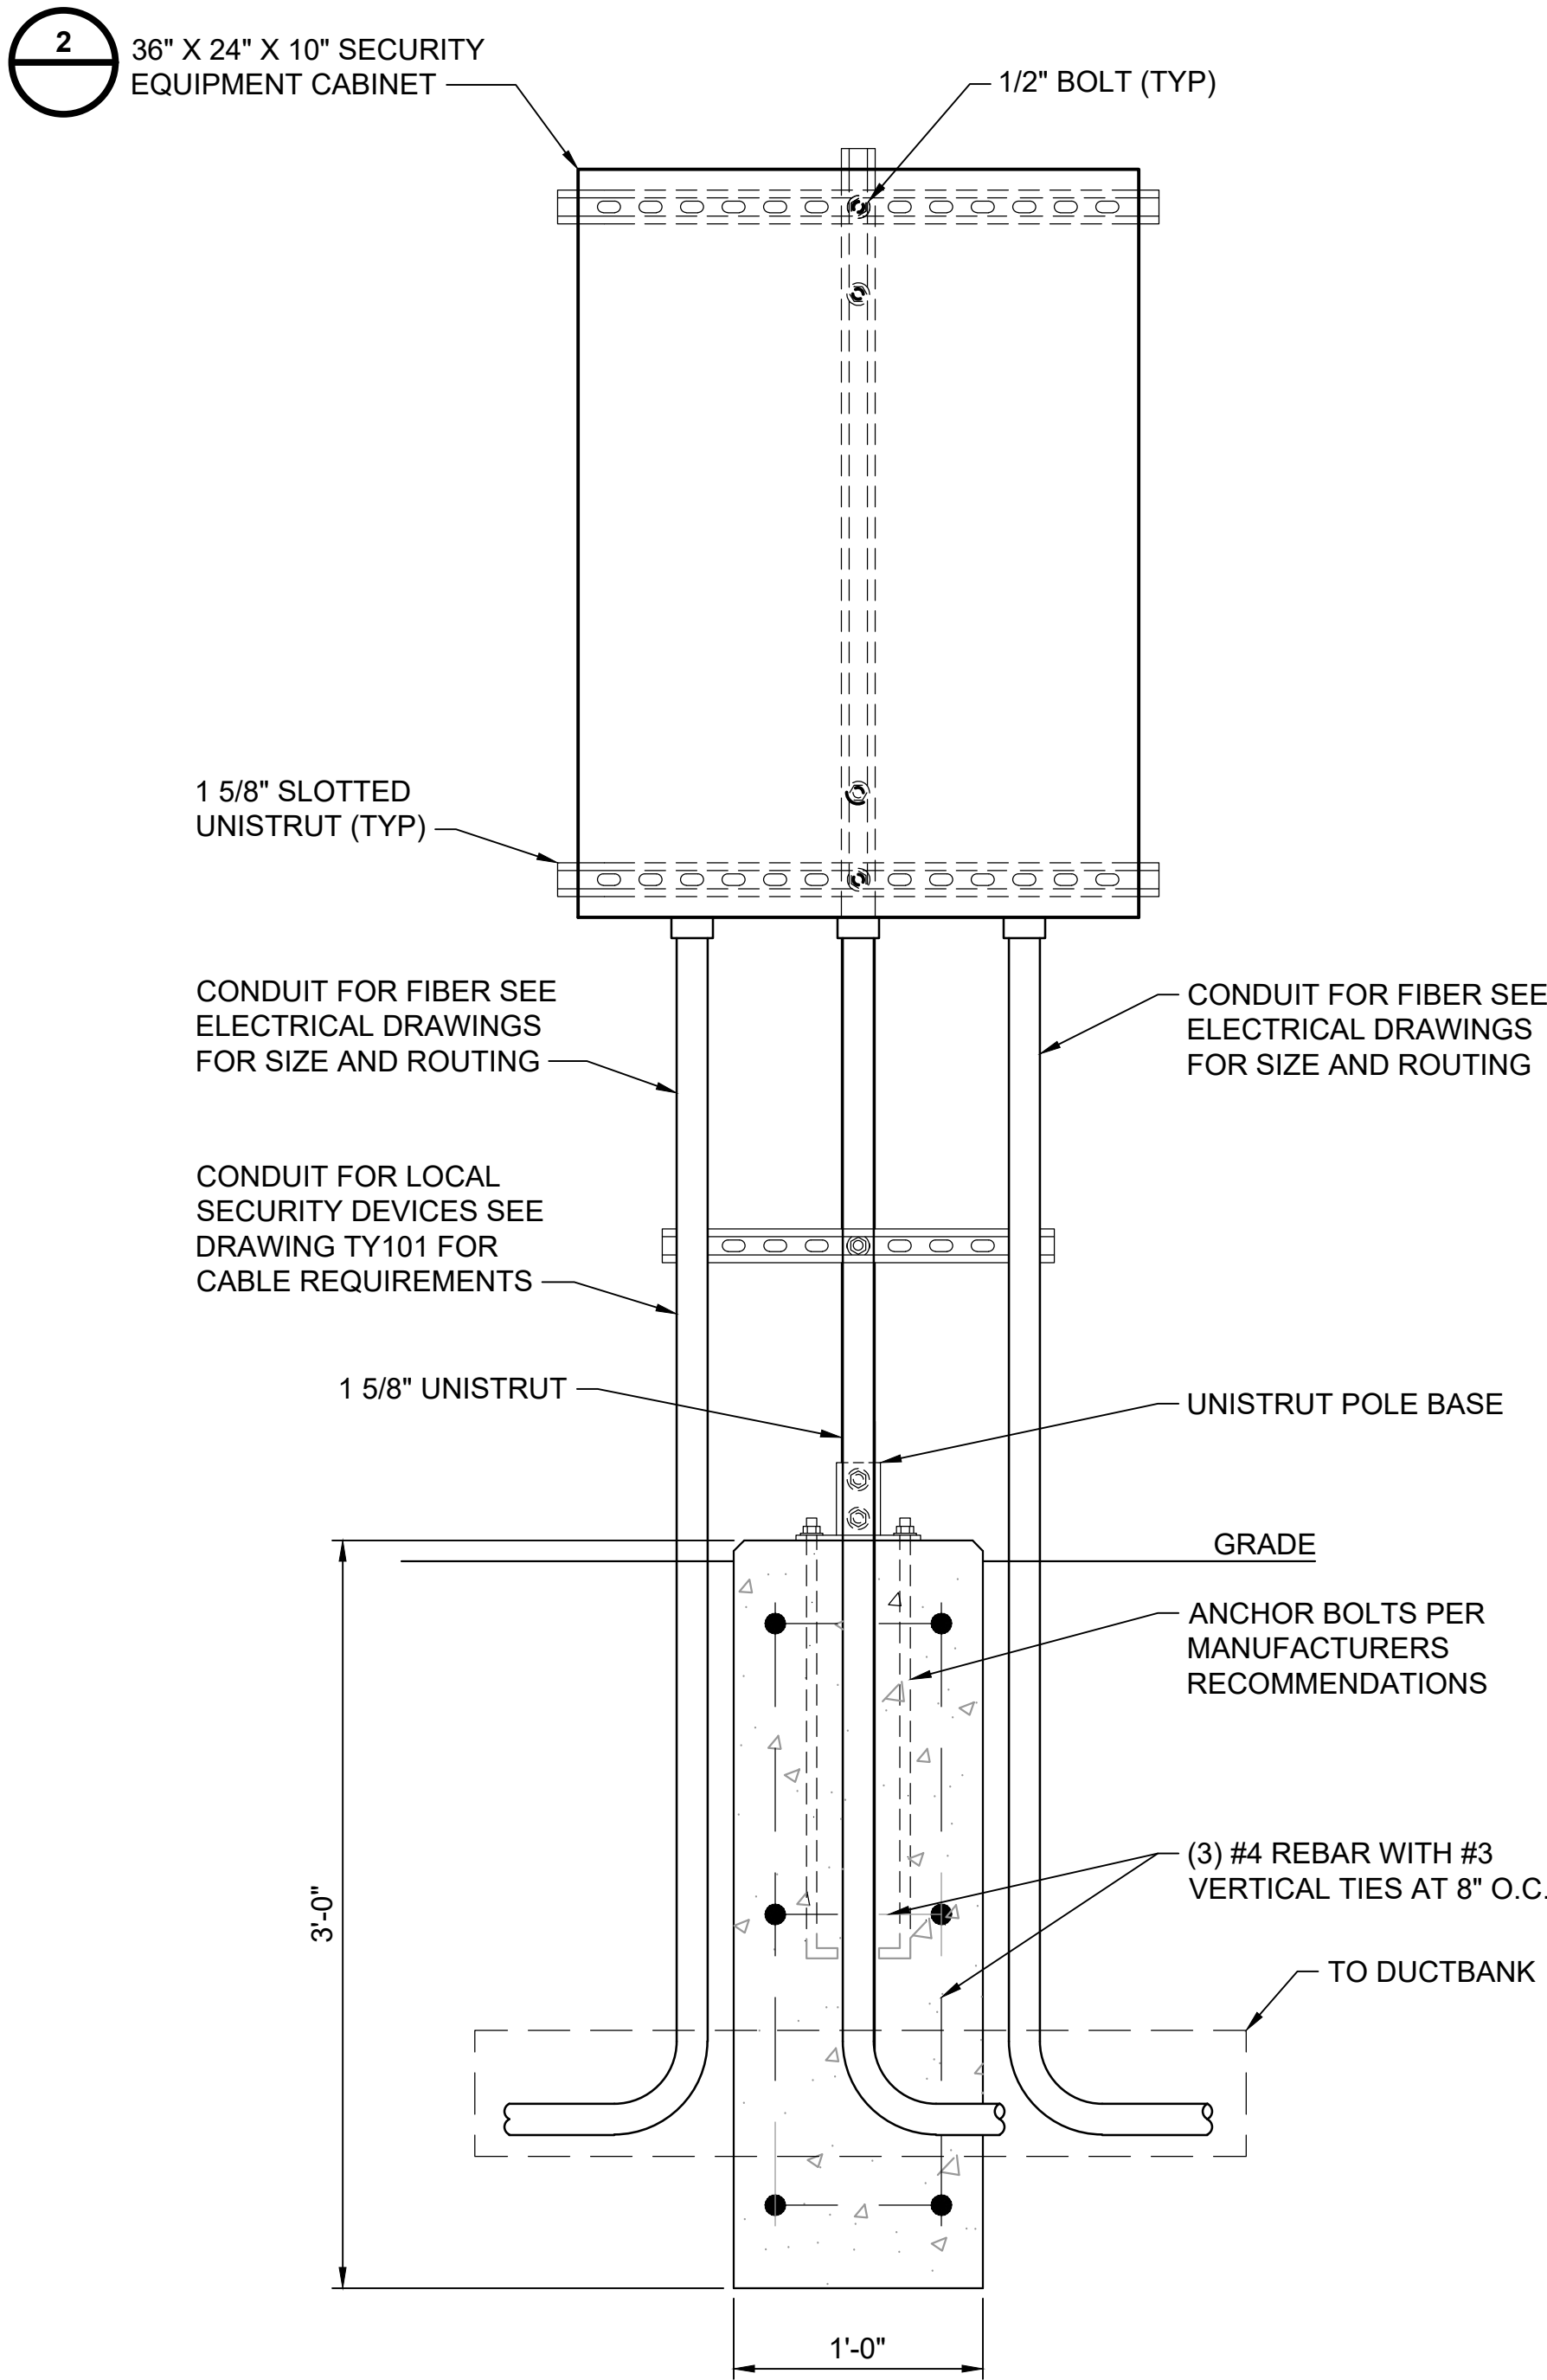


DETAIL
EQUIPMENT CABINET
MOUNTING DETAIL
NOT TO SCALE

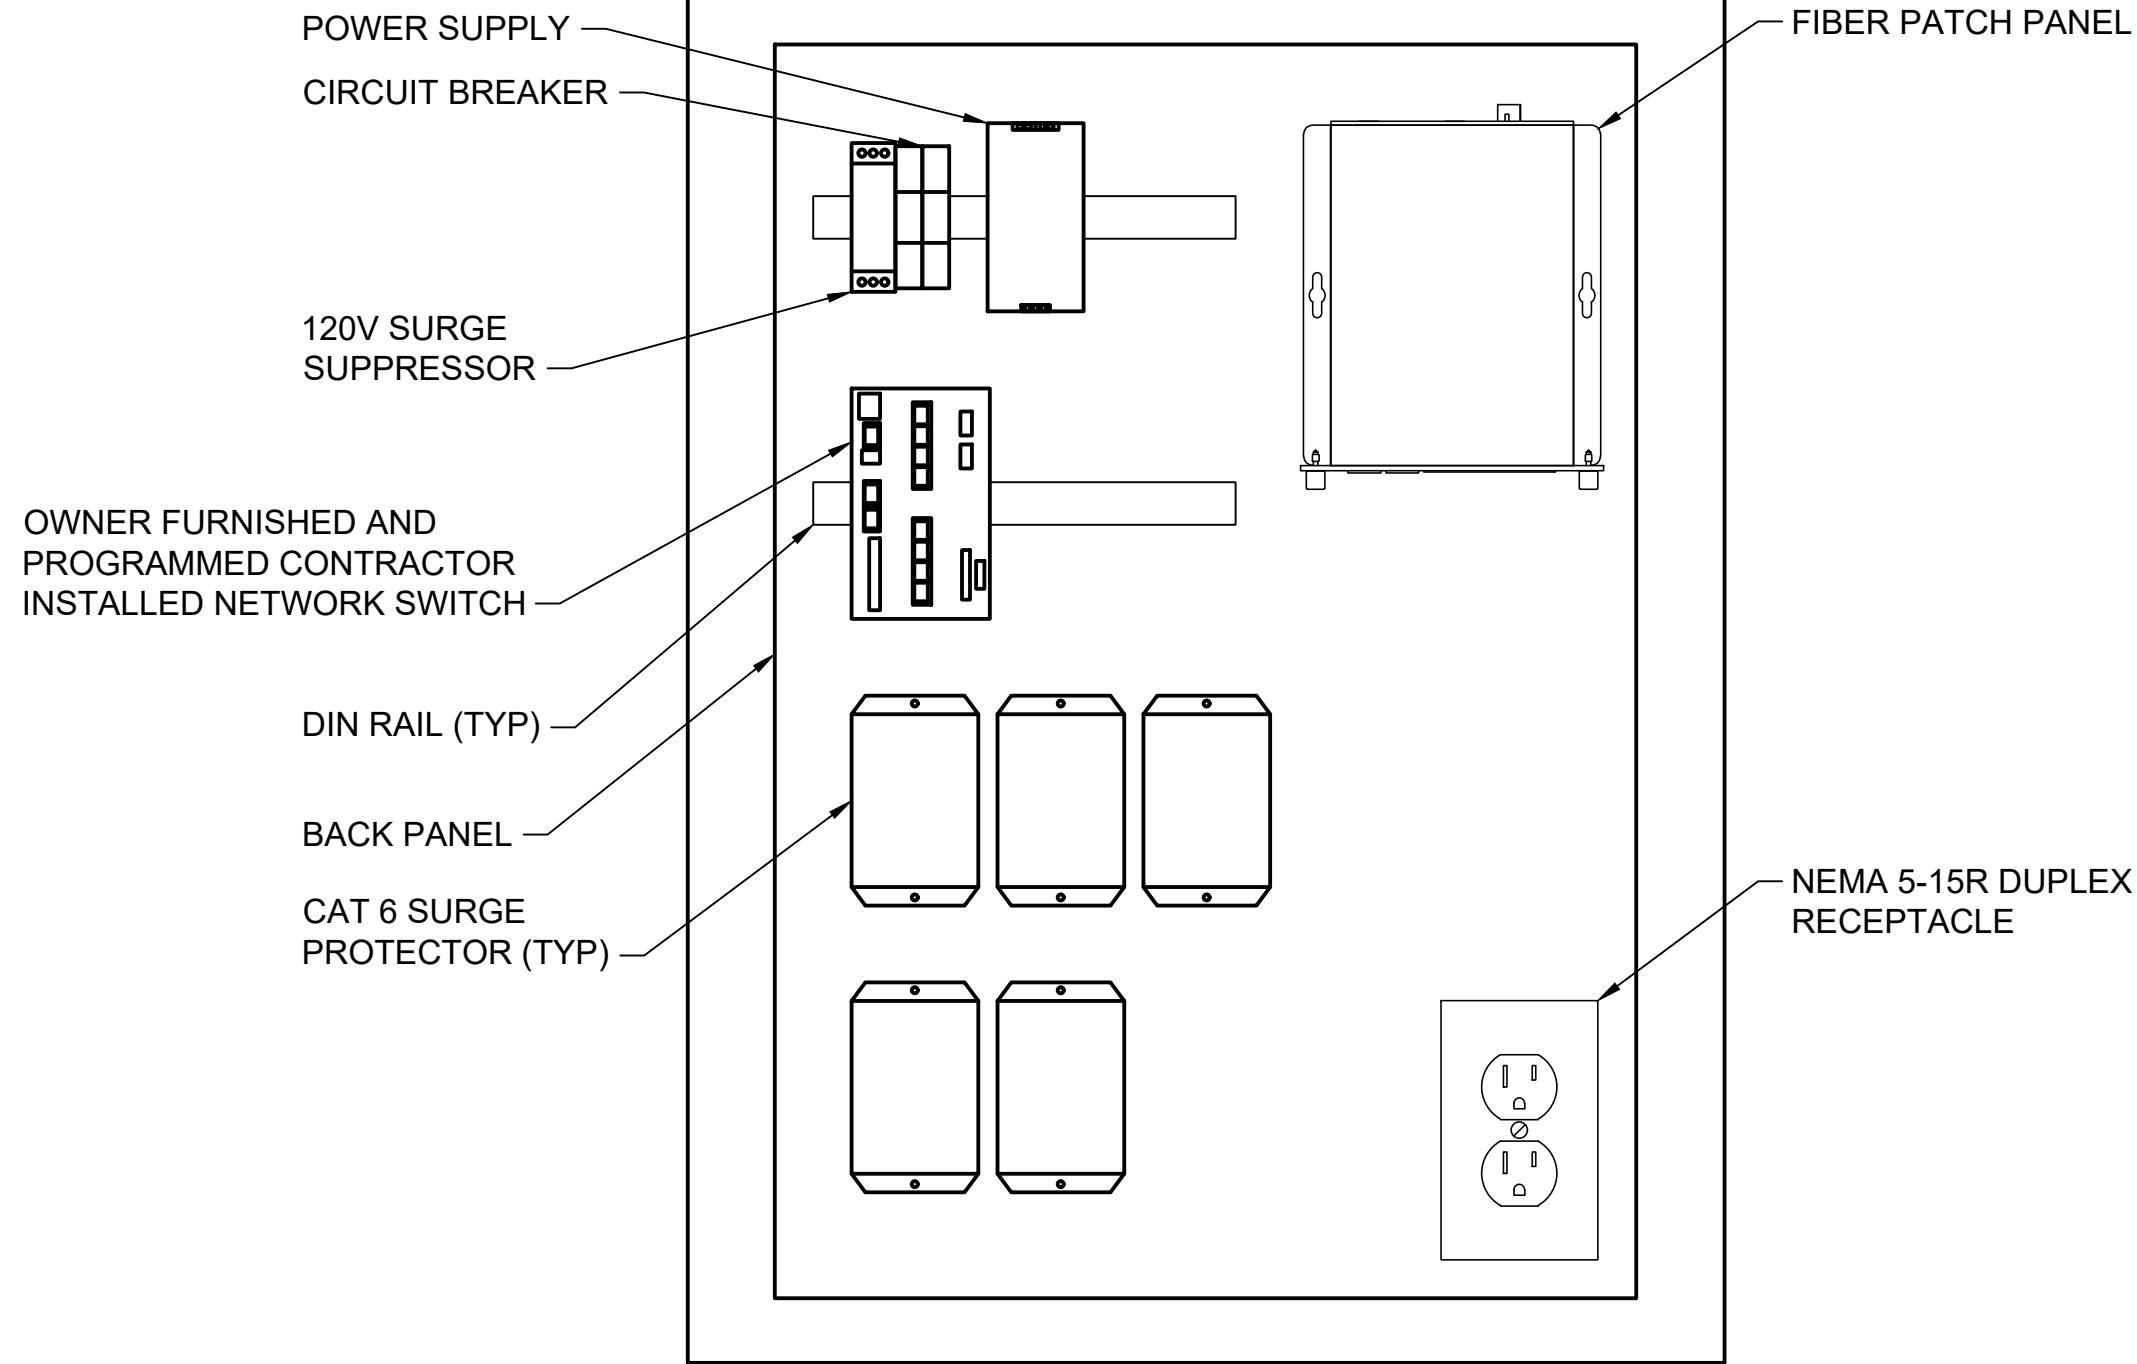

DETAIL
EQUIPMENT CABINET

NOT TO SCALE

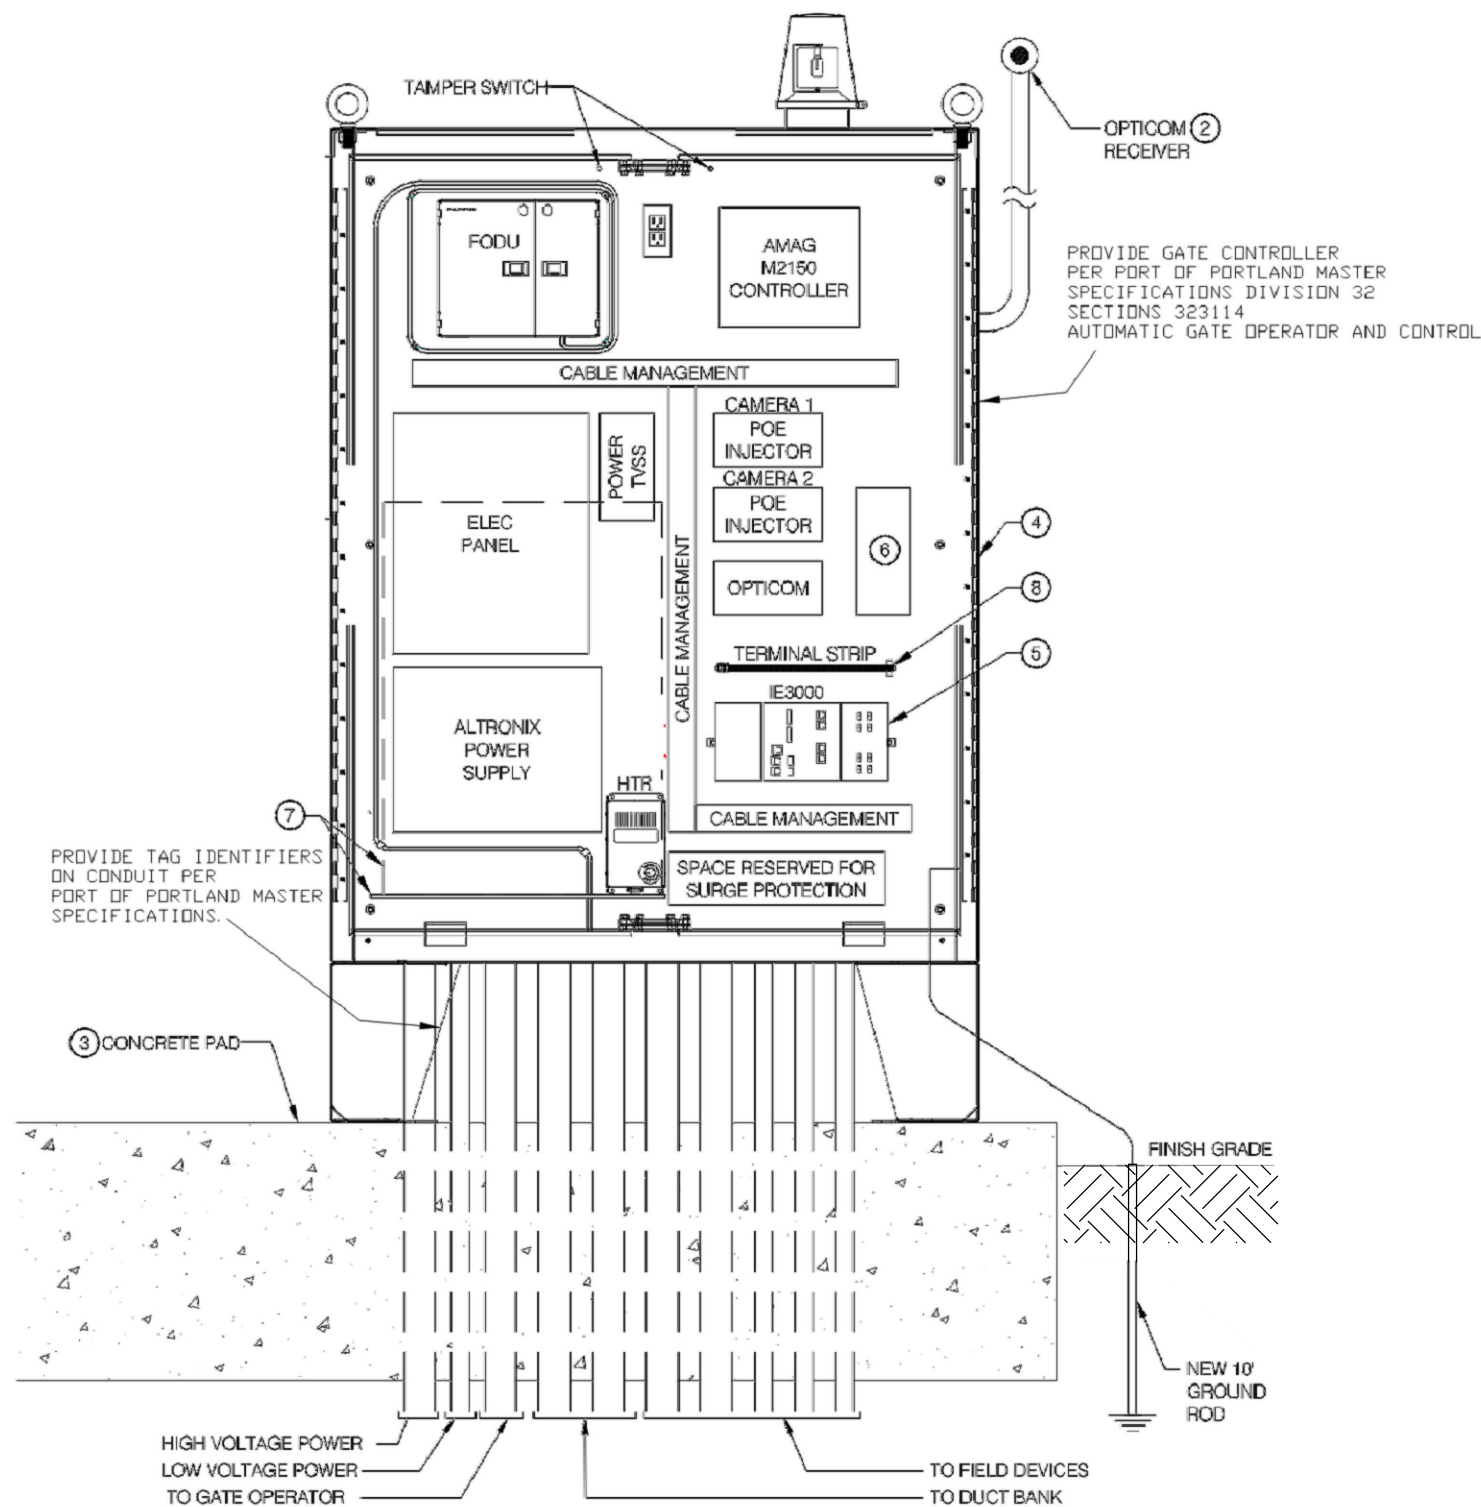

AOA CABINET KEYED NOTES:

1. N/A
2. OPTICOM RECEIVER MOUNTED ON 1-1/2" GRC, AS REQUIRED.
3. CONCRETE PAD.
4. NEMA 4 ENCLOSURE WITH HASP AND STAPLE FOR PORT PROVIDED PAD LOCK. PROVIDE WITH ENCLOSURE LABEL, GROUND BUS AND DATA POCKET.
5. OFCI CISCO IE3000 ETHERNET SWITCH, CONTRACTOR TO MOUNT ON CONTRACTOR PROVIDED DIN RAIL.
6. CAT 6 SURGE PROTECTOR(S). PROVIDE IAW 271000.
7. PROVIDE SHELF MOUNTED ON "L" BRACKETS AND UPS.
8. LOW VIS SYSTEM CONTROL RELAY.

ELEVATION

AOA CABINET
(NOT TO SCALE)

12/20/2023

no.	date	by	ckd	description
A	12/21/23	TSR	BAW	ISSUED FOR PERMIT

ISSUED FOR PERMIT
ONLY

**BURNS
MCDONNELL**

9400 WARD PARKWAY
KANSAS CITY, MO 64114
816-333-9400
Burns & McDonnell Engineering Co, Inc.

date	04/24/2023	detailed	S. JESBERG
designed	T. RENSHAW	checked	B. WINTER


PDX FUEL COMPANY L.L.C

PORTLAND INTERNATIONAL AIRPORT
5000 NE MARINE DR.
PORTLAND, OREGON 97218


PDX FACILITY IMPROVEMENTS
SECURITY DETAILS - 2

project	153929	contract	
drawing	TY502	rev.	A

file 153929TY502.dwg

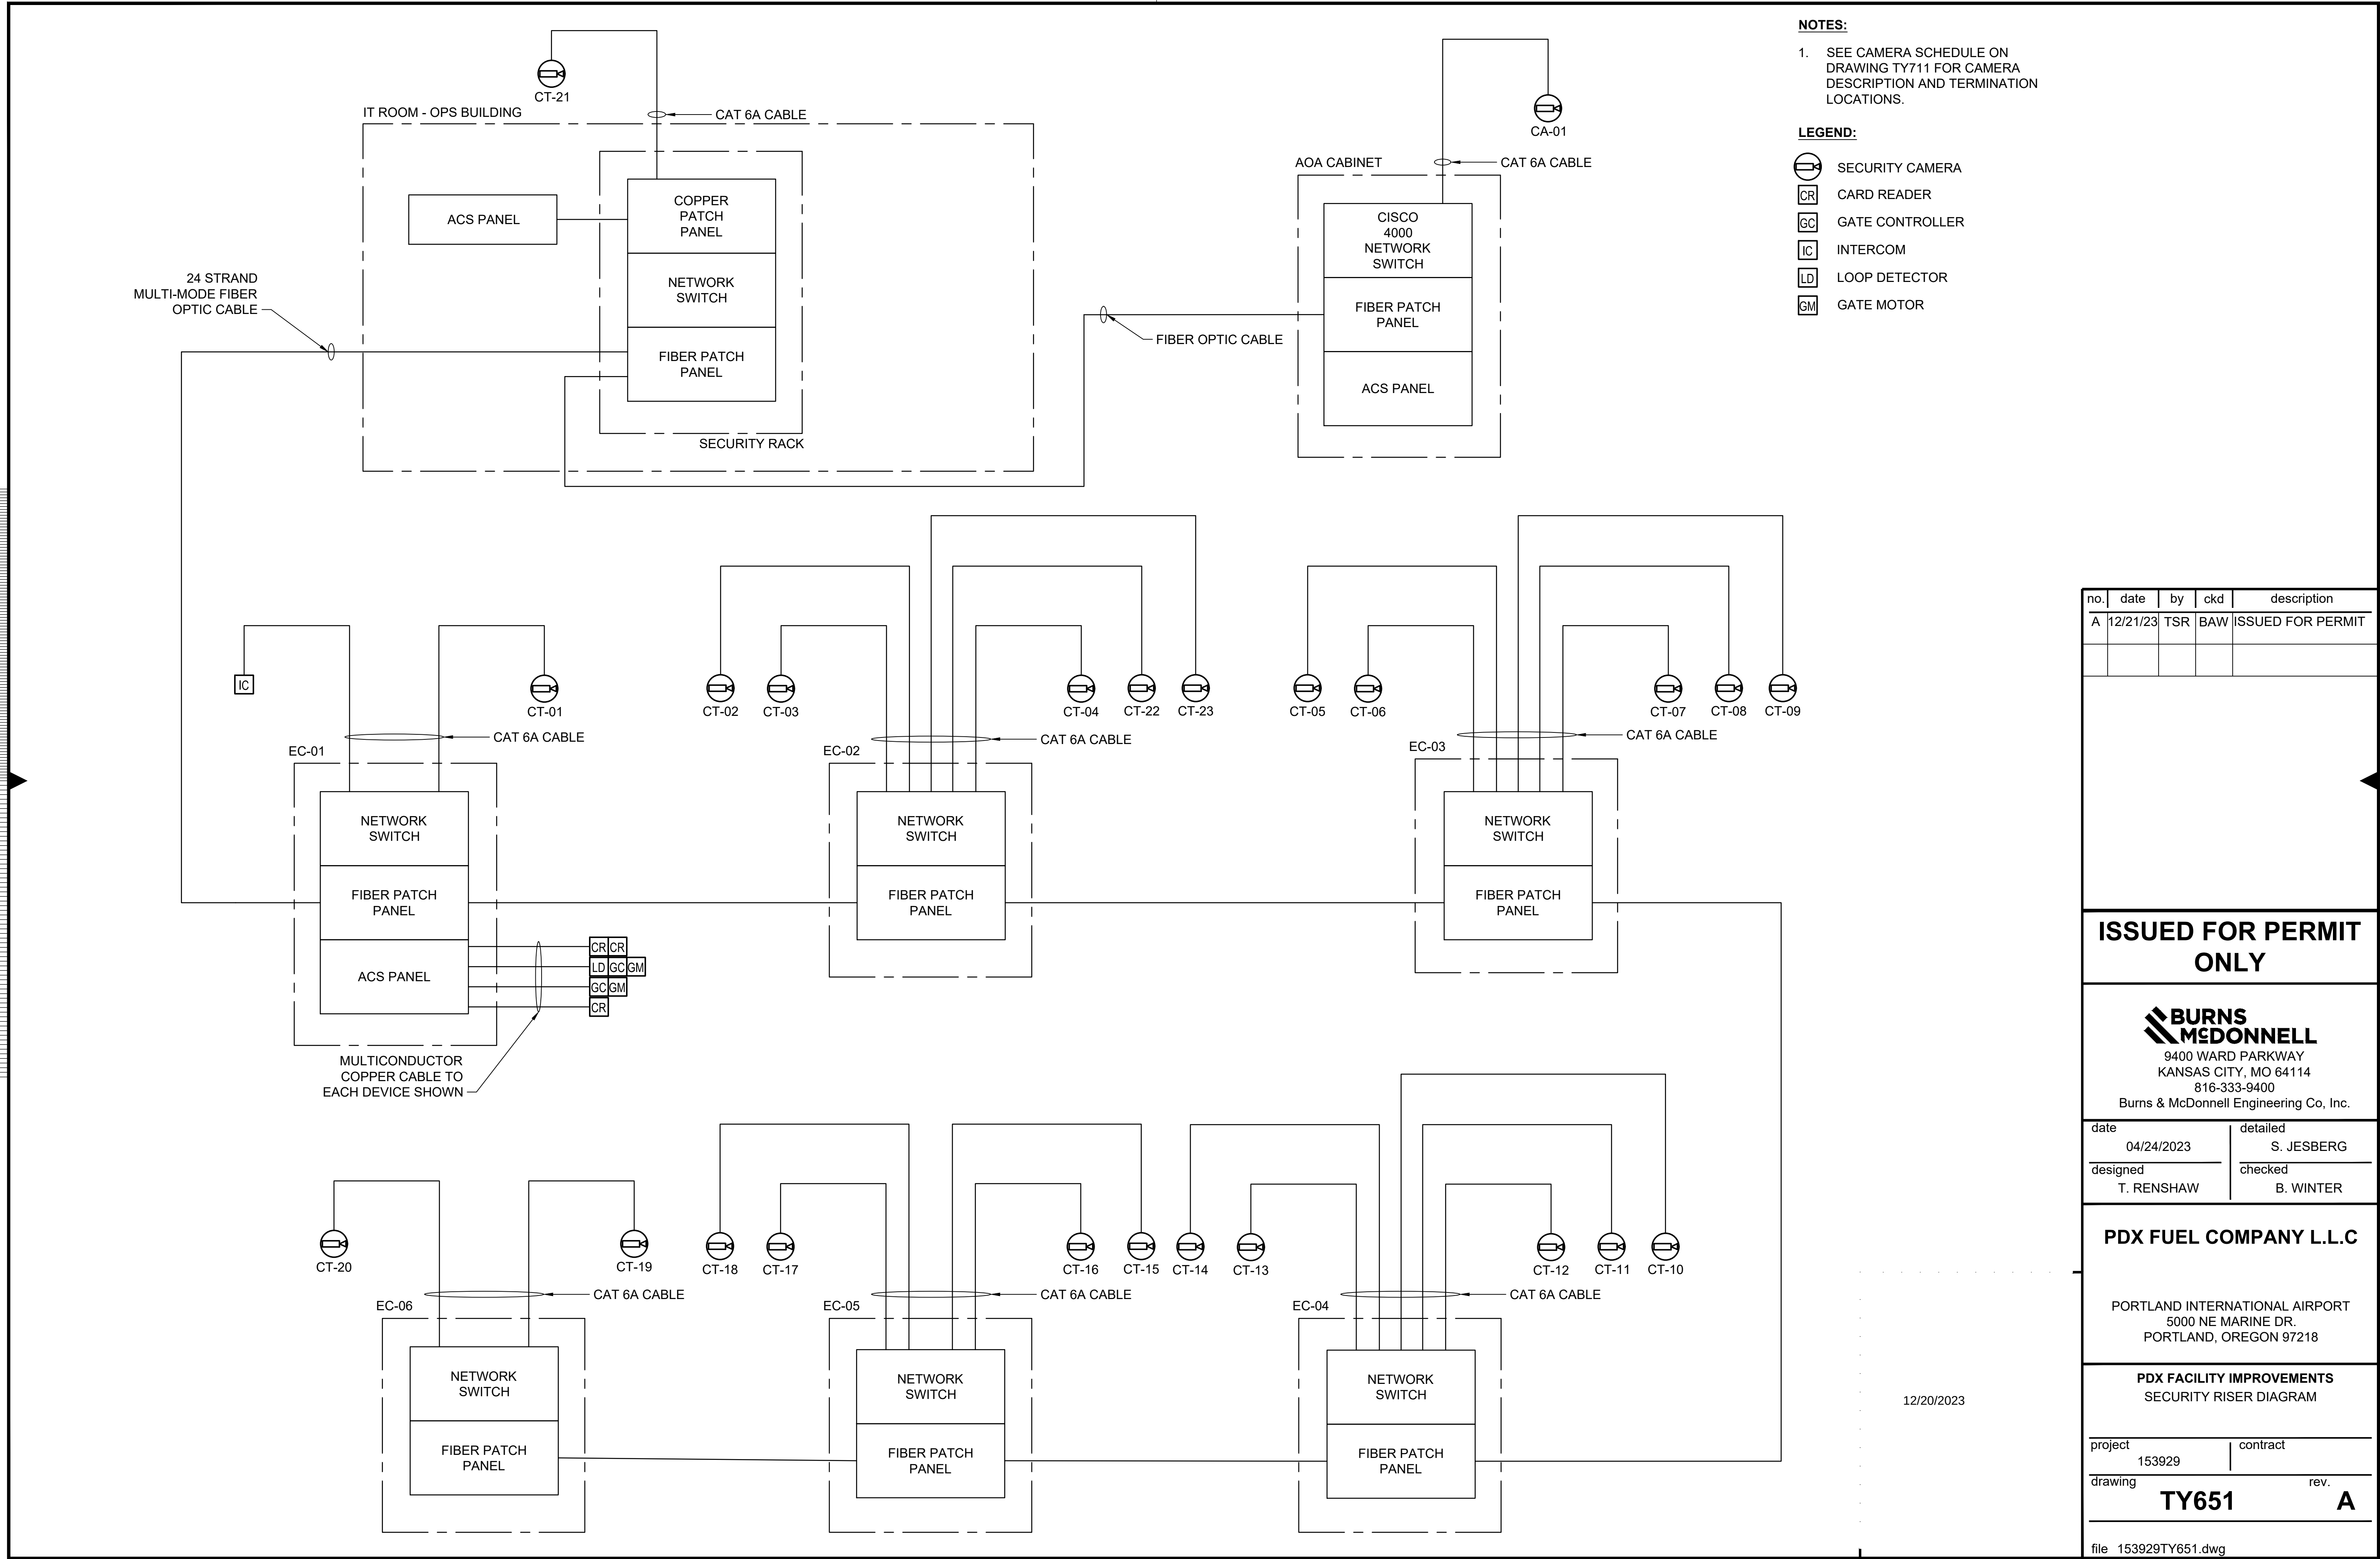

**ISSUED FOR PERMIT
ONLY**

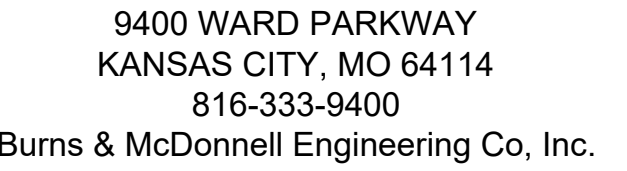


PDX FUEL COMPANY L.L.C

PORTLAND INTERNATIONAL AIRPORT
5000 NE MARINE DR.
PORTLAND, OREGON 97218

project	contract
153929	
drawing	rev.

TY651 **A**

file 153929TY651.dwg

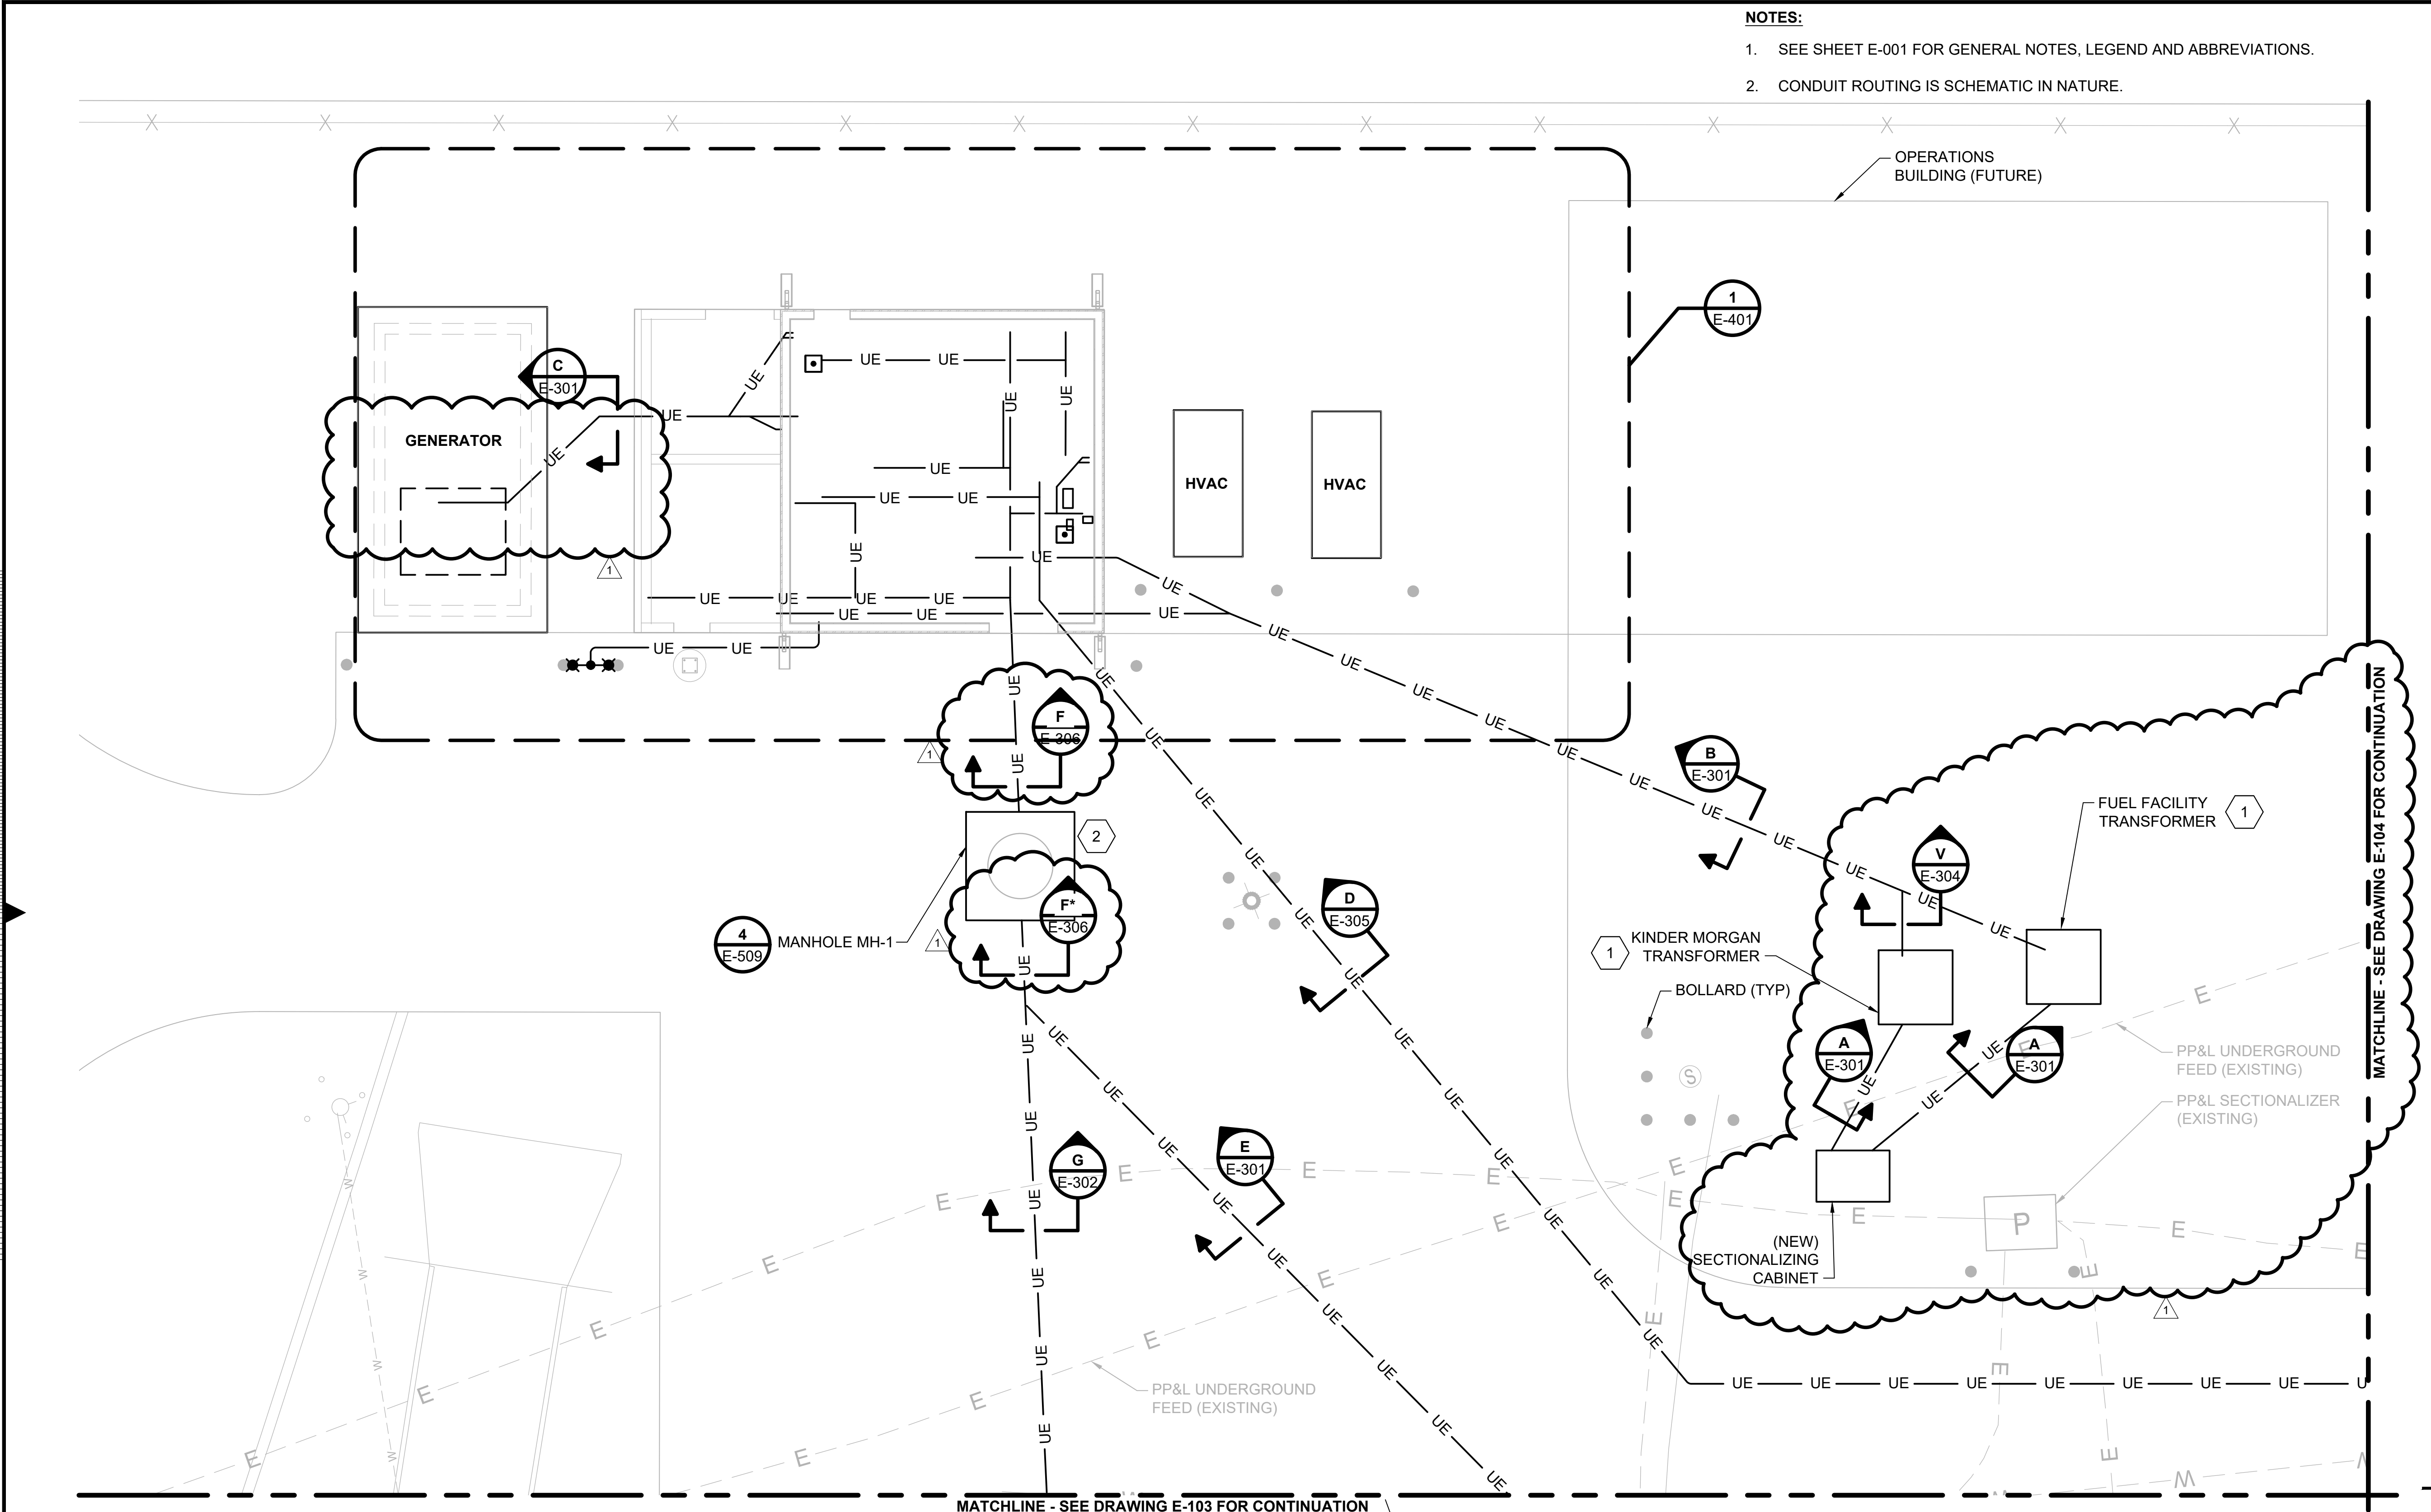


- NOTES:**
- 1. SEE SHEET E-001 FOR GENERAL NOTES, LEGEND AND ABBREVIATIONS.
 - 2. CONDUIT ROUTING IS SCHEMATIC IN NATURE.

- KEYED NOTES:**
- 1 TRANSFORMER, TRANSFORMER PAD, CONDUITS TO AND FROM TRANSFORMERS AND GROUNDING SHALL BE PROVIDED PER PP&L SPECIFICATION 6-17-122 (REVISION 3).SUBCONTRACTOR SHALL COORDINATE WITH PP&L FOR INSTALLATION COORDINATION.
 - 2 PROVIDE CONDUIT SEALS IN MANHOLE IN ACCORDANCE WITH THE NEC AND DETAIL 1 ON SHEET E-511.

OVERALL ELECTRICAL PLAN

0 4' 8' 16'

SCALE IN FEET

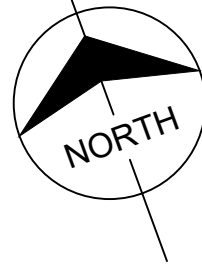

no.	date	by	ckd	description
0	11/13/20	TSR	TSR	ISSUED FOR CONSTRUCTION
1	10/11/22	TSR	TSR	ECN-001

date 10/11/2019	detailed L. HURST
designed E. WEIDEMAN	checked Y. KHISLAVSKIY
PORTLAND INTERNATIONAL AIRPORT 5000 NE MARINE DR. PORTLAND, OREGON 97218	
ELECTRICAL PLAN	
project	contract
drawing E-102	rev. 1
file 114425E-102.DWG	

CONDUIT SCHEDULE:


- 1. 2"C: (BY KINDER MORGAN)
- 2. 2"C: (BY KINDER MORGAN)
- 3. 2"C: (BY KINDER MORGAN)
- 4. 2"C: (BY KINDER MORGAN)
- 5. 2"C: (BY KINDER MORGAN)
- 6. 2"C: I.LT.WT
- 7. 2"C: C.LSH.500
- 8. 2"C: C.HS.TP2.2, C.FSC.SG
- 9. 2"C: C.FSC.SLTLSHH, C.FSC.SLTLA
- 10. 3/4"C: C.EFSO.T3EX
- 11. 2"C: (BY KINDER MORGAN)
- 12. 3/4"C: C.EFSO.T12EX
- 13. 2"C: IC.FSC.TEMP
- 14. 2"C: IC.FSC.AFS
- 15. 2"C: C.FSC.LABLSH
- 16. 2"C: C.FSC.KM, C.EFSO.AIRSIDE

NOTES:



171. 1"SEE PNL8 E-001 FOR GENERAL NOTES, LEGEND AND ABBREVIATIONS.

KEYED NOTE:

- 1 TIE IN P.MCC1.PP1 INTO EXISTING 480 VOLT PANEL LOCATED IN FUEL LAB.
- 2 TIE IN P.PNL6.8 INTO RELOCATED AIR COMPRESSOR LOCATED IN MAINTENANCE BAY.

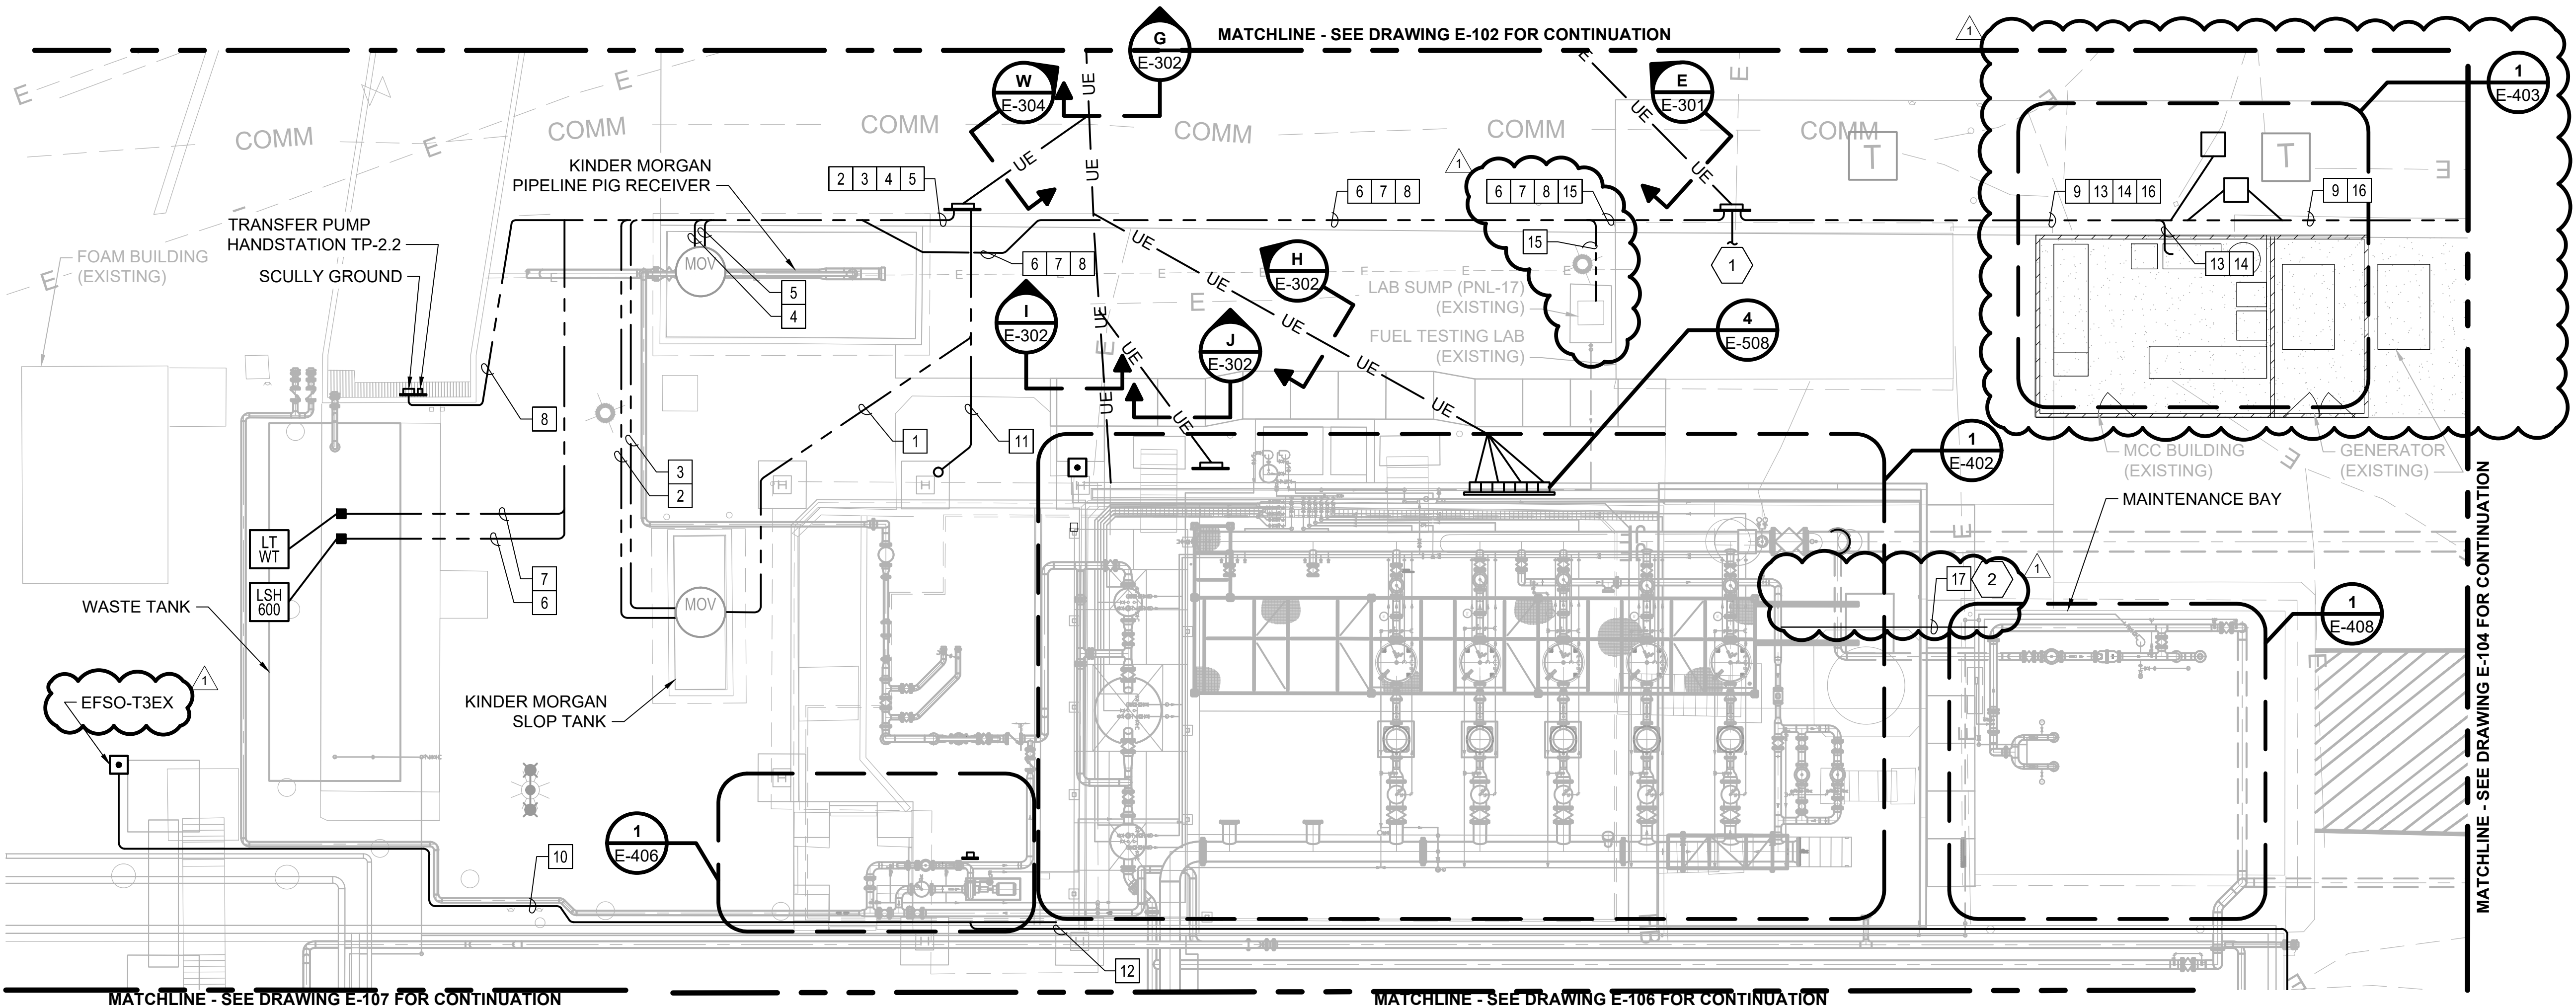

ELECTRICAL PLAN

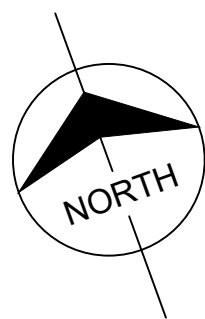 

no.	date	by	ckd	description
0	11/13/20	TSR	TSR	ISSUED FOR CONSTRUCTION
1	10/11/22	TSR	TSR	ECN-001




date 10/11/2019	detailed L. HURST
designed E. WEIDEMAN	checked Y. KHISLAVSKIY

PORTLAND INTERNATIONAL AIRPORT
5000 NE MARINE DR.
PORTLAND, OREGON 97218

ELECTRICAL PLAN

project	contract
drawing E-103	rev. 1
file 114425E-103.DWG	

REFERENCE DRAWING

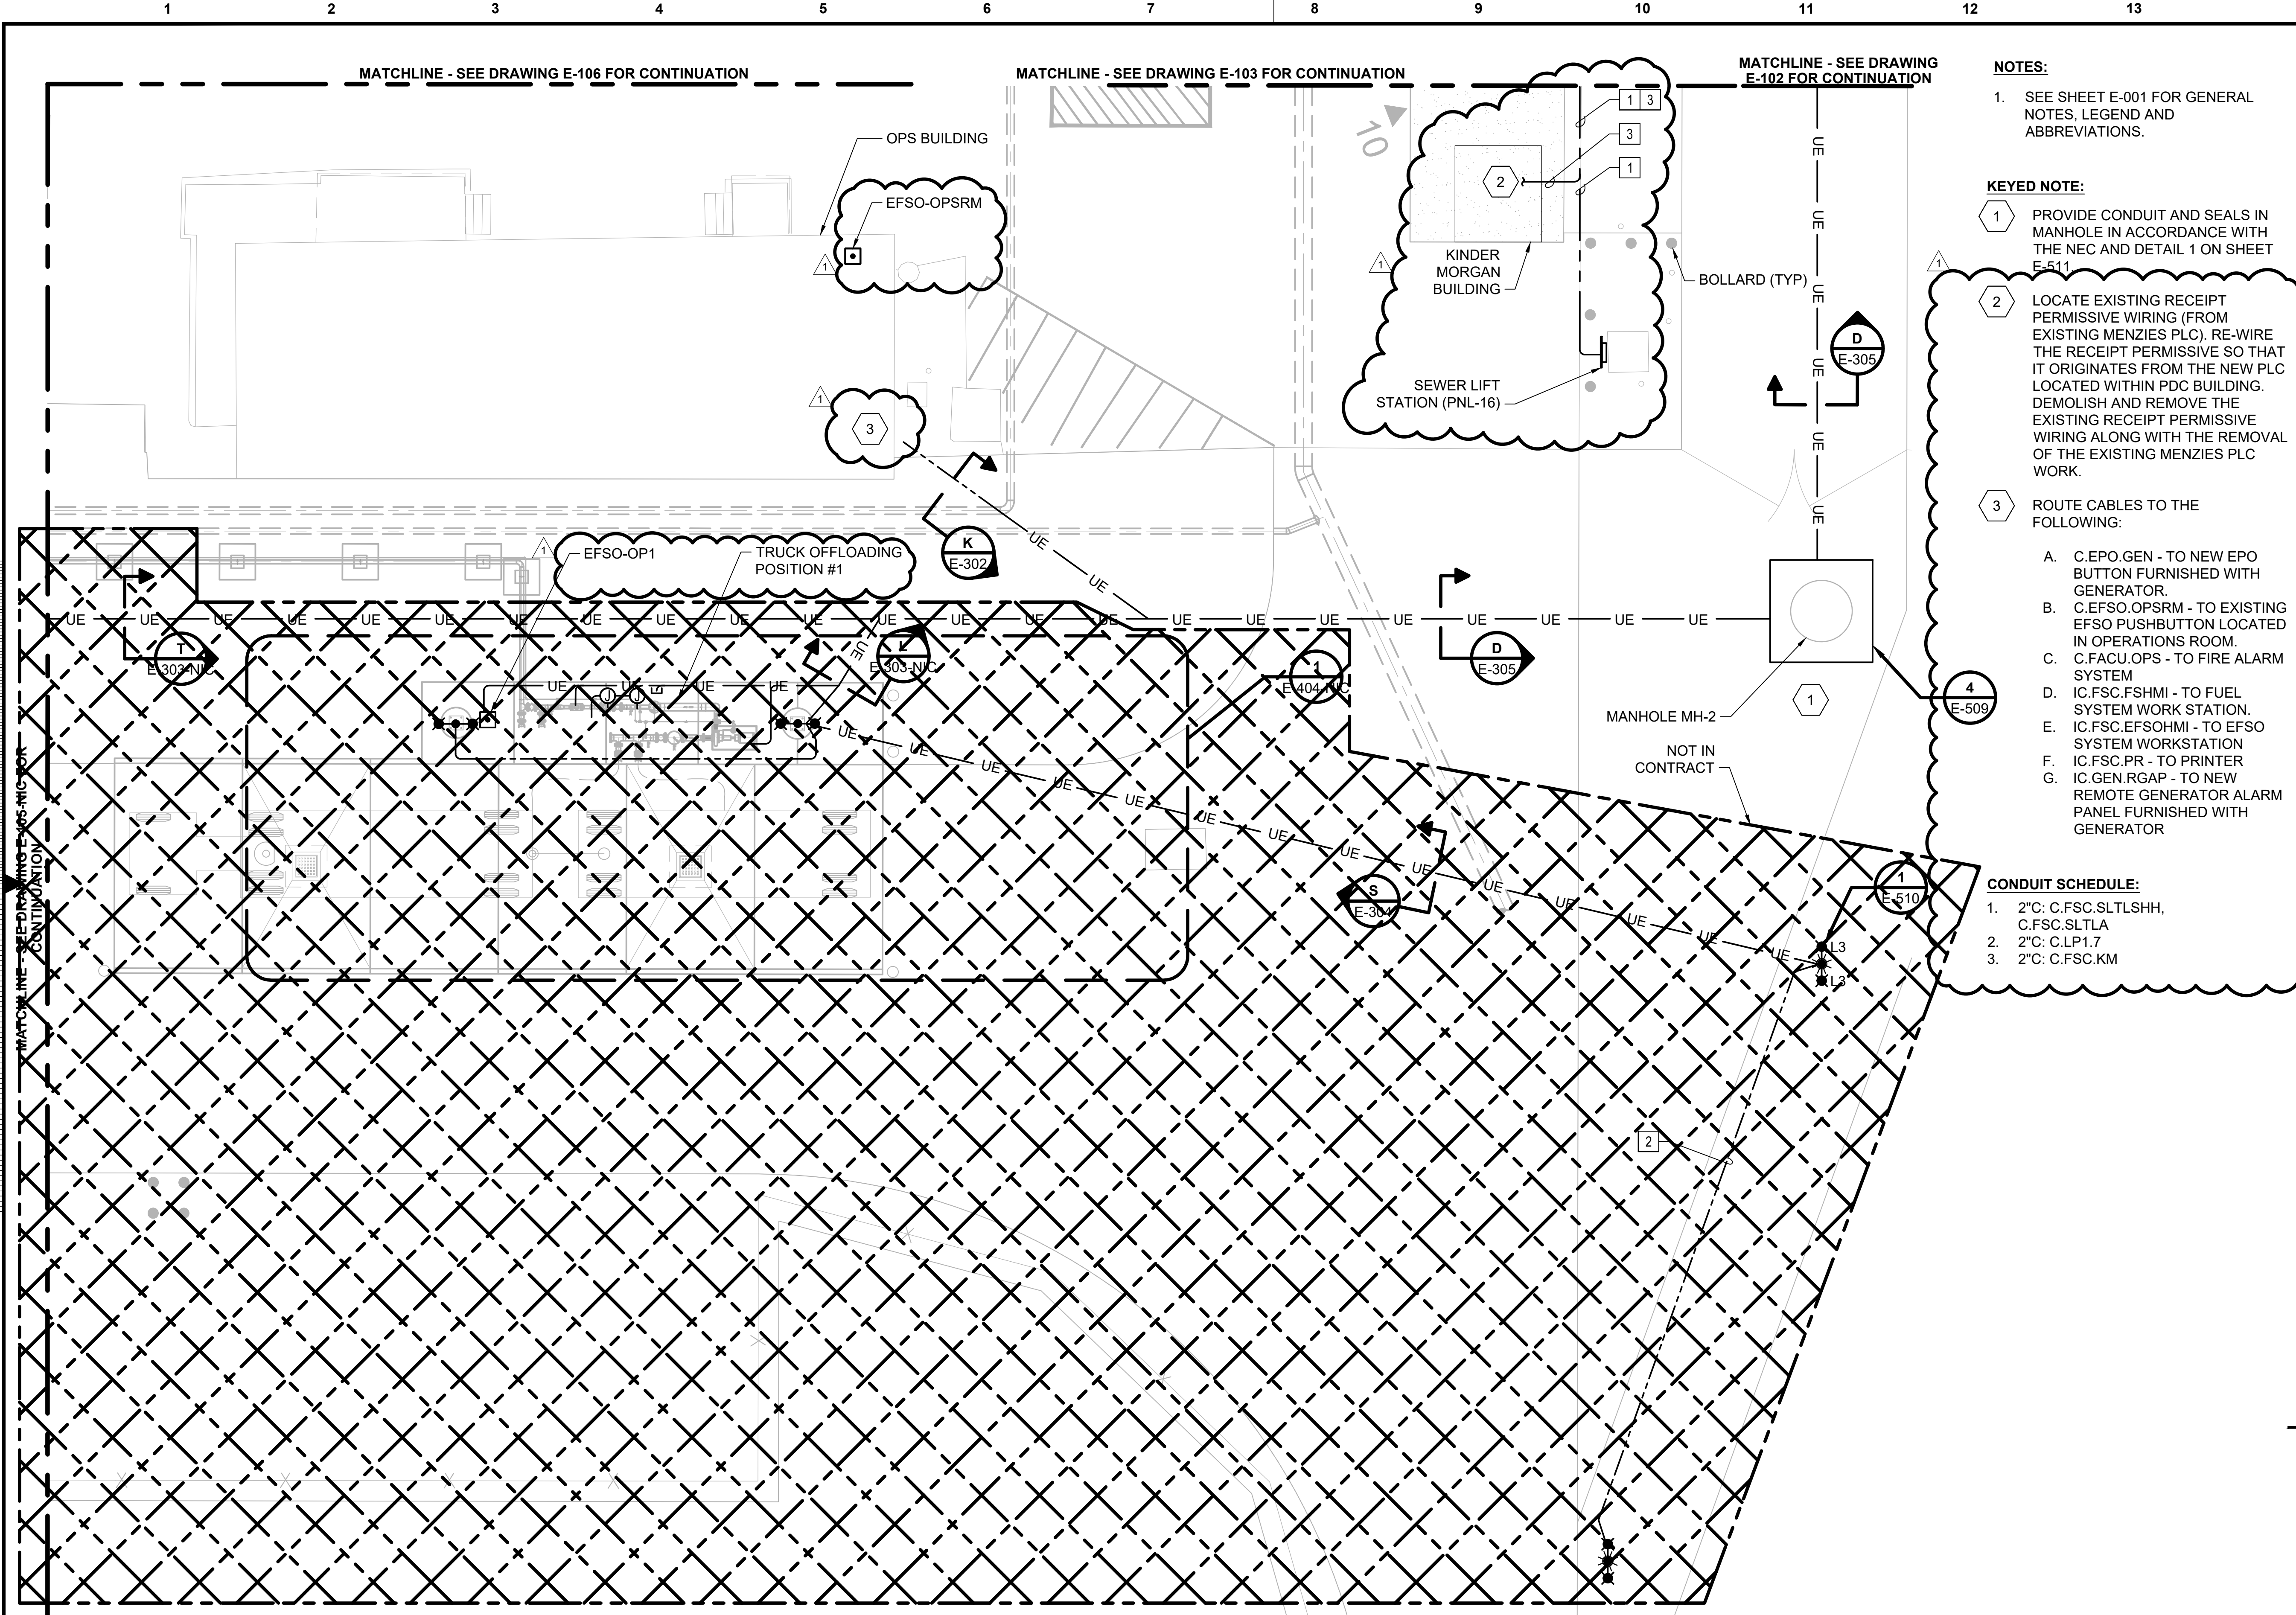

- NOTES:**
- SEE SHEET E-001 FOR GENERAL NOTES, LEGEND AND ABBREVIATIONS.
- KEYED NOTE:**
- PROVIDE CONDUIT AND SEALS IN MANHOLE IN ACCORDANCE WITH THE NEC AND DETAIL 1 ON SHEET E-511.
 - LOCATE EXISTING RECEIPT PERMISSIVE WIRING (FROM EXISTING MENZIES PLC). RE-WIRE THE RECEIPT PERMISSIVE SO THAT IT ORIGINATES FROM THE NEW PLC LOCATED WITHIN PDC BUILDING. DEMOLISH AND REMOVE THE EXISTING RECEIPT PERMISSIVE WIRING ALONG WITH THE REMOVAL OF THE EXISTING MENZIES PLC WORK.
 - ROUTE CABLES TO THE FOLLOWING:
 - A. C.EPO.GEN - TO NEW EPO BUTTON FURNISHED WITH GENERATOR.
 - B. C.EFSO.OPSRM - TO EXISTING EFSO PUSHBUTTON LOCATED IN OPERATIONS ROOM.
 - C. C.FACU.OPS - TO FIRE ALARM SYSTEM
 - D. IC.FSC.FSHMI - TO FUEL SYSTEM WORK STATION.
 - E. IC.FSC.EFSOHMI - TO EFSO SYSTEM WORKSTATION
 - F. IC.FSC.PR - TO PRINTER
 - G. IC.GEN.RGAP - TO NEW REMOTE GENERATOR ALARM PANEL FURNISHED WITH GENERATOR
 -
- CONDUIT SCHEDULE:**
- 2"C: C.FSC.SLTLSHH, C.FSC.SLTLA
 - 2"C: C.LP1.7
 - 2"C: C.FSC.KM

no.	date	by	ckd	description
0	11/13/20	TSR	TSR	ISSUED FOR CONSTRUCTION
1	10/11/22	TSR	TSR	ECN-001




date	10/11/2019	detailed	L. HURST
designed	E. WEIDEMAN	checked	Y. KHISLAVSKIY

PORTLAND INTERNATIONAL AIRPORT
5000 NE MARINE DR.
PORTLAND, OREGON 97218

ELECTRICAL PLAN

project	contract
drawing	rev.
E-104	1
file 114425E-104.DWG	

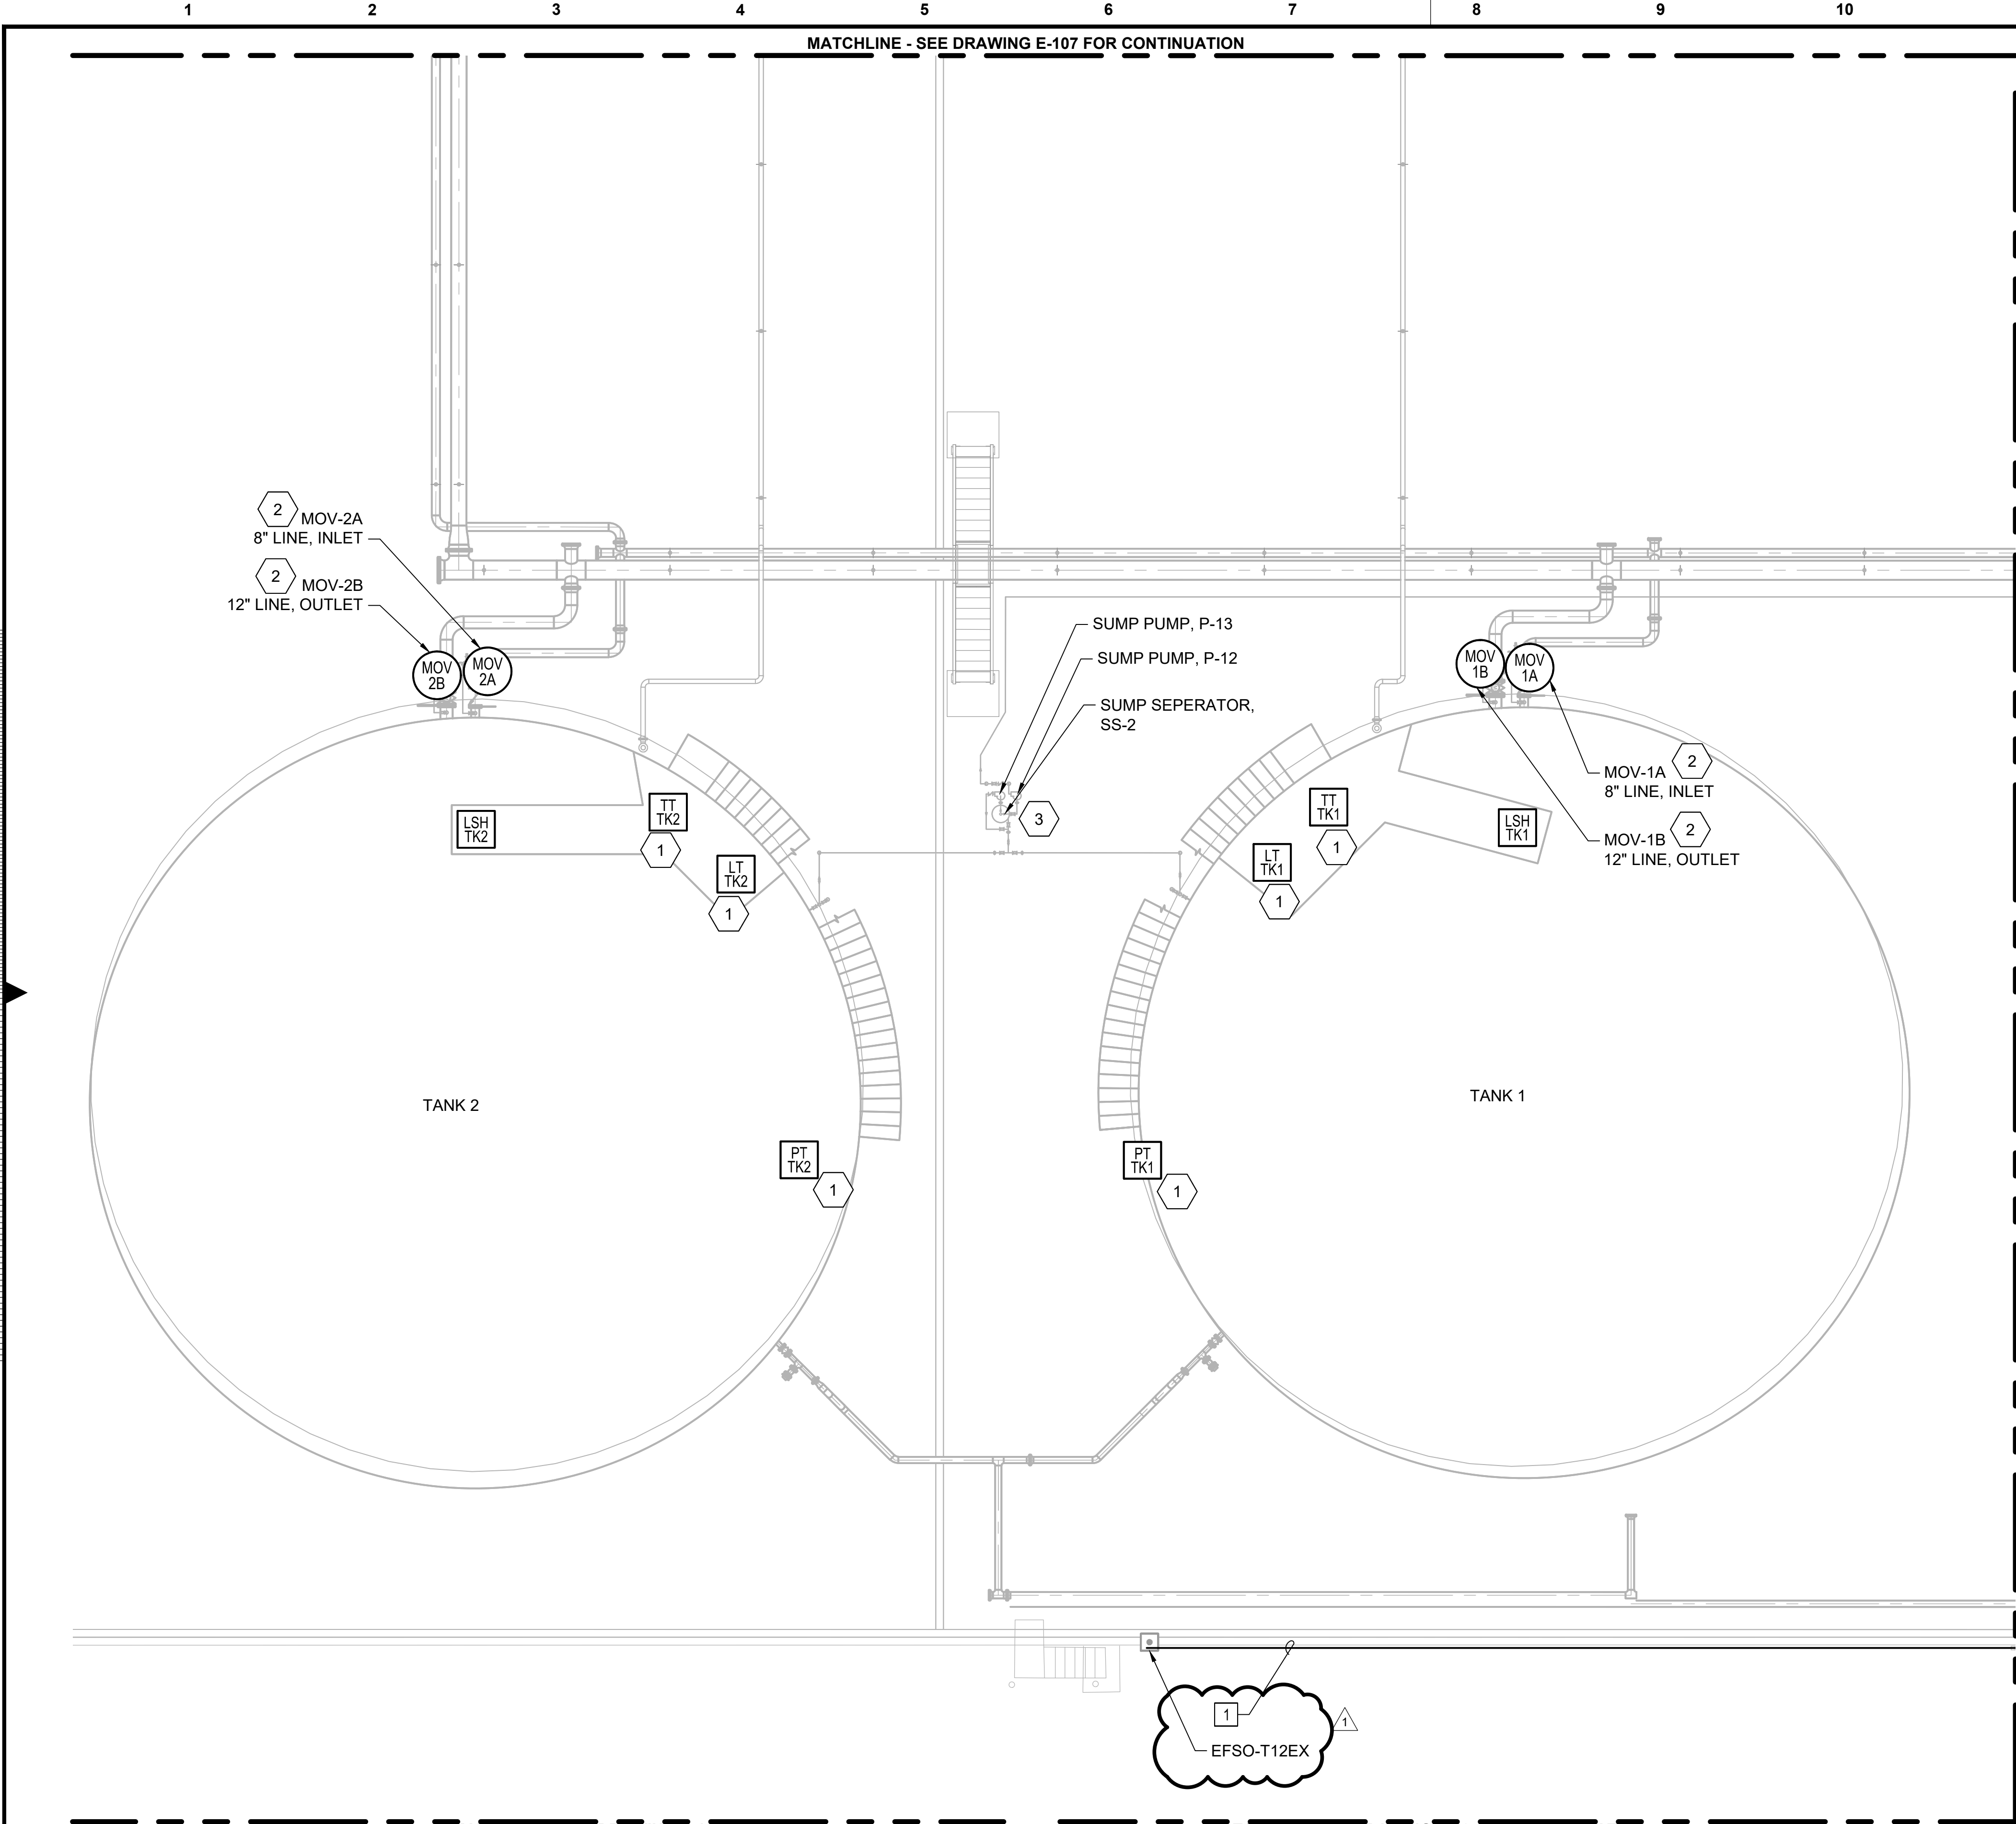

- NOTES:**
- SEE SHEET E-001 FOR GENERAL NOTES, LEGEND AND ABBREVIATIONS.
 - ALL CONDUCTORS ROUTED IN THE TANK FARM SHALL UTILIZE EXISTING CONDUIT UNLESS OTHERWISE NOTED.

- KEYED NOTES:**
- TANK INSTRUMENTS ARE CURRENTLY CONNECTED TO WIRELESS TRANSMITTER AT EACH TANK WHICH COMMUNICATES TO A WIRELESS GATEWAY AT THE KINDER MORGAN CANOPY. PROVIDE POWER CIRCUIT TO EACH TANK TO POWER INSTRUMENTS AND WIRELESS COMMUNICATION SYSTEM. ALL OTHER WIRING IS EXISTING AND SHALL REMAIN IN PLACE.
 - PROVIDE POWER AND CONTROL CIRCUITS TO EACH MOV. MOV'S ARE EXISTING AND SHALL REMAIN IN PLACE.
 - SUMP SEPARATOR IS POWERED FROM ELECTRICAL INFRASTRUCTURE THAT SHALL REMAIN IN PLACE DURING CONSTRUCTION. NO MODIFICATIONS ARE REQUIRED.

CONDUIT SCHEDULE:
1. 3/4"C: C.EFSO.T12EX

no.	date	by	ckd	description
0	11/13/20	TSR	TSR	ISSUED FOR CONSTRUCTION
1	10/11/22	TSR	TSR	ECN-001



date 10/11/2019	detailed L. HURST
designed E. WEIDEMAN	checked Y. KHISLAVSKIY

PORTLAND INTERNATIONAL AIRPORT
5000 NE MARINE DR.
PORTLAND, OREGON 97218

ELECTRICAL PLAN	
project	contract
drawing E-106	rev. 1
file 114425E-106.DWG	

REFERENCE DRAWING

1 2 3 4 5 6 7 8 9 10 11 12 13


NOTES:

1. SEE SHEET E-001 FOR GENERAL NOTES, LEGEND AND ABBREVIATIONS.

KEYED NOTES:


1 CONNECT NEW GROUND GRID TO EXISTING GRID AT THE FENCE.

no.	date	by	ckd	description
0	11/13/20	DSW	TBR	ISSUED FOR CONSTRUCTION
1	10/11/22	DSW	CSB	ECN-001

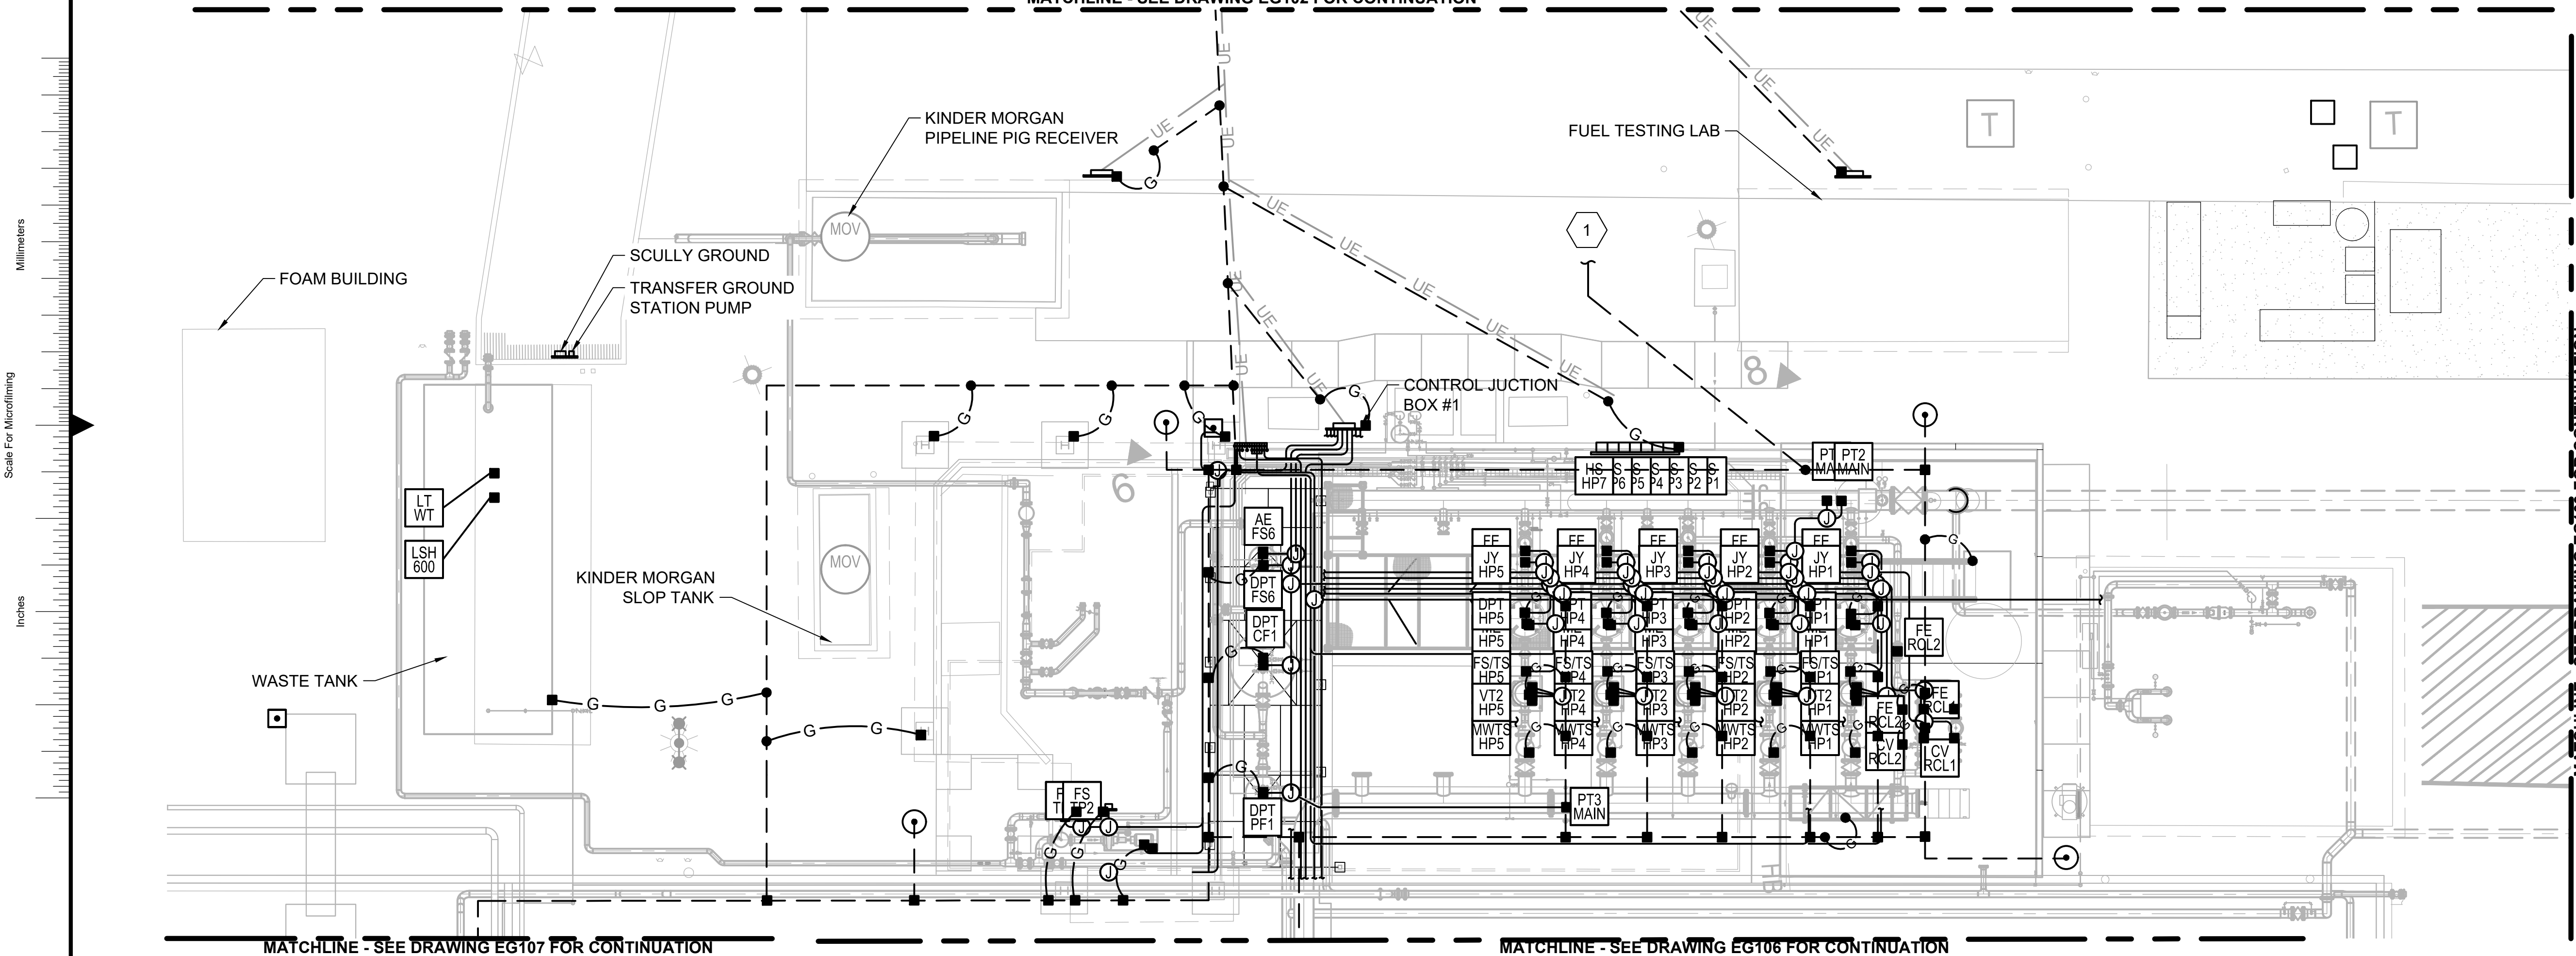

GROUNDING PLAN

0 4' 8' 16'
SCALE IN FEET

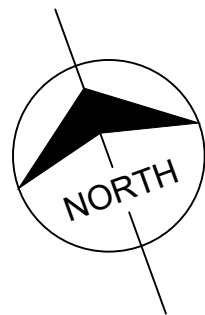


date 10/11/2019	detailed L. HURST
designed E. WEIDEMAN	checked Y. KHISLAVSKIY

PORTLAND INTERNATIONAL AIRPORT
5000 NE MARINE DR.
PORTLAND, OREGON 97218

GROUNDING PLAN

project	contract
drawing EG103	rev. 1
file 114425EG103.DWG	

REFERENCE DRAWING

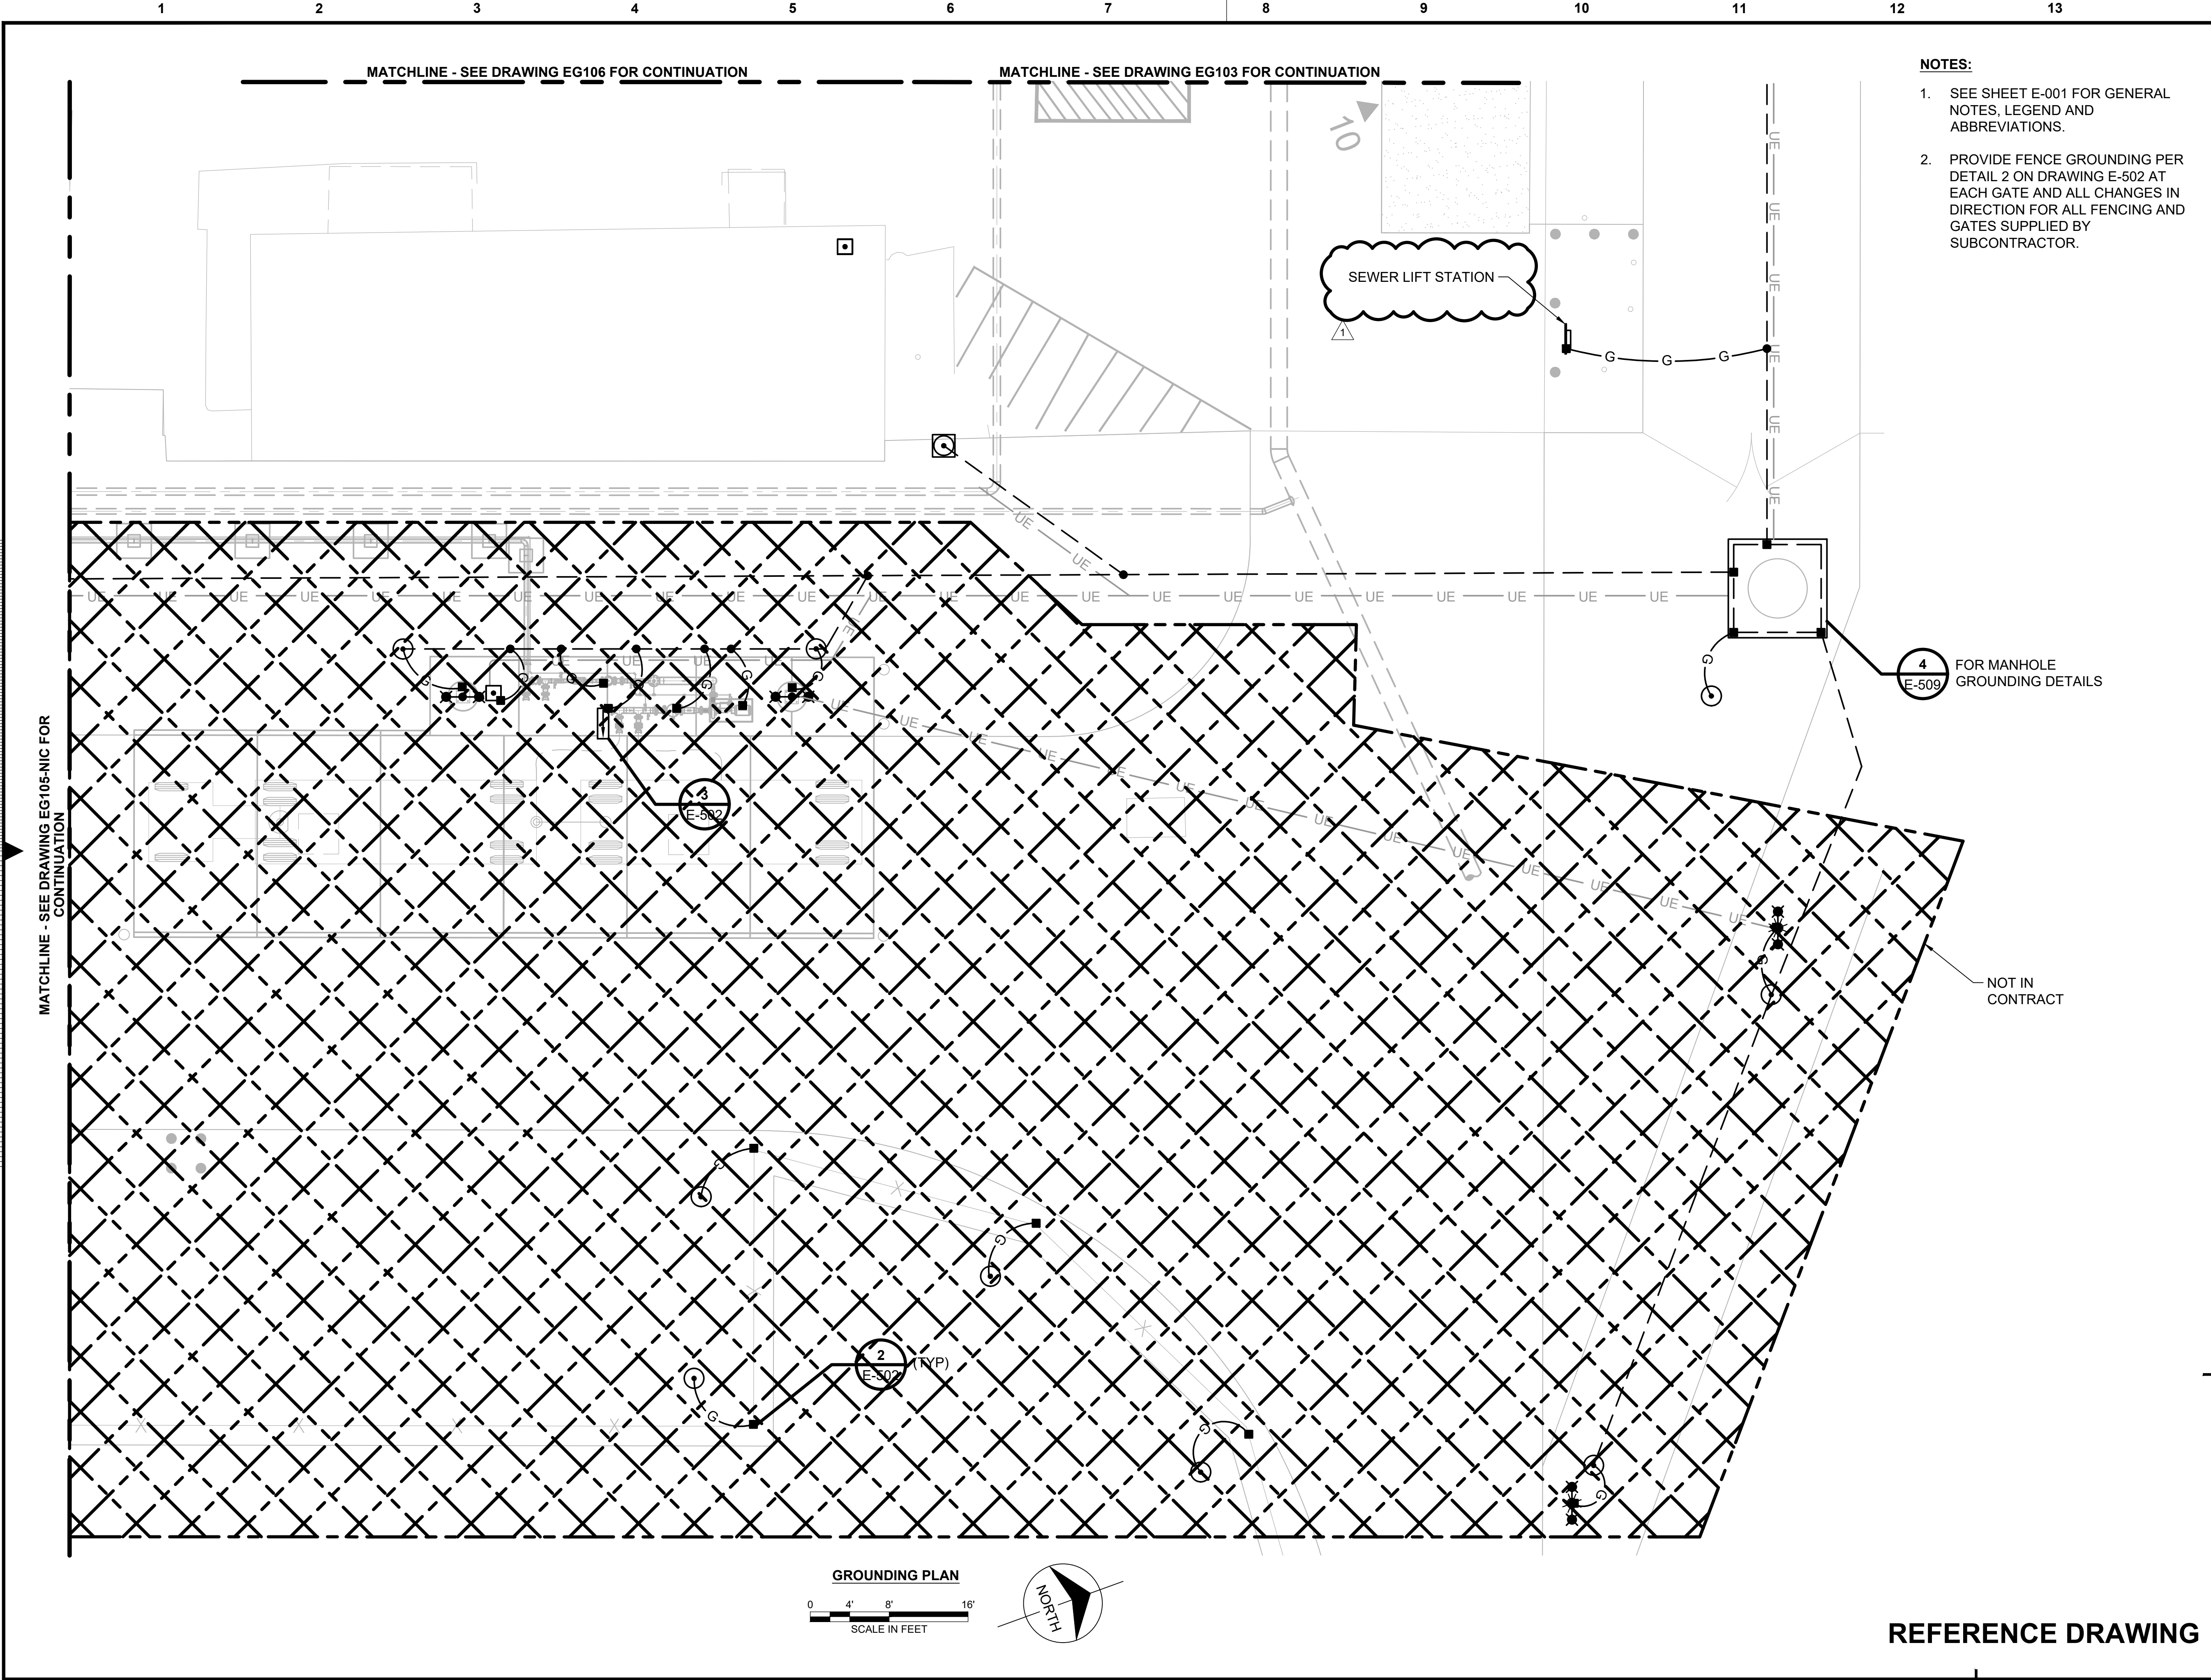

- NOTES:**
- SEE SHEET E-001 FOR GENERAL NOTES, LEGEND AND ABBREVIATIONS.
 - PROVIDE FENCE GROUNDING PER DETAIL 2 ON DRAWING E-502 AT EACH GATE AND ALL CHANGES IN DIRECTION FOR ALL FENCING AND GATES SUPPLIED BY SUBCONTRACTOR.

no.	date	by	ckd	description
0	11/13/20	DSW	TBR	ISSUED FOR CONSTRUCTION
1	10/11/22	DSW	CSB	ECN-001




date	10/11/2019	detailed	L. HURST
designed	E. WEIDEMAN	checked	Y. KHISLAVSKIY

PORTLAND INTERNATIONAL AIRPORT
5000 NE MARINE DR.
PORTLAND, OREGON 97218

GROUNDING PLAN

project	contract
drawing	rev.
EG104	1
file 114425EG104.DWG	

REFERENCE DRAWING

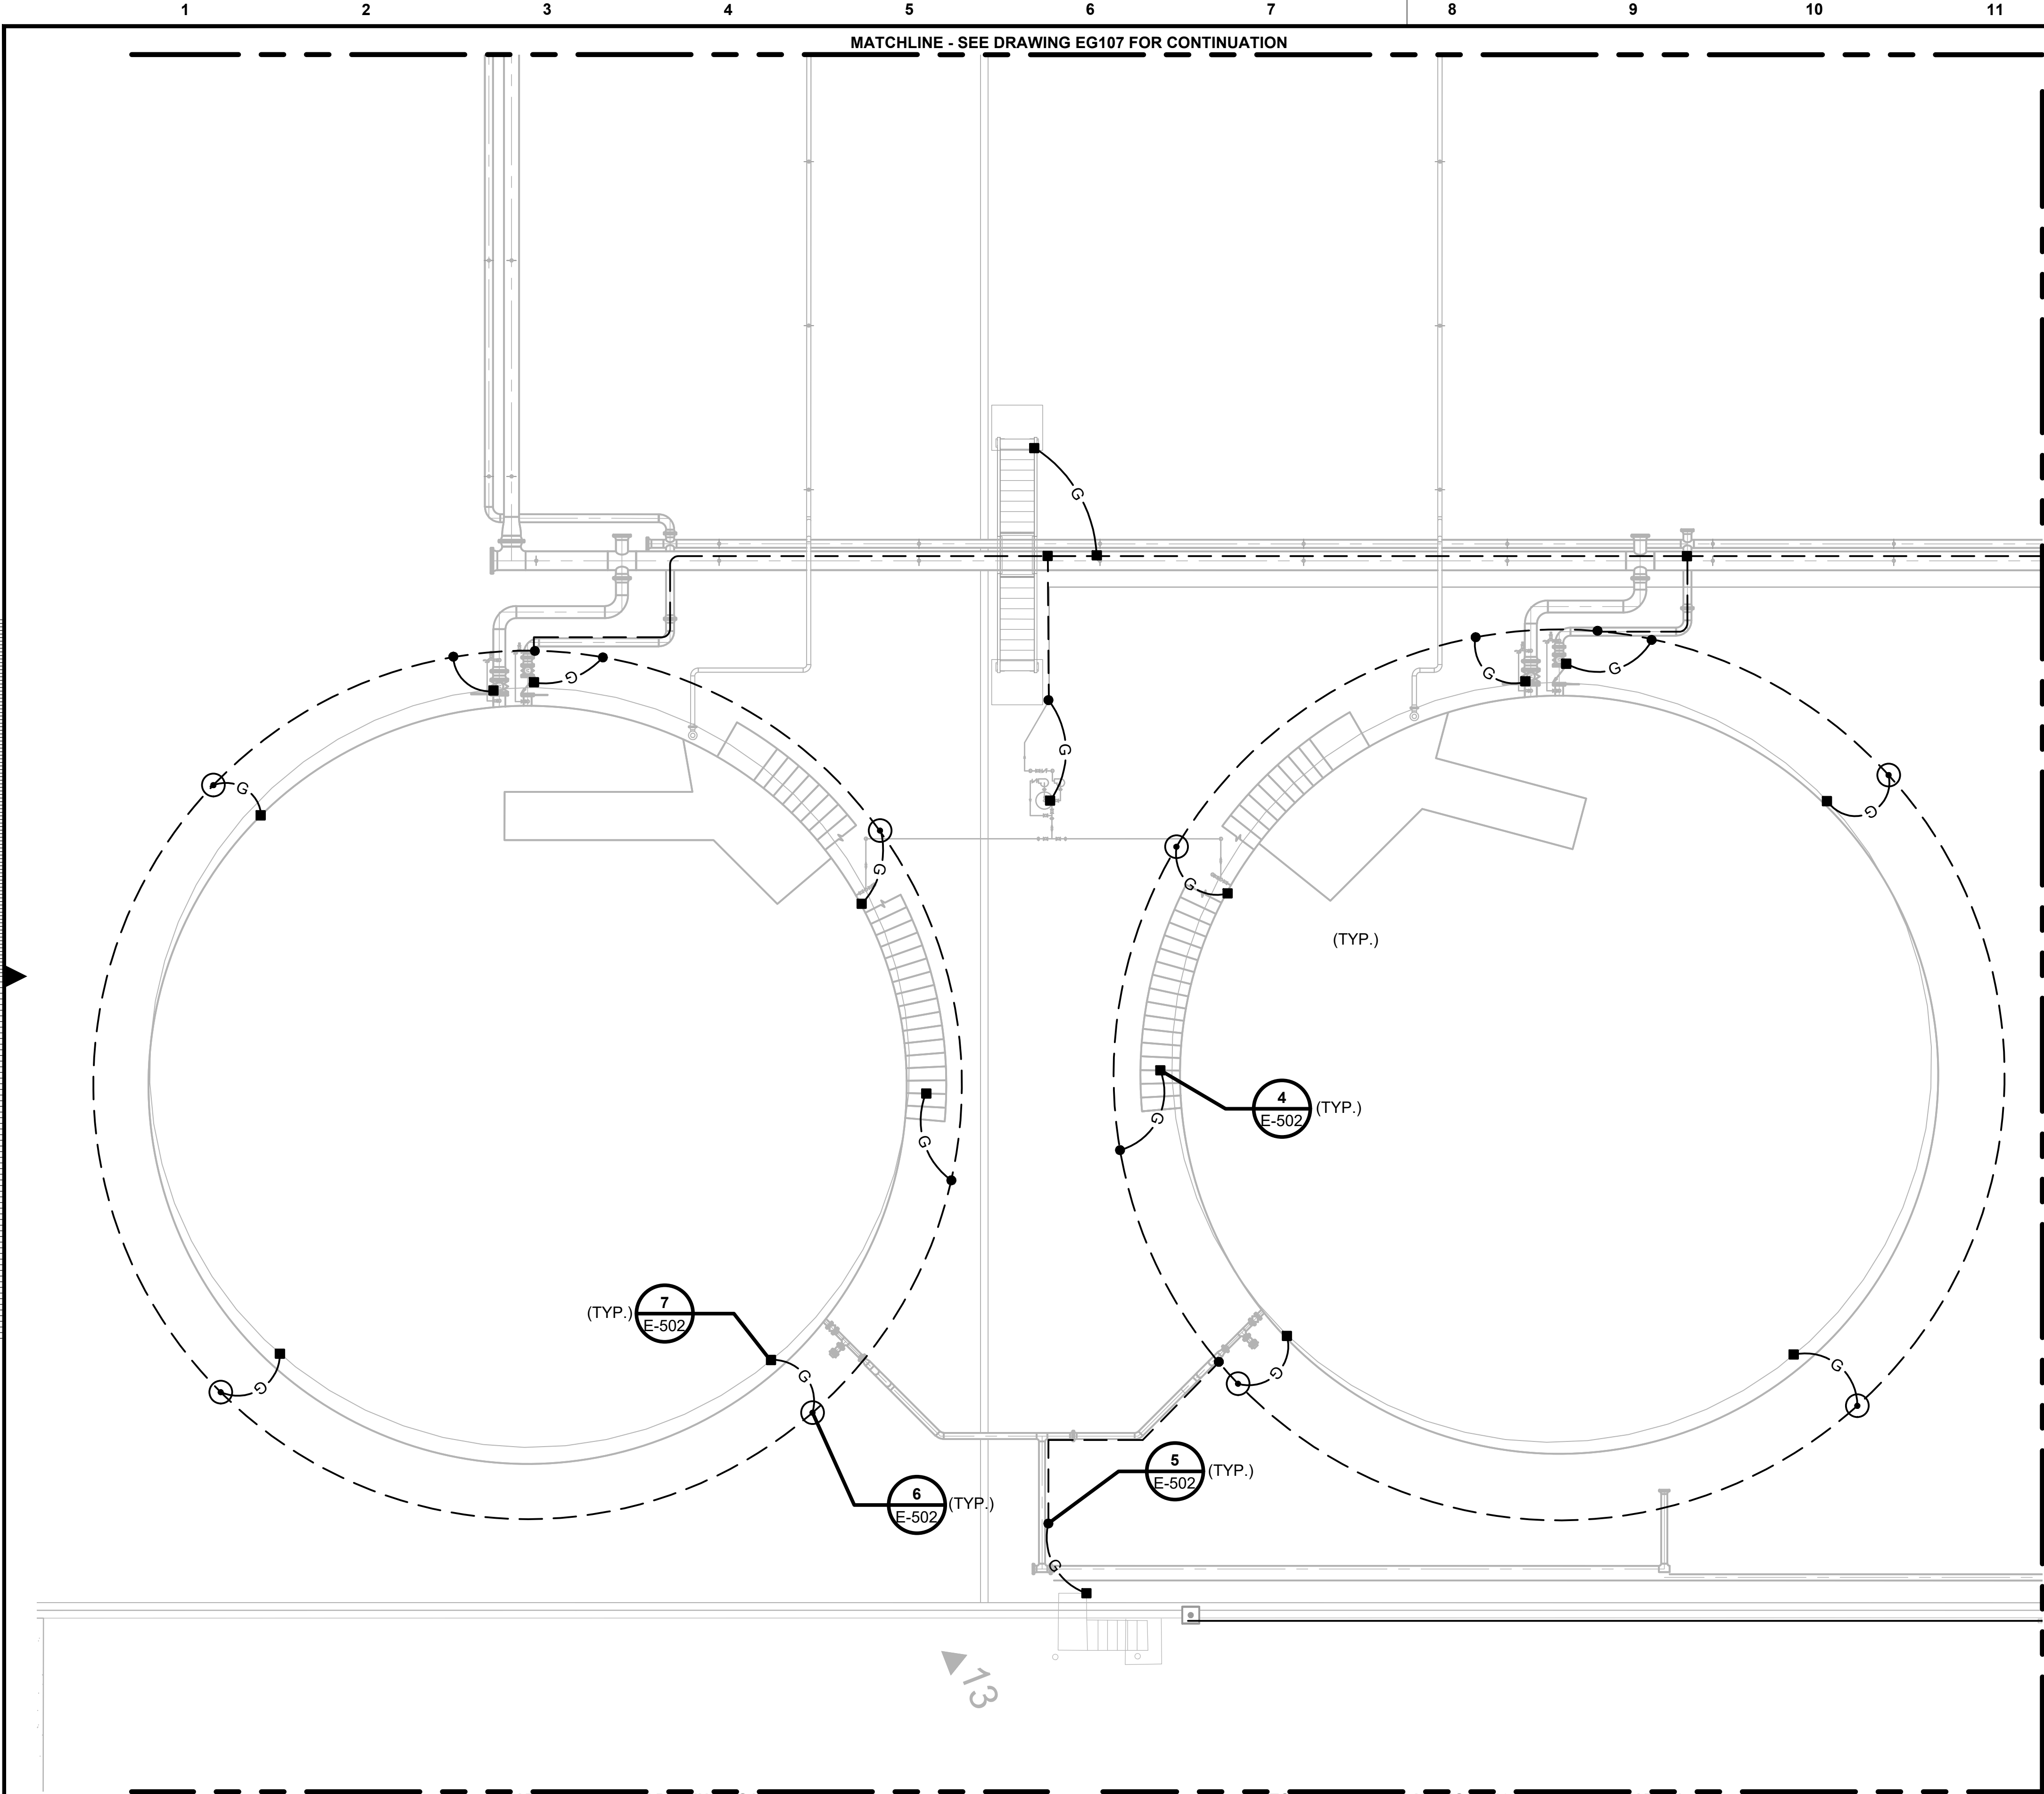

NOTES:

1. SEE SHEET E-001 FOR GENERAL NOTES, LEGEND AND ABBREVIATIONS.

no.	date	by	ckd	description
0	11/13/20	DSW	TBR	ISSUED FOR CONSTRUCTION
1	10/11/22	DSW	CSB	ECN-001




date 10/11/2019	detailed L. HURST
designed E. WEIDEMAN	checked Y. KHISLAVSKIY



PORTLAND INTERNATIONAL AIRPORT
5000 NE MARINE DR.
PORTLAND, OREGON 97218

GROUNDING PLAN

project	contract
drawing EG106	rev. 1
file 114425EG106.DWG	

REFERENCE DRAWING

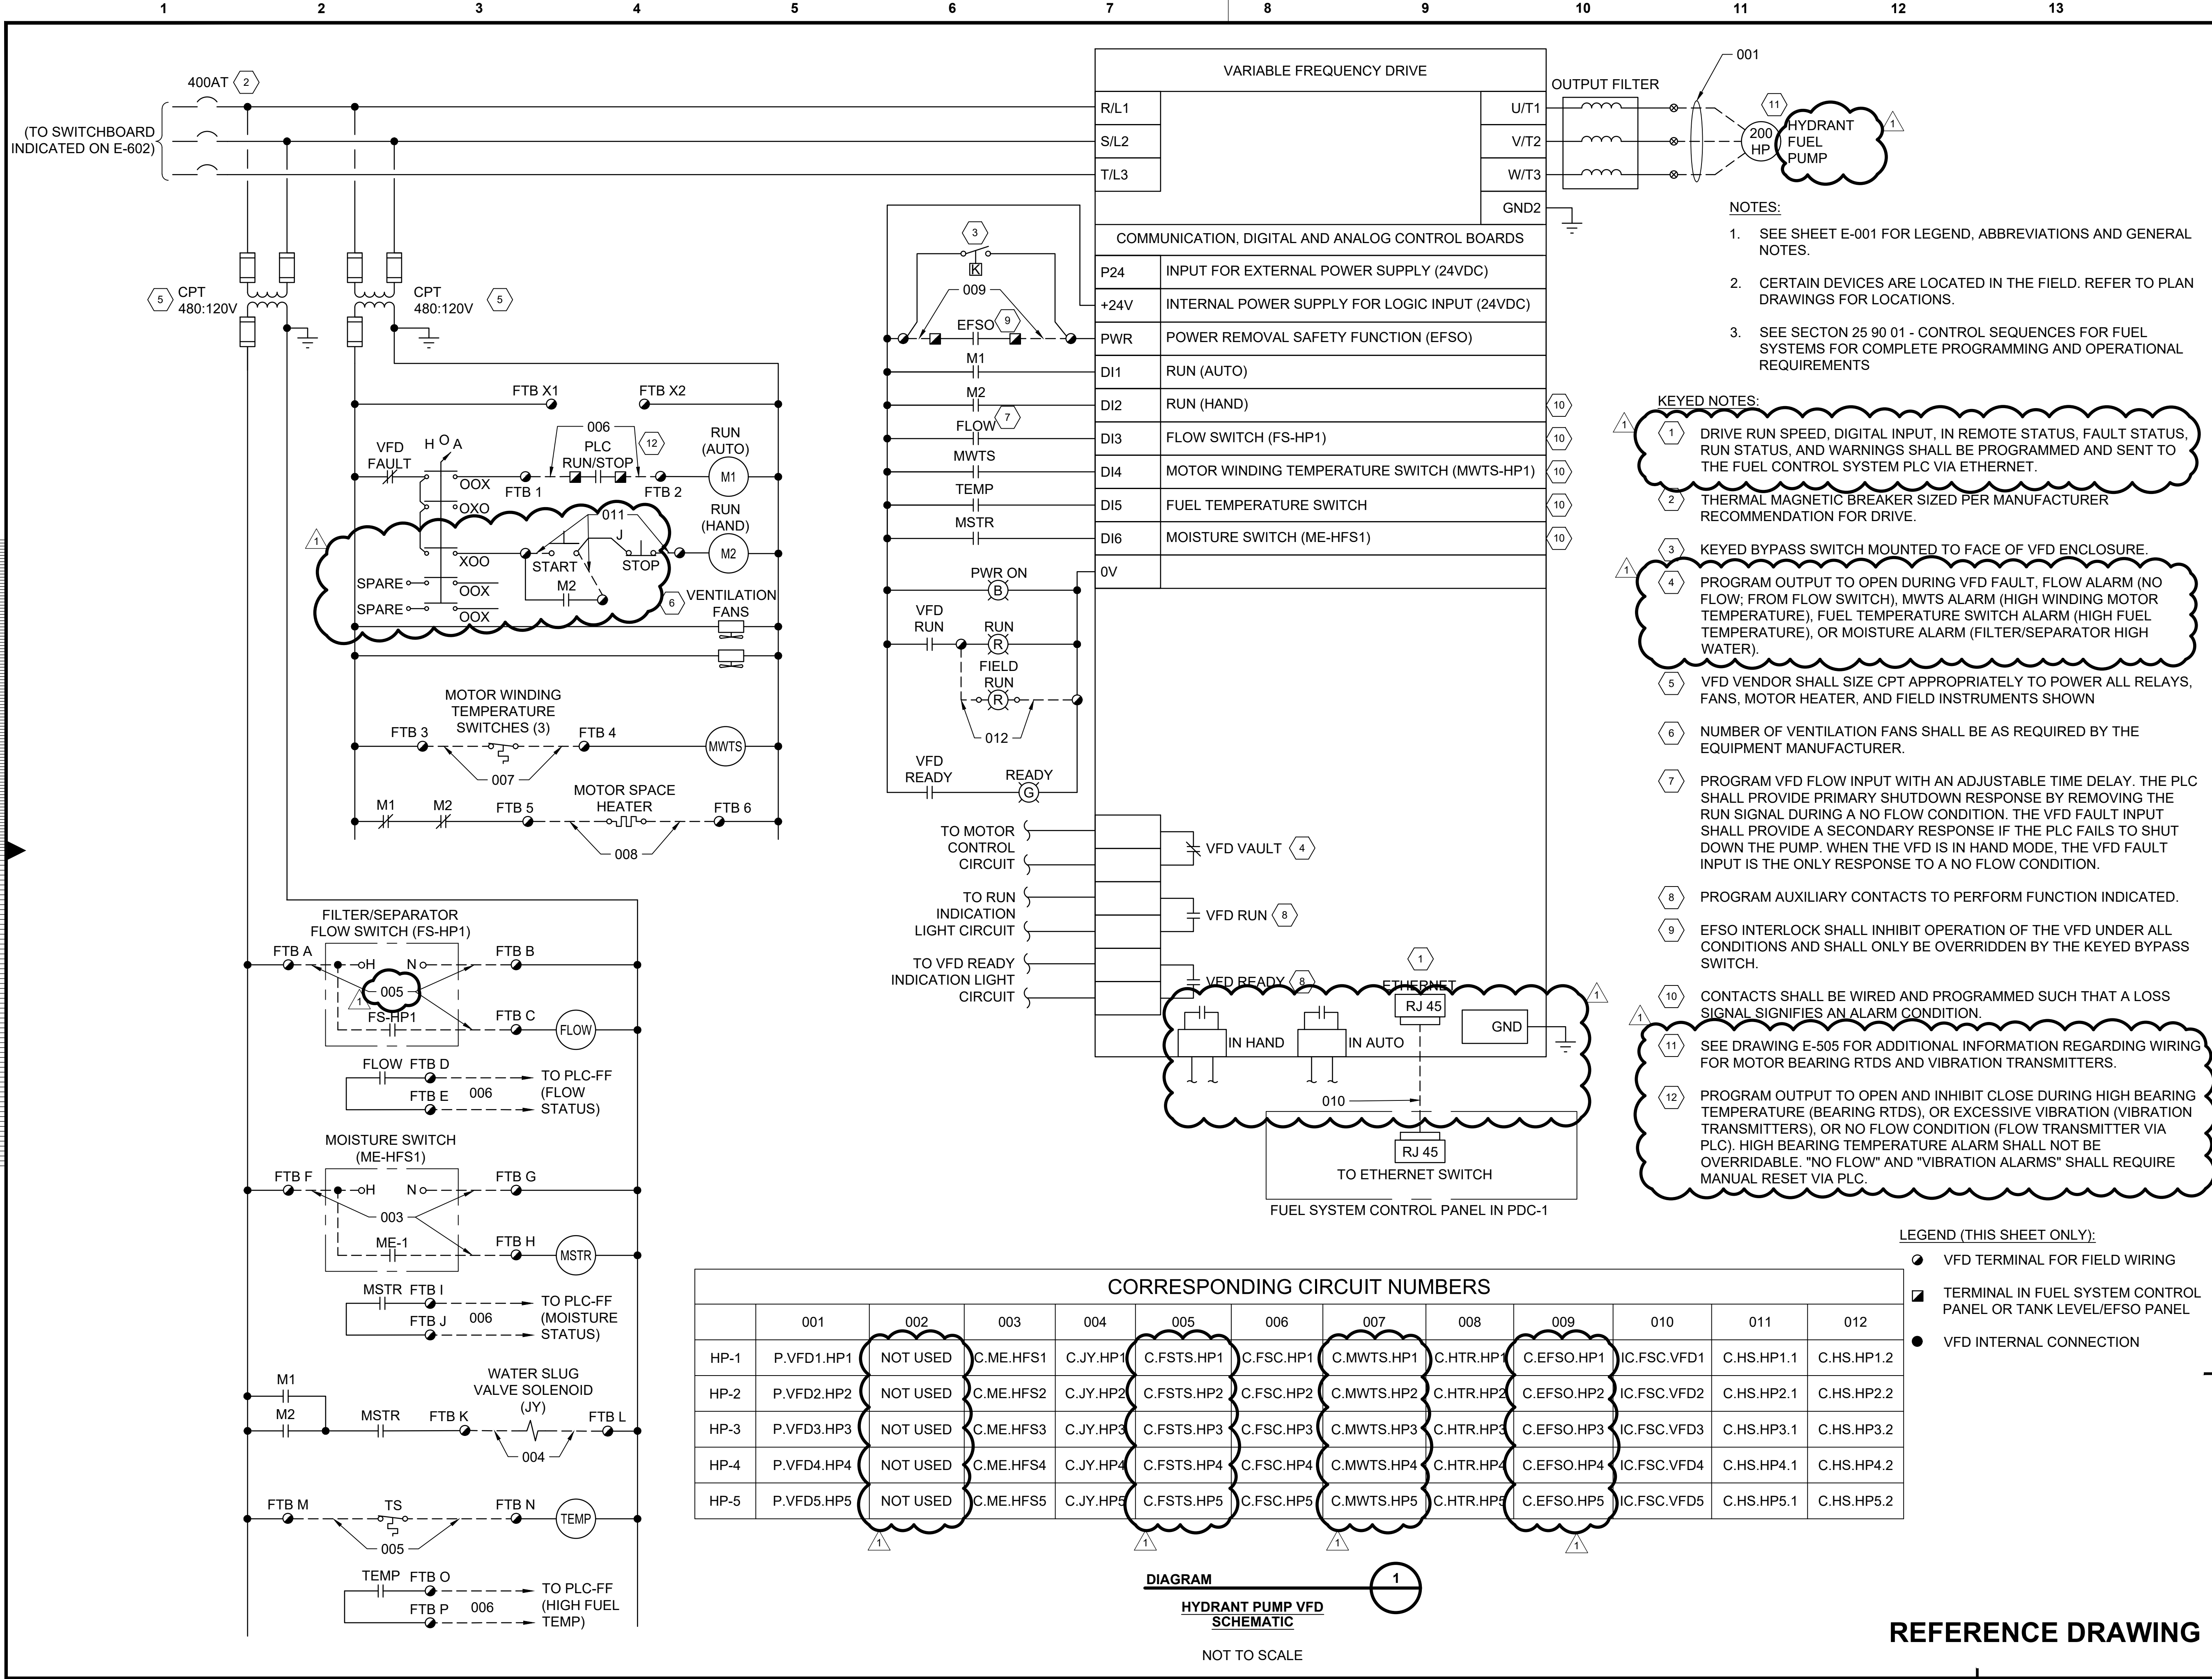

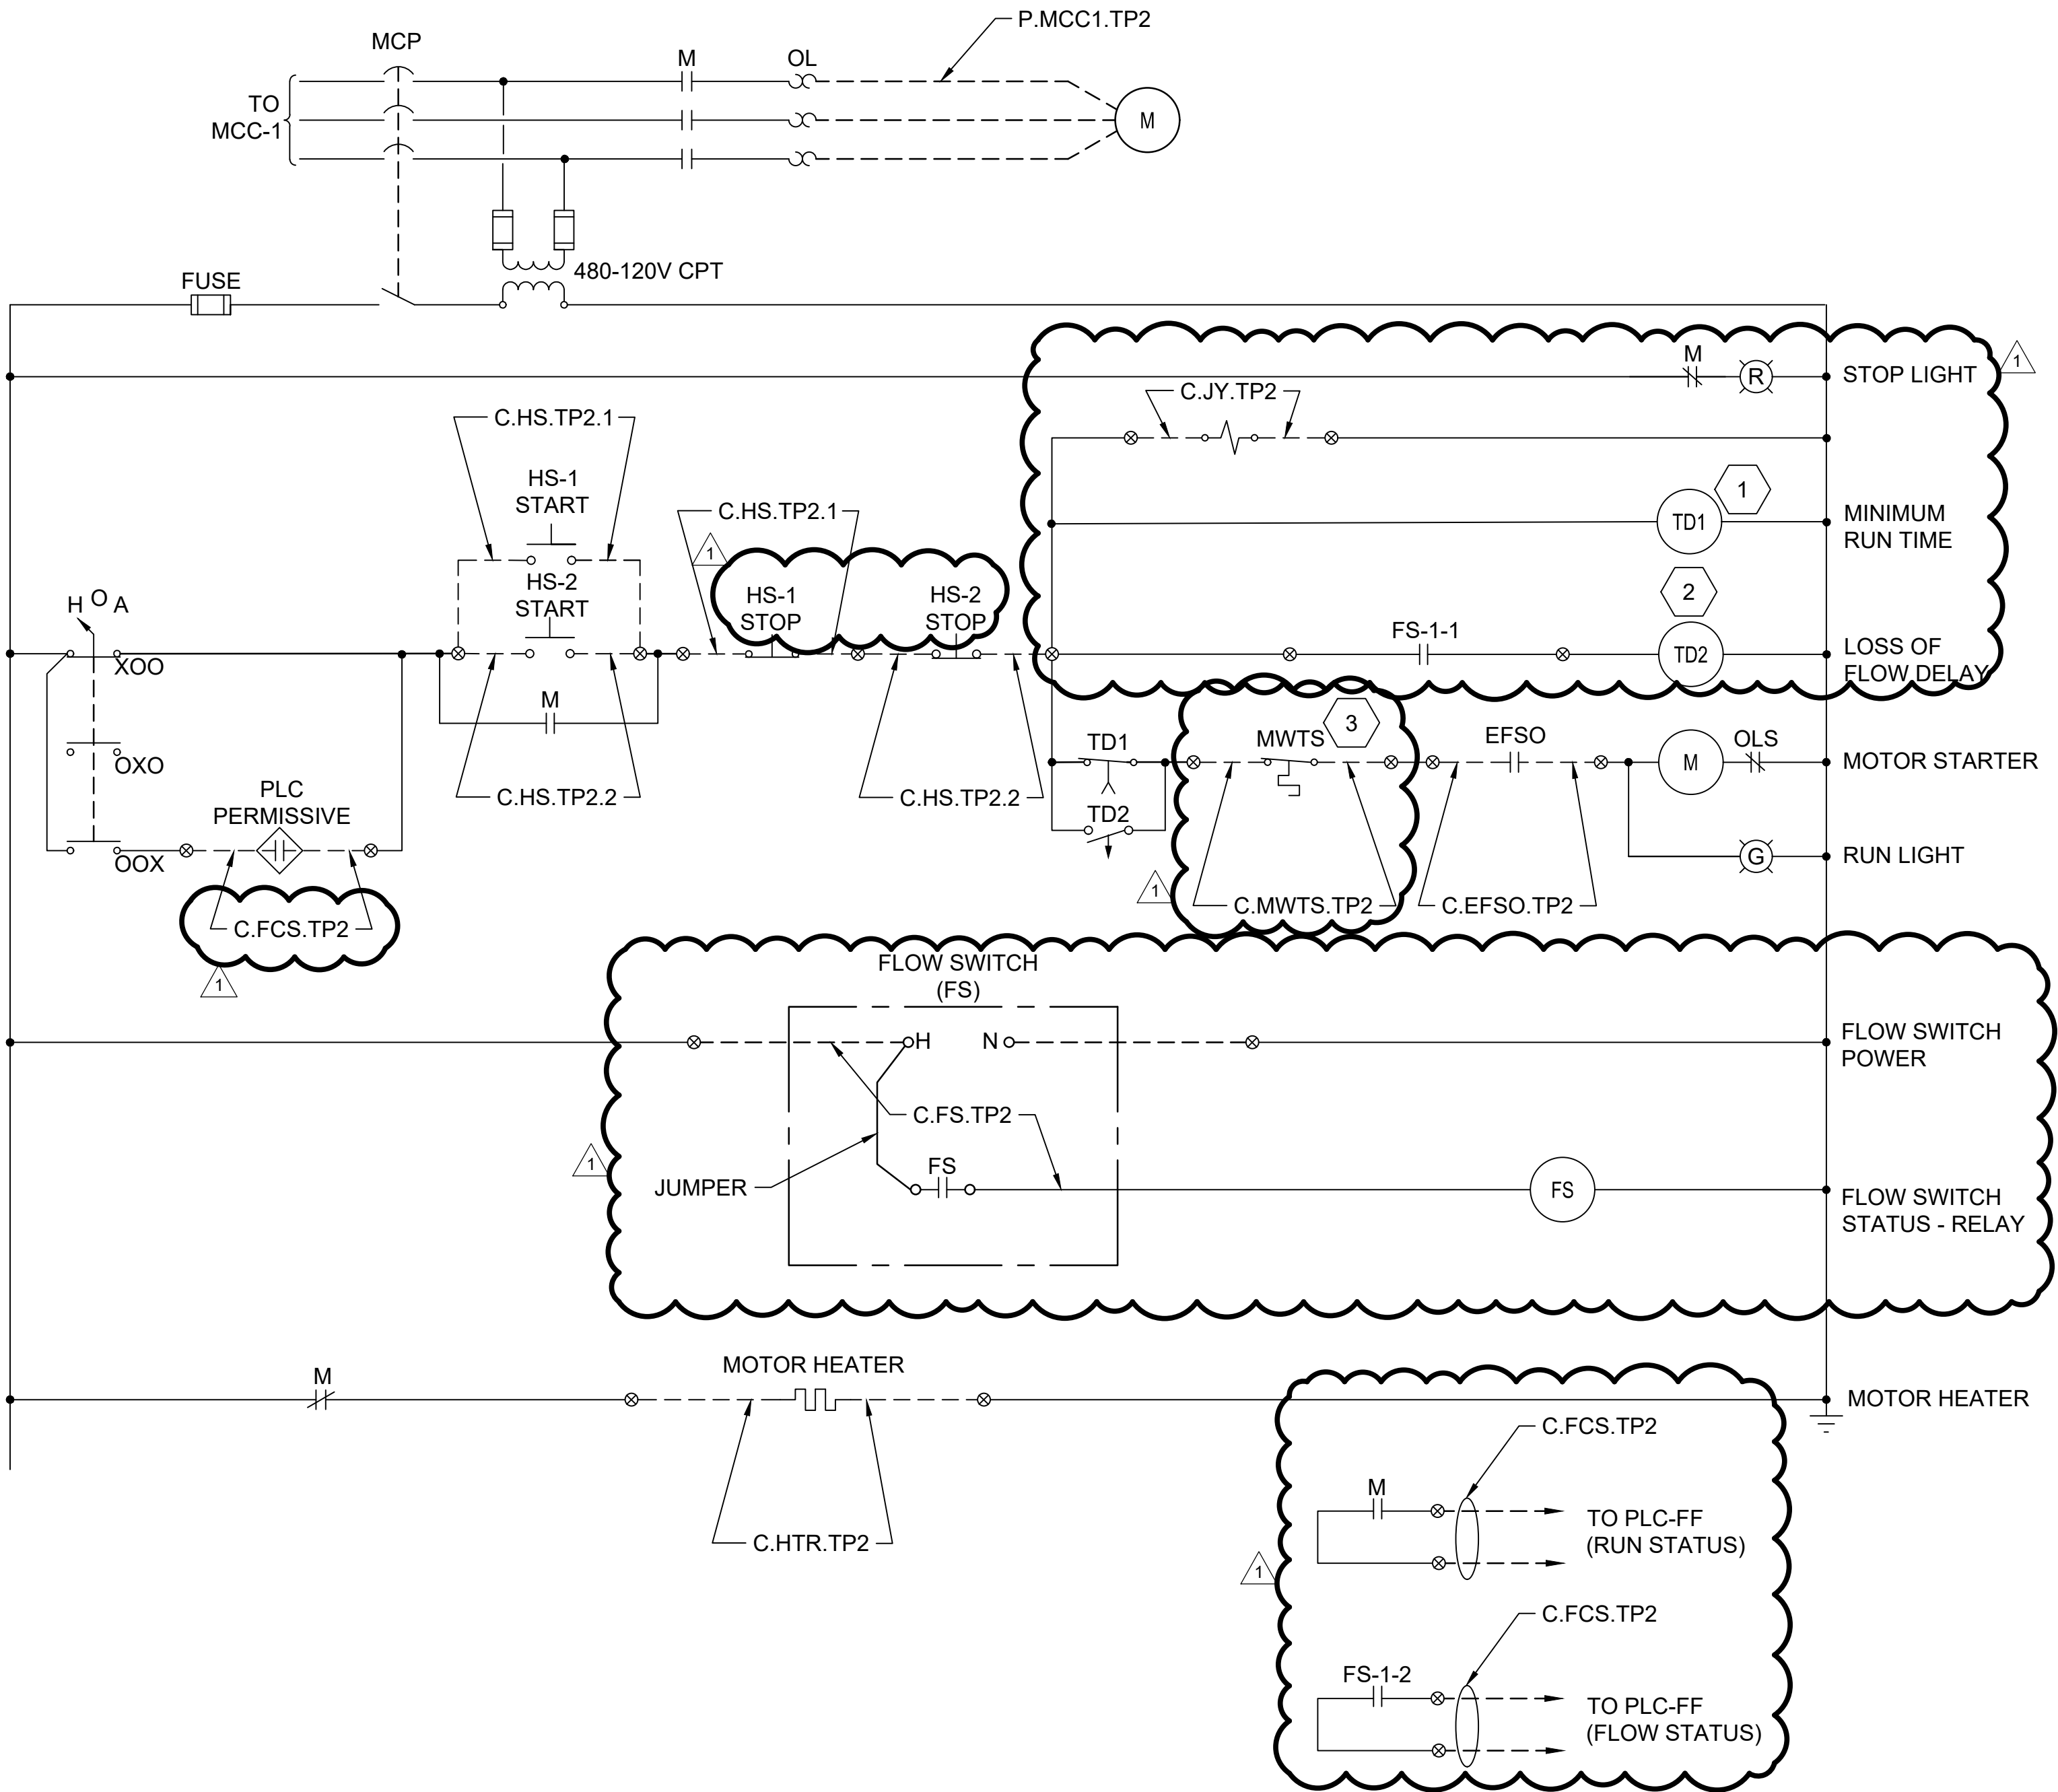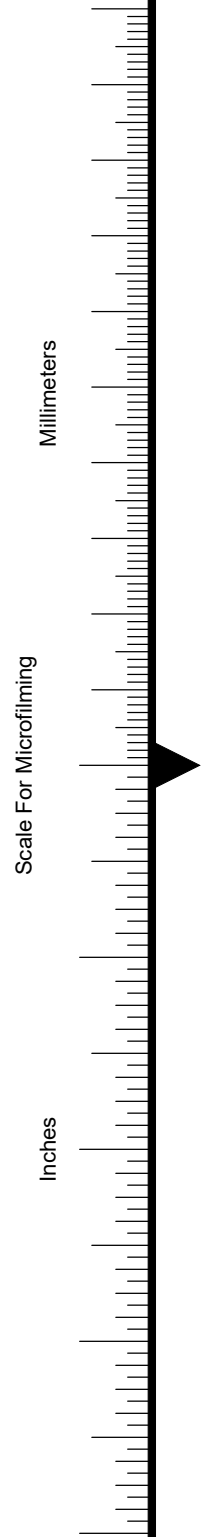

DETAIL 1
TRANSFER PUMP TP-2
WIRING DIAGRAM -
MOTOR CONTROLLER
NOT TO SCALE

- NOTES:**
- SEE SHEET E-001 FOR GENERAL NOTES, LEGEND AND ABBREVIATIONS.
 - CERTAIN DEVICES ARE LOCATED IN THE FIELD. REFER TO PLAN DRAWINGS FOR LOCATIONS.
 - SEE SECTION 25 90 01 - CONTROL SEQUENCES FOR FUEL SYSTEMS FOR COMPLETE PROGRAMMING AND OPERATIONAL REQUIREMENTS

- KEYED NOTES:**
- TD1 CONTACT SHALL BE NORMALLY CLOSED. DELAY TO OPEN WHEN TD1 RELAY IS ENERGIZED. DELAY SHALL BE ADJUSTABLE FROM 1-60 SECONDS. INITIAL SETTING SHALL BE 10 SECONDS, ADJUST AS NECESSARY.
 - TD2 CONTACT SHALL BE NORMALLY OPEN, CLOSES ON TD2 ENERGIZATION AND DELAY TO OPEN ON TD2 DE-ENERGIZATION. DELAY SHALL BE ADJUSTABLE FROM 1-60 SECONDS. INITIAL SETTING SHALL BE 5 SECONDS, ADJUST AS NECESSARY.
 - MOTOR WINDING TEMPERATURE SWITCH. WINDING TEMPERATURE SWITCH SHALL BE WIRED DIRECTLY BETWEEN THE TRANSFER PUMP AND THE MOTOR CONTROL BUCKET.

no.	date	by	ckd	description
0	11/13/20	DSW	TBR	ISSUED FOR CONSTRUCTION
1	10/11/22	DSW	CSB	ECN-001

date	10/11/2019	detailed	L. HURST
designed	E. WEIDEMAN	checked	Y. KHISLAVSKIY

PORTLAND INTERNATIONAL AIRPORT
5000 NE MARINE DR.
PORTLAND, OREGON 97218

TRANSFER PUMP SCHEMATIC	
project	contract
drawing	rev.
E-613	0
file 114425E-613.DWG	